

SMITHFIELD IRRIGATION COMPANY MILL RACE PRESSUREIZED PIPELINE PROJECT

SMITHFIELD, UT


2025

SMITHFIELD IRRIGATION COMPANY


Pat Draper President
Chris Chambers Vice President
Dennis Thornley Board Member
Lisa Peterson Board Member
Darin Evans Board Member
LuAnn Hansen Secretary
Lyle Coleman Water Master

ENGINEERING CONSULTANTS (SE)

Sunrise Engineering
Scott Archibald, P.E. Principal Engineer
Steven Wood, P.E. Project Manager
Haiming Peng, P.E. Project Engineer

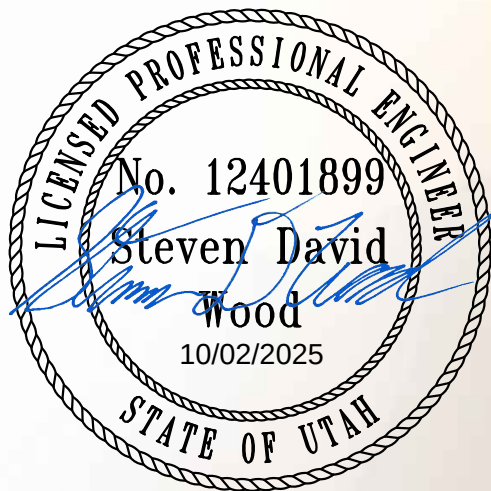


2100 NORTH MAIN STREET
NORTH LOGAN, UTAH 84341
TEL 435.563.3734
sunrise-eng.com

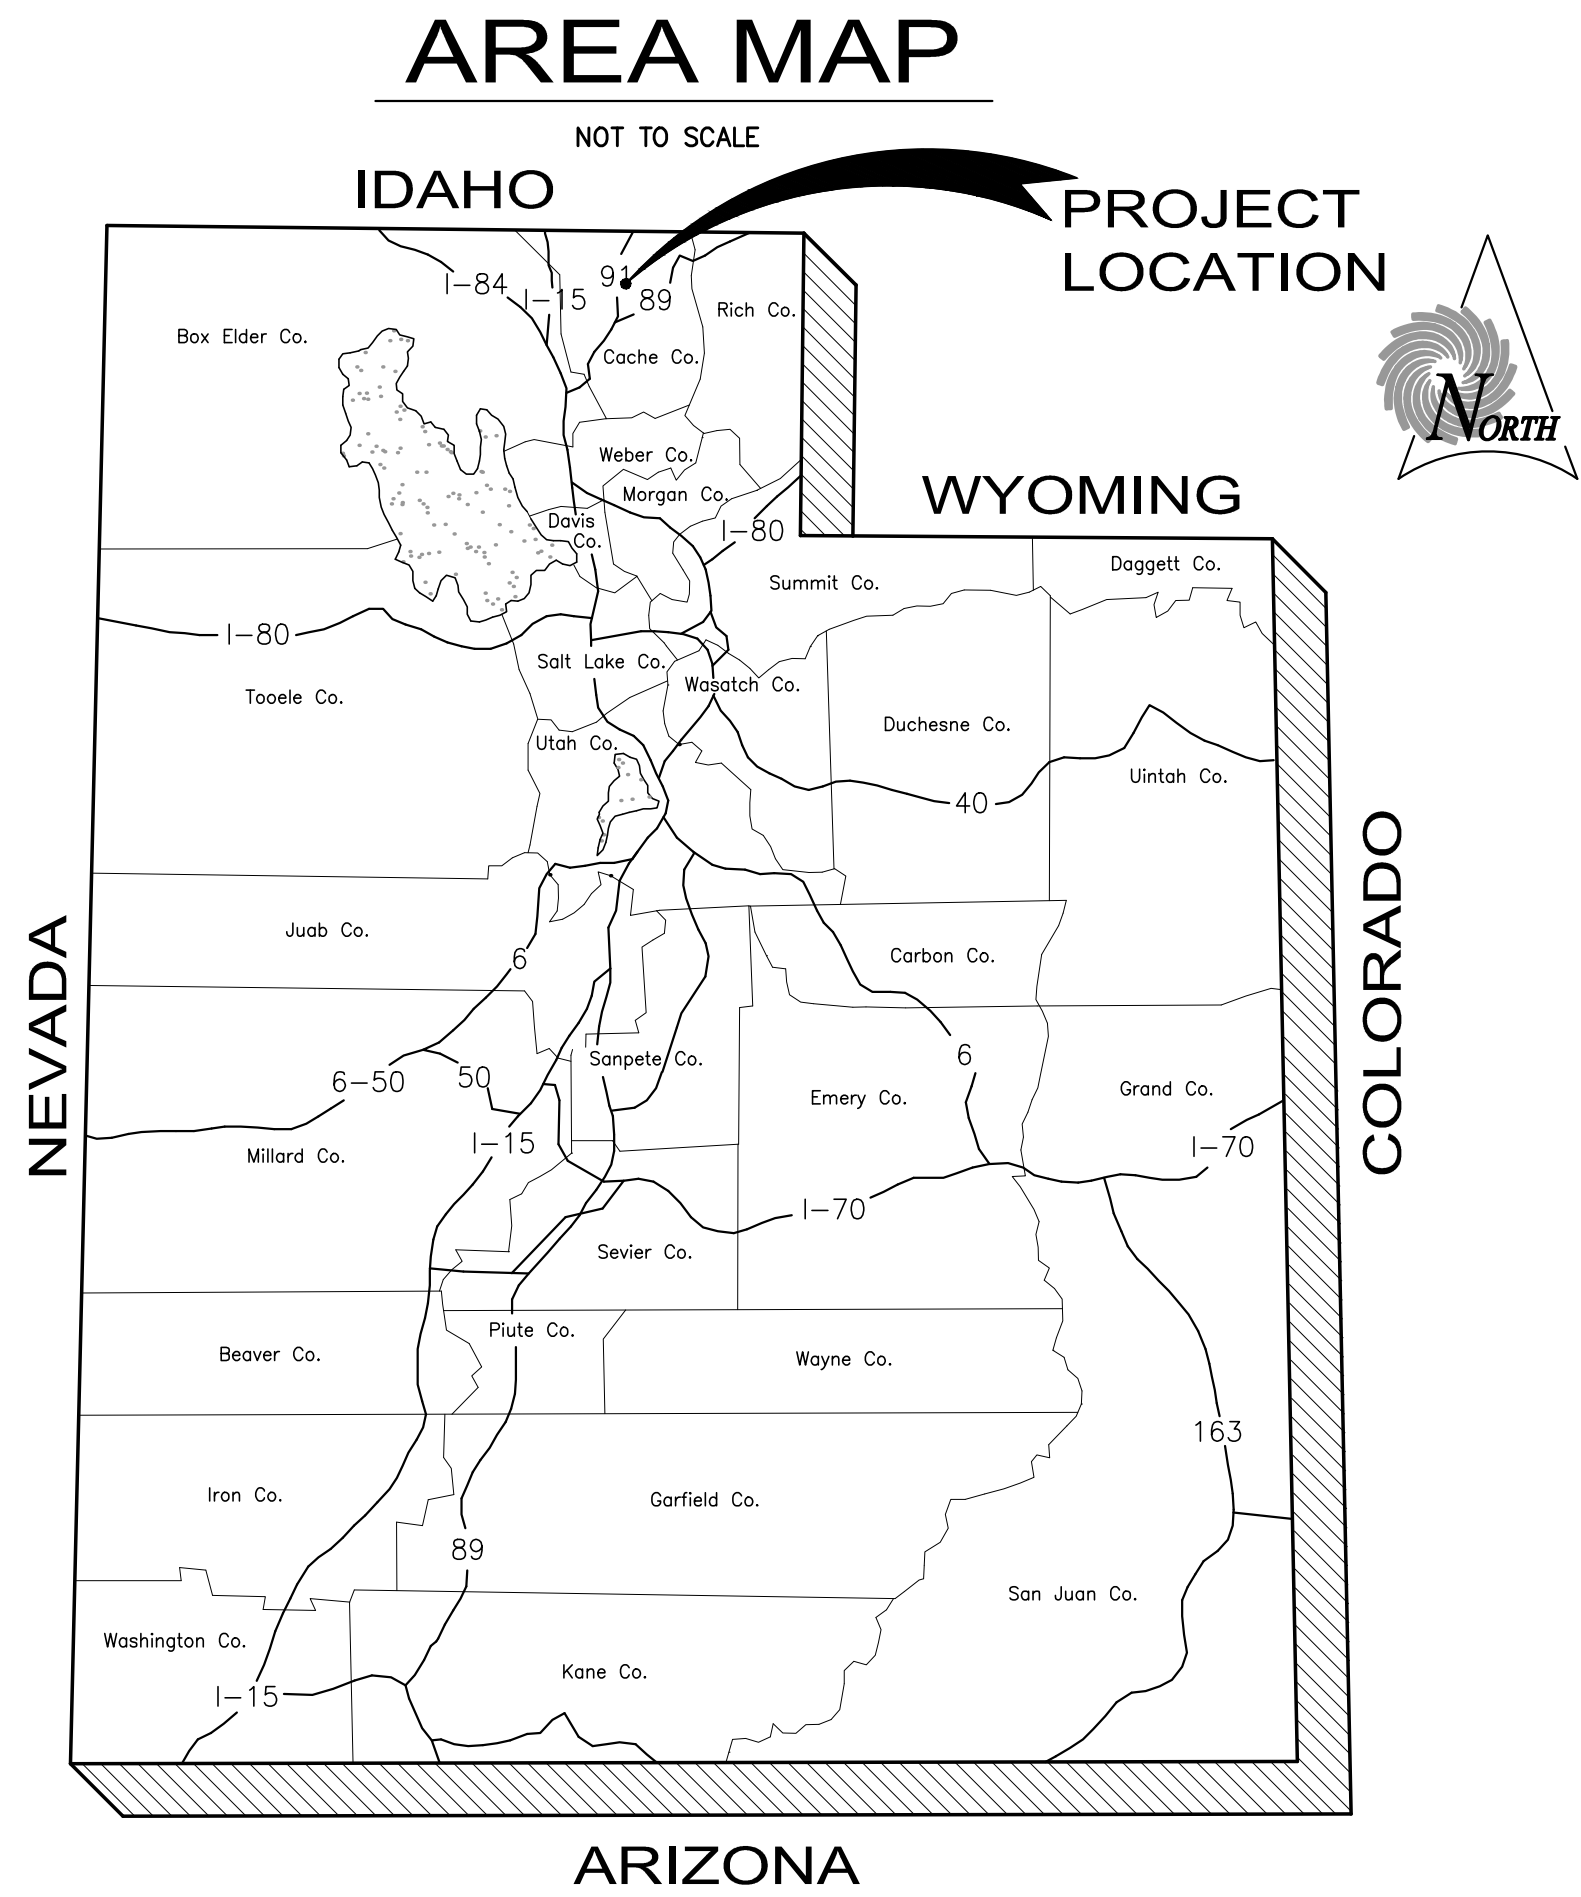

SHEET INDEX

1 - GENERAL:		
COVER SHEET	DWG. NO. GN1	SHEET NO. 1
AREA MAPS AND SHEET INDEX	GN2	2
NOTES, ABBREVIATIONS AND LEGEND	GN3	3
PROJECT OVERVIEW MAP AND INDEX	GN4	4
DESIGN CRITERIA	GN5	5
2 - PRESSURIZED PIPELINE:		
PLAN AND PROFILE	PP1-PP15	6-20
3 - DETAILS:		
PIPELINE DETAILS	D1-D2	21-22
PIPELINE AND SITE DETAILS	D3	23
PIPELINE IMPROVEMENTS	D4	24
EXISTING PUMP HOUSE REPLUMBING	D5	25
THRUST BLOCK DETAILS	D6	26

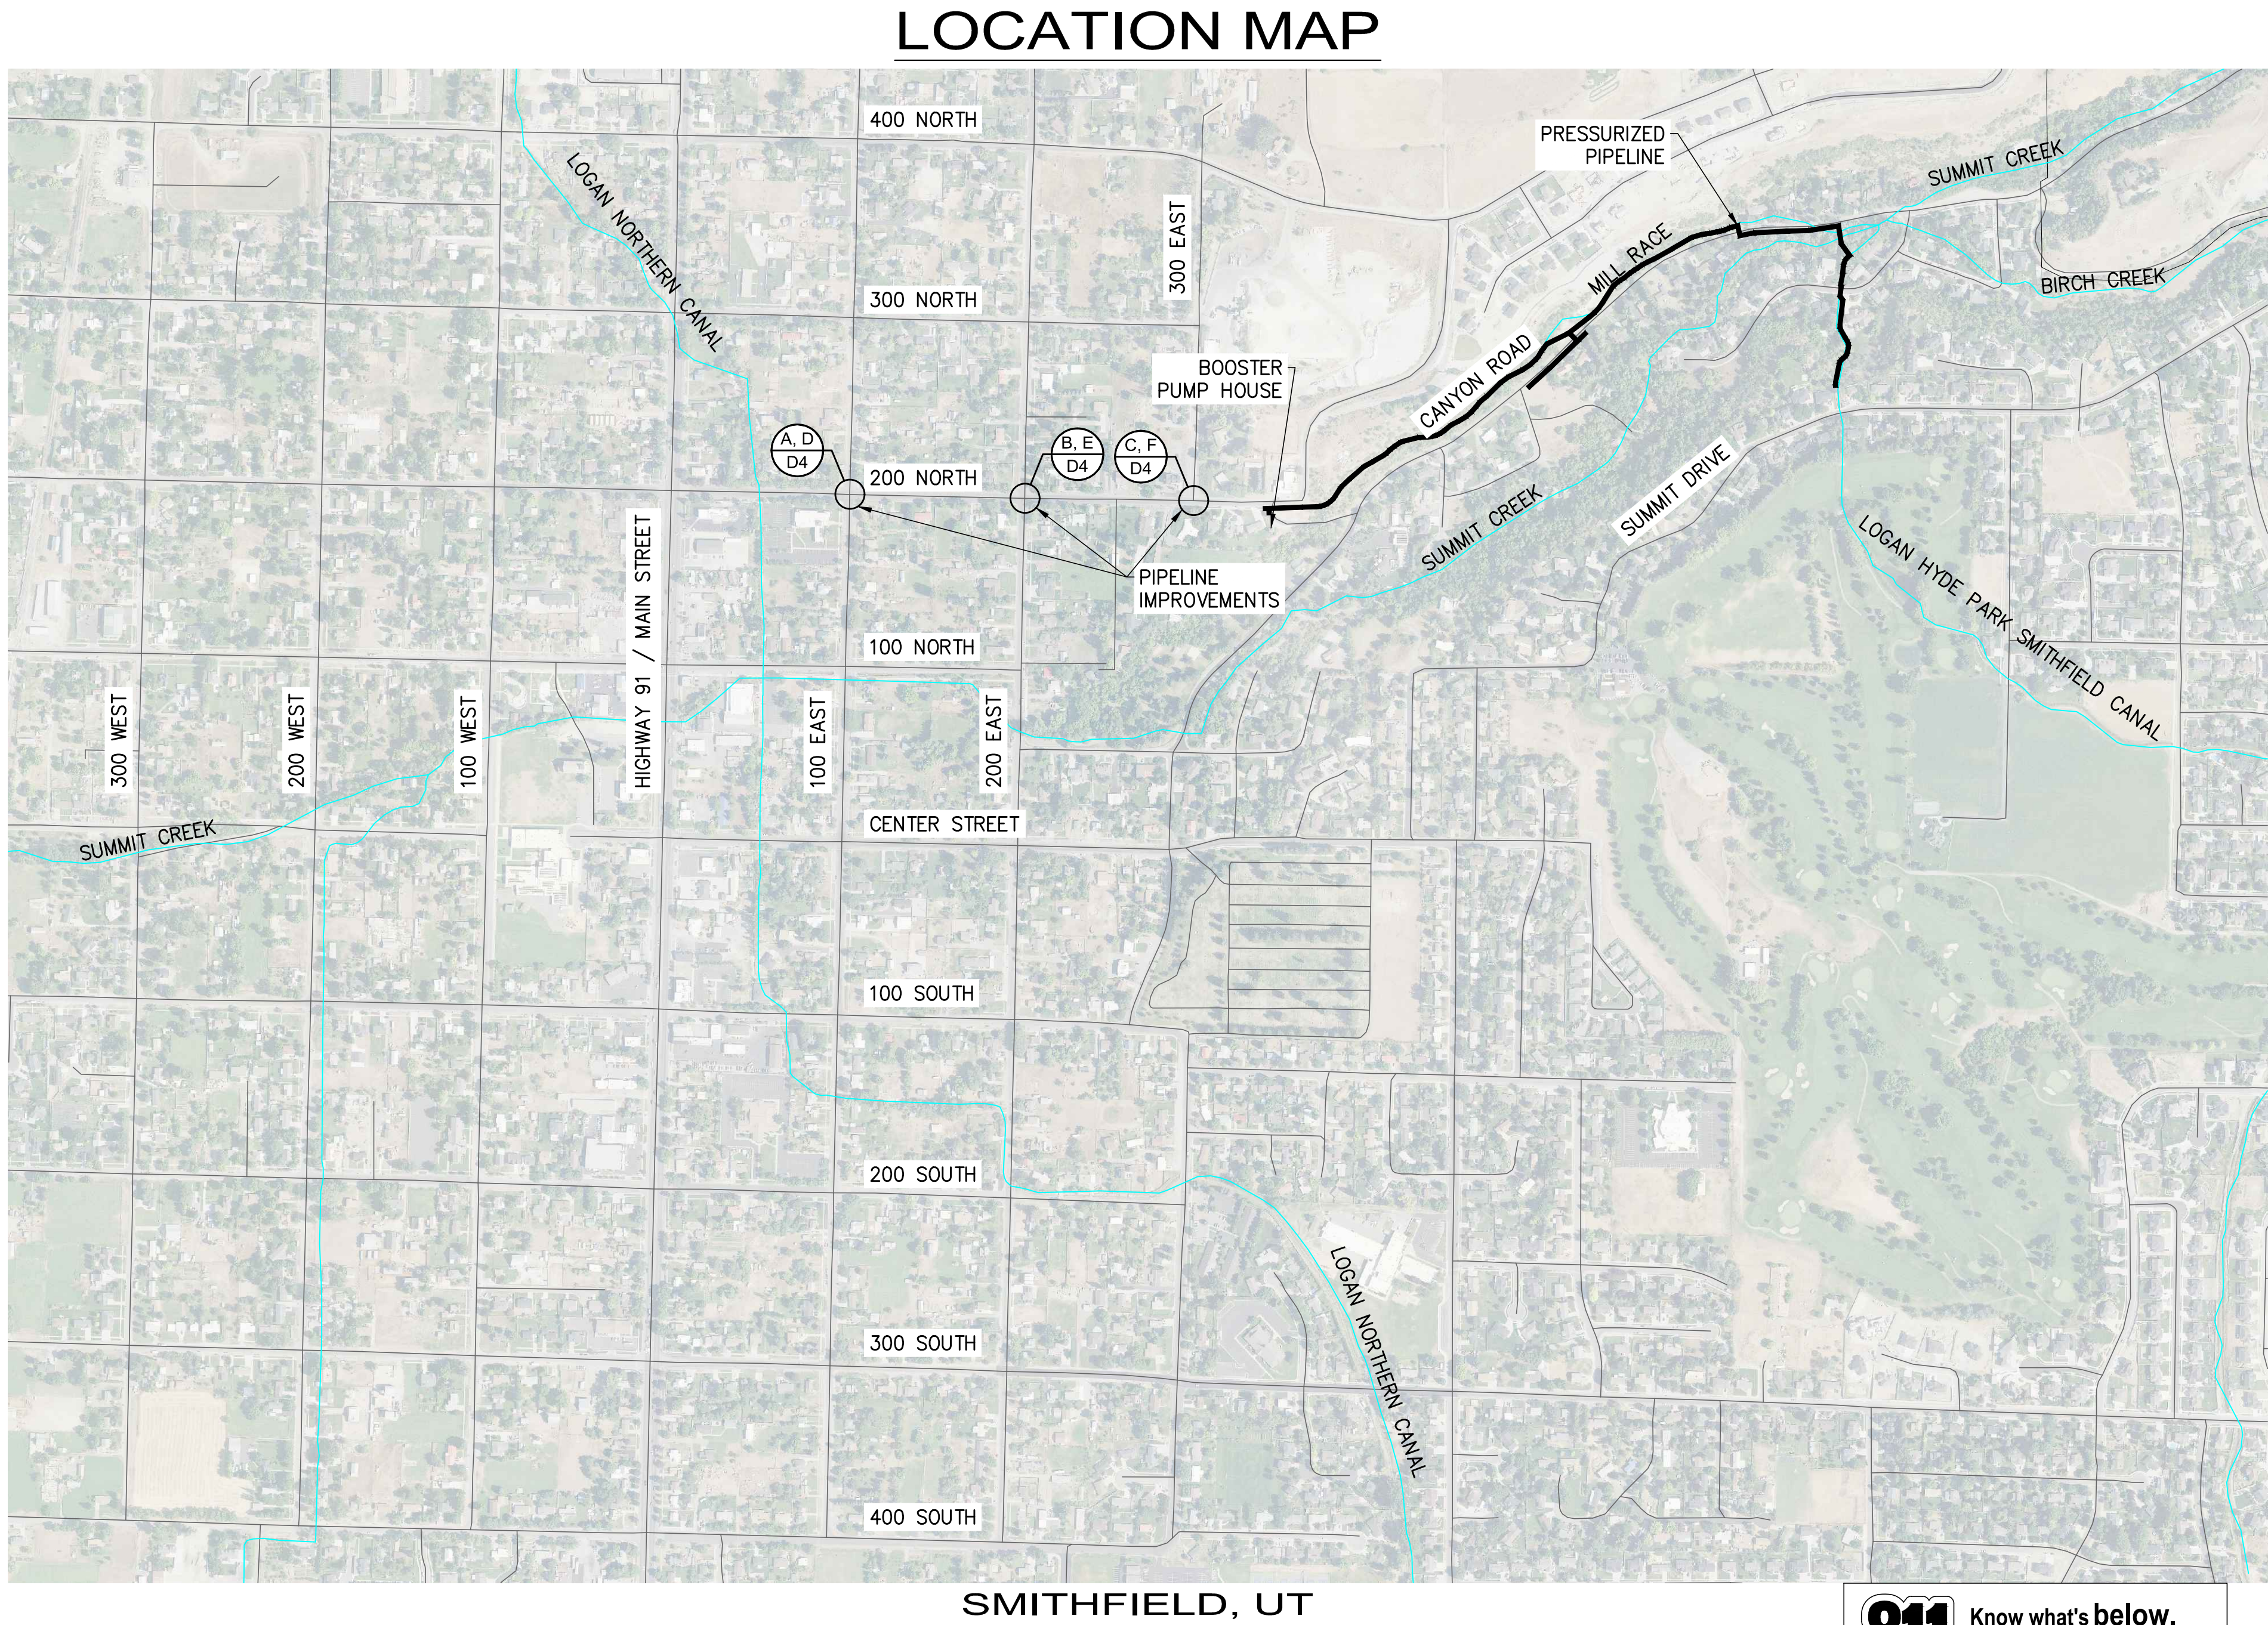

SMITHFIELD, UT






REV NO.		COMMENT		DATE	
</					

SE GENERAL NOTES

1. ALL SITE WORK SHALL CONFORM TO THE CURRENT EDITION OF THE AMERICAN PUBLIC WORKS ASSOCIATION UNIFORM STANDARD SPECIFICATIONS AND DETAILS (APWA SPECIFICATIONS AND DETAILS) AND ANY SUPPLEMENTS TO THE APWA SPECIFICATIONS AND DETAILS BY SMITHFIELD CITY UNLESS SPECIFICALLY STATED OTHERWISE IN THESE PLANS.
2. THE CONTRACTOR SHALL OBTAIN ALL NECESSARY PERMITS PRIOR TO BEGINNING CONSTRUCTION. THE CONTRACTOR IS RESPONSIBLE FOR VERIFICATION OF EXISTING PERMITS, RENEWAL OF LAPSED PERMITS, AND OBTAINING ANY NEW PERMITS, INCLUDING, BUT NOT LIMITED TO, DUST CONTROL PERMITS, ENCROACHMENT PERMITS, TRAFFIC CONTROL PERMITS, AND/OR UTAH POLLUTANT DISCHARGE ELIMINATE SYSTEM (UPDES) PERMITS.
3. THE CONTRACTOR IS RESPONSIBLE FOR MAKING ARRANGEMENTS FOR INSPECTION AND TESTING BY AN INDEPENDENT AND QUALIFIED LABORATORY.
4. THE CONTRACTOR SHALL NOTIFY SMITHFIELD IRRIGATION COMPANY 24 HOURS PRIOR TO CONSTRUCTION. CONSTRUCTION CONCEALED WITHOUT THE REQUIRED INSPECTION SHALL BE SUBJECT TO EXPOSURE AT THE CONTRACTOR'S EXPENSE.
5. THE CONTRACTOR IS RESPONSIBLE FOR LOCATING EXISTING UNDERGROUND UTILITIES PRIOR TO CONSTRUCTION. THE CONTRACTOR MUST CALL BLUE STAKE AT (800) 662-4111 AT LEAST 48 HOURS BEFORE ANY CONSTRUCTION BEGINS.
6. THE CONTRACTOR SHALL FOLLOW GUIDELINES AND REGULATIONS SET FORTH BY O.S.H.A. SUNRISE ENGINEERING, INC. WILL NOT BE RESPONSIBLE FOR JOB-SITE SAFETY PROCEDURES OR CONDITIONS.
7. THE CONTRACTOR IS RESPONSIBLE FOR HIS OWN TAKEOFF QUANTITIES. QUANTITIES IF SHOWN HEREON ARE ESTIMATES ONLY AND AS SUCH ARE NOT TO BE USED FOR BID PURPOSES.
8. THE CONTRACTOR IS RESPONSIBLE FOR THE NOTIFICATION OF THE PROPER AUTHORITY(S) IF THERE ARE OBSTRUCTIONS TO PROPOSED IMPROVEMENTS AS SHOWN ON THE CONSTRUCTION DRAWINGS. ANY EXISTING ITEM REMOVED TO FACILITATE CONSTRUCTION SHALL BE REPLACED IN THE SAME OR BETTER CONDITION AT THE CONTRACTOR'S EXPENSE.
9. THE CONTRACTOR SHALL COORDINATE WITH UTILITY COMPANIES FOR LOCATION OF SERVICE AND/OR RELOCATION OF UTILITIES IN CONFLICT WITH PROPOSED CONSTRUCTION. THE ENGINEER SHALL NOT BE RESPONSIBLE FOR COORDINATING THE RELOCATION OF UTILITIES, POWER POLES, ETC.
10. IT IS THE CONTRACTOR'S RESPONSIBILITY TO REMOVE AND SAFELY DISPOSE OF ALL REMOVAL MATERIAL AND DEBRIS DEEMED UNSALVAGEABLE BY ENGINEER. THE CONTRACTOR SHALL MAKE APPROPRIATE ARRANGEMENTS FOR DISPOSAL SITES AT WHICH DEBRIS MAY BE LAWFULLY DISPOSED. NO CONSTRUCTION DEBRIS WILL BE BURIED IN THE PIPELINE TRENCH.
11. THE CONTRACTOR IS RESPONSIBLE FOR TRAFFIC CONTROL ON AND AROUND THE CONSTRUCTION SITE IN ACCORDANCE WITH THE MANUAL ON UNIFORM TRAFFIC CONTROL DEVICES FOR STREETS AND HIGHWAYS.
12. THE CONTRACTOR SHALL PROVIDE ADEQUATE MEANS FOR CLEANING TRUCKS AND/OR OTHER EQUIPMENT OF MUD PRIOR TO ENTERING PUBLIC STREETS, AND IT IS THE CONTRACTOR'S RESPONSIBILITY TO CLEAN STREETS, AND TAKE WHATEVER MEASURES ARE NECESSARY TO INSURE THAT ALL ROADS ARE MAINTAINED IN A CLEAN, MUD AND DUST FREE CONDITION AT ALL TIMES. NO WORK WILL BE CONSIDERED COMPLETE UNTIL ALL PAVEMENTS HAVE BEEN SWEEPED CLEAN OF DIRT AND DEBRIS.
13. A THOROUGH ATTEMPT HAS BEEN MADE TO SHOW THE LOCATIONS OF ALL UNDERGROUND OBSTRUCTIONS AND UTILITY LINES IN THE WORK AREA. HOWEVER, THE CONTRACTOR SHALL BE RESPONSIBLE FOR ANY DAMAGE TO OBSTRUCTIONS AND UTILITY LINES ENCOUNTERED DURING CONSTRUCTION AND SHALL DETERMINE THE EXACT LOCATION OF UTILITIES IN ADVANCE OF TRENCHING. THE ENGINEER WILL NOT GUARANTEE ANY ELEVATIONS AT LOCATIONS OF THE EXISTING UNDERGROUND UTILITIES SHOWN ON THESE PLANS.
14. THE CONTRACTOR SHALL PROVIDE A LICENSED SURVEYOR FOR THE SURVEYING/CONSTRUCTION STAKING OF ALIGNMENT AND GRADE FOR EACH MAIN AND/OR FACILITY AS SHOWN ON THE PLANS.
15. EXACT POINT OF MATCHING, TERMINATION AND OVERLAY, IF NECESSARY, MAY BE DETERMINED IN THE FIELD BY THE ENGINEER OF RECORD OR THE RESIDENT ENGINEER OVERSEEING THE PROJECT CONSTRUCTION.
16. ANY AMBIGUITIES OR DEFICIENCIES DISCOVERED ON THESE PLANS ARE TO BE RESOLVED BY SUNRISE ENGINEERING OR ITS APPOINTED REPRESENTATIVE. ANY MODIFICATIONS TO THESE PLANS MADE BY ANYONE OTHER THAN SUNRISE ENGINEERING OR ITS APPOINTED REPRESENTATIVE IS SOLELY RESPONSIBLE FOR THOSE MODIFICATIONS.
17. THE CONTRACTOR SHALL NOT REMOVE, TRIM, OR OTHERWISE CUT ANY TREES WITHOUT WRITTEN APPROVAL FROM SMITHFIELD CITY IN RIGHT-OF-WAY AREAS
18. WHEN REMOVING BRANCHES FROM TREES, THE BRANCH IS TO BE CUT WITH A CLEAN (BLEACHED) SAW BLADE AT THE POINT OF CONNECTION OF THE BRANCH TO A PRIMARY BRANCH OR TRUNK

ABC
AC
BCF
BCHH
BCR
BM
BSW
BTM
CB
C/L
CMP
CO
CONC
CONST
CY
DI
D/W
DWG
DTL
E
ECR
ELEV
EP
ESMT
EX, EXIST
EG
FC
FES
FF
FG
FH
FL
FND
FO
FPS
FSW
FT
G
GB
GPM
HDPE
HP
HW
IN
INV
IRR, IRRIG
LF
LT
MH
MJ
N
NA
NIC
NO.
OHE
OPNG
P/L
PC
PCC
PCC
PRC
PT
PUE
PVC
PVI
R
R/W
RGRCP
RJ
RT
S
SDMH
SF
SSMH
STA
STD
SWK
SY
TAN
TBC
T, TEL
TL
TOC
TOW
TYP
UGE
UPRR
VNAE
Vr
Vp
W
XFMR

   ABBREVIATIONS

AGGREGATE BASE COURSE	
ASPHALT CONCRETE	
BRASS CAP FLUSH	
BRASS CAP IN HAND HOLE	
BEGIN CURB RETURN	
BENCHMARK	
BACK OF SIDEWALK	
BOTTOM	
CATCH BASIN	
CENTERLINE	
CORRUGATED METAL PIPE	
CLEAN OUT	
CONCRETE	
CONSTRUCTION	
CUBIC YARD	
DUCTILE IRON	
DRIVEWAY	
DRAWING	
DETAIL	
EAST	
END CURB RETURN	
ELEVATION	
EDGE OF PAVEMENT	
EASEMENT	
EXISTING	
EXISTING GROUND	
FACE OF CURB	
FLARED END SECTION	
FINISHED FLOOR	
FINISHED GRADE	
FIRE HYDRANT	
FLANGE	
FOUND	
FIBER OPTIC	
FEET PER SECOND	
FRONT OF SIDEWALK	
FOOT, FEET	
GAS, GUTTER, GRADE	
GRADE BREAK	
GALLONS PER MINUTE	
HIGH DENSITY POLYETHYLENE PIPE	
HIGH POINT	
HIGHWATER	
INCH, INCHES	
INVERT	
IRRIGATION	
LENGTH	
LINEAR FEET	
LEFT	
MANHOLE	
MECHANICAL JOINT	
NORTH	
NOT APPLICABLE	
NOT IN CONTRACT	
NUMBER	
OVERHEAD ELECTRIC	
OPENING	
PROPERTY LINE	
POINT OF CURVATURE	
POINT OF COMPOUND CURVE	
PORTLAND CEMENT CONCRETE	
POINT OF REVERSE CURVE	
POINT OF TANGENCY	
PUBLIC UTILITY EASEMENT	
POLYVINYL CHLORIDE	
POINT OF VERTICAL INTERSECTION	
RADIUS	
RIGHT-OF-WAY	
RUBBER GASKETED REINFORCED CONCRETE PIPE	
RESTRAINED JOINT	
RIGHT	
SEWER, SLOPE, SOUTH	
STORM DRAIN MANHOLE	
SQUARE FEET	
SANITARY SEWER MANHOLE	
STATION	
STANDARD	
SIDEWALK	
SQUARE YARD	
TANGENT	
TOP BACK OF CURB	
TELEPHONE	
TRUE LENGTH	
TOP OF CONCRETE	
TOP OF WALL	
TYPICAL	
UNDERGROUND ELECTRIC	
UNION PACIFIC RAILROAD	
VEHICLE NON-ACCESS EASEMENT	
VOLUME REQUIRED	
VOLUME PROVIDED	
WATER, WEST, WITH	
TRANSFORMER	

EXISTING


	EXISTING CONCRETE
	EXISTING PAVEMENT TO BE REMOVED
	EXISTING PAVEMENT TO REMAIN
	EXISTING IRRIGATION LINE
	EXISTING SEWER LINE
	EXISTING STORM DRAIN
	EXISTING WATER LINE
	EXISTING OVERHEAD ELECTRIC
	EXISTING UNDERGROUND ELECTRIC
	EXISTING CABLE (TV) LINE
	EXISTING FIBER OPTIC LINE
	EXISTING UNDERGROUND TELEPHONE
	EXISTING GAS LINE
	EXISTING BARBED WIRE FENCE
	EXISTING EASEMENT
	EXISTING FLOWLINE
	EXISTING PROPERTY LINE
	EXISTING SPOT ELEVATION
	EXISTING CONTOUR
	EXISTING BRASS CAP MONUMENT
	EXISTING SIGN
	EXISTING IRRIGATION MANHOLE
	EXISTING IRRIGATION VALVE
	EXISTING DRYWELL
	EXISTING SEWER CLEANOUT
	EXISTING SEWER MANHOLE
	EXISTING CATCH BASIN
	EXISTING STORM DRAIN MANHOLE
	EXISTING STORM DRAIN W/ STRUCTURE
	EXISTING AIR VAC
	EXISTING FIRE HYDRANT
	EXISTING UNKNOWN MANHOLE
	EXISTING GATE VALVE
	EXISTING REDUCER
CONCRETE PIPE	EXISTING WATER MANHOLE (OR WELL)
	EXISTING WATER METER
	EXISTING CABLE MANHOLE
	EXISTING ELECTRIC MANHOLE
	EXISTING GUY WIRE
	EXISTING LIGHT POLE
	EXISTING POWER POLE
	EXISTING TELEPHONE MANHOLE
	EXISTING TELEPHONE PEDESTAL
	EXISTING GAS MANHOLE
	EXISTING GAS METER
	EXISTING GAS RISER
	EXISTING GAS VALVE
	EXISTING VEGETATION

LEGEND

PROPOSED


	PROPOSED CONCRETE
	PROPOSED PAVEMENT
	EXISTING IRRIGATION LINE
	PROPOSED SEWER LINE
	PROPOSED STORM DRAIN
	PROPOSED WATER LINE
	PROPOSED OVERHEAD ELECTRIC
	PROPOSED UNDERGROUND ELECTRIC
	PROPOSED CABLE (TV) LINE
	PROPOSED FIBER OPTIC LINE
	PROPOSED UNDERGROUND TELEPHONE
	PROPOSED GAS LINE
	PROPOSED BARBED WIRE FENCE
	PROPOSED EASEMENT
	PROPOSED FLOWLINE
	PROPOSED PROPERTY LINE
	PROPOSED SPOT ELEVATION
	PROPOSED CONTOUR
	PROPOSED (PLACED) BRASS CAP MONUMENT
	PROPOSED SIGN
	PROPOSED IRRIGATION MANHOLE
	PROPOSED IRRIGATION VALVE
	PROPOSED DRYWELL
	PROPOSED SEWER CLEANOUT
	PROPOSED SEWER MANHOLE
	PROPOSED CATCH BASIN
	PROPOSED STORM DRAIN MANHOLE
	PROPOSED STORM DRAIN W/ STRUCTURE
	PROPOSED AIR VAC
	PROPOSED FIRE HYDRANT
	PROPOSED FITTINGS
	PROPOSED GATE VALVE
	PROPOSED REDUCER
	PROPOSED WATER MANHOLE (OR WELL)
	PROPOSED WATER METER
	PROPOSED CABLE MANHOLE
	PROPOSED ELECTRIC MANHOLE
	PROPOSED GUY WIRE
	PROPOSED LIGHT POLE
	PROPOSED POWER POLE
	PROPOSED TELEPHONE MANHOLE
	PROPOSED GAS MANHOLE
	PROPOSED GAS METER
	PROPOSED GAS RISER
	PROPOSED GAS VALVE
	PROPOSED VEGETATION

 OTHER

	GRADE BREAK
	HIGH WATERLINE
	LOT LINE
	RIGHT-OF-WAY
	ROADWAY CENTERLINE
	SECTION LINE
	SETBACK LINE
	CONSTRUCTION LIMITS
	POINT OF VERTICAL INTERSECTION
	PLAN, SECTION, OR DETAIL LABEL
	DRAWING TITLE/SHEET NUMBER
	TBC ELEVATION (x1000')
	LOT ELEVATION (x1000')
	BASIN ULTIMATE OUTFALL LOCATION AND DIRECTION
	GRADE BREAK (PROFILE SYMBOL)

811 Know what's below.
Call before you dig.
1-800-662-4111

REV NO.
COMMENT
DATE

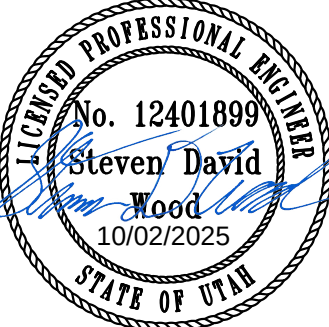



SUNRISE ENGINEERING

2100 NORTH MAIN STREET
NORTH LOGAN, UTAH 84341
TEL 435.563.3734
www.sunrise-eng.com



SMITHFIELD IRRIGATION COMPANY

MILL RACE PRESSURIZED PIPELINE

GENERAL

NOTES, ABBREVIATIONS, AND LEGEND

SET NO. 12499	DESIGNED HP	DRAWN JJ	CHECKED SDW	SHEET NO. 3 of 26	GN3
------------------	----------------	-------------	----------------	----------------------	-----

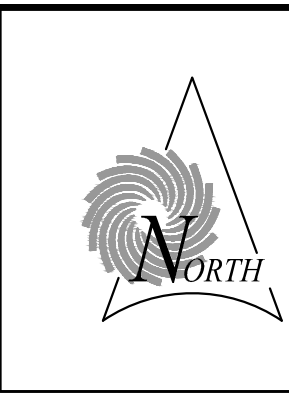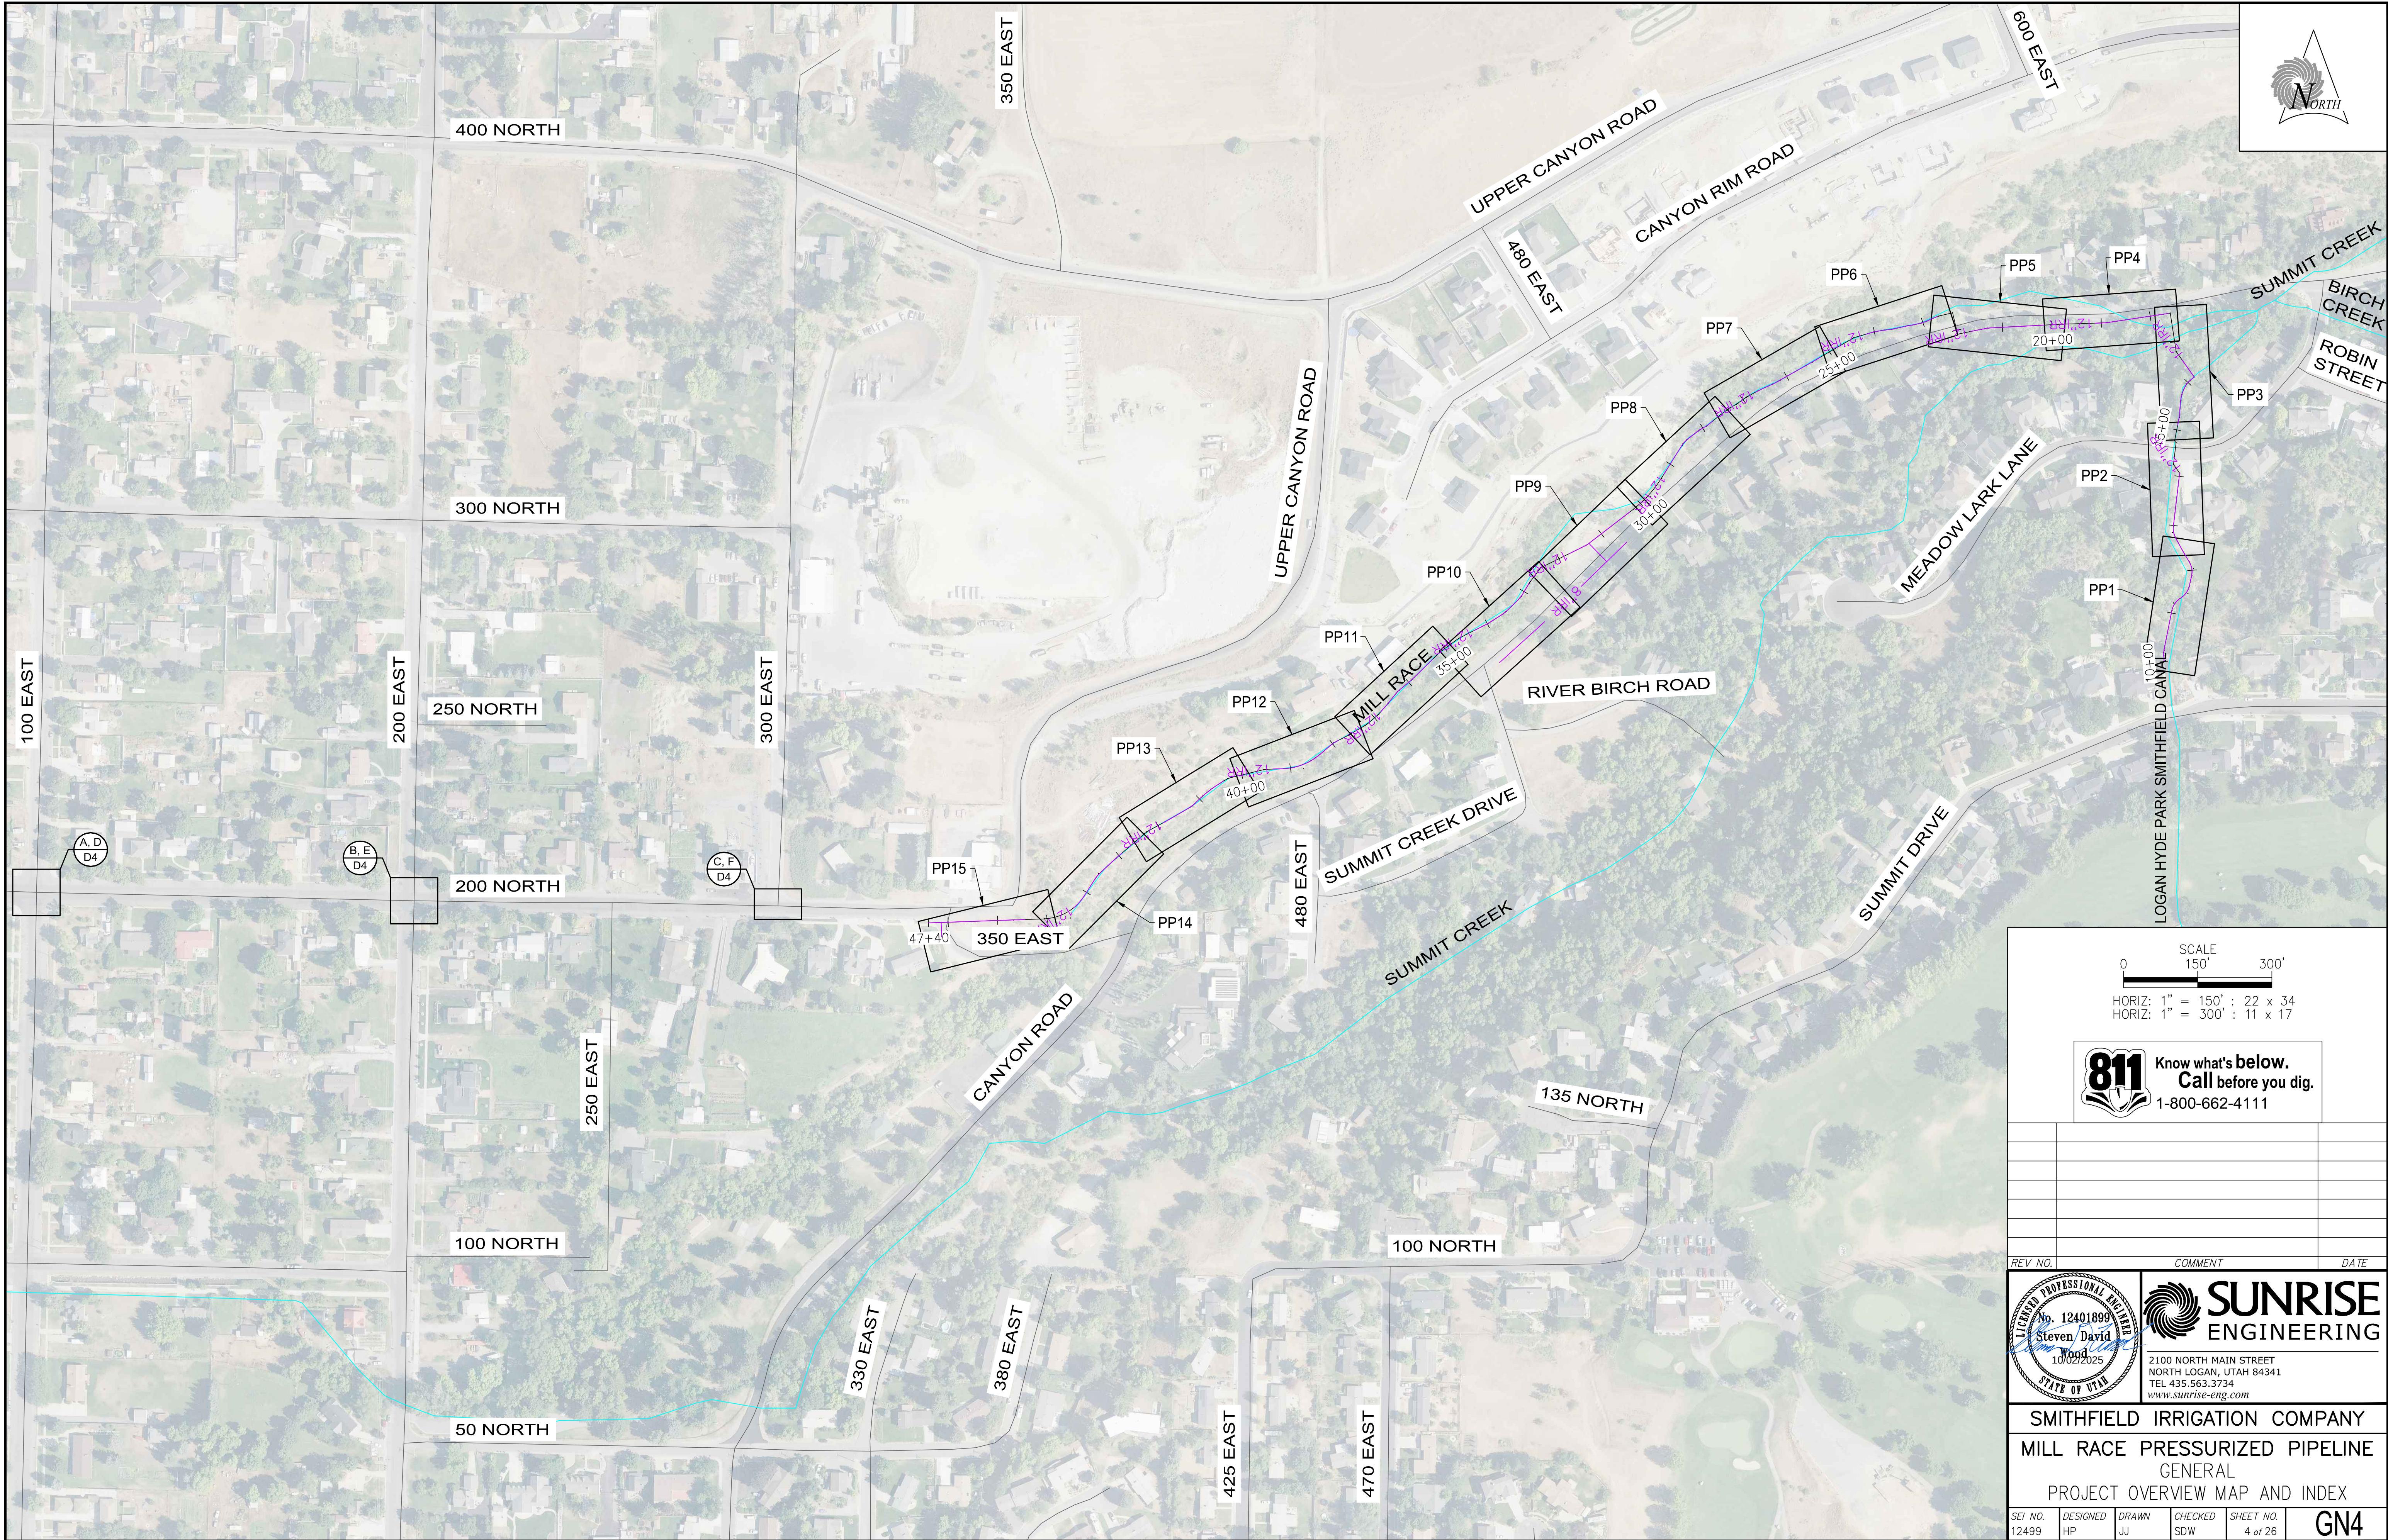


BID SET

SCALE
0 150' 300'
HORIZ: 1" = 150' : 22 x 34
HORIZ: 1" = 300' : 11 x 17

811 Know what's below.
Call before you dig.
1-800-662-4111

REV. NO.	COMMENT	DATE

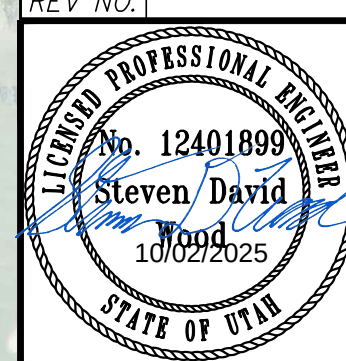


SUNRISE
ENGINEERING
2100 NORTH MAIN STREET
NORTH LOGAN, UTAH 84341
TEL 435.563.3734
www.sunrise-eng.com

SMITHFIELD IRRIGATION COMPANY					
MILL RACE PRESSURIZED PIPELINE					
GENERAL					
PROJECT OVERVIEW MAP AND INDEX					
SEI NO. 12499	DESIGNED HP	DRAWN JJ	CHECKED SDW	SHEET NO. 4 of 26	GN4

E:\Smithfield Irrigation Company\12499 - SIC Diversion System Improvements Project 2025\DWG\Sheets\SIC-D51-GN4-PP.dwg Oct 02, 2025 4:36pm jjoey

PROFILE OF ENTIRE PIPELINE

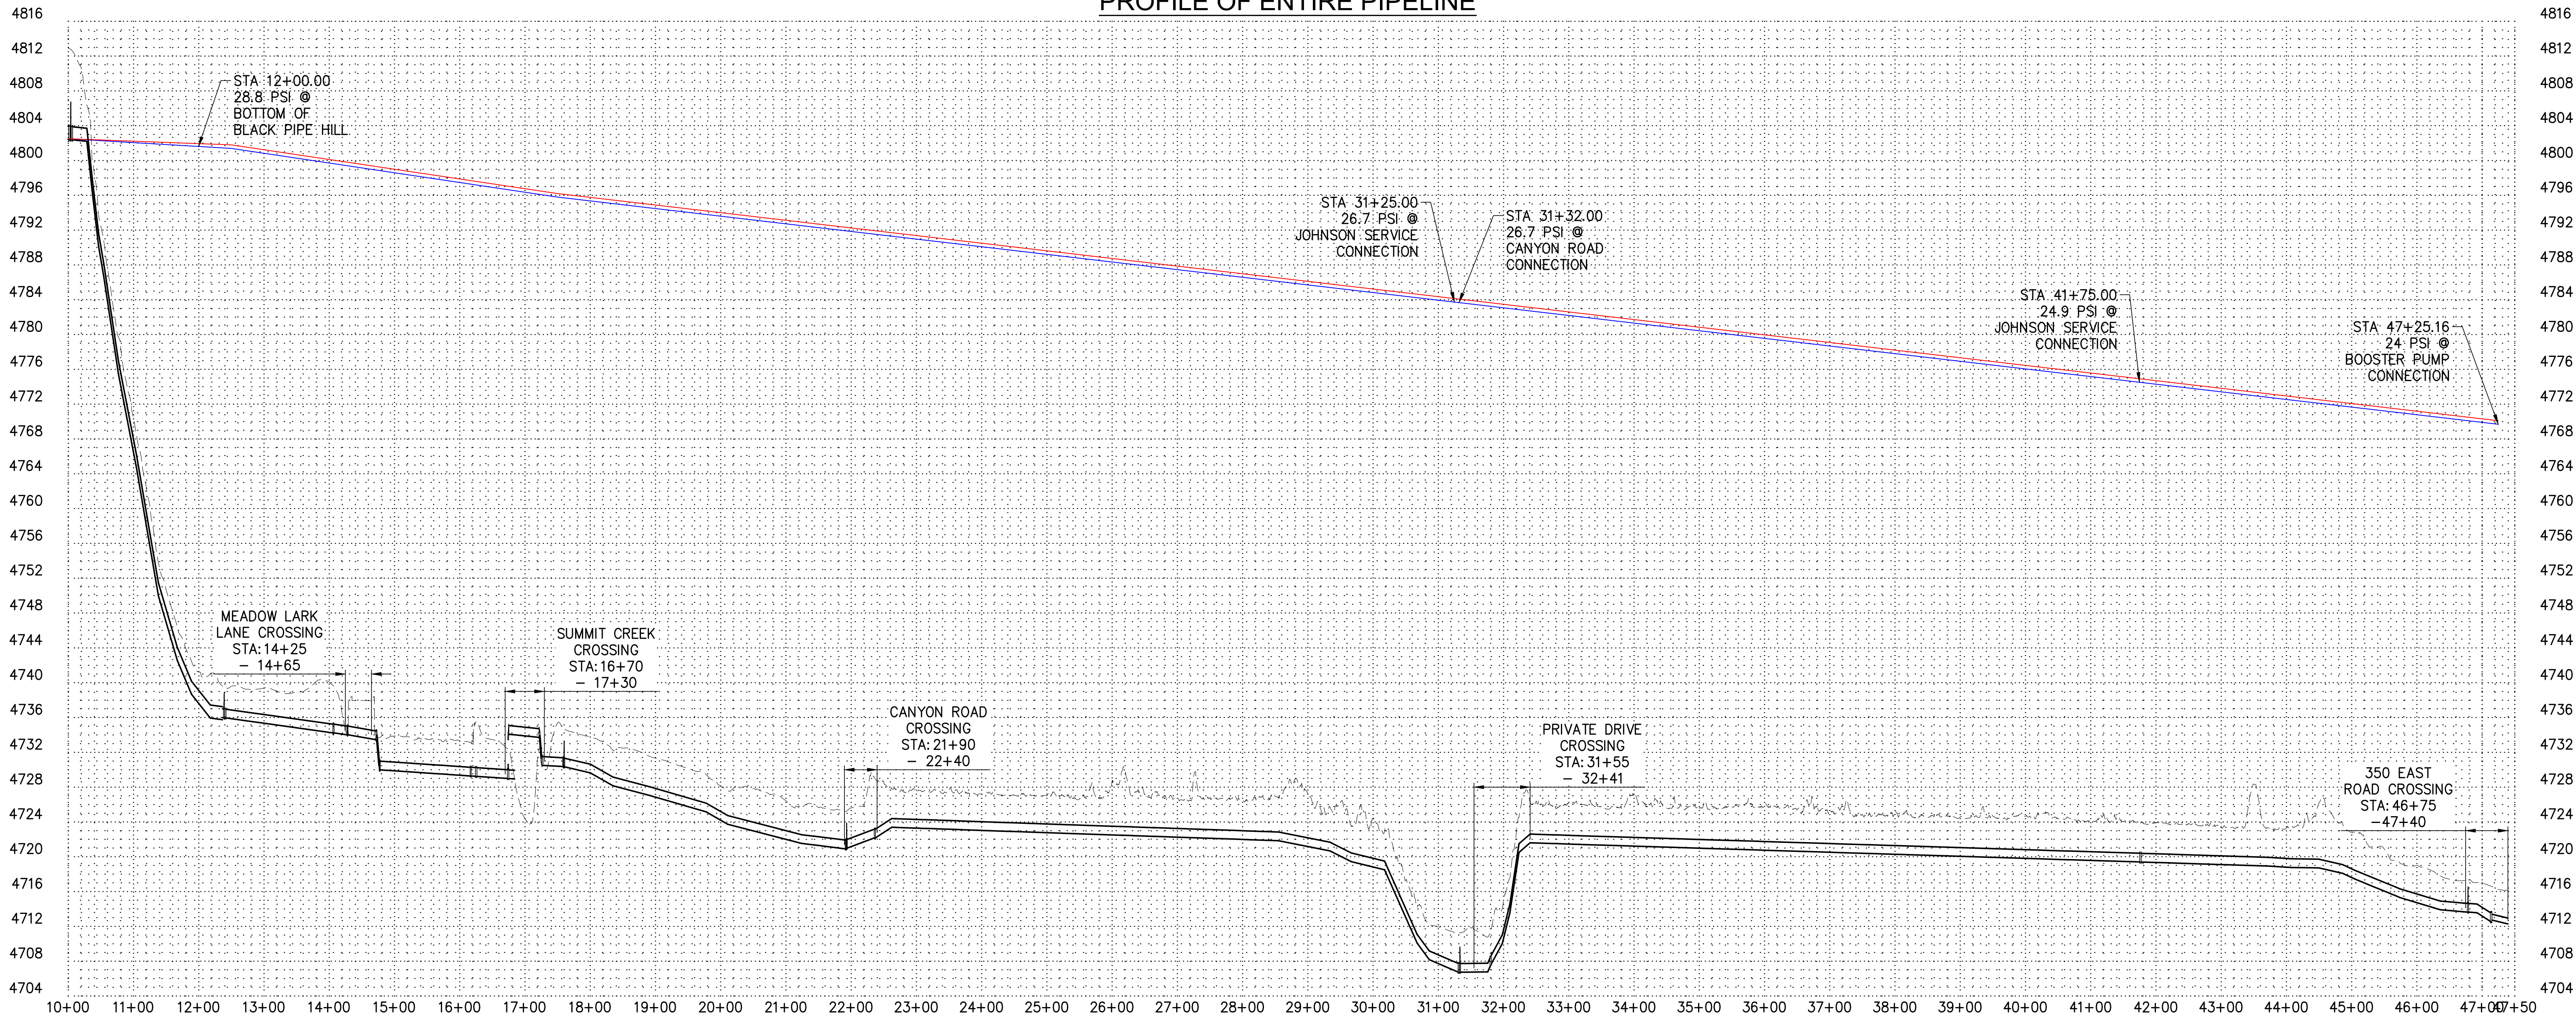


DESIGN CRITERIA

PRESSURIZED PIPELINES

- DESIGN FLOW: 1,792 GPM
- INITIAL HEAD: 4802.5 FT
- TOTAL FRICTIONAL LOSS: 26.53 FT
- TOTAL MINOR LOSS: 5.92 FT
- TOTAL HEAD LOSS: 32.45 FT
- VELOCITY IN INTAKE LINE: 2.26 FT / SEC (18" HDPE)
- VELOCITY IN TRANSMISSION LINE: 5.09 FT / SEC (12" HDPE)

LEGEND

- HGL - HYDRAULIC GRADE LINE
- EGL - ENERGY GRADE LINE

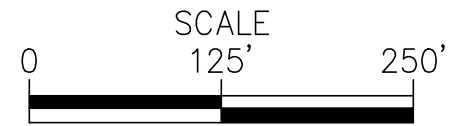

HORIZ: 1" = 125' : 22 x 34
HORIZ: 1" = 250' : 11 x 17
VERT: 1" = 10' : 22 x 34
VERT: 1" = 20' : 11 x 17

HYDRAULIC PROFILE					
	STATION	HGL	EGL	SYSTEM PRESSURE	HYDRAULIC PROFILE
1	10+00	4802.5	4802.5	0.0	TOP OF HILL BLACK PIPE INTAKE
2	12+50	4801.4	4801.8	28.8	18" TO 12" TRANSITION
3	17+50	4795.8	4796.2	29.0	THREE CREEKS AREA
4	47+25	4769.7	4770.1	24.0	DUG WAY BOOSTER PUMP HOUSE

FLOW (CFS)	VELOCITY @ 18" INTAKE PIPE (FT/S)	VELOCITY @ 12" TRANSMISSION LINE (FT/S)	TOTAL MINOR LOSS (FT)	TOTAL FRICTIONAL LOSS (FT)	TOTAL HEAD LOSS (FT)
1	0.57	1.27	0.37	2.04	2.41
2	1.13	2.55	1.48	7.36	8.84
3	1.70	3.82	3.33	15.58	18.91
4	2.26	5.09	5.92	26.53	32.45





REV NO.	COMMENT	DATE


SUNRISE
ENGINEERING

2100 NORTH MAIN STREET
NORTH LOGAN, UTAH 84341
TEL 435.563.3734
www.sunrise-eng.com

SMITHFIELD IRRIGATION COMPANY
MILL RACE PRESSURIZED PIPELINE
GENERAL
DESIGN CRITERIA

SEI NO.	DESIGNED	DRAWN	CHECKED	SHEET NO.	
12499	HP	JJ	SDW	5 of 26	GN5

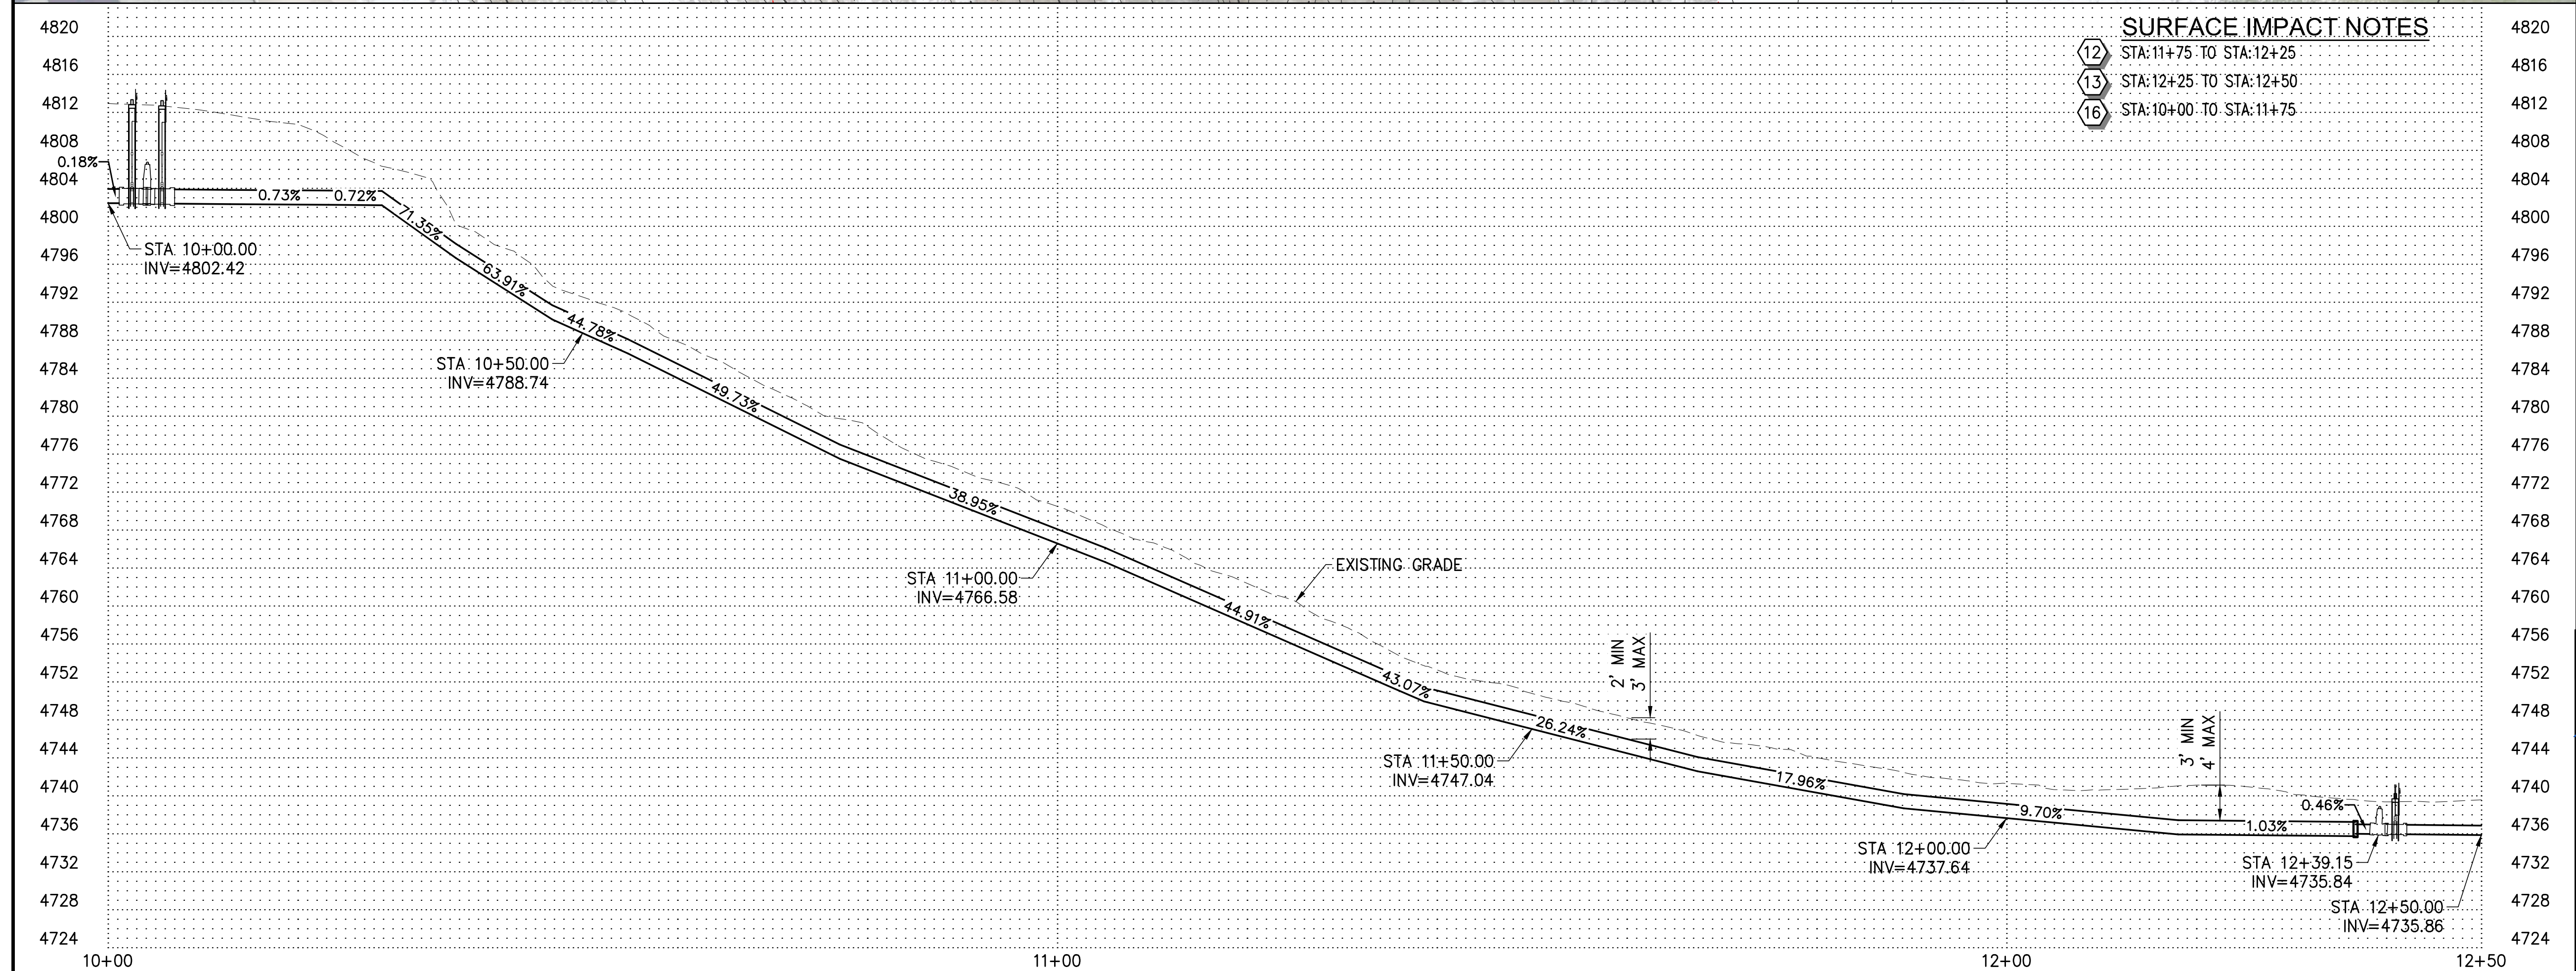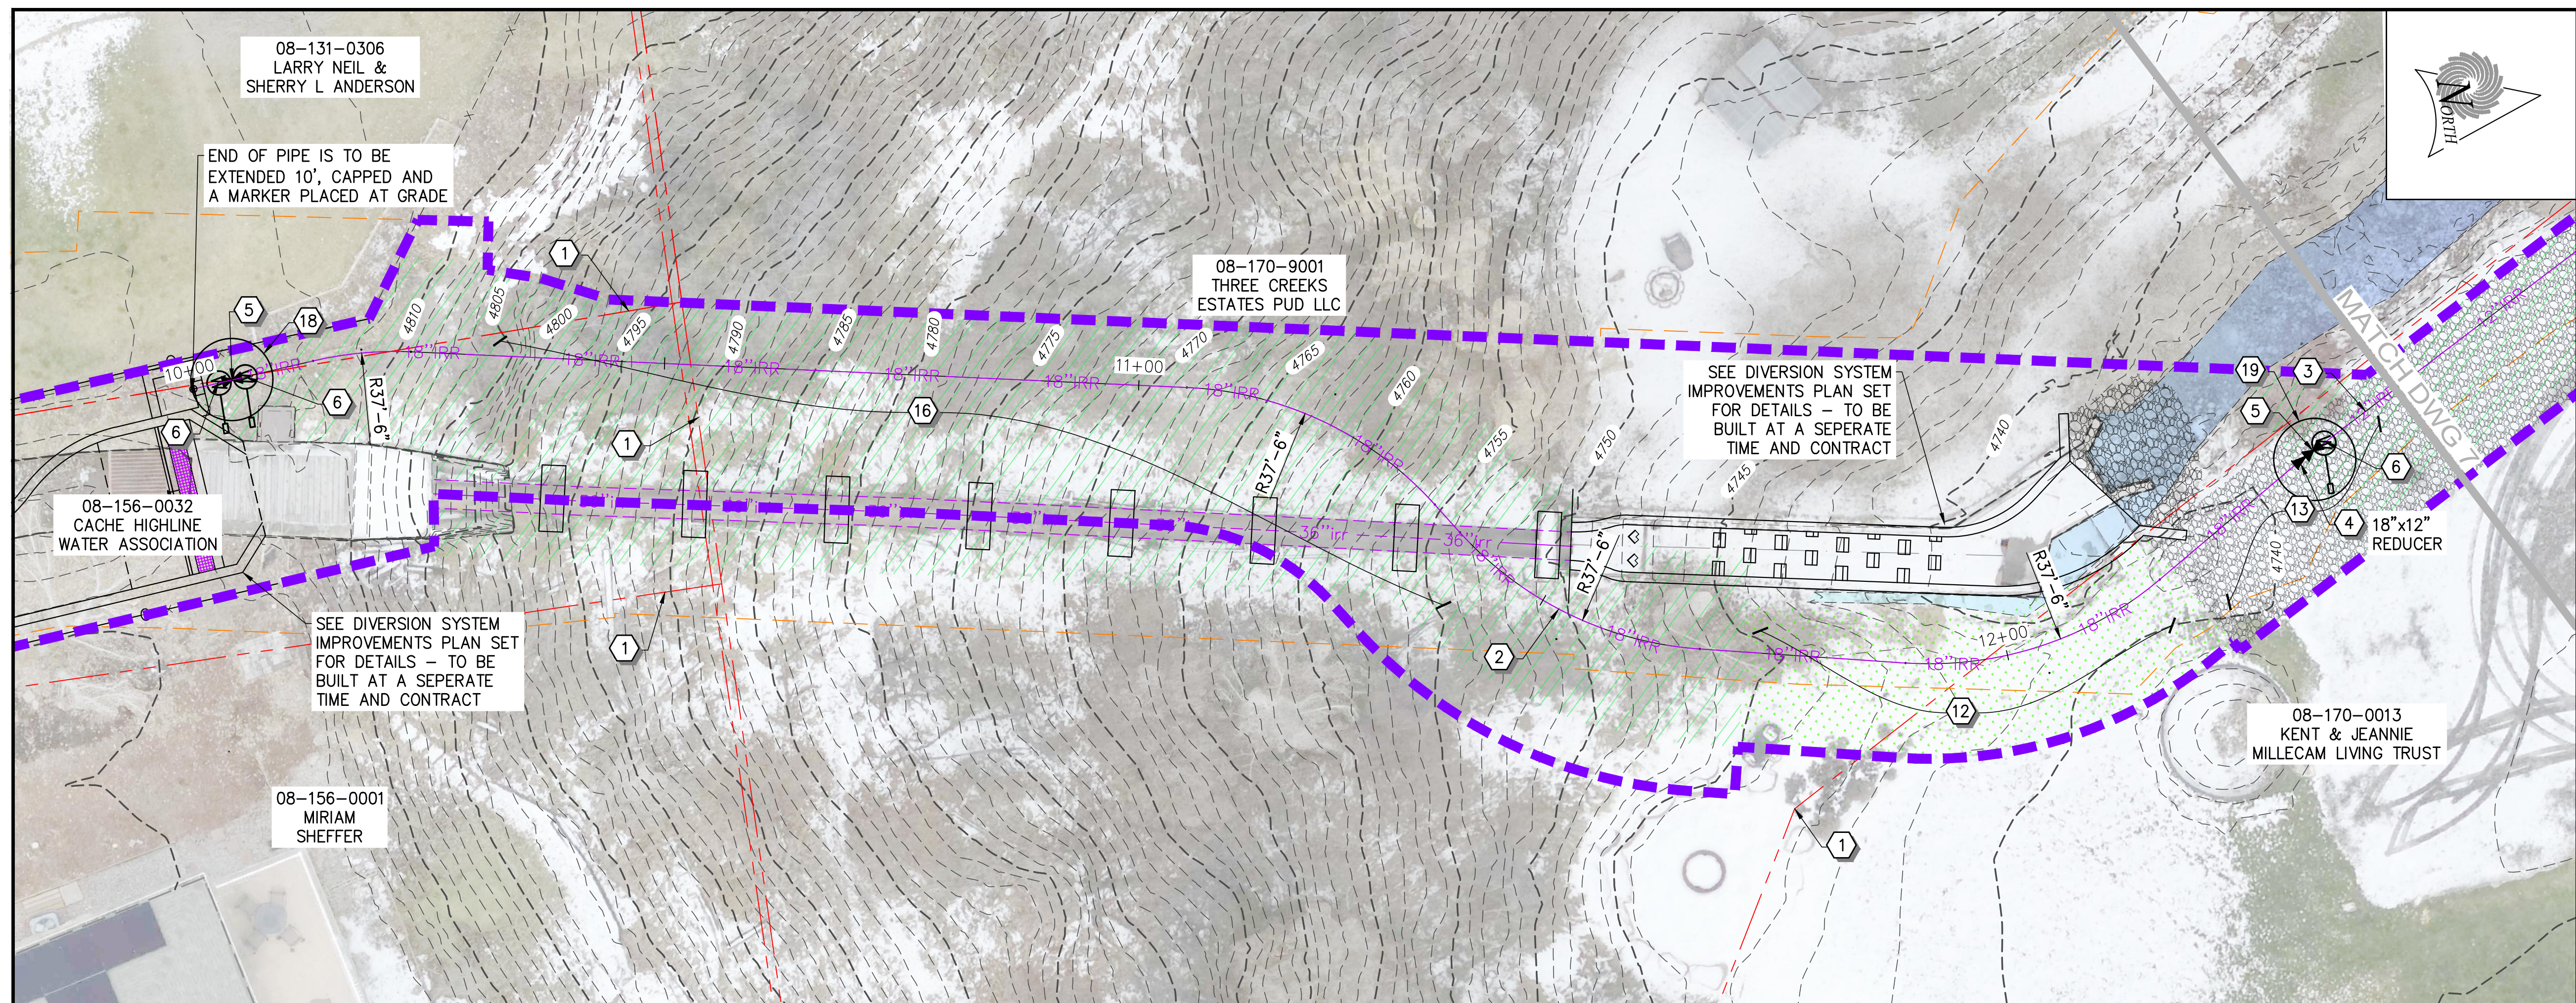

 
- ## CONSTRUCTION NOTES
- 1 PROPERTY LINES
 - 2 INSTALL 18" HDPE DR11 PIPE 
 - 3 INSTALL 12" HDPE DR11 PIPE 
 - 4 INSTALL FITTING PER PLAN
 - 5 INSTALL ISOLATION VALVE 
 - 6 INSTALL AIR / VAC ASSEMBLY 
 - 7 INSTALL TRACER WIRE CURB BOX 
 - 8 INSTALL MEADOW LARK CROSSING - IN CONCRETE CULVERT, AREA SURROUNDING 12" PIPE IS TO BE CLEANED AND FILLED WITH FLOWABLE FILL - PIPE IS TO BE SECURED WITH STAINLESS STEEL STRAPS 
 - 9 INSTALL SUMMIT CREEK CROSSING 
 - 10 INSTALL METER MANHOLE 
 - 11 INSTALL DIRECTIONAL BORE W/ 12" HDPE DR11 PIPE - NO TRACER WIRE REQUIRED AT BORE
 - 12 RESTORE AREA WITH LANDSCAPING SOD OR MATCHING LANDSCAPING LEVEL WITH SURROUNDING AREA
 - 13 RESTORE AREA WITH GRAVEL MATCHING EXISTING GRAVEL SURFACE - RESTORED AREA TO HAVE 3" MIN GRAVEL
 - 14 PROTECT EXISTING ROCK WALLS IN PLACE
 - 15 PROTECT EXISTING CONCRETE STRUCTURE IN PLACE
 - 16 VEGETATION IN AREA TO BE TRIMMED / REMOVED AS NEEDED FOR PIPE INSTALLATION
 - 17 PLACE ROCKS ALONG BANK WHERE LAND OWNERS HAVE LINED THEIR BANKS
 - 18 CONNECTION #1 
 - 19 CONNECTION #2 
 - 20 INSTALL 4" HDPE DR11 PIPE 
 - 21 INSTALL 8" HDPE DR11 PIPE 
 - 22 INSTALL 4" PERFORATED MANHOLE 
 - 23 INSTALL SERVICE CONNECTION 
 - 24 INFILL OLD IRRIGATION DITCH FOR 20' EAST AND WEST OF PIPE CROSSING - COMPACT TO 90%
 - 25 SAWCUT ASPHALT TO PROVIDE CLEAN EDGE - REMOVE ASPHALT PAVEMENT
 - 26 REPLACE ASPHALT PAVEMENT 
 - 27 RESTORE GRAVEL DRIVEWAY 
 - 28 REMOVE CURB AND GUTTER OR SIDEWALK IN FULL SECTIONS
 - 29 REPLACE SIDEWALK / ADA RAMP 
 - 30 REPLACE CURB AND GUTTER 
 - 31 INSTALL 8" C900 PIPE FROM REDUCER AND SPLICE INTO EXISTING PIPES W/ COUPLER 
 - 32 EXISTING PUMP HOUSE REPLUMBING 
- 2025 DWG Sheets \\SC-DSI-18-12 INCH-PP1.dwg Oct, 2025 4:37pm jolley

SCALE

0 10' 20'


HORIZ: 1" = 10' : 22 x 34
HORIZ: 1" = 20' : 11 x 17
VERT: 1" = 10' : 22 x 34
VERT: 1" = 20' : 11 x 17

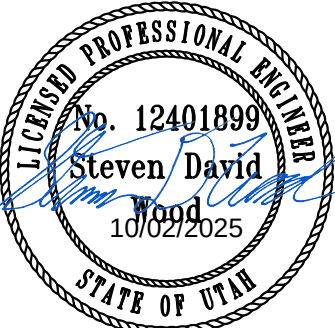


REV NO.		COMMENT		DATE	
		 SUNRISE ENGINEERING			
		2100 NORTH MAIN STREET NORTH LOGAN, UTAH 84341 TEL 435.563.3734 www.sunrise-eng.com			
SMITHFIELD IRRIGATION COMPANY					
MOUND RACE PRESSURIZED PIPELINE PRESSURIZED PIPELINE PLAN AND PROFILE					
SEI NO. 12499	DESIGNED HP	DRAWN JJ	CHECKED SDW	SHEET NO. 6 of 26	PP1

BID SET

P:\Smithfield Irrigation Company\12499 - SIC Diversion System Improvements Project 2025\DWG\Sheets\SIC-DSL-18-12 INCH-PP1.dwg Oct 02, 2025 4:37pm jjolley

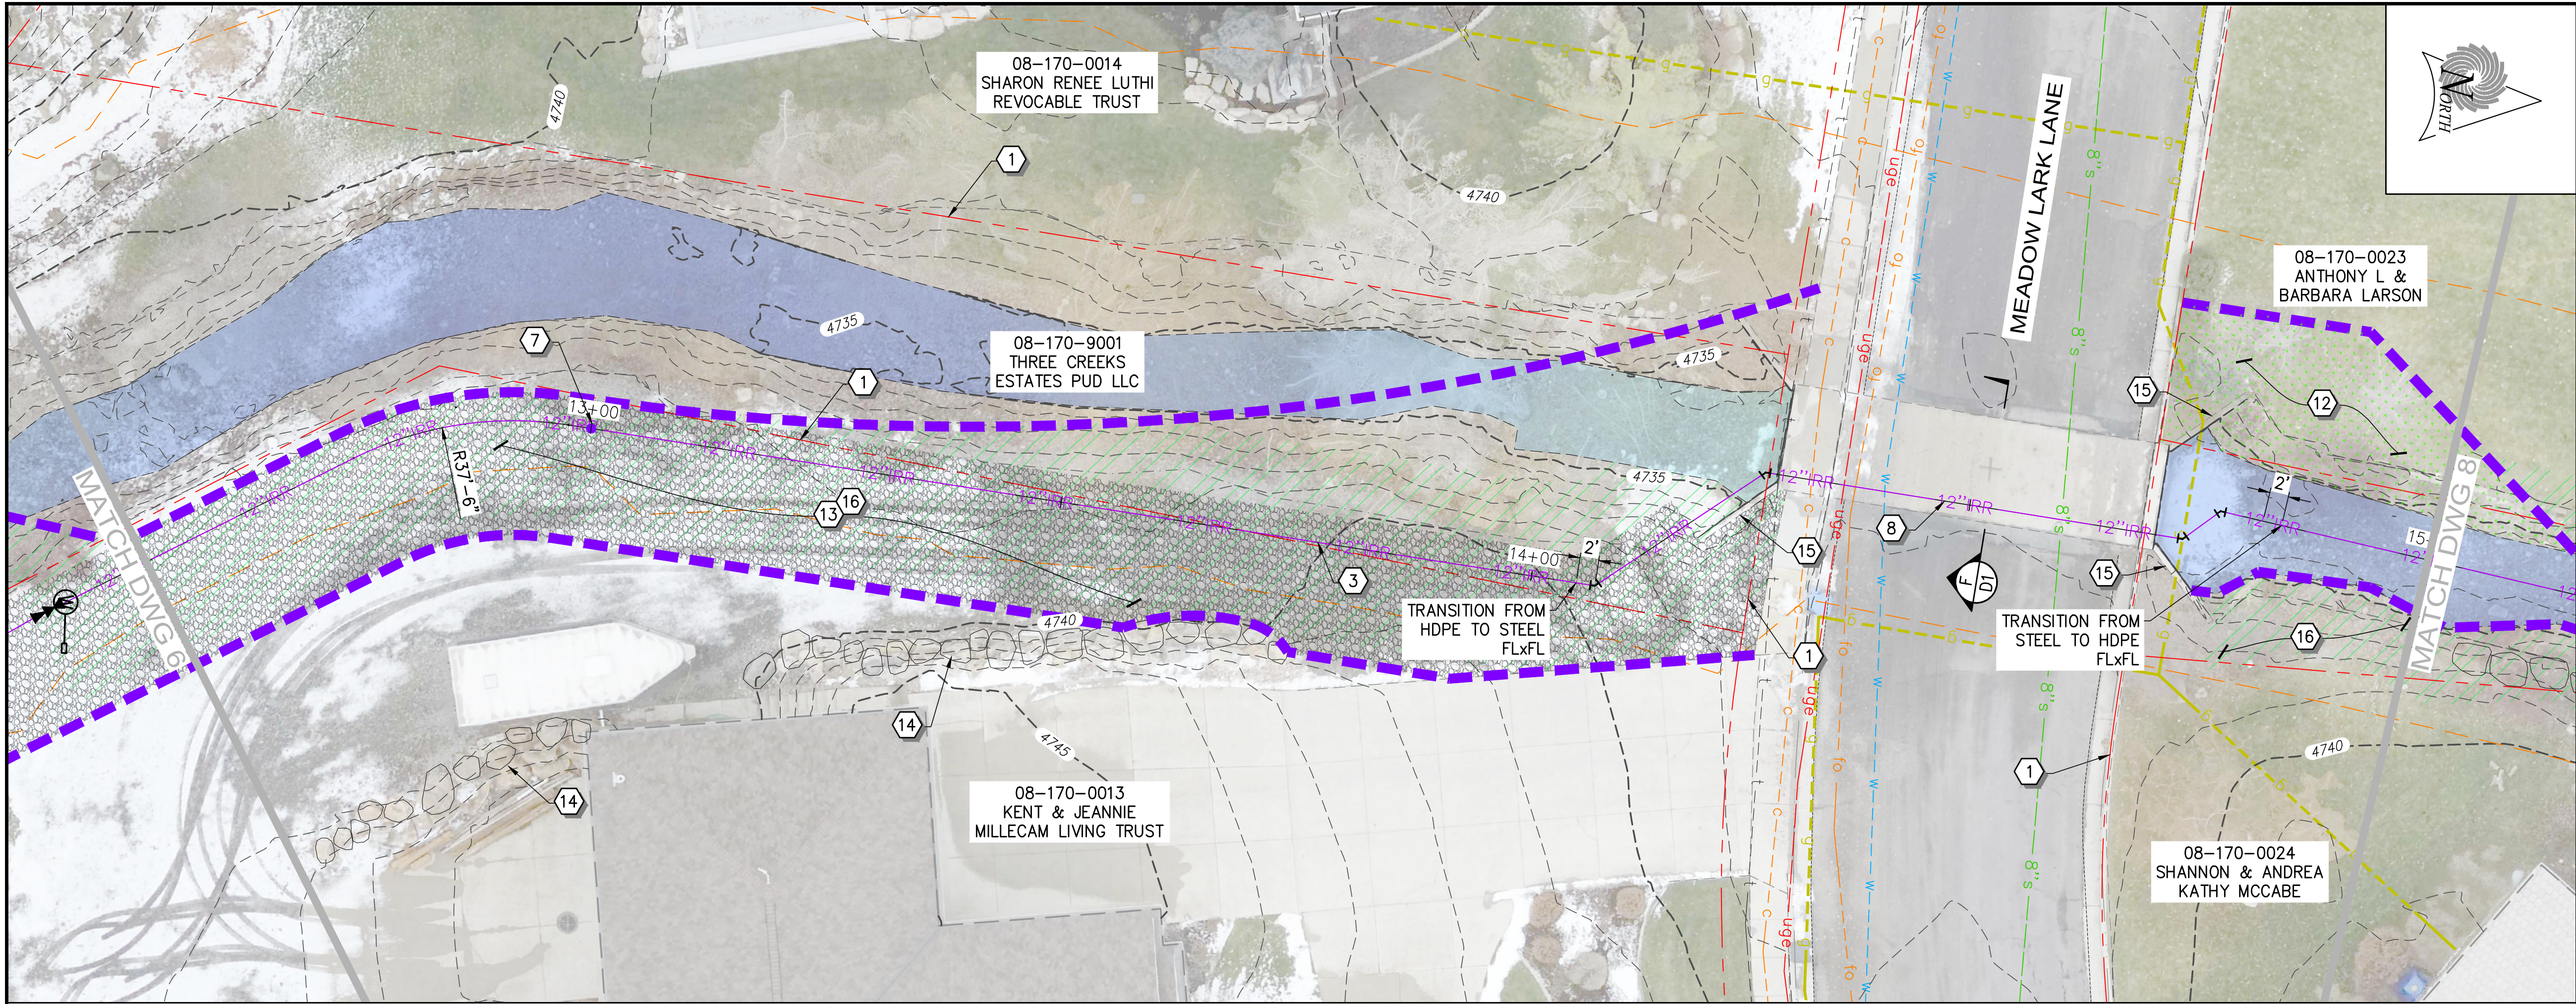

- ### CONSTRUCTION NOTES
- 1 PROPERTY LINES
 - 2 INSTALL 18" HDPE DR11 PIPE
 - 3 INSTALL 12" HDPE DR11 PIPE
 - 4 INSTALL FITTING PER PLAN
 - 5 INSTALL ISOLATION VALVE
 - 6 INSTALL AIR / VAC ASSEMBLY
 - 7 INSTALL TRACER WIRE CURB BOX
 - 8 INSTALL MEADOW LARK CROSSING - IN CONCRETE CULVERT, AREA SURROUNDING 12" PIPE IS TO BE CLEANED AND FILLED WITH FLOWABLE FILL - PIPE IS TO BE SECURED WITH STAINLESS STEEL STRAPS
 - 9 INSTALL SUMMIT CREEK CROSSING
 - 10 INSTALL METER MANHOLE
 - 11 INSTALL DIRECTIONAL BORE W/ 12" HDPE DR11 PIPE - NO TRACER WIRE REQUIRED AT BORE
 - 12 RESTORE AREA WITH LANDSCAPING SOD OR MATCHING LANDSCAPING LEVEL WITH SURROUNDING AREA
 - 13 RESTORE AREA WITH GRAVEL MATCHING EXISTING GRAVEL SURFACE - RESTORED AREA TO HAVE 3" MIN GRAVEL
 - 14 PROTECT EXISTING ROCK WALLS IN PLACE
 - 15 PROTECT EXISTING CONCRETE STRUCTURE IN PLACE
 - 16 VEGETATION IN AREA TO BE TRIMMED / REMOVED AS NEEDED FOR PIPE INSTALLATION
 - 17 PLACE ROCKS ALONG BANK WHERE LAND OWNERS HAVE LINED THEIR BANKS
 - 18 CONNECTION #1
 - 19 CONNECTION #2
 - 20 INSTALL 4" HDPE DR11 PIPE
 - 21 INSTALL 8" HDPE DR11 PIPE
 - 22 INSTALL 4" PERFORATED MANHOLE
 - 23 INSTALL SERVICE CONNECTION
 - 24 INFILL OLD IRRIGATION DITCH FOR 20' EAST AND WEST OF PIPE CROSSING - COMPACT TO 90%
 - 25 SAWCUT ASPHALT TO PROVIDE CLEAN EDGE - REMOVE ASPHALT PAVEMENT
 - 26 REPLACE ASPHALT PAVEMENT
 - 27 RESTORE GRAVEL DRIVEWAY
 - 28 REMOVE CURB AND GUTTER OR SIDEWALK IN FULL SECTIONS
 - 29 REPLACE SIDEWALK / ADA RAMP
 - 30 REPLACE CURB AND GUTTER
 - 31 INSTALL 8" C900 PIPE FROM REDUCER AND SPLICE INTO EXISTING PIPES W/ COUPLER
 - 32 EXISTING PUMP HOUSE REPLUMBING

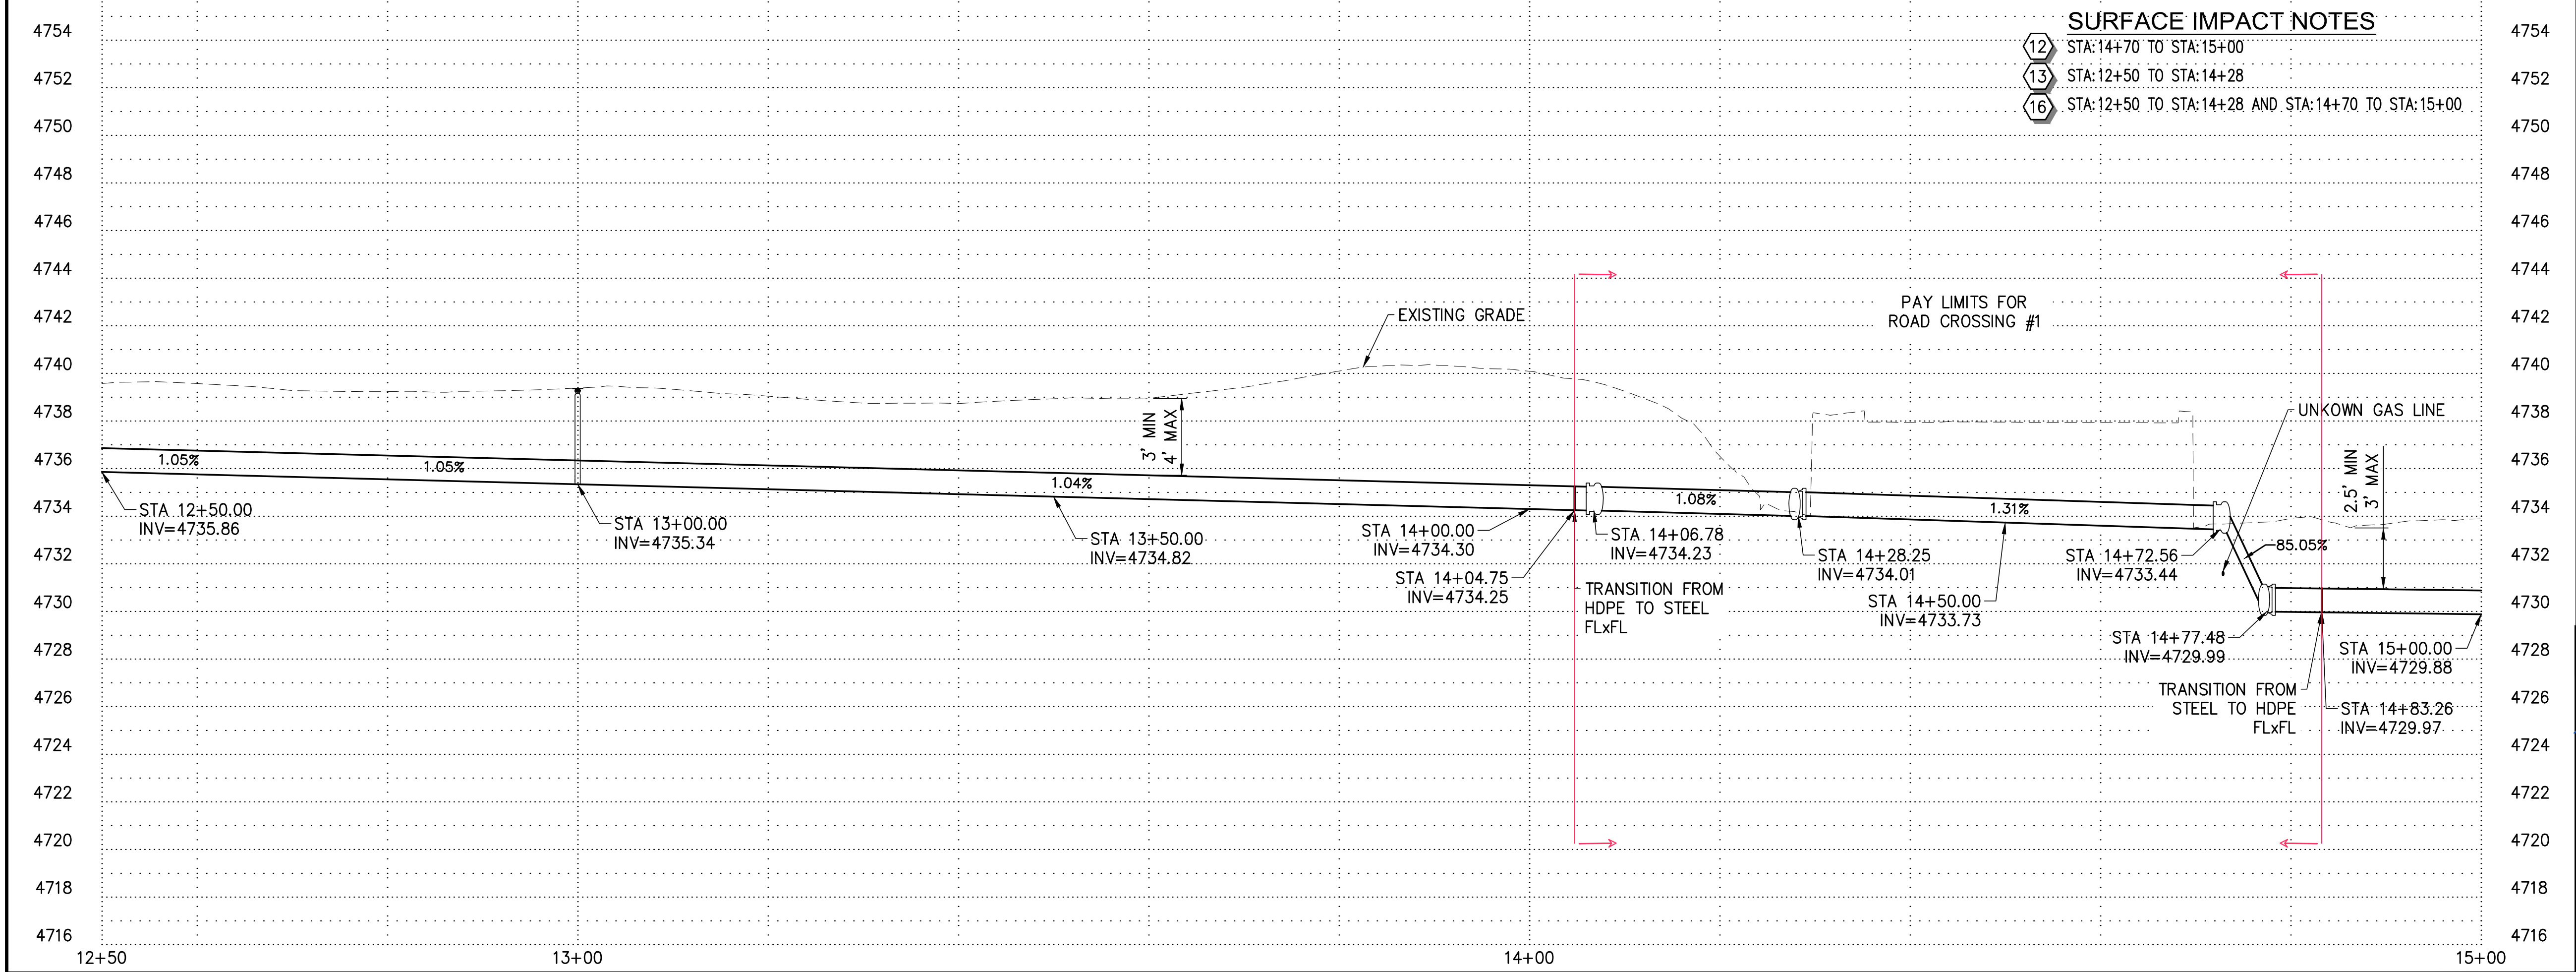

SCALE
0 10' 20'

HORIZ: 1" = 10' : 22 x 34
HORIZ: 1" = 20' : 11 x 17
VERT: 1" = 4' : 22 x 34
VERT: 1" = 8' : 11 x 17

811 Know what's below.
Call before you dig.
1-800-662-4111

REV. NO.	COMMENT	DATE



SUNRISE ENGINEERING
2100 NORTH MAIN STREET
NORTH LOGAN, UTAH 84341
TEL 435.563.3734
www.sunrise-eng.com

SMITHFIELD IRRIGATION COMPANY
MILL RACE PRESSURIZED PIPELINE
PRESSURIZED PIPELINE
PLAN AND PROFILE

SEI NO.	DESIGNED	DRAWN	CHECKED	SHEET NO.	
12499	HP	JJ	SDW	7 of 26	PP2

BID SET

E:\Smithfield Irrigation Company\12499 - SIC Diversion System Improvements Project 2025\DWG\Sheets\SIC-D5-18-18-12 INCH-PP2.dwg Oct 02, 2025 4:36pm jjoiley

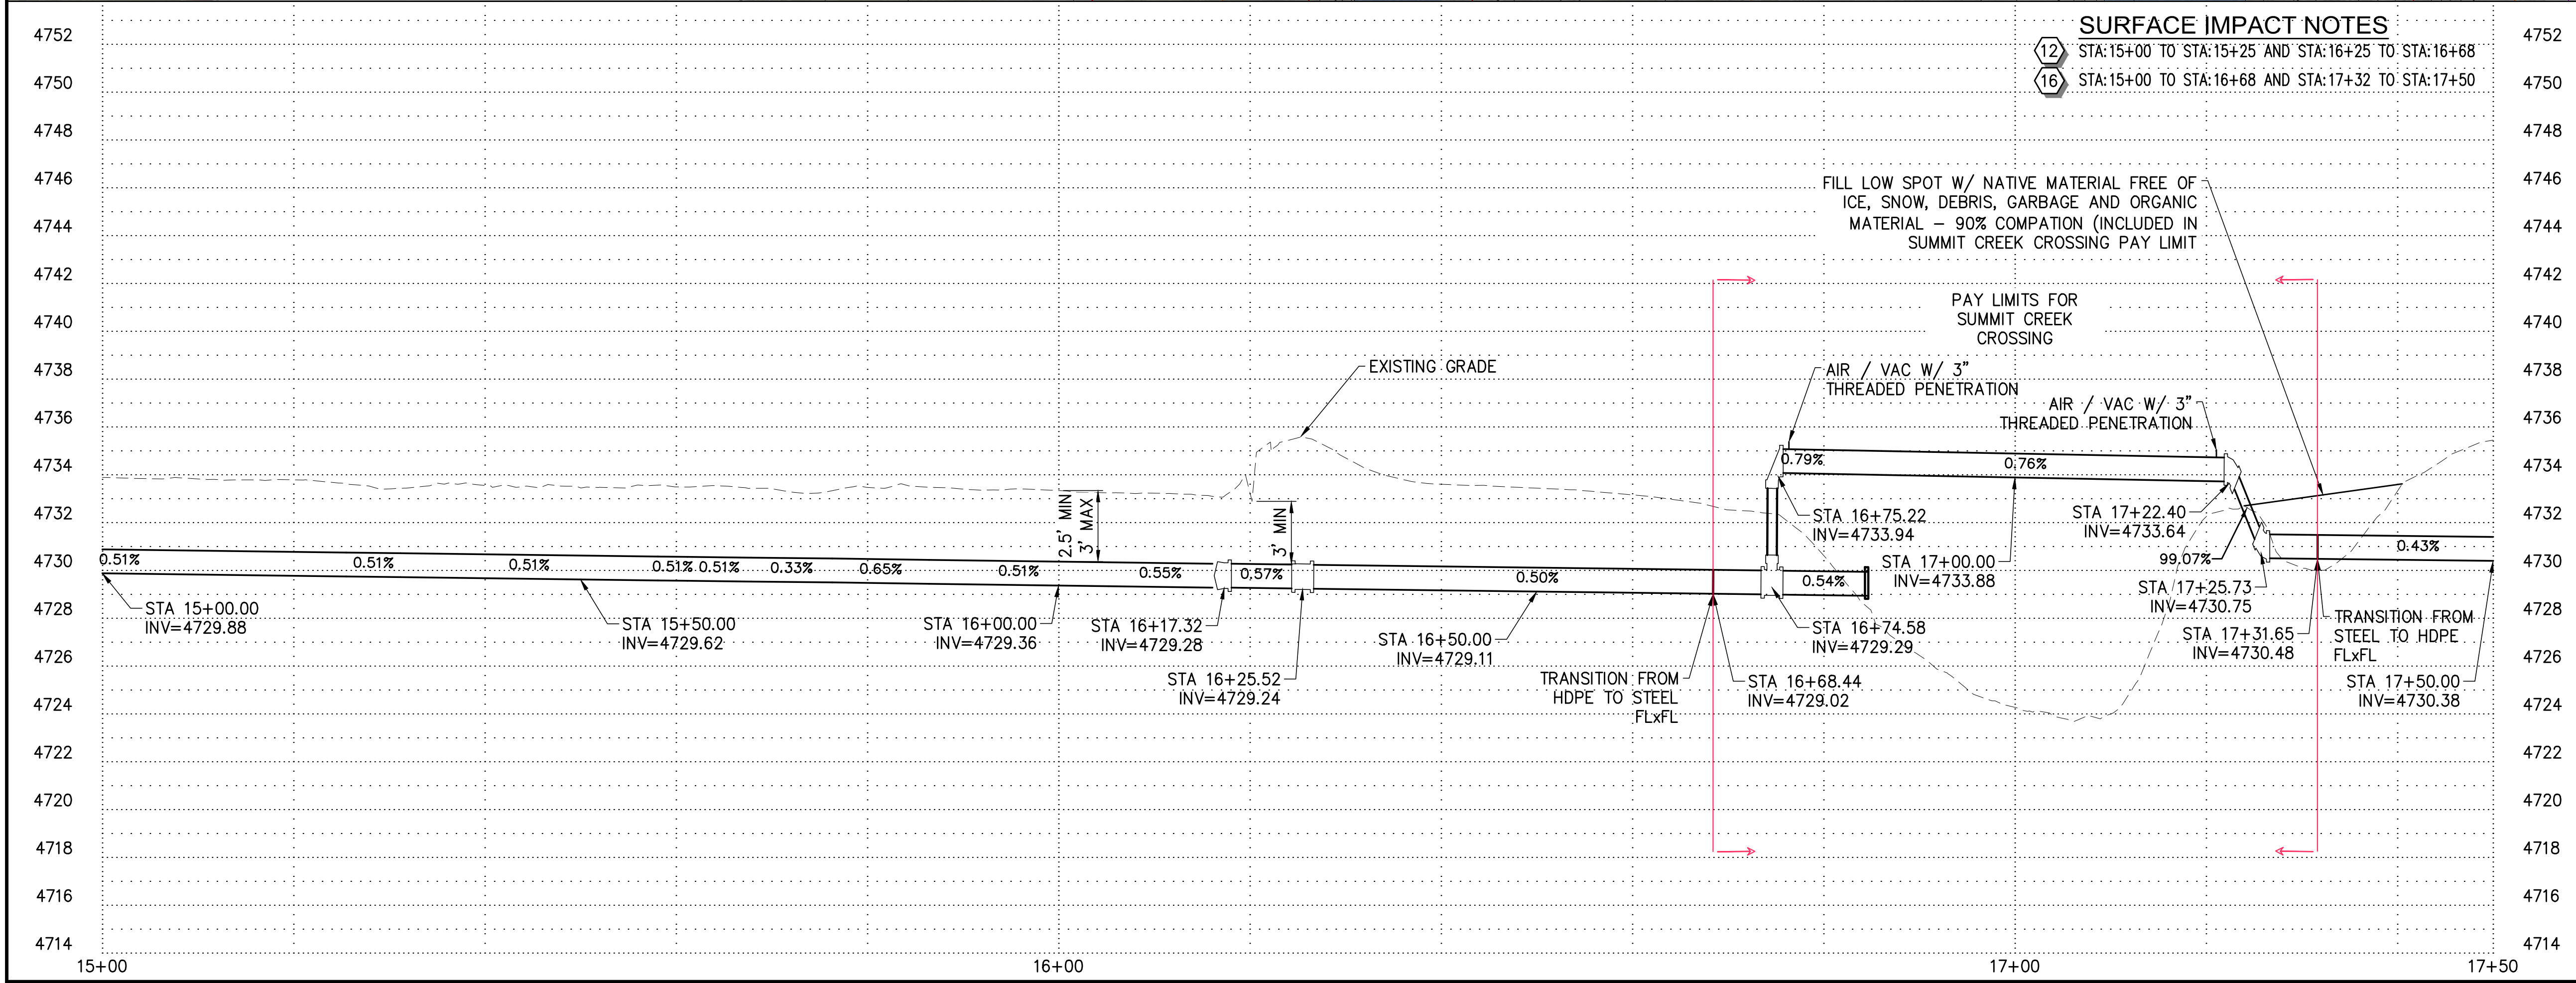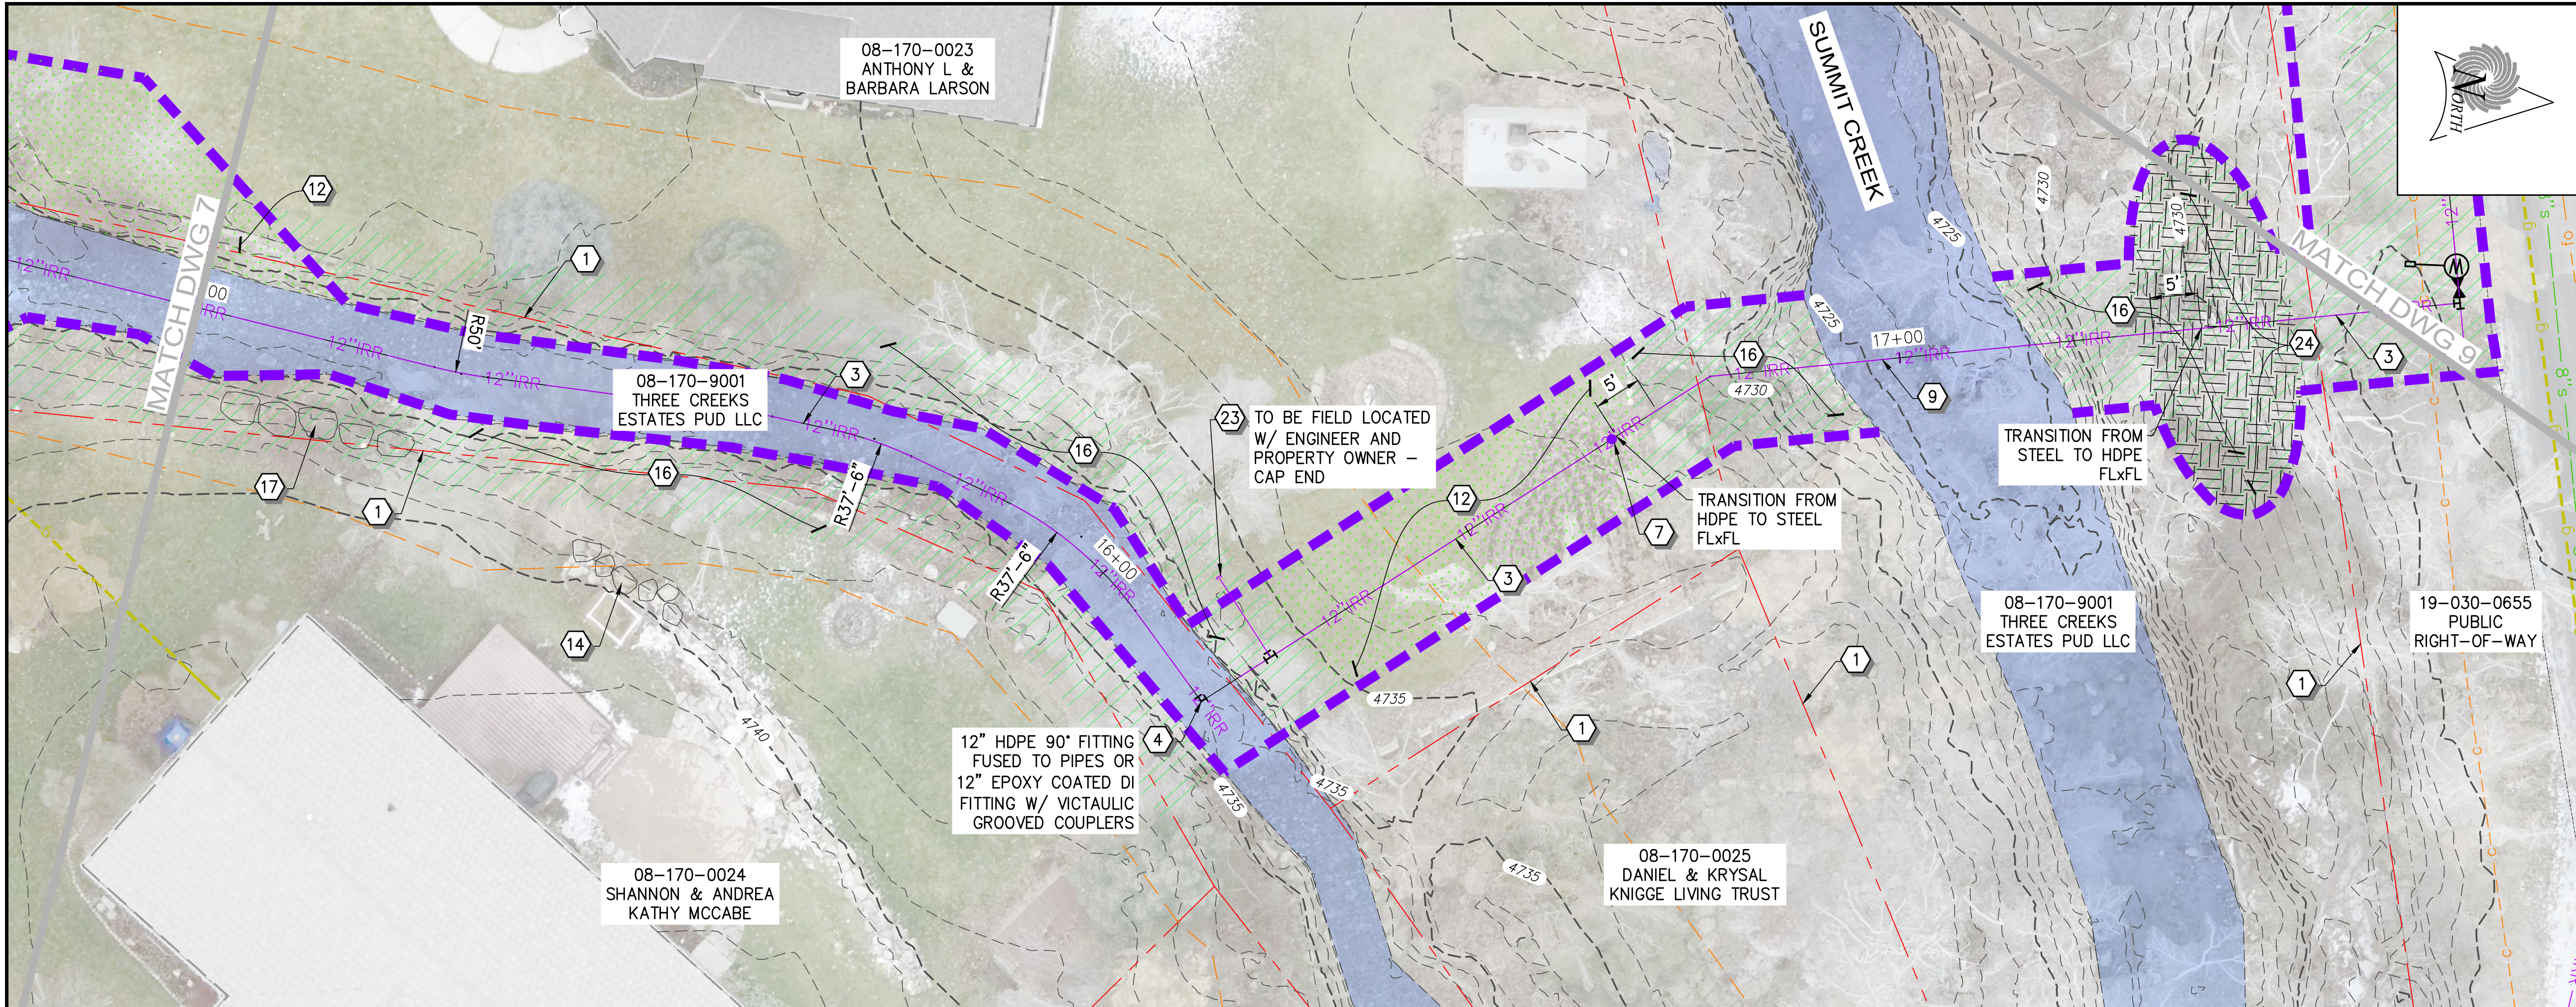

CONSTRUCTION NOTES

- PROPERTY LINES
- INSTALL 18" HDPE DR11 PIPE
- INSTALL 12" HDPE DR11 PIPE
- INSTALL FITTING PER PLAN
- INSTALL ISOLATION VALVE
- INSTALL AIR / VAC ASSEMBLY
- INSTALL TRACER WIRE CURB BOX
- INSTALL MEADOW LARK CROSSING - IN CONCRETE CULVERT, AREA SURROUNDING 12" PIPE IS TO BE CLEANED AND FILLED WITH FLOWABLE FILL - PIPE IS TO BE SECURED WITH STAINLESS STEEL STRAPS
- INSTALL SUMMIT CREEK CROSSING
- INSTALL METER MANHOLE
- INSTALL DIRECTIONAL BORE W/ 12" HDPE DR11 PIPE - NO TRACER WIRE REQUIRED AT BORE
- RESTORE AREA WITH LANDSCAPING SOD OR MATCHING LANDSCAPING LEVEL WITH SURROUNDING AREA
- RESTORE AREA WITH GRAVEL MATCHING EXISTING GRAVEL SURFACE - RESTORED AREA TO HAVE 3" MIN GRAVEL
- PROTECT EXISTING ROCK WALLS IN PLACE
- PROTECT EXISTING CONCRETE STRUCTURE IN PLACE
- VEGETATION IN AREA TO BE TRIMMED / REMOVED AS NEEDED FOR PIPE INSTALLATION
- PLACE ROCKS ALONG BANK WHERE LAND OWNERS HAVE LINED THEIR BANKS
- CONNECTION #1
- CONNECTION #2
- INSTALL 4" HDPE DR11 PIPE
- INSTALL 8" HDPE DR11 PIPE
- INSTALL 4" PERFORATED MANHOLE
- INSTALL SERVICE CONNECTION
- INFILL OLD IRRIGATION DITCH FOR 20' EAST AND WEST OF PIPE CROSSING - COMPACT TO 90%
- SAWCUT ASPHALT TO PROVIDE CLEAN EDGE - REMOVE ASPHALT PAVEMENT
- REPLACE ASPHALT PAVEMENT
- RESTORE GRAVEL DRIVEWAY
- REMOVE CURB AND GUTTER OR SIDEWALK IN FULL SECTIONS
- REPLACE SIDEWALK / ADA RAMP
- REPLACE CURB AND GUTTER
- INSTALL 8" C900 PIPE FROM REDUCER AND SPLICE INTO EXISTING PIPES W/ COUPLER
- EXISTING PUMP HOUSE REPLUMBING

SURFACE IMPACT NOTES

12 STA:15+00 TO STA:15+25 AND STA:16+25 TO STA:16+68

16 STA:15+00 TO STA:16+68 AND STA:17+32 TO STA:17+50

FILL LOW SPOT W/ NATIVE MATERIAL FREE OF ICE, SNOW, DEBRIS, GARBAGE AND ORGANIC MATERIAL - 90% COMPACTION (INCLUDED IN SUMMIT CREEK CROSSING PAY LIMIT)

PAY LIMITS FOR SUMMIT CREEK CROSSING

AIR / VAC W/ 3" THREADED PENETRATION

AIR / VAC W/ 3" THREADED PENETRATION

EXISTING GRADE

TRANSITION FROM HDPE TO STEEL FLxFL

TRANSITION FROM STEEL TO HDPE FLxFL

TRANSITION FROM STEEL TO HDPE FLxFL

SCALE

0 10' 20'

HORIZ: 1" = 10' : 22 x 34

HORIZ: 1" = 20' : 11 x 17

VERT: 1" = 4' : 22 x 34

VERT: 1" = 8' : 11 x 17

811 Know what's below. Call before you dig. 1-800-662-4111

REV NO.	COMMENT	DATE

SUNRISE ENGINEERING

2100 NORTH MAIN STREET
NORTH LOGAN, UTAH 84341
TEL 435.563.3734
www.sunrise-eng.com

SMITHFIELD IRRIGATION COMPANY

MILL RACE PRESSURIZED PIPELINE



PRESSURIZED PIPELINE

PLAN AND PROFILE

SEI NO.	DESIGNED	DRAWN	CHECKED	SHEET NO.	PP3
12499	HP	JJ	SDW	8 of 26	

BID SET

E:\Smithfield Irrigation Company\12499 - SIC Diversion System Improvements Project 2025\DWG\Sheets\SIC-D5-18-18-12 INCH-PP3.dwg Oct 02, 2025 4:39pm jjoiley

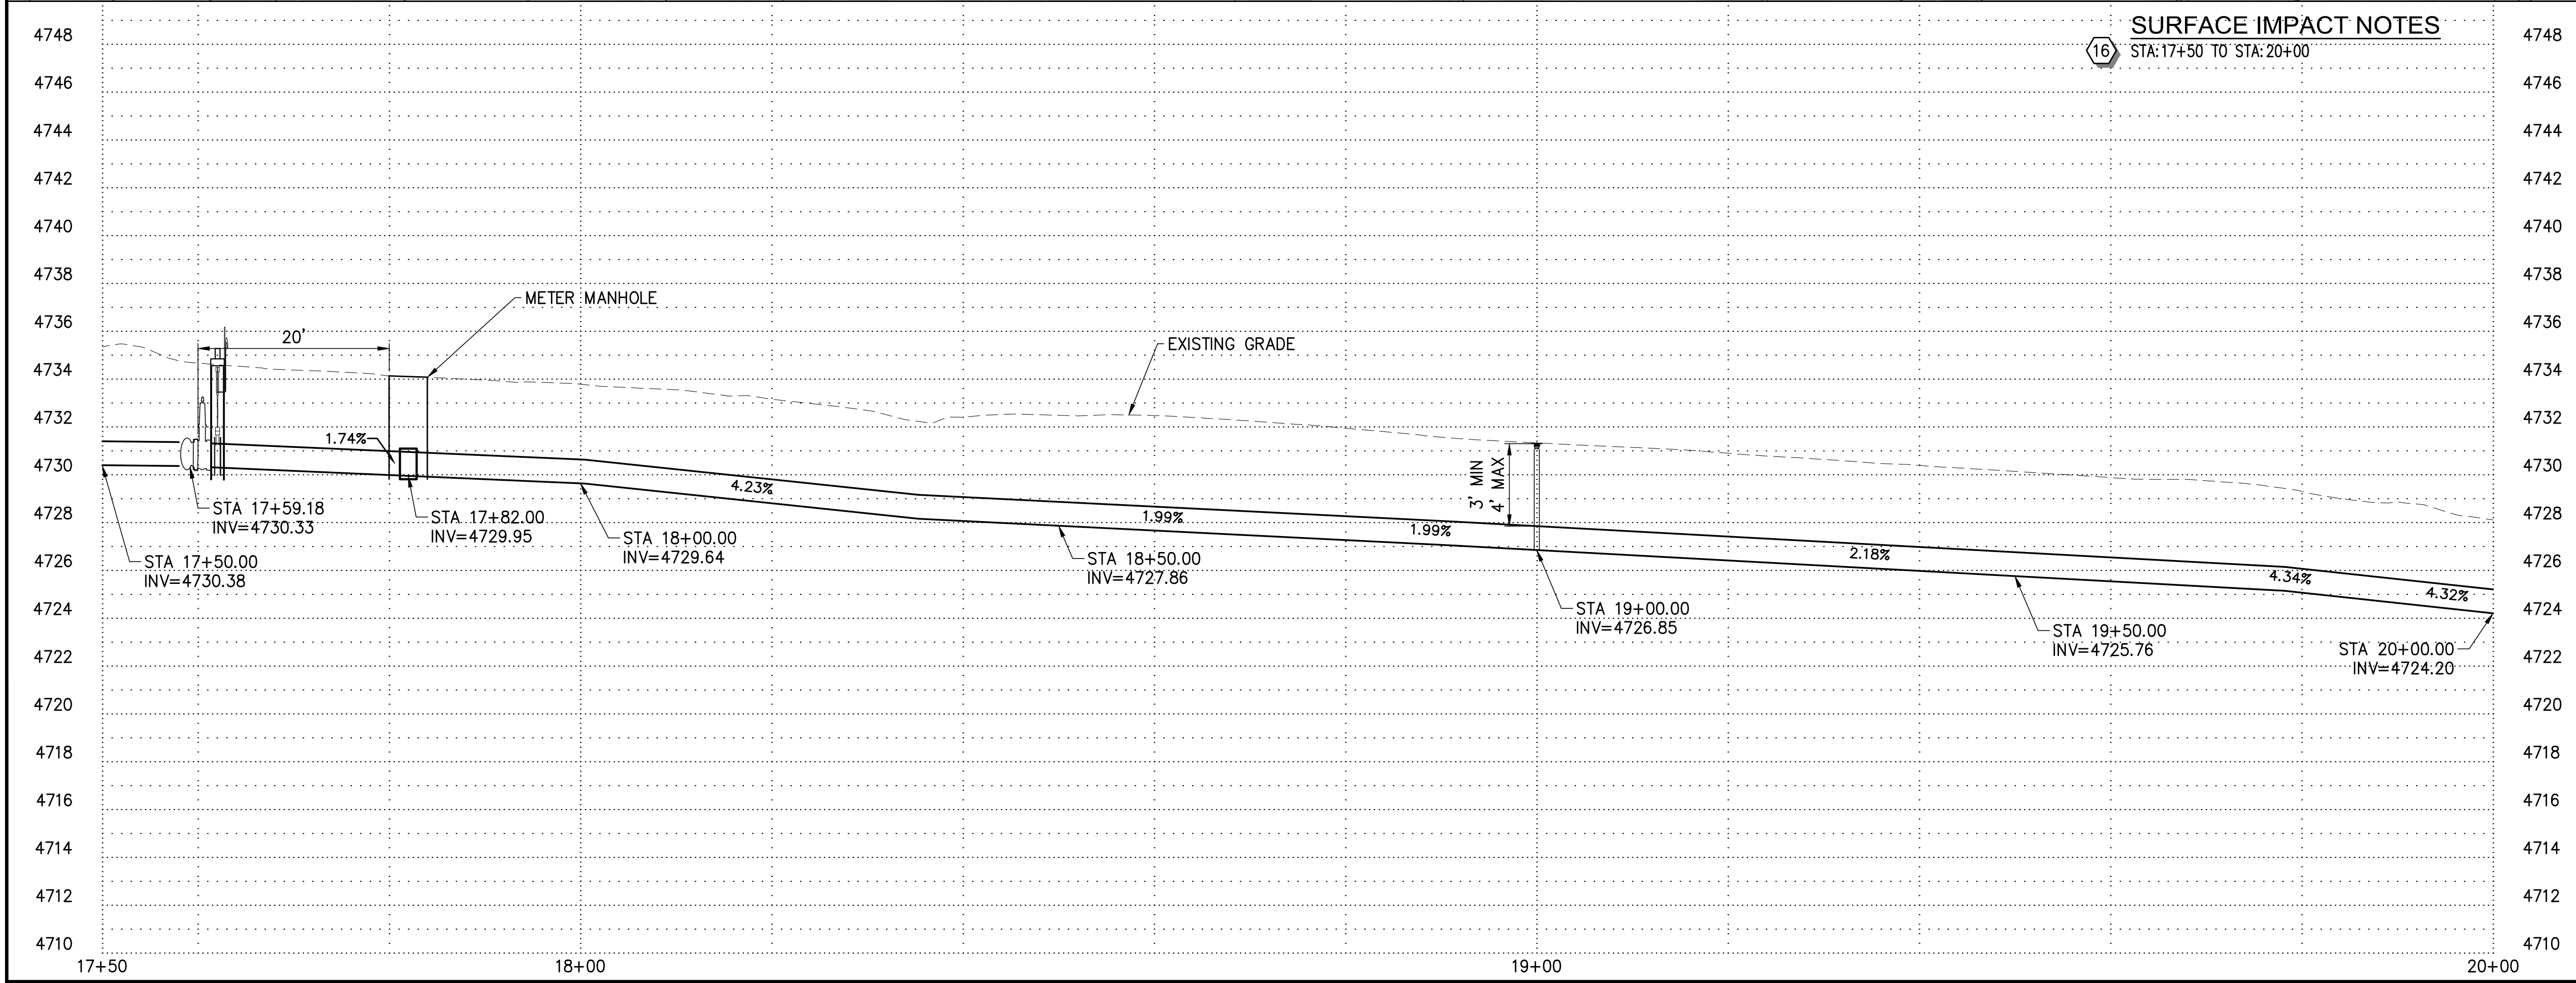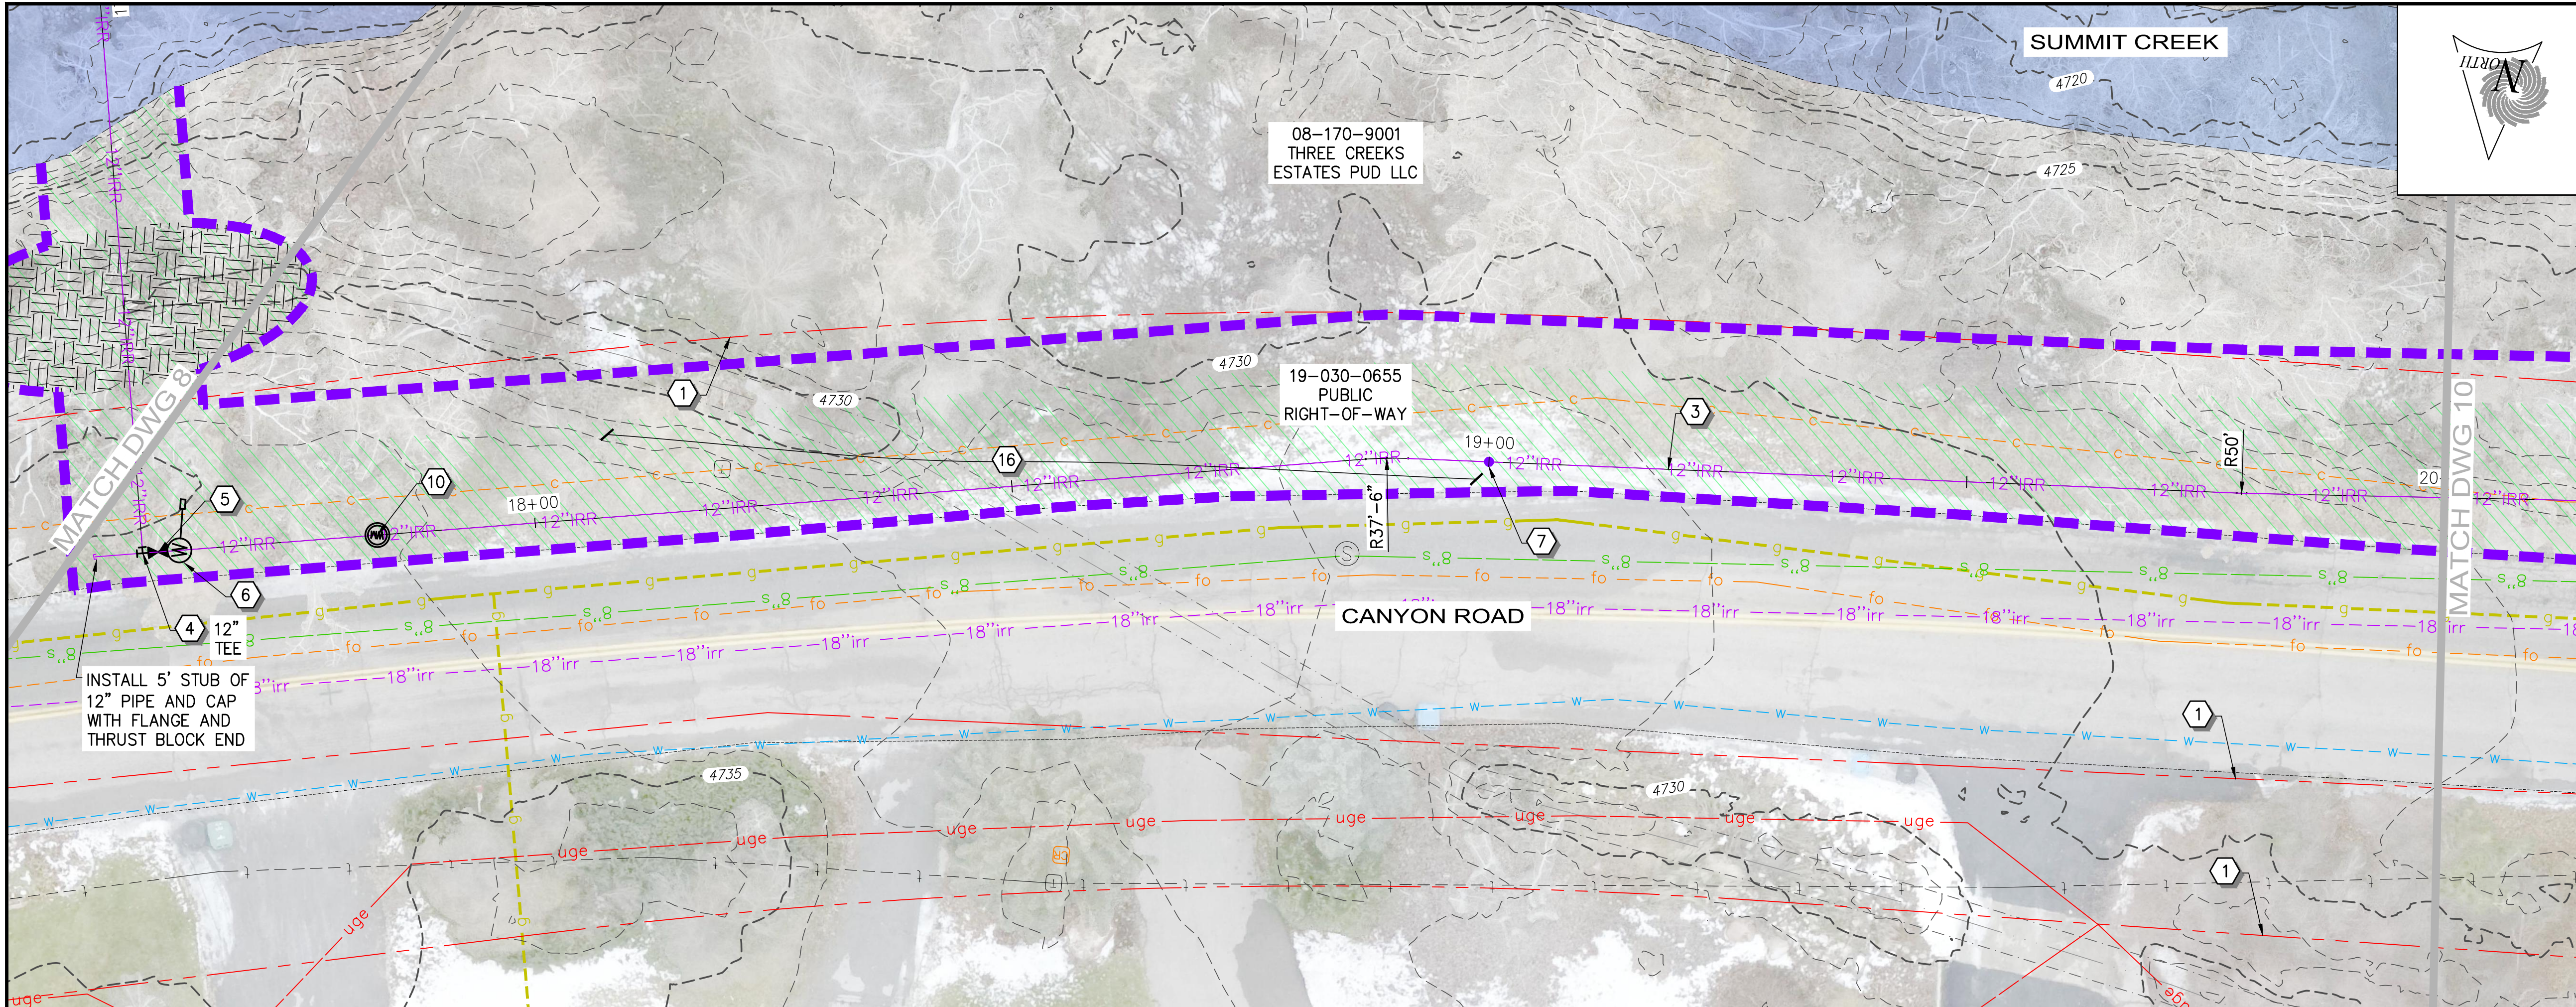

CONSTRUCTION NOTES

- 1 PROPERTY LINES
- 2 INSTALL 18" HDPE DR11 PIPE
- 3 INSTALL 12" HDPE DR11 PIPE
- 4 INSTALL FITTING PER PLAN
- 5 INSTALL ISOLATION VALVE
- 6 INSTALL AIR / VAC ASSEMBLY
- 7 INSTALL TRACER WIRE CURB BOX
- 8 INSTALL MEADOW LARK CROSSING - IN CONCRETE CULVERT, AREA SURROUNDING 12" PIPE IS TO BE CLEANED AND FILLED WITH FLOWABLE FILL - PIPE IS TO BE SECURED WITH STAINLESS STEEL STRAPS
- 9 INSTALL SUMMIT CREEK CROSSING
- 10 INSTALL METER MANHOLE
- 11 INSTALL DIRECTIONAL BORE W/ 12" HDPE DR11 PIPE - NO TRACER WIRE REQUIRED AT BORE
- 12 RESTORE AREA WITH LANDSCAPING SOD OR MATCHING LANDSCAPING LEVEL WITH SURROUNDING AREA
- 13 RESTORE AREA WITH GRAVEL MATCHING EXISTING GRAVEL SURFACE - RESTORED AREA TO HAVE 3" MIN GRAVEL
- 14 PROTECT EXISTING ROCK WALLS IN PLACE
- 15 PROTECT EXISTING CONCRETE STRUCTURE IN PLACE
- 16 VEGETATION IN AREA TO BE TRIMMED / REMOVED AS NEEDED FOR PIPE INSTALLATION
- 17 PLACE ROCKS ALONG BANK WHERE LAND OWNERS HAVE LINED THEIR BANKS
- 18 CONNECTION #1
- 19 CONNECTION #2
- 20 INSTALL 4" HDPE DR11 PIPE
- 21 INSTALL 8" HDPE DR11 PIPE
- 22 INSTALL 4" PERFORATED MANHOLE
- 23 INSTALL SERVICE CONNECTION
- 24 INFILL OLD IRRIGATION DITCH FOR 20' EAST AND WEST OF PIPE CROSSING - COMPACT TO 90%
- 25 SAWCUT ASPHALT TO PROVIDE CLEAN EDGE - REMOVE ASPALT PAVEMENT
- 26 REPLACE ASPHALT PAVEMENT
- 27 RESTORE GRAVEL DRIVEWAY
- 28 REMOVE CURB AND GUTTER OR SIDEWALK IN FULL SECTIONS
- 29 REPLACE SIDEWALK / ADA RAMP
- 30 REPLACE CURB AND GUTTER
- 31 INSTALL 8" C900 PIPE FROM REDUCER AND SPLICE INTO EXISTING PIPES W/ COUPLER
- 32 EXISTING PUMP HOUSE REPLUMBING

SURFACE IMPACT NOTES

16 STA:17+50 TO STA:20+00

SCALE
0 10' 20'

HORIZ: 1" = 10' : 22 x 34
HORIZ: 1" = 20' : 11 x 17
VERT: 1" = 4' : 22 x 34
VERT: 1" = 8' : 11 x 17

811 Know what's below.
Call before you dig.
1-800-662-4111

REV NO.	COMMENT	DATE

SUNRISE ENGINEERING

2100 NORTH MAIN STREET
NORTH LOGAN, UTAH 84341
TEL 435.563.3734
www.sunrise-eng.com

SMITHFIELD IRRIGATION COMPANY


MILL RACE PRESSURIZED PIPELINE
PRESSURIZED PIPELINE
PLAN AND PROFILE

SEI NO.	DESIGNED	DRAWN	CHECKED	SHEET NO.
12499	HP	JJ	SDW	9 of 26


PP4

BID SET

E:\Smithfield Irrigation Company\12499 - SIC Diversion System Improvements Project 2025\DWG\Sheets\SIC-D5-18-12 INCH-PP4.dwg Oct 02, 2025 4:40pm jjohey

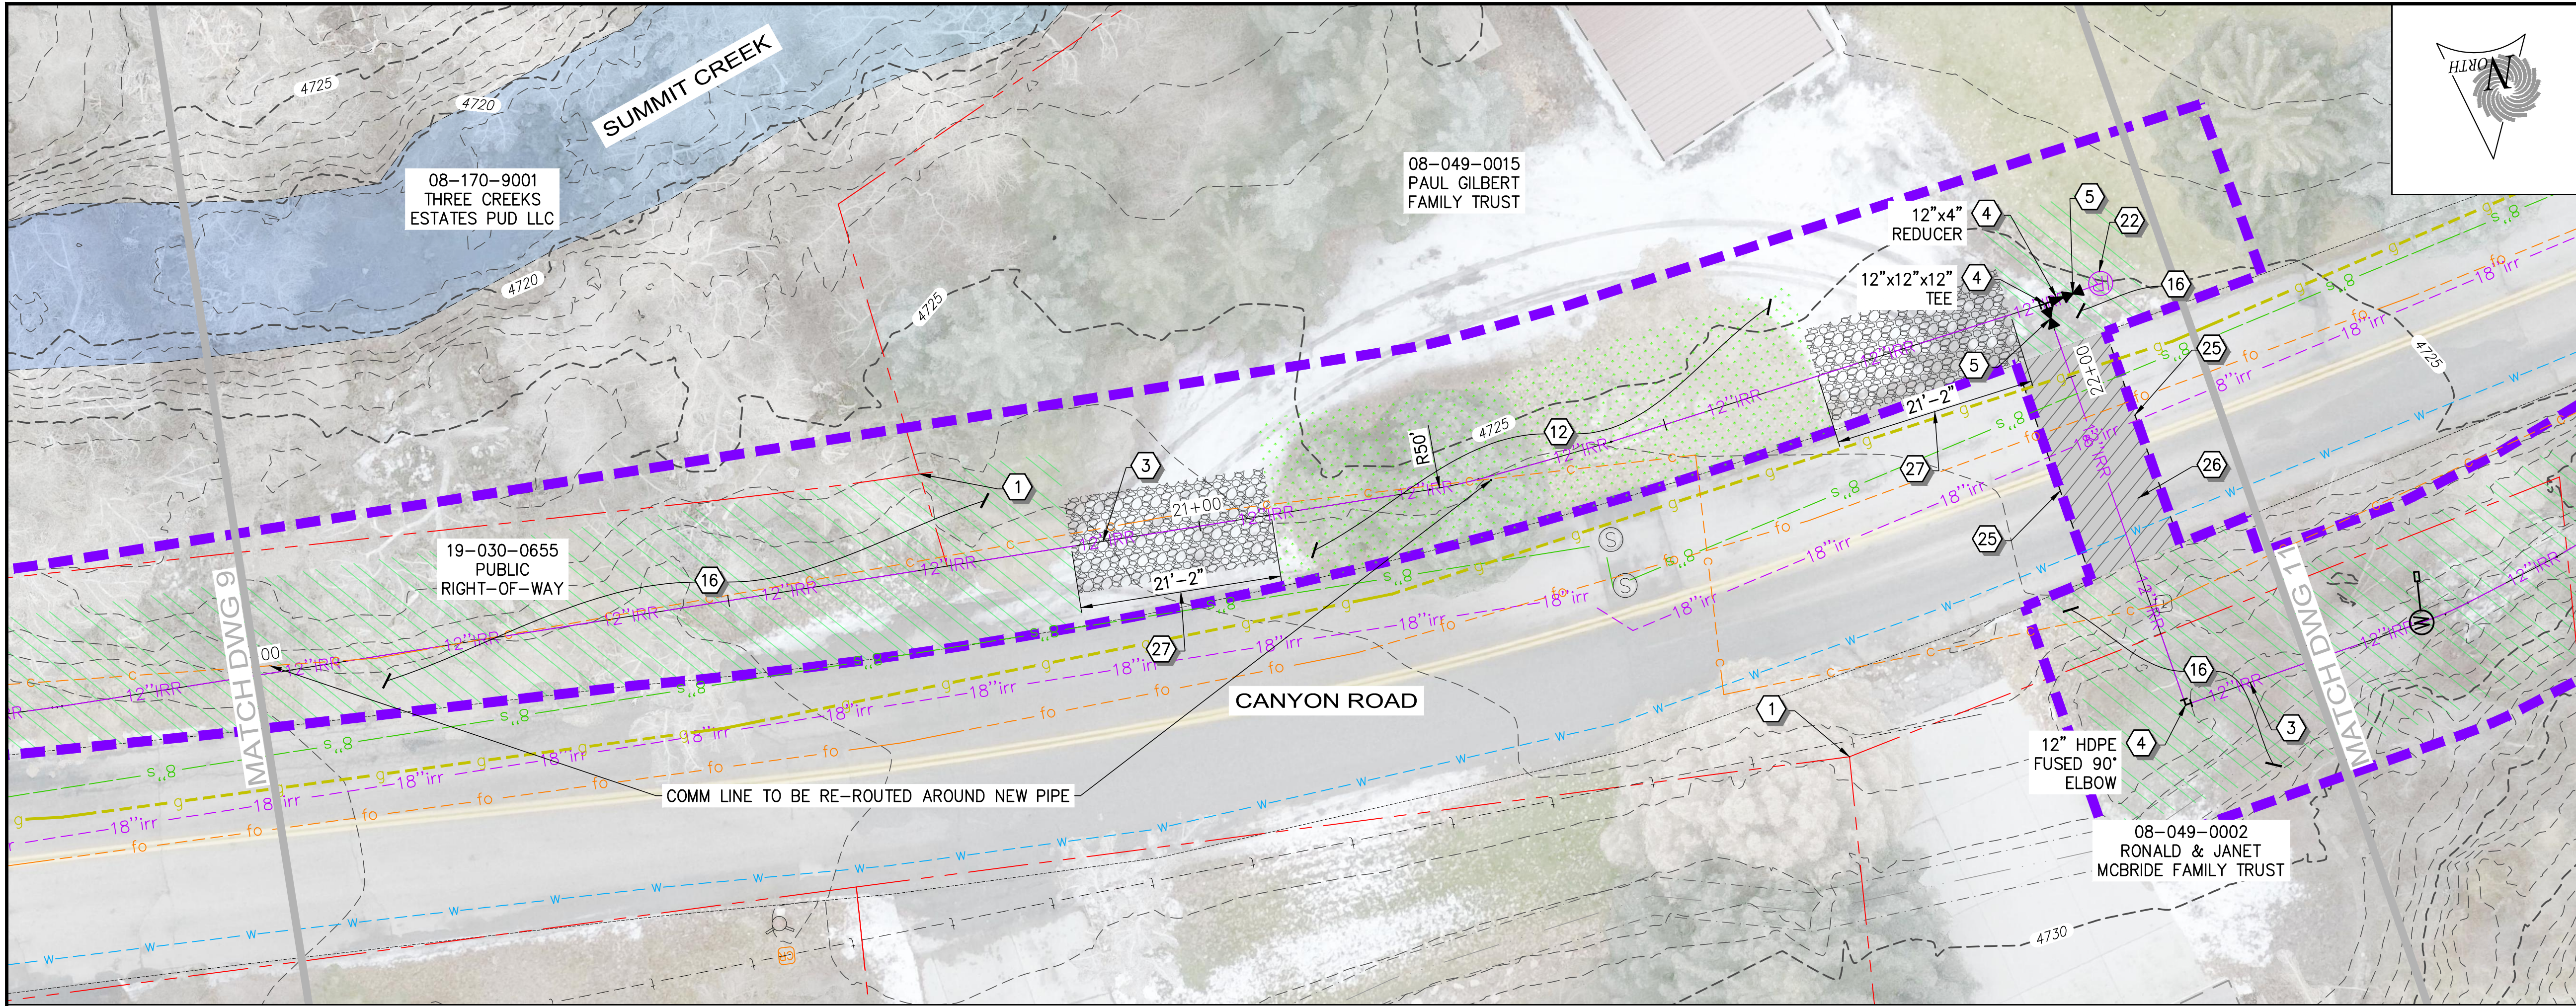

- ### CONSTRUCTION NOTES
- 1 PROPERTY LINES
 - 2 INSTALL 18" HDPE DR11 PIPE
 - 3 INSTALL 12" HDPE DR11 PIPE
 - 4 INSTALL FITTING PER PLAN
 - 5 INSTALL ISOLATION VALVE
 - 6 INSTALL AIR / VAC ASSEMBLY
 - 7 INSTALL TRACER WIRE CURB BOX
 - 8 INSTALL MEADOW LARK CROSSING - IN CONCRETE CULVERT, AREA SURROUNDING 12" PIPE IS TO BE CLEANED AND FILLED WITH FLOWABLE FILL - PIPE IS TO BE SECURED WITH STAINLESS STEEL STRAPS
 - 9 INSTALL SUMMIT CREEK CROSSING
 - 10 INSTALL METER MANHOLE
 - 11 INSTALL DIRECTIONAL BORE W/ 12" HDPE DR11 PIPE - NO TRACER WIRE REQUIRED AT BORE
 - 12 RESTORE AREA WITH LANDSCAPING SOD OR MATCHING LANDSCAPING LEVEL WITH SURROUNDING AREA
 - 13 RESTORE AREA WITH GRAVEL MATCHING EXISTING GRAVEL SURFACE - RESTORED AREA TO HAVE 3" MIN GRAVEL
 - 14 PROTECT EXISTING ROCK WALLS IN PLACE
 - 15 PROTECT EXISTING CONCRETE STRUCTURE IN PLACE
 - 16 VEGETATION IN AREA TO BE TRIMMED / REMOVED AS NEEDED FOR PIPE INSTALLATION
 - 17 PLACE ROCKS ALONG BANK WHERE LAND OWNERS HAVE LINED THEIR BANKS
 - 18 CONNECTION #1
 - 19 CONNECTION #2
 - 20 INSTALL 4" HDPE DR11 PIPE
 - 21 INSTALL 8" HDPE DR11 PIPE
 - 22 INSTALL 4" PERFORATED MANHOLE
 - 23 INSTALL SERVICE CONNECTION
 - 24 INFILL OLD IRRIGATION DITCH FOR 20' EAST AND WEST OF PIPE CROSSING - COMPACT TO 90%
 - 25 SAWCUT ASPHALT TO PROVIDE CLEAN EDGE - REMOVE ASPHALT PAVEMENT
 - 26 REPLACE ASPHALT PAVEMENT
 - 27 RESTORE GRAVEL DRIVEWAY
 - 28 REMOVE CURB AND GUTTER OR SIDEWALK IN FULL SECTIONS
 - 29 REPLACE SIDEWALK / ADA RAMP
 - 30 REPLACE CURB AND GUTTER
 - 31 INSTALL 8" C900 PIPE FROM REDUCER AND SPLICE INTO EXISTING PIPES W/ COUPLER
 - 32 EXISTING PUMP HOUSE REPLUMBING

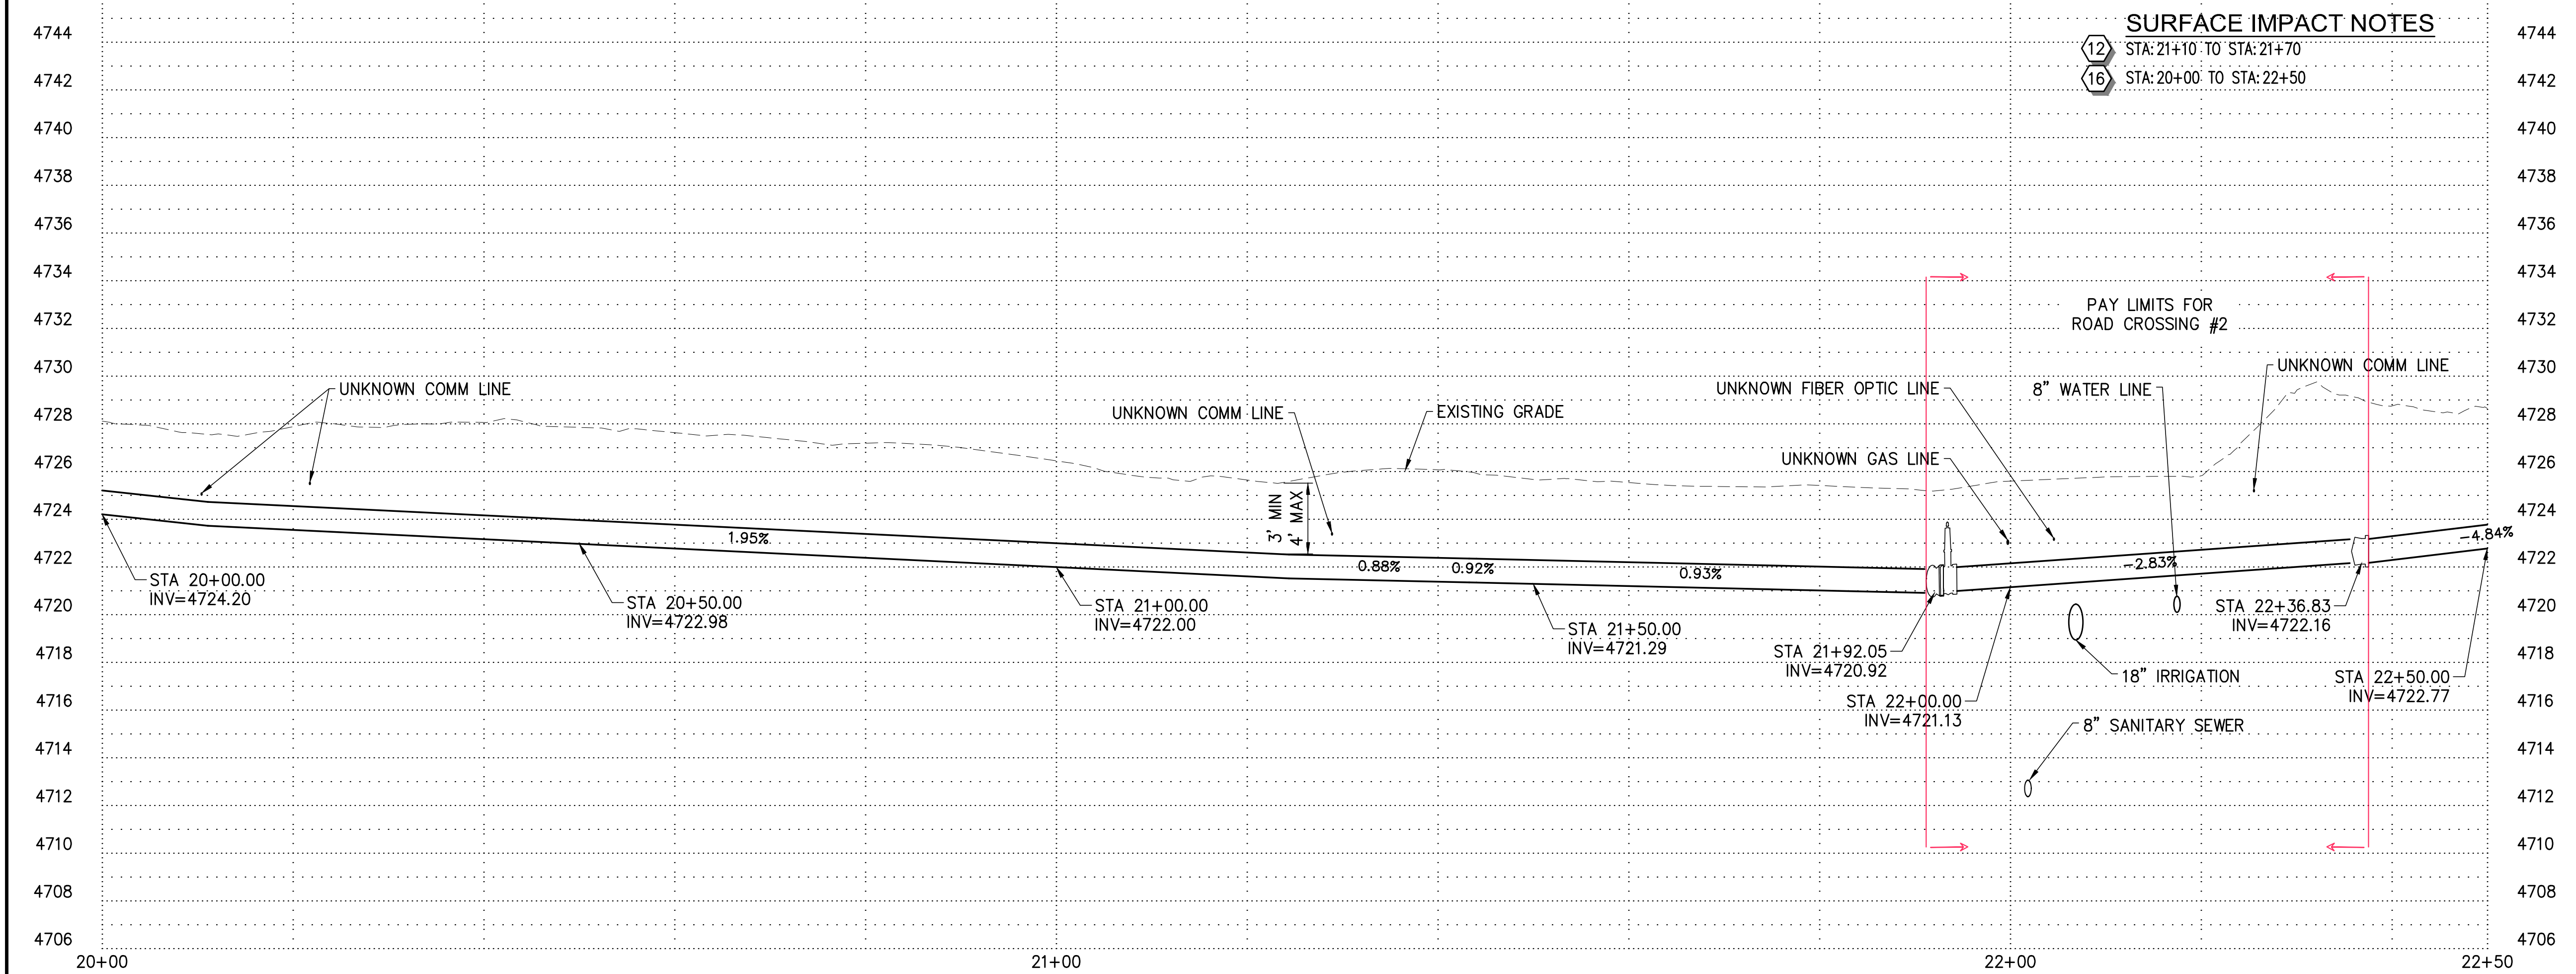

SURFACE IMPACT NOTES

- 12 STA: 21+10 TO STA: 21+70
- 16 STA: 20+00 TO STA: 22+50

SCALE
0 10' 20'

HORIZ: 1" = 10' : 22 x 34
HORIZ: 1" = 20' : 11 x 17
VERT: 1" = 4' : 22 x 34
VERT: 1" = 8' : 11 x 17

811 Know what's below.
Call before you dig.
1-800-662-4111

REV NO.	COMMENT	DATE

SUNRISE ENGINEERING
2100 NORTH MAIN STREET
NORTH LOGAN, UTAH 84341
TEL 435.563.3734
www.sunrise-eng.com

SMITHFIELD IRRIGATION COMPANY

MILL RACE PRESSURIZED PIPELINE



PRESSURIZED PIPELINE

PLAN AND PROFILE

SEI NO.	DESIGNED	DRAWN	CHECKED	SHEET NO.	
12499	HP	JJ	SDW	10 of 26	PP5

BID SET

E:\Smithfield Irrigation Company\12499 - SIC Diversion System Improvements Project 2025\DWG\Sheets\SIC-D5-18-18-12 INCH-PP5.dwg Oct 02, 2025 4:41pm jjoiley

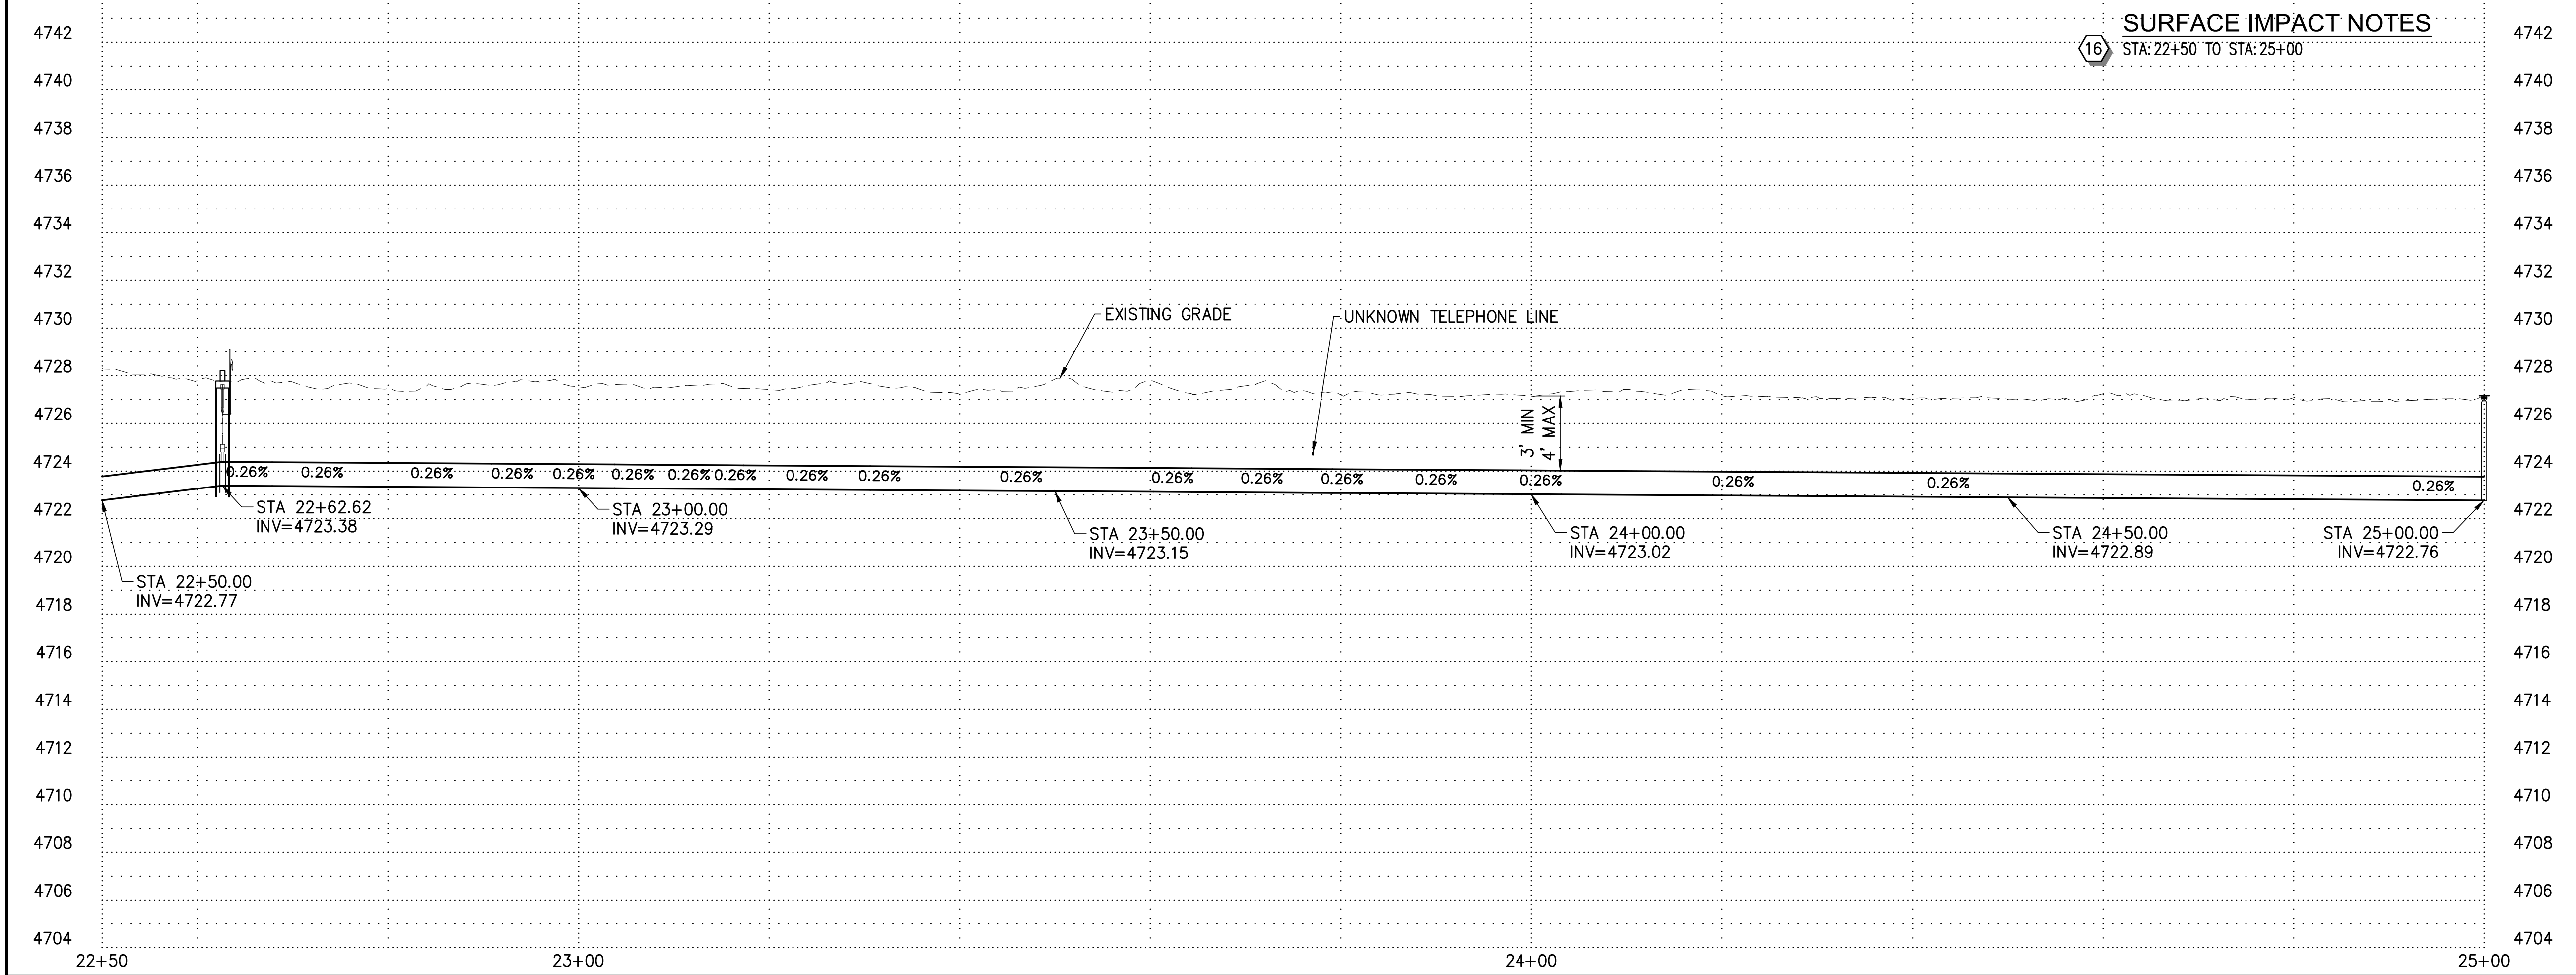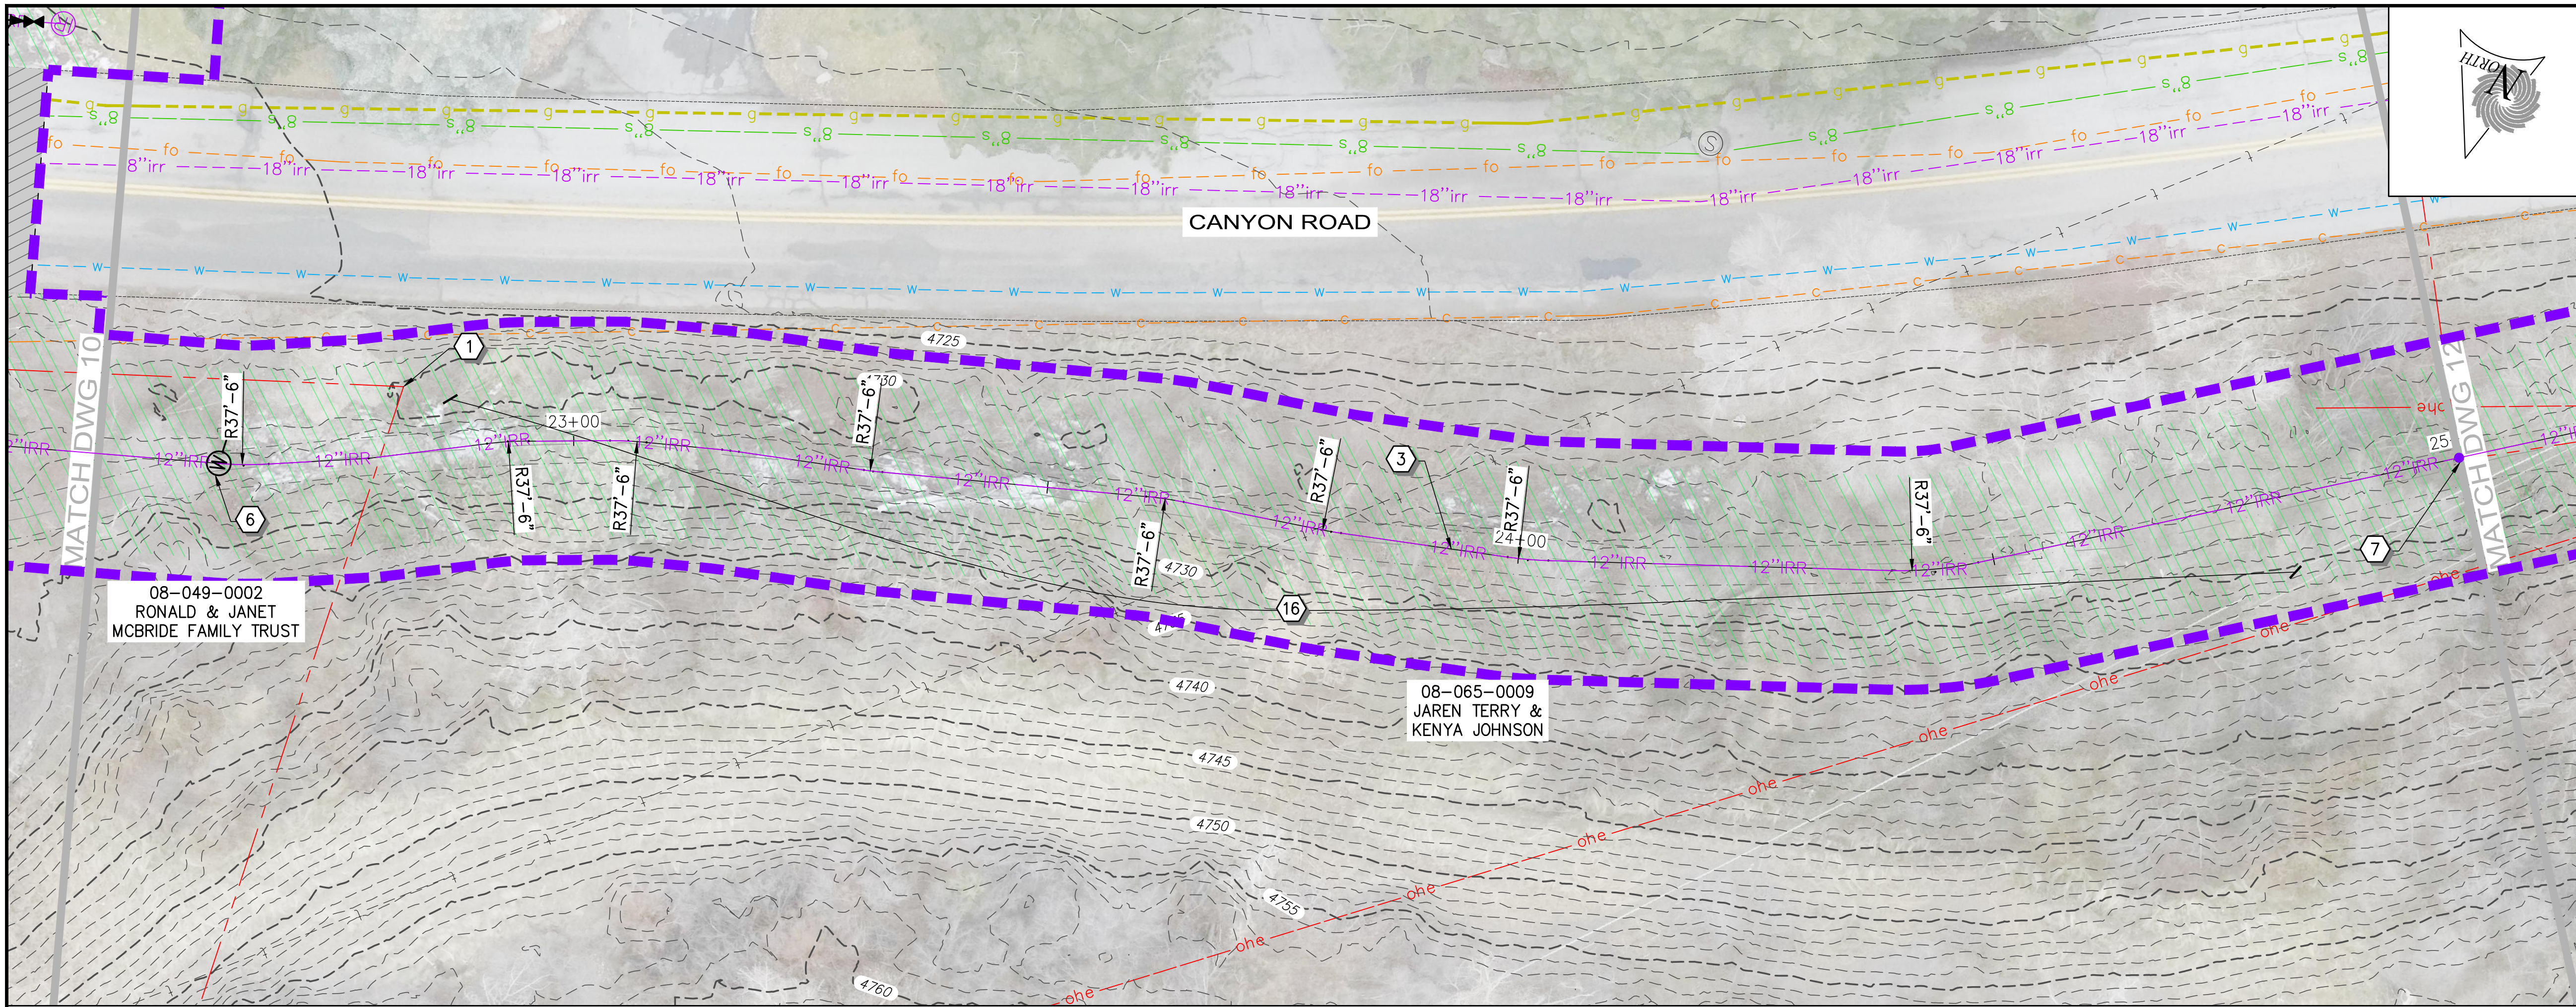

CONSTRUCTION NOTES


- 1 PROPERTY LINES
- 2 INSTALL 18" HDPE DR11 PIPE
- 3 INSTALL 12" HDPE DR11 PIPE
- 4 INSTALL FITTING PER PLAN
- 5 INSTALL ISOLATION VALVE
- 6 INSTALL AIR / VAC ASSEMBLY
- 7 INSTALL TRACER WIRE CURB BOX
- 8 INSTALL MEADOW LARK CROSSING - IN CONCRETE CULVERT, AREA SURROUNDING 12" PIPE IS TO BE CLEANED AND FILLED WITH FLOWABLE FILL - PIPE IS TO BE SECURED WITH STAINLESS STEEL STRAPS
- 9 INSTALL SUMMIT CREEK CROSSING
- 10 INSTALL METER MANHOLE
- 11 INSTALL DIRECTIONAL BORE W/ 12" HDPE DR11 PIPE - NO TRACER WIRE REQUIRED AT BORE
- 12 RESTORE AREA WITH LANDSCAPING SOD OR MATCHING LANDSCAPING LEVEL WITH SURROUNDING AREA
- 13 RESTORE AREA WITH GRAVEL MATCHING EXISTING GRAVEL SURFACE - RESTORED AREA TO HAVE 3" MIN GRAVEL
- 14 PROTECT EXISTING ROCK WALLS IN PLACE
- 15 PROTECT EXISTING CONCRETE STRUCTURE IN PLACE
- 16 VEGETATION IN AREA TO BE TRIMMED / REMOVED AS NEEDED FOR PIPE INSTALLATION
- 17 PLACE ROCKS ALONG BANK WHERE LAND OWNERS HAVE LINED THEIR BANKS
- 18 CONNECTION #1
- 19 CONNECTION #2
- 20 INSTALL 4" HDPE DR11 PIPE
- 21 INSTALL 8" HDPE DR11 PIPE
- 22 INSTALL 4" PERFORATED MANHOLE
- 23 INSTALL SERVICE CONNECTION
- 24 INFILL OLD IRRIGATION DITCH FOR 20' EAST AND WEST OF PIPE CROSSING - COMPACT TO 90%
- 25 SAWCUT ASPHALT TO PROVIDE CLEAN EDGE - REMOVE ASPHALT PAVEMENT
- 26 REPLACE ASPHALT PAVEMENT
- 27 RESTORE GRAVEL DRIVEWAY
- 28 REMOVE CURB AND GUTTER OR SIDEWALK IN FULL SECTIONS
- 29 REPLACE SIDEWALK / ADA RAMP
- 30 REPLACE CURB AND GUTTER
- 31 INSTALL 8" C900 PIPE FROM REDUCER AND SPLICE INTO EXISTING PIPES W/ COUPLER
- 32 EXISTING PUMP HOUSE REPLUMBING

SURFACE IMPACT NOTES

16 STA: 22+50 TO STA: 25+00

SCALE
0 10' 20'
HORIZ: 1" = 10' : 22 x 34
HORIZ: 1" = 20' : 11 x 17
VERT: 1" = 4' : 22 x 34
VERT: 1" = 8' : 11 x 17

811 Know what's below.
Call before you dig.
1-800-662-4111


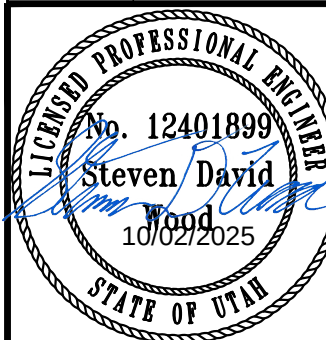


SUNRISE
ENGINEERING


2100 NORTH MAIN STREET
NORTH LOGAN, UTAH 84341
TEL 435.563.3734
www.sunrise-eng.com



SMITHFIELD IRRIGATION COMPANY
MILL RACE PRESSURIZED PIPELINE
PRESSURIZED PIPELINE
PLAN AND PROFILE

REV. NO.	DESIGNED	DRAWN	CHECKED	SHEET NO.	
12499	HP	JJ	SDW	11 of 26	PP6

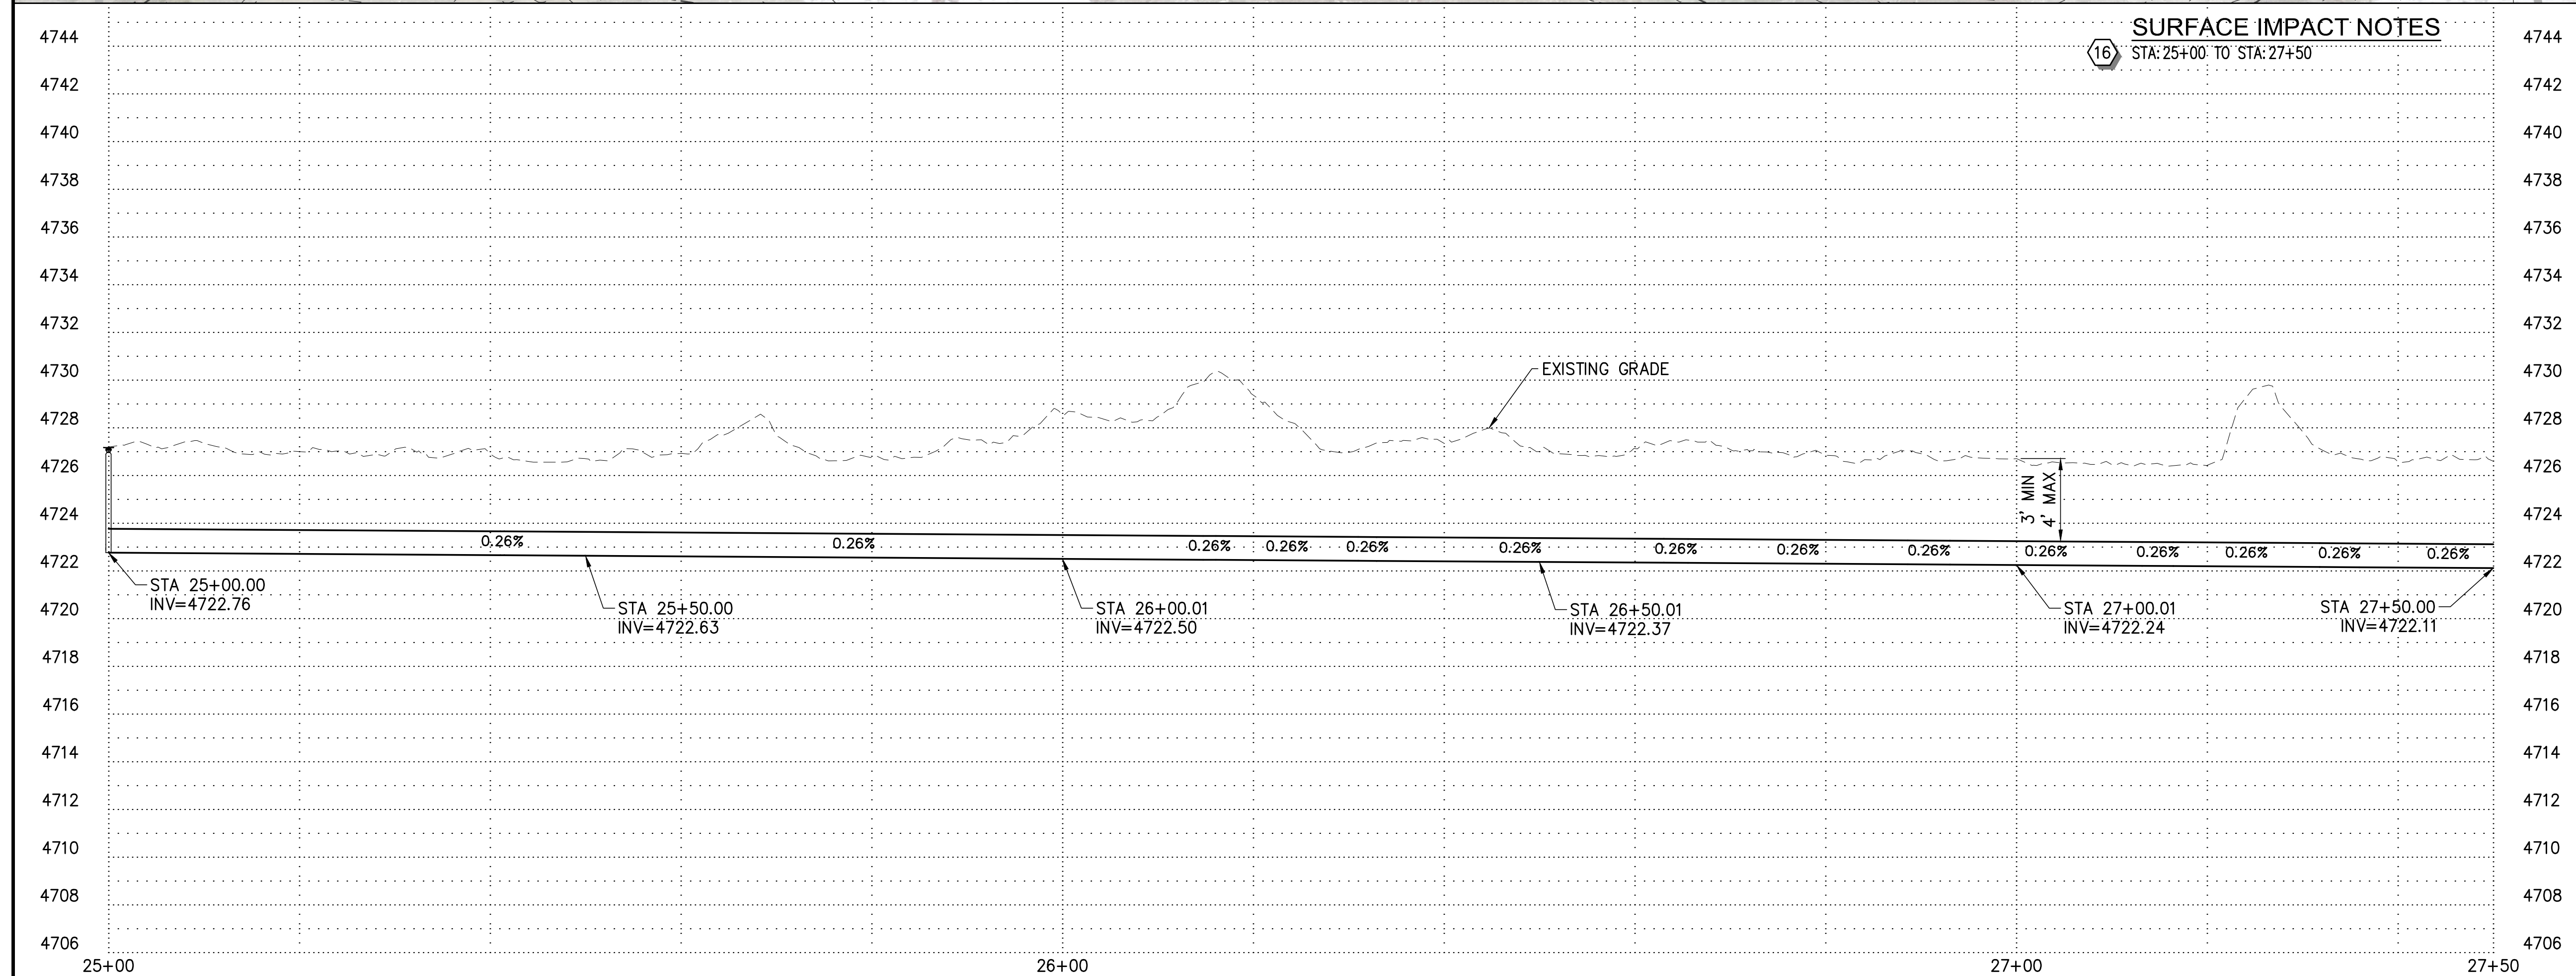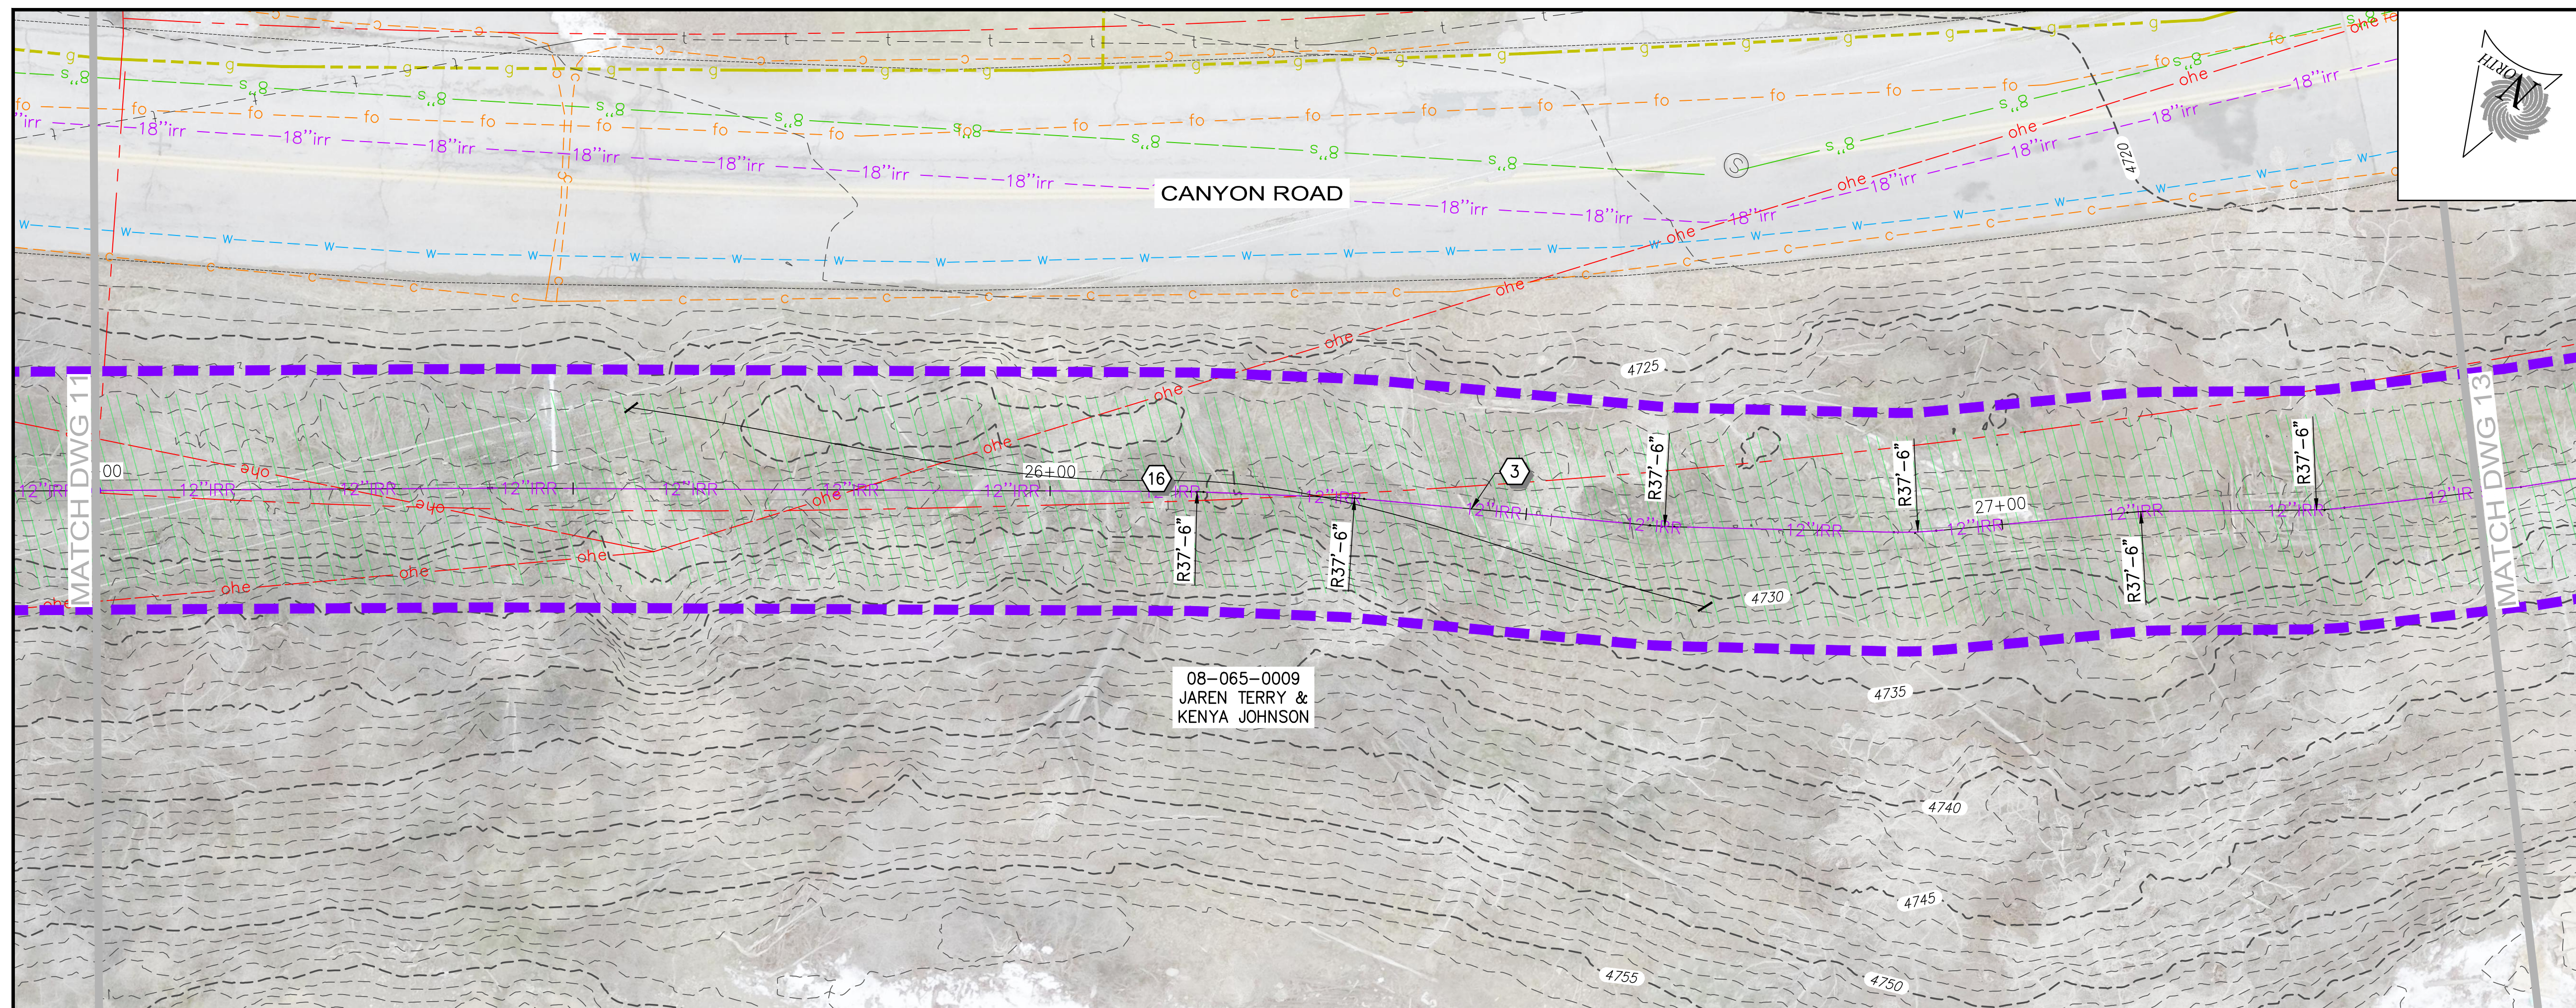


- ## CONSTRUCTION NOTES
- 1 PROPERTY LINES
 - 2 INSTALL 18" HDPE DR11 PIPE (A,B,C)
D1
 - 3 INSTALL 12" HDPE DR11 PIPE (A,B,C)
D1
 - 4 INSTALL FITTING PER PLAN
 - 5 INSTALL ISOLATION VALVE (D)
D1
 - 6 INSTALL AIR / VAC ASSEMBLY (E)
D1
 - 7 INSTALL TRACER WIRE CURB BOX (G)
D1
 - 8 INSTALL MEADOW LARK CROSSING – IN CONCRETE CULVERT, AREA SURROUNDING 12" PIPE IS TO BE CLEANED AND FILLED WITH FLOWABLE FILL. PIPE IS TO BE SECURED WITH STAINLESS STEEL STRAPS (F)
D1
 - 9 INSTALL SUMMIT CREEK CROSSING (K)
D1
 - 10 INSTALL METER MANHOLE (E)
D2
 - 11 INSTALL DIRECTIONAL BORE W/ 12" HDPE DR11 PIPE – NO TRACER WIRE REQUIRED AT BORE
 - 12 RESTORE AREA WITH LANDSCAPING SOD OR MATCHING LANDSCAPING LEVEL WITH SURROUNDING AREA
 - 13 RESTORE AREA WITH GRAVEL MATCHING EXISTING GRAVEL SURFACE – RESTORED AREA TO HAVE 3" MIN GRAVEL
 - 14 PROTECT EXISTING ROCK WALLS IN PLACE
 - 15 PROTECT EXISTING CONCRETE STRUCTURE IN PLACE
 - 16 VEGETATION IN AREA TO BE TRIMMED / REMOVED AS NEEDED FOR PIPE INSTALLATION
 - 17 PLACE ROCKS ALONG BANK WHERE LAND OWNERS HAVE LINED THEIR BANKS
 - 18 CONNECTION #1 (H)
D1
 - 19 CONNECTION #2 (J)
D1
 - 20 INSTALL 4" HDPE DR11 PIPE (A,B,C)
D1
 - 21 INSTALL 8" HDPE DR11 PIPE (A,B,C)
D1
 - 22 INSTALL 4" PERFORATED MANHOLE (A,B)
D2
 - 23 INSTALL SERVICE CONNECTION (D)
D3
 - 24 INFILL OLD IRRIGATION DITCH FOR 20' EAST AND WEST OF PIPE CROSSING – COMPACT TO 90%
 - 25 SAWCUT ASPHALT TO PROVIDE CLEAN EDGE – REMOVE ASPALT PAVEMENT
 - 26 REPLACE ASPHALT PAVEMENT (C)
D2
 - 27 RESTORE GRAVEL DRIVEWAY (C)
D3
 - 28 REMOVE CURB AND GUTTER OR SIDEWALK IN FULL SECTIONS
 - 29 REPLACE SIDEWALK / ADA RAMP (A)
D3
 - 30 REPLACE CURB AND GUTTER (B)
D3
 - 31 INSTALL 8" C900 PIPE FROM REDUCER AND SPLICE INTO EXISTING PIPES W/ COUPLER (A,B,C)
D1
 - 32 EXISTING PUMP HOUSE REPLUMBING (A)
D5
- 2025 DWG Sheets (SIC-DSI-18-12 INCH-PP7.dwg Oct. 02, 2025 4:33pm Jolley

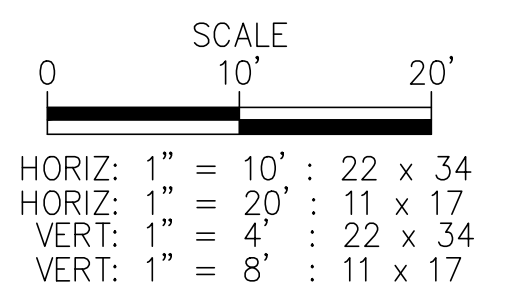[illegible]

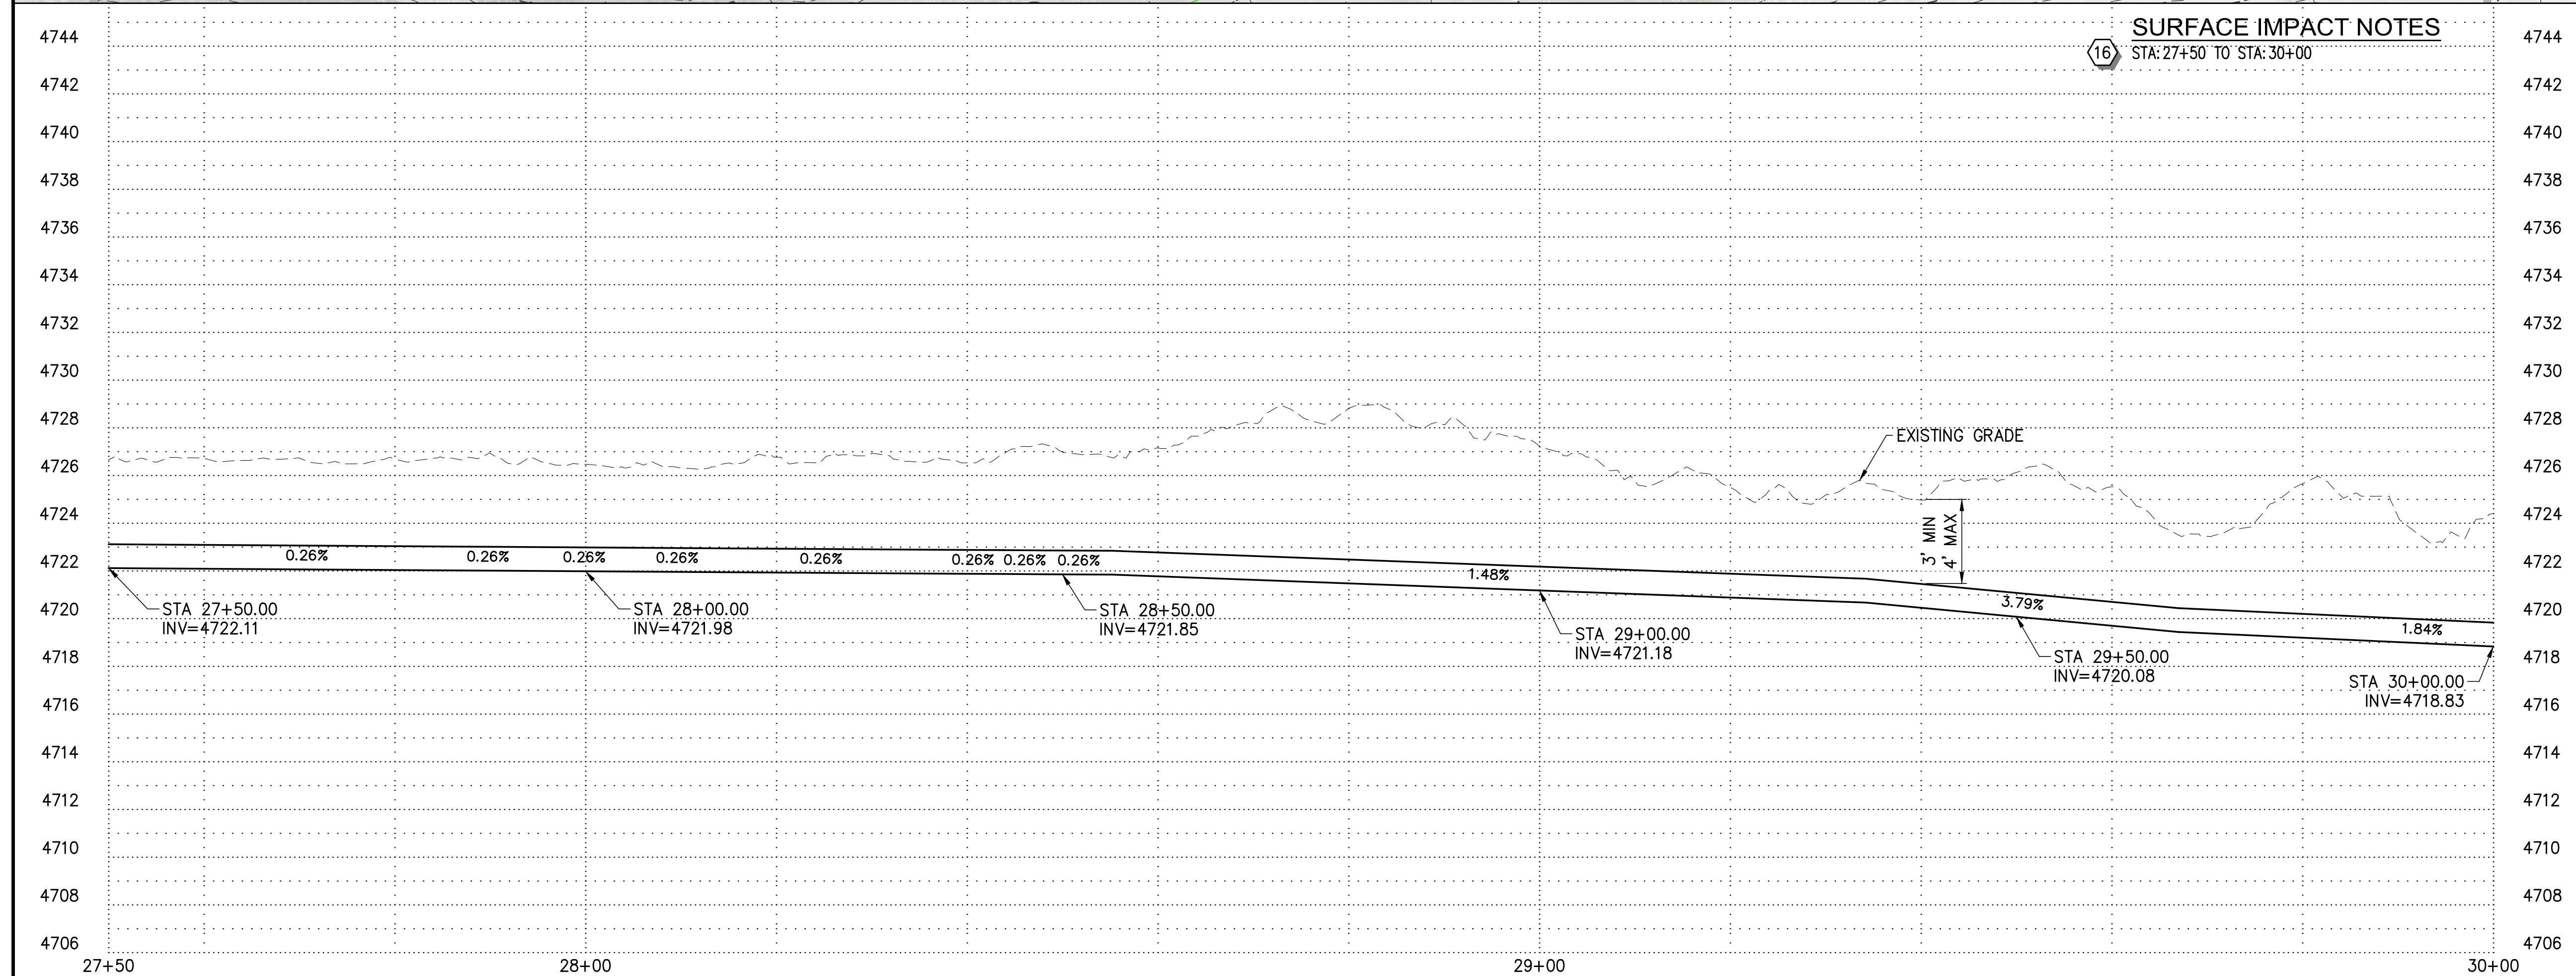
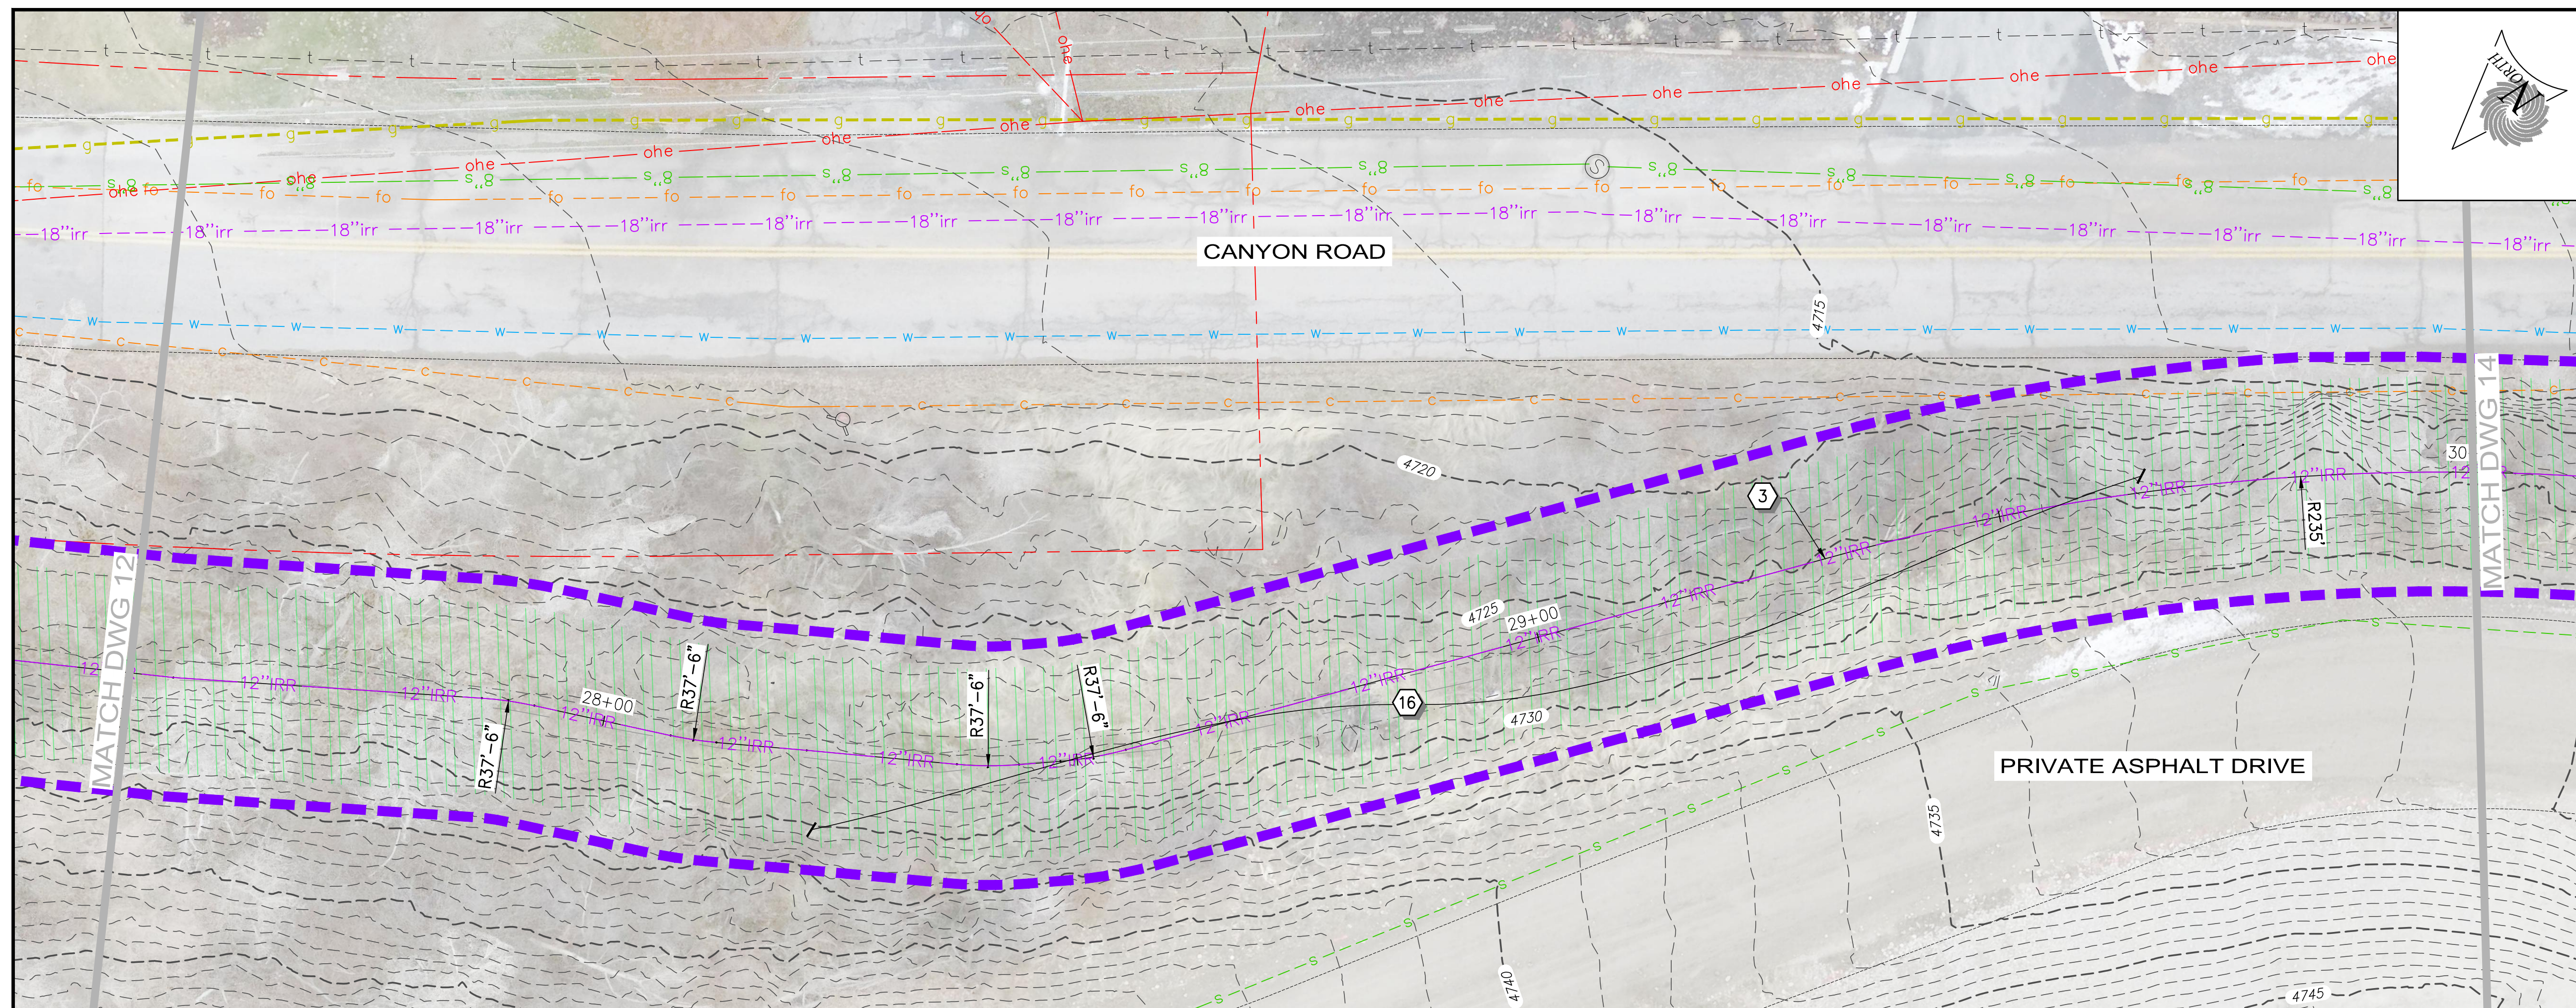


- ## CONSTRUCTION NOTES
- 1 PROPERTY LINES
 - 2 INSTALL 18" HDPE DR11 PIPE (A,B,C)
D1
 - 3 INSTALL 12" HDPE DR11 PIPE (A,B,C)
D1
 - 4 INSTALL FITTING PER PLAN
 - 5 INSTALL ISOLATION VALVE (D)
D1
 - 6 INSTALL AIR / VAC ASSEMBLY (E)
D1
 - 7 INSTALL TRACER WIRE CURB BOX (G)
D1
 - 8 INSTALL MEADOW LARK CROSSING – IN CONCRETE CULVERT, AREA SURROUNDING 12" PIPE IS TO BE CLEANED AND FILLED WITH FLOWABLE FILL. PIPE IS TO BE SECURED WITH STAINLESS STEEL STRAPS (F)
D1
 - 9 INSTALL SUMMIT CREEK CROSSING (K)
D1
 - 10 INSTALL METER MANHOLE (E)
D2
 - 11 INSTALL DIRECTIONAL BORE W/ 12" HDPE DR11 PIPE – NO TRACER WIRE REQUIRED AT BORE
 - 12 RESTORE AREA WITH LANDSCAPING SOD OR MATCHING LANDSCAPING LEVEL WITH SURROUNDING AREA
 - 13 RESTORE AREA WITH GRAVEL MATCHING EXISTING GRAVEL SURFACE – RESTORED AREA TO HAVE 3" MIN GRAVEL
 - 14 PROTECT EXISTING ROCK WALLS IN PLACE
 - 15 PROTECT EXISTING CONCRETE STRUCTURE IN PLACE
 - 16 VEGETATION IN AREA TO BE TRIMMED / REMOVED AS NEEDED FOR PIPE INSTALLATION
 - 17 PLACE ROCKS ALONG BANK WHERE LAND OWNERS HAVE LINED THEIR BANKS
 - 18 CONNECTION #1 (H)
D1
 - 19 CONNECTION #2 (J)
D1
 - 20 INSTALL 4" HDPE DR11 PIPE (A,B,C)
D1
 - 21 INSTALL 8" HDPE DR11 PIPE (A,B,C)
D1
 - 22 INSTALL 4" PERFORATED MANHOLE (A,B)
D2
 - 23 INSTALL SERVICE CONNECTION (D)
D3
 - 24 INFILL OLD IRRIGATION DITCH FOR 20' EAST AND WEST OF PIPE CROSSING – COMPACT TO 90%
 - 25 SAWCUT ASPHALT TO PROVIDE CLEAN EDGE – REMOVE ASPALT PAVEMENT
 - 26 REPLACE ASPHALT PAVEMENT (C)
D2
 - 27 RESTORE GRAVEL DRIVEWAY (C)
D3
 - 28 REMOVE CURB AND GUTTER OR SIDEWALK IN FULL SECTIONS
 - 29 REPLACE SIDEWALK / ADA RAMP (A)
D3
 - 30 REPLACE CURB AND GUTTER (B)
D3
 - 31 INSTALL 8" C900 PIPE FROM REDUCER AND SPLICE INTO EXISTING PIPES W/ COUPLER (A,B,C)
D1
 - 32 EXISTING PUMP HOUSE REPLUMBING (A)
D5
- R1D SET
- 2025 DWG Sheets (SIC-18-12-INCH-PPB.dwg Oct. 2025 4:44pm Jolley)

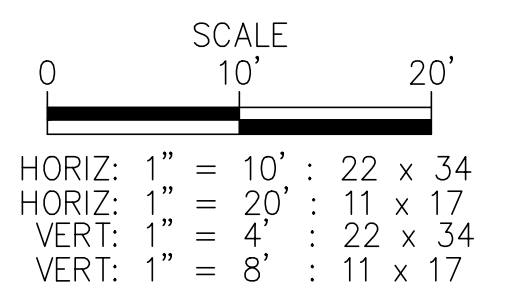[illegible]


BID SET

P:\Smithfield Irrigation Company\12499 - SIC Diversion System Improvements Project 2025\DWG\Sheets\SIC-DSI-18-12 INCH-PP8.dwg Oct 02, 2025 4:44pm jjolley

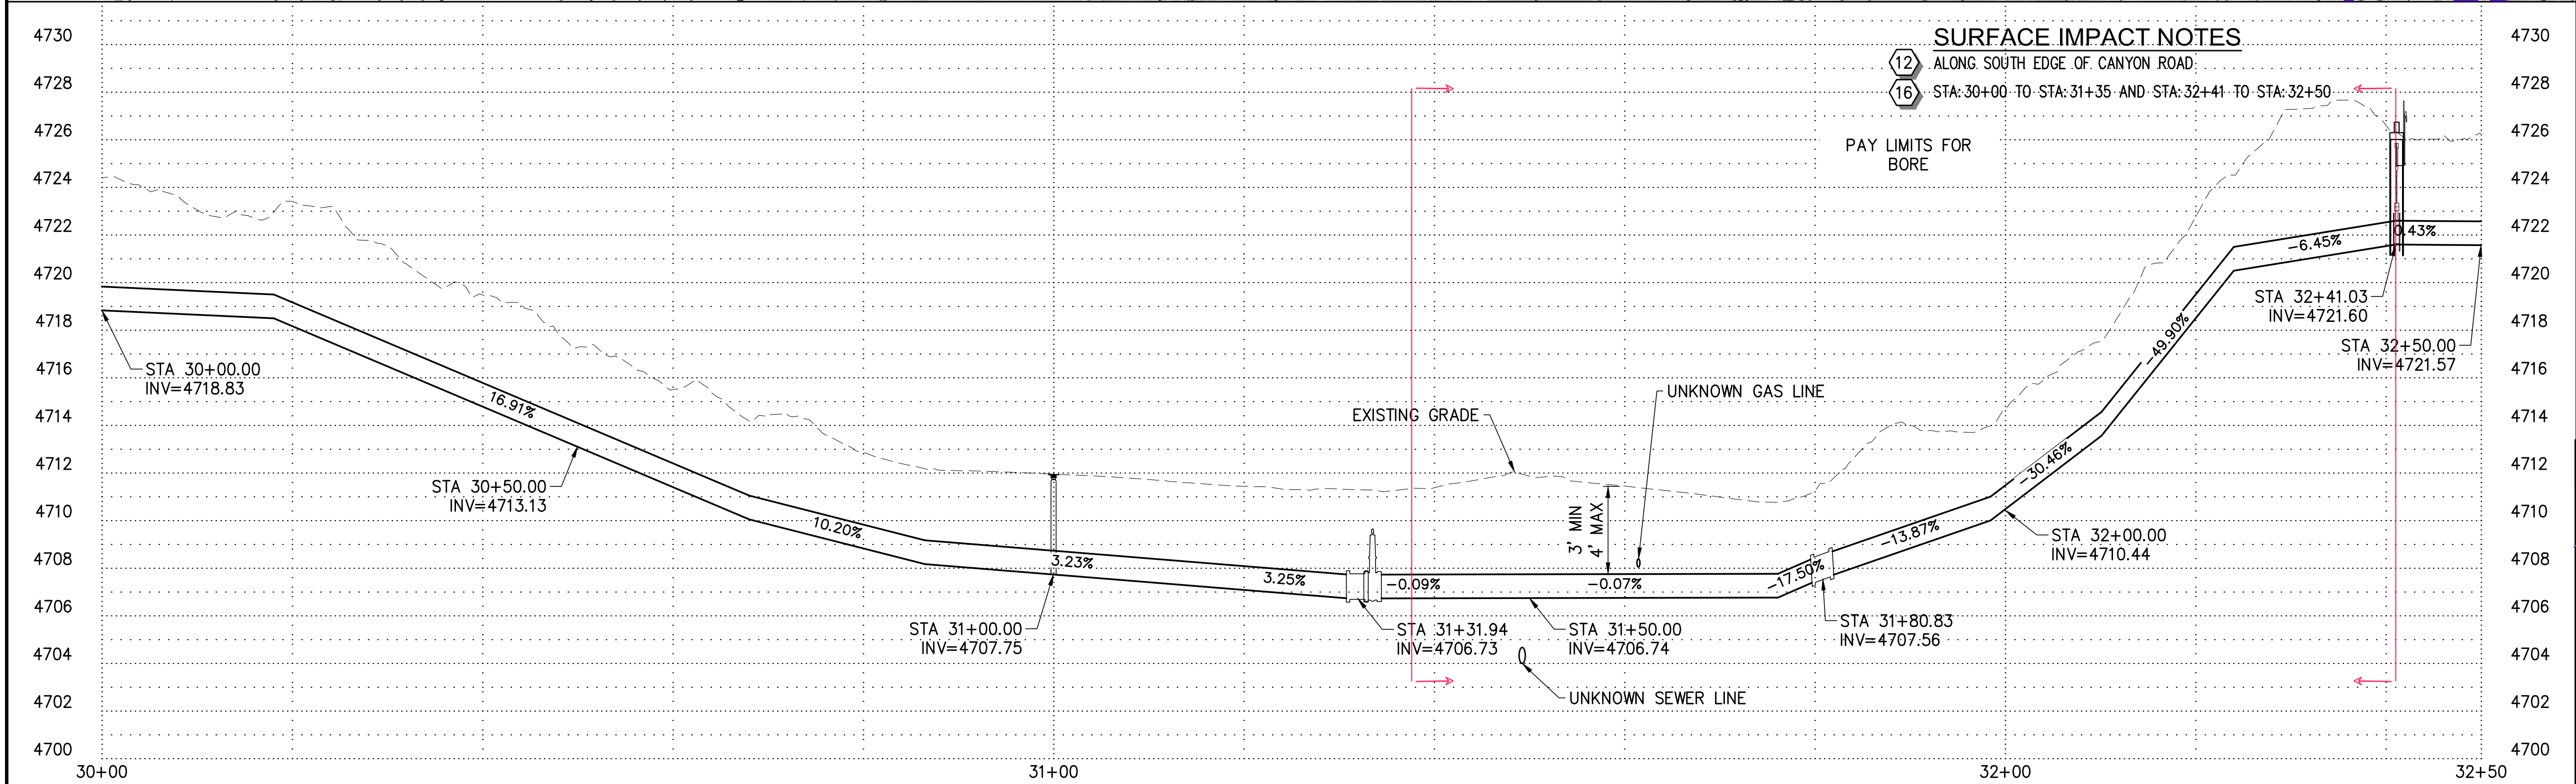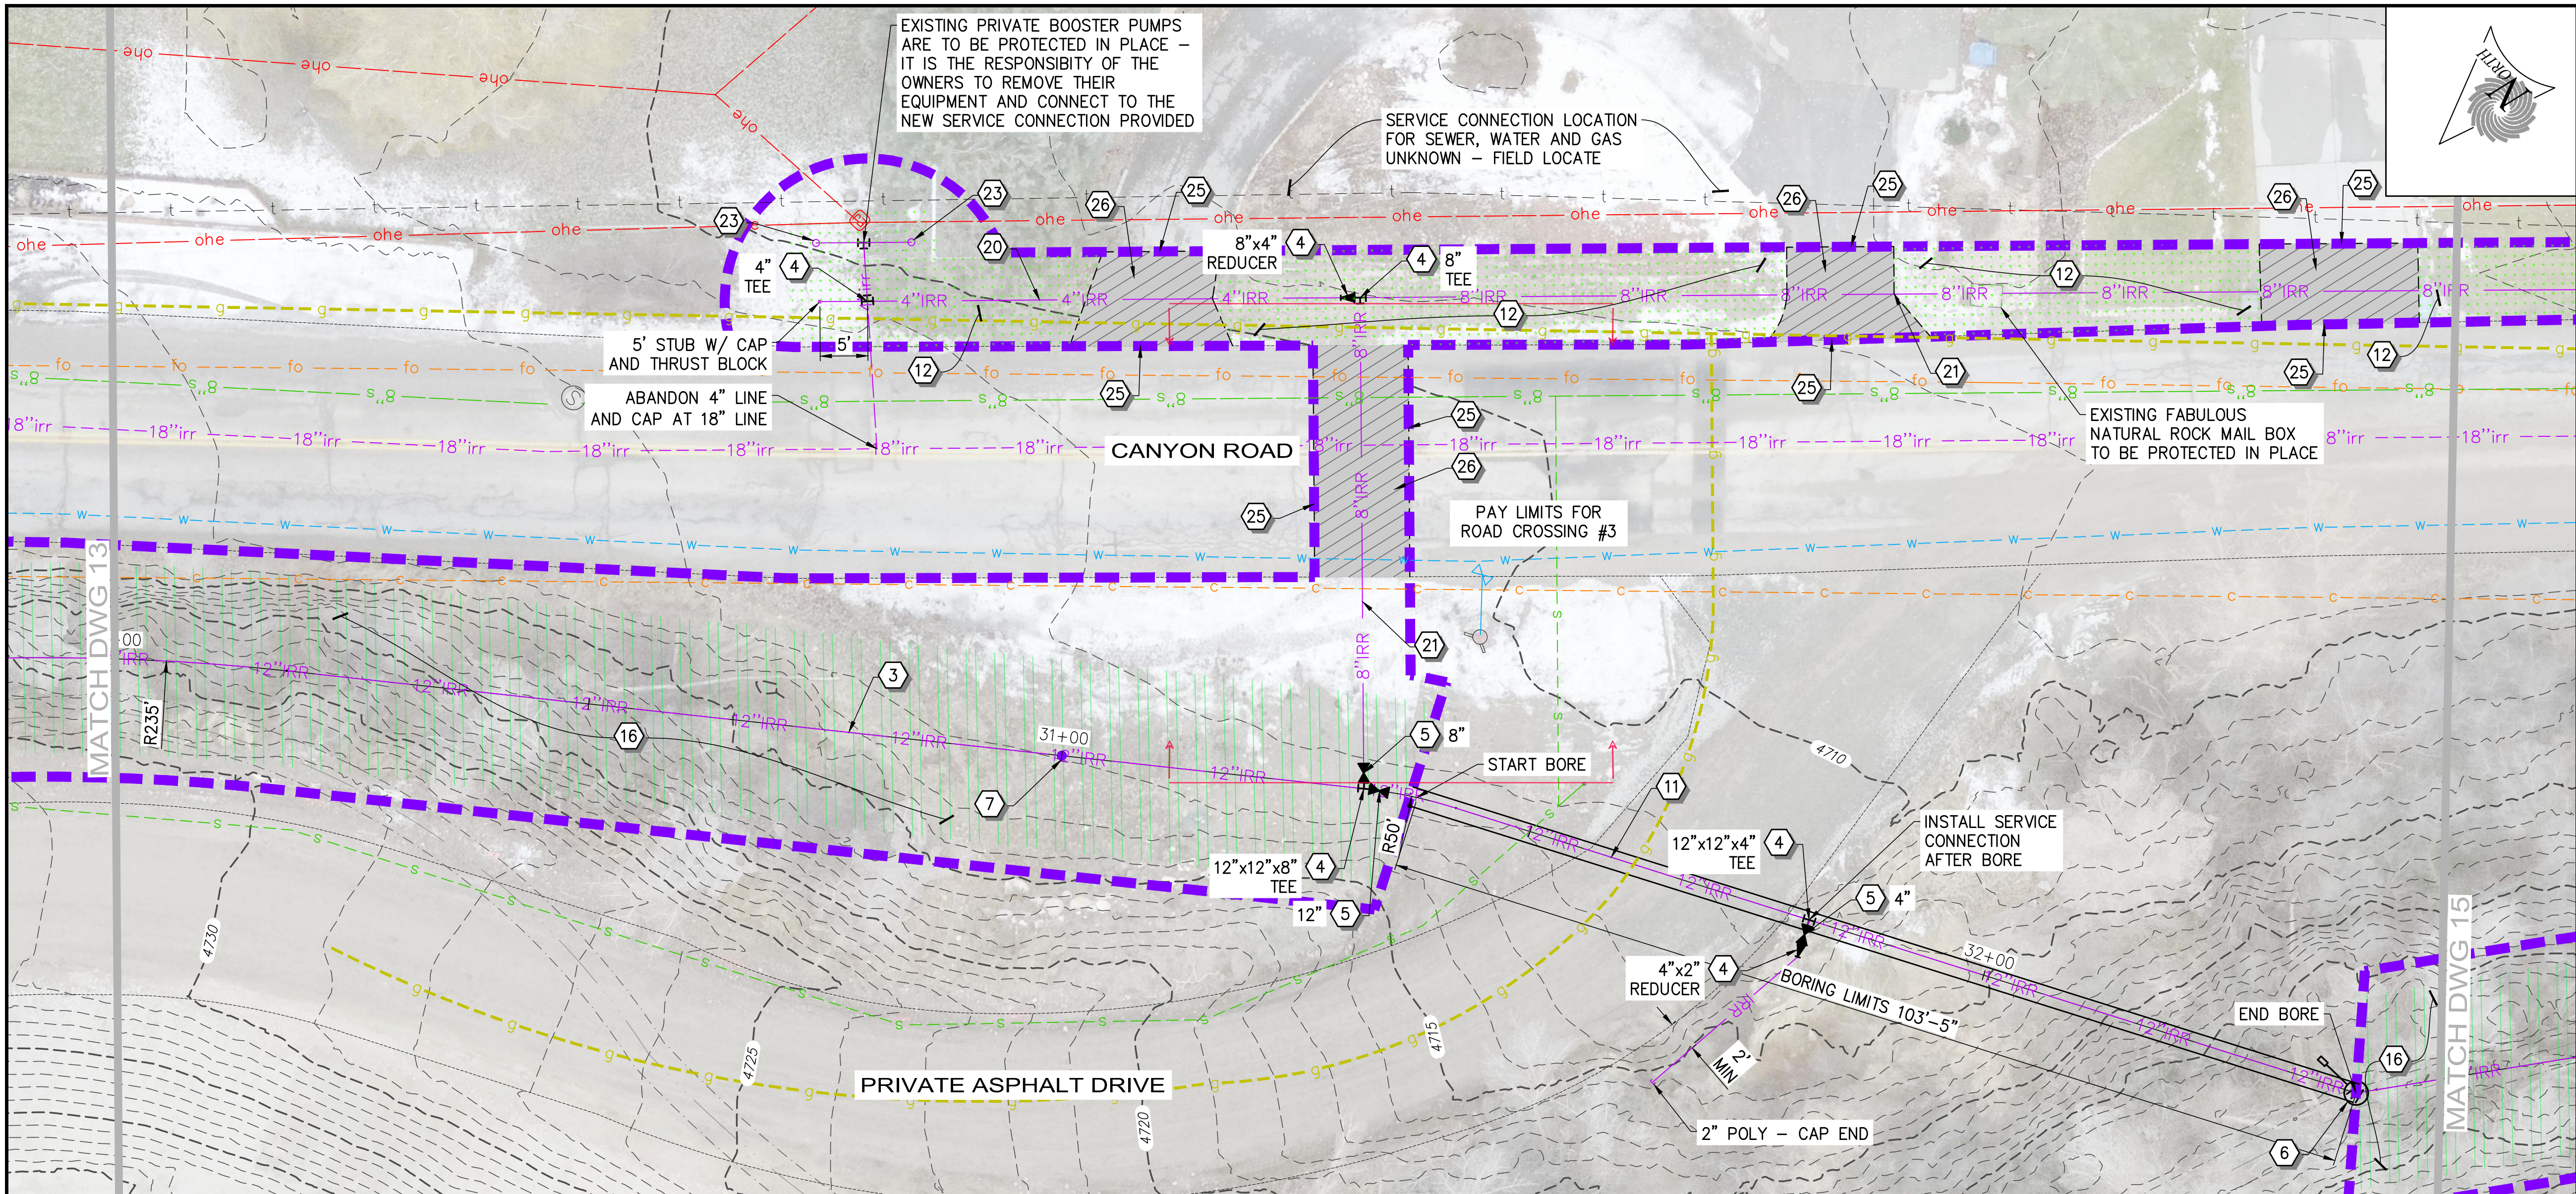


CONSTRUCTION NOTES

- 1 PROPERTY LINES
- 2 INSTALL 18" HDPE DR11 PIPE
- 3 INSTALL 12" HDPE DR11 PIPE
- 4 INSTALL FITTING PER PLAN
- 5 INSTALL ISOLATION VALVE
- 6 INSTALL AIR / VAC ASSEMBLY
- 7 INSTALL TRACER WIRE CURB BOX
- 8 INSTALL MEADOW LARK CROSSING - IN CONCRETE CULVERT, AREA SURROUNDING 12" PIPE IS TO BE CLEANED AND FILLED WITH FLOWABLE FILL - PIPE IS TO BE SECURED WITH STAINLESS STEEL STRAPS
- 9 INSTALL SUMMIT CREEK CROSSING
- 10 INSTALL METER MANHOLE
- 11 INSTALL DIRECTIONAL BORE W/ 12" HDPE DR11 PIPE - NO TRACER WIRE REQUIRED AT BORE
- 12 RESTORE AREA WITH LANDSCAPING SOD OR MATCHING LANDSCAPING LEVEL WITH SURROUNDING AREA
- 13 RESTORE AREA WITH GRAVEL MATCHING EXISTING GRAVEL SURFACE - RESTORED AREA TO HAVE 3" MIN GRAVEL
- 14 PROTECT EXISTING ROCK WALLS IN PLACE
- 15 PROTECT EXISTING CONCRETE STRUCTURE IN PLACE
- 16 VEGETATION IN AREA TO BE TRIMMED / REMOVED AS NEEDED FOR PIPE INSTALLATION
- 17 PLACE ROCKS ALONG BANK WHERE LAND OWNERS HAVE LINED THEIR BANKS
- 18 CONNECTION #1
- 19 CONNECTION #2
- 20 INSTALL 4" HDPE DR11 PIPE
- 21 INSTALL 8" HDPE DR11 PIPE
- 22 INSTALL 4" PERFORATED MANHOLE
- 23 INSTALL SERVICE CONNECTION
- 24 INFILL OLD IRRIGATION DITCH FOR 20' EAST AND WEST OF PIPE CROSSING - COMPACT TO 90%
- 25 SAWCUT ASPHALT TO PROVIDE CLEAN EDGE - REMOVE ASPHALT PAVEMENT
- 26 REPLACE ASPHALT PAVEMENT
- 27 RESTORE GRAVEL DRIVEWAY
- 28 REMOVE CURB AND GUTTER OR SIDEWALK IN FULL SECTIONS
- 29 REPLACE SIDEWALK / ADA RAMP
- 30 REPLACE CURB AND GUTTER
- 31 INSTALL 8" C900 PIPE FROM REDUCER AND SPLICE INTO EXISTING PIPES W/ COUPLER
- 32 EXISTING PUMP HOUSE REPLUMBING

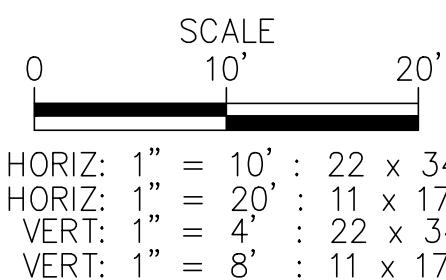


811 Know what's below.
Call before you dig.
1-800-662-4111

REV. NO. COMMENT DATE


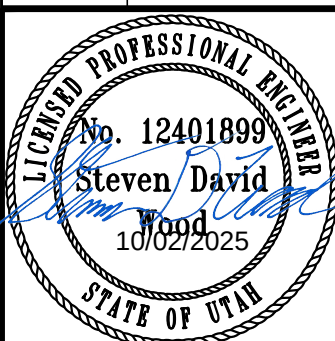




SMITHFIELD IRRIGATION COMPANY
MILL RACE PRESSURIZED PIPELINE
PRESSURIZED PIPELINE
PLAN AND PROFILE



REV. NO.	DESIGNED	DRAWN	CHECKED	SHEET NO.	
12499	HP	JJ	SDW	14 of 26	PP9

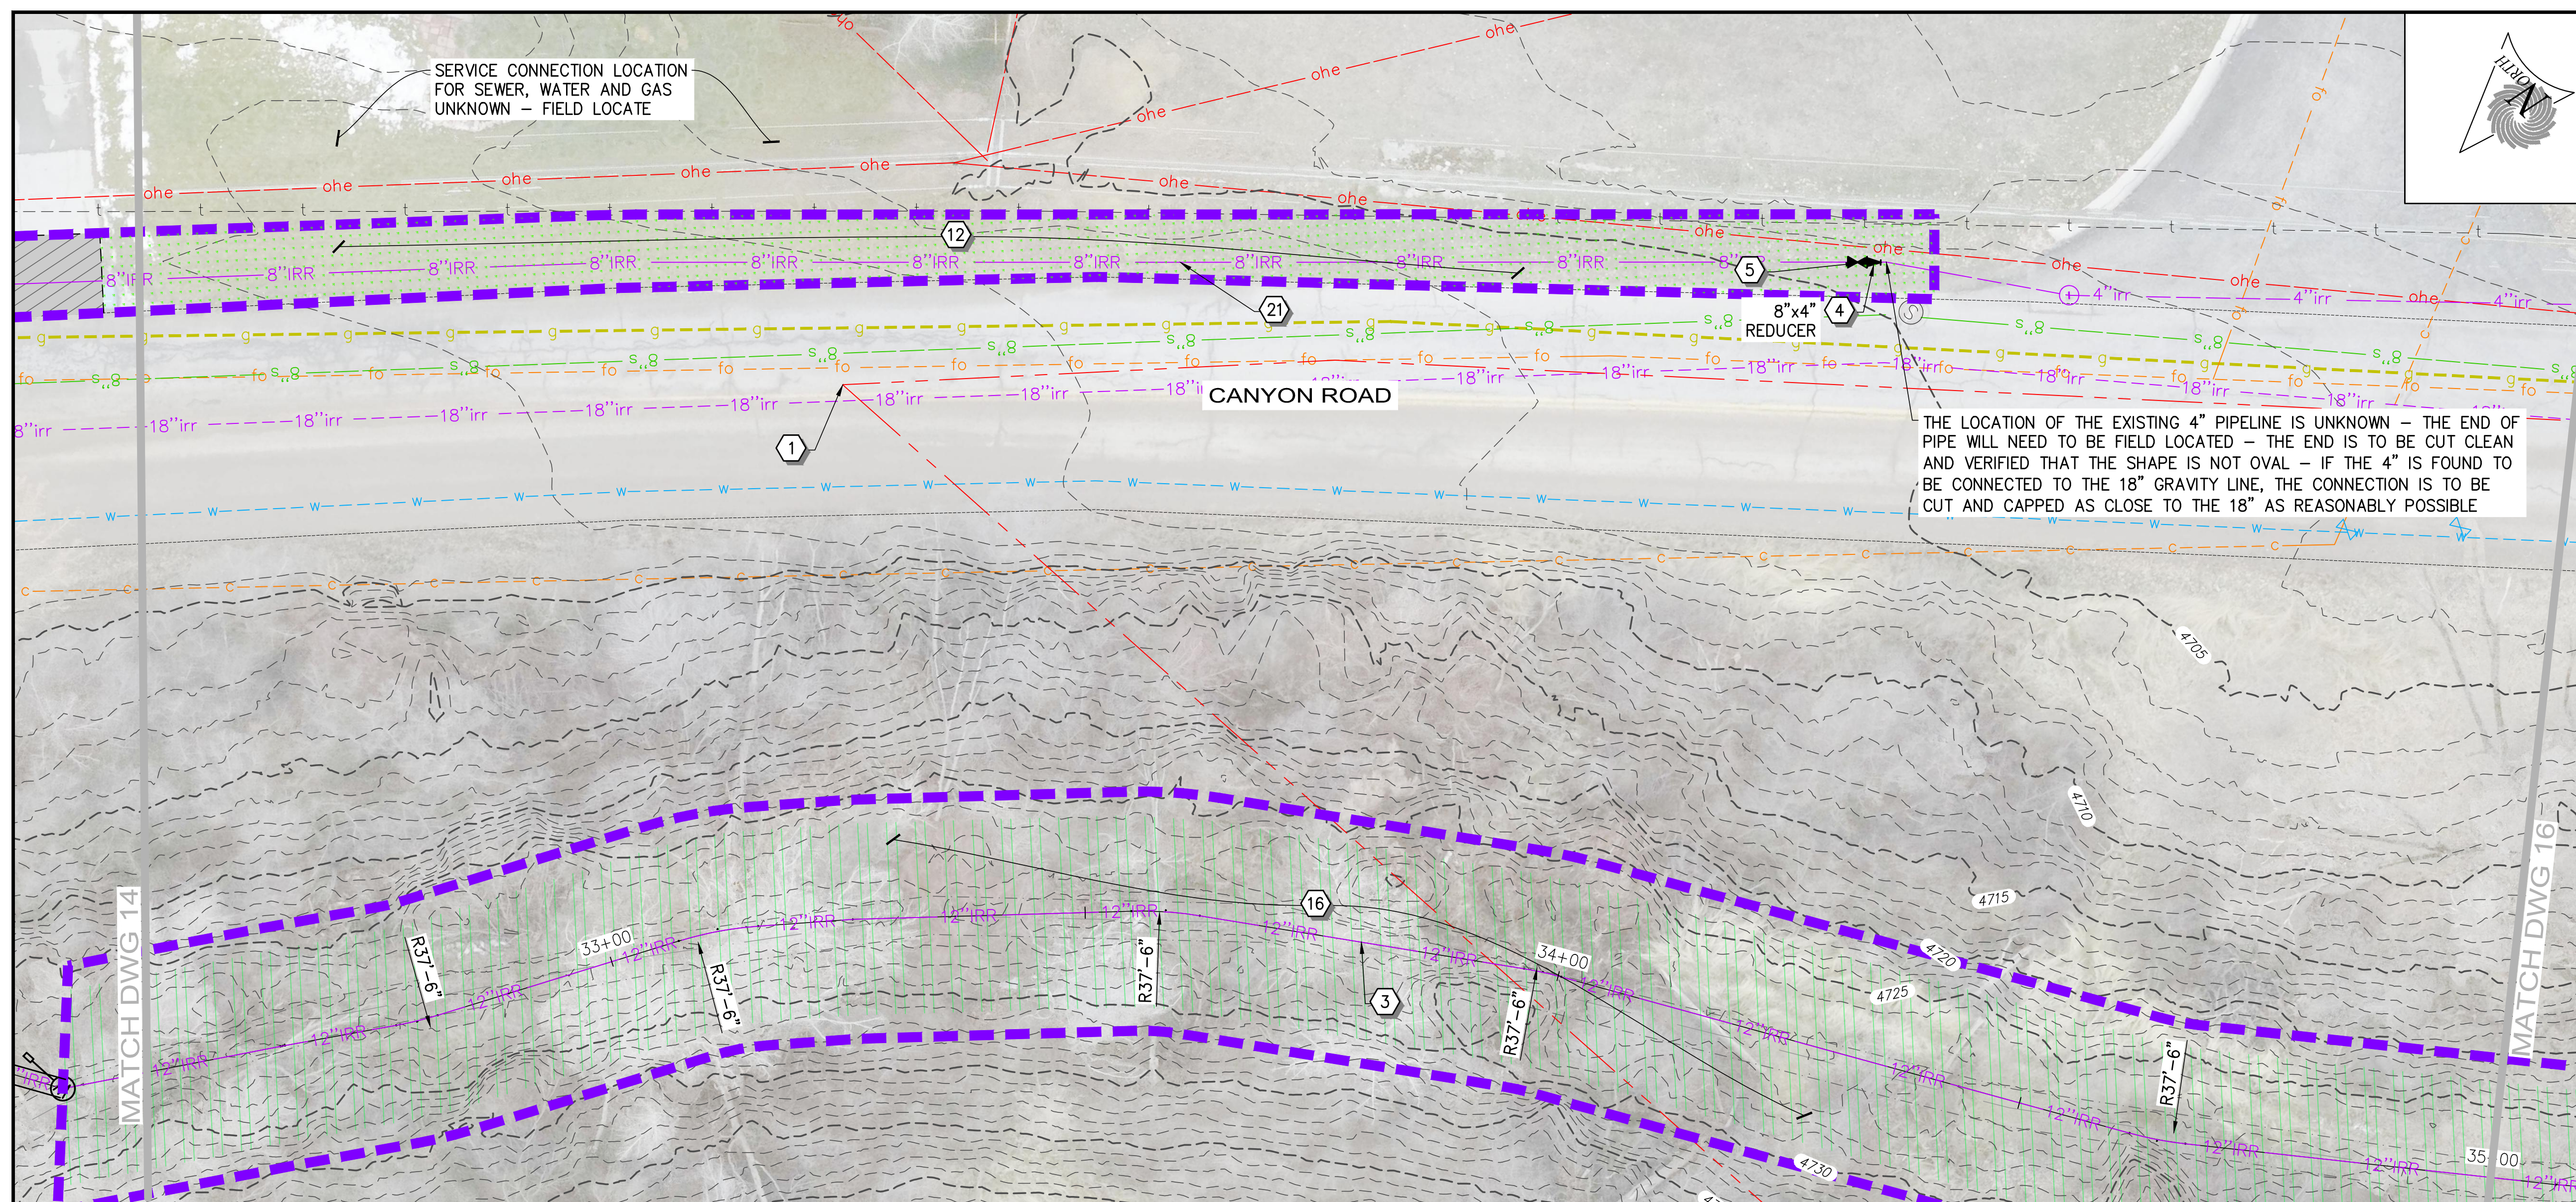

- ## CONSTRUCTION NOTES
- 1 PROPERTY LINES
 - 2 INSTALL 18" HDPE DR11 PIPE 
 - 3 INSTALL 12" HDPE DR11 PIPE 
 - 4 INSTALL FITTING PER PLAN
 - 5 INSTALL ISOLATION VALVE 
 - 6 INSTALL AIR / VAC ASSEMBLY 
 - 7 INSTALL TRACER WIRE CURB BOX 
 - 8 INSTALL MEADOW LARK CROSSING - IN CONCRETE CULVERT, AREA SURROUNDING 12" PIPE IS TO BE CLEANED AND FILLED WITH FLOWABLE FILL PIPE IS TO BE SECURED WITH STAINLESS STEEL STRAPS 
 - 9 INSTALL SUMMIT CREEK CROSSING 
 - 10 INSTALL METER MANHOLE 
 - 11 INSTALL DIRECTIONAL BORE W/ 12" HDPE DR11 PIPE - NO TRACER WIRE REQUIRED AT BORE
 - 12 RESTORE AREA WITH LANDSCAPING SOD OR MATCHING LANDSCAPING LEVEL WITH SURROUNDING AREA
 - 13 RESTORE AREA WITH GRAVEL MATCHING EXISTING GRAVEL SURFACE - RESTORED AREA TO HAVE 3" MIN GRAVEL
 - 14 PROTECT EXISTING ROCK WALLS IN PLACE
 - 15 PROTECT EXISTING CONCRETE STRUCTURE IN PLACE
 - 16 VEGETATION IN AREA TO BE TRIMMED / REMOVED AS NEEDED FOR PIPE INSTALLATION
 - 17 PLACE ROCKS ALONG BANK WHERE LAND OWNERS HAVE LINED THEIR BANKS
 - 18 CONNECTION #1 
 - 19 CONNECTION #2 
 - 20 INSTALL 4" HDPE DR11 PIPE 
 - 21 INSTALL 8" HDPE DR11 PIPE 
 - 22 INSTALL 4" PERFORATED MANHOLE 
 - 23 INSTALL SERVICE CONNECTION 
 - 24 INFILL OLD IRRIGATION DITCH FOR 20' EAST AND WEST OF PIPE CROSSING - COMPACT TO 90%
 - 25 SAWCUT ASPHALT TO PROVIDE CLEAN EDGE - REMOVE ASPALT PAVEMENT
 - 26 REPLACE ASPHALT PAVEMENT 
 - 27 RESTORE GRAVEL DRIVEWAY 
 - 28 REMOVE CURB AND GUTTER OR SIDEWALK IN FULL SECTIONS
 - 29 REPLACE SIDEWALK / ADA RAMP 
 - 30 REPLACE CURB AND GUTTER 
 - 31 INSTALL 8" C900 PIPE FROM REDUCER AND SPLICE INTO EXISTING PIPES W/ COUPLER 
 - 32 EXISTING PUMP HOUSE REPLUMBING 

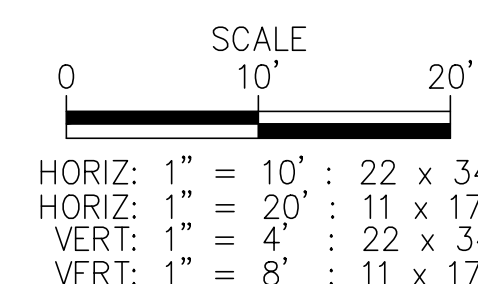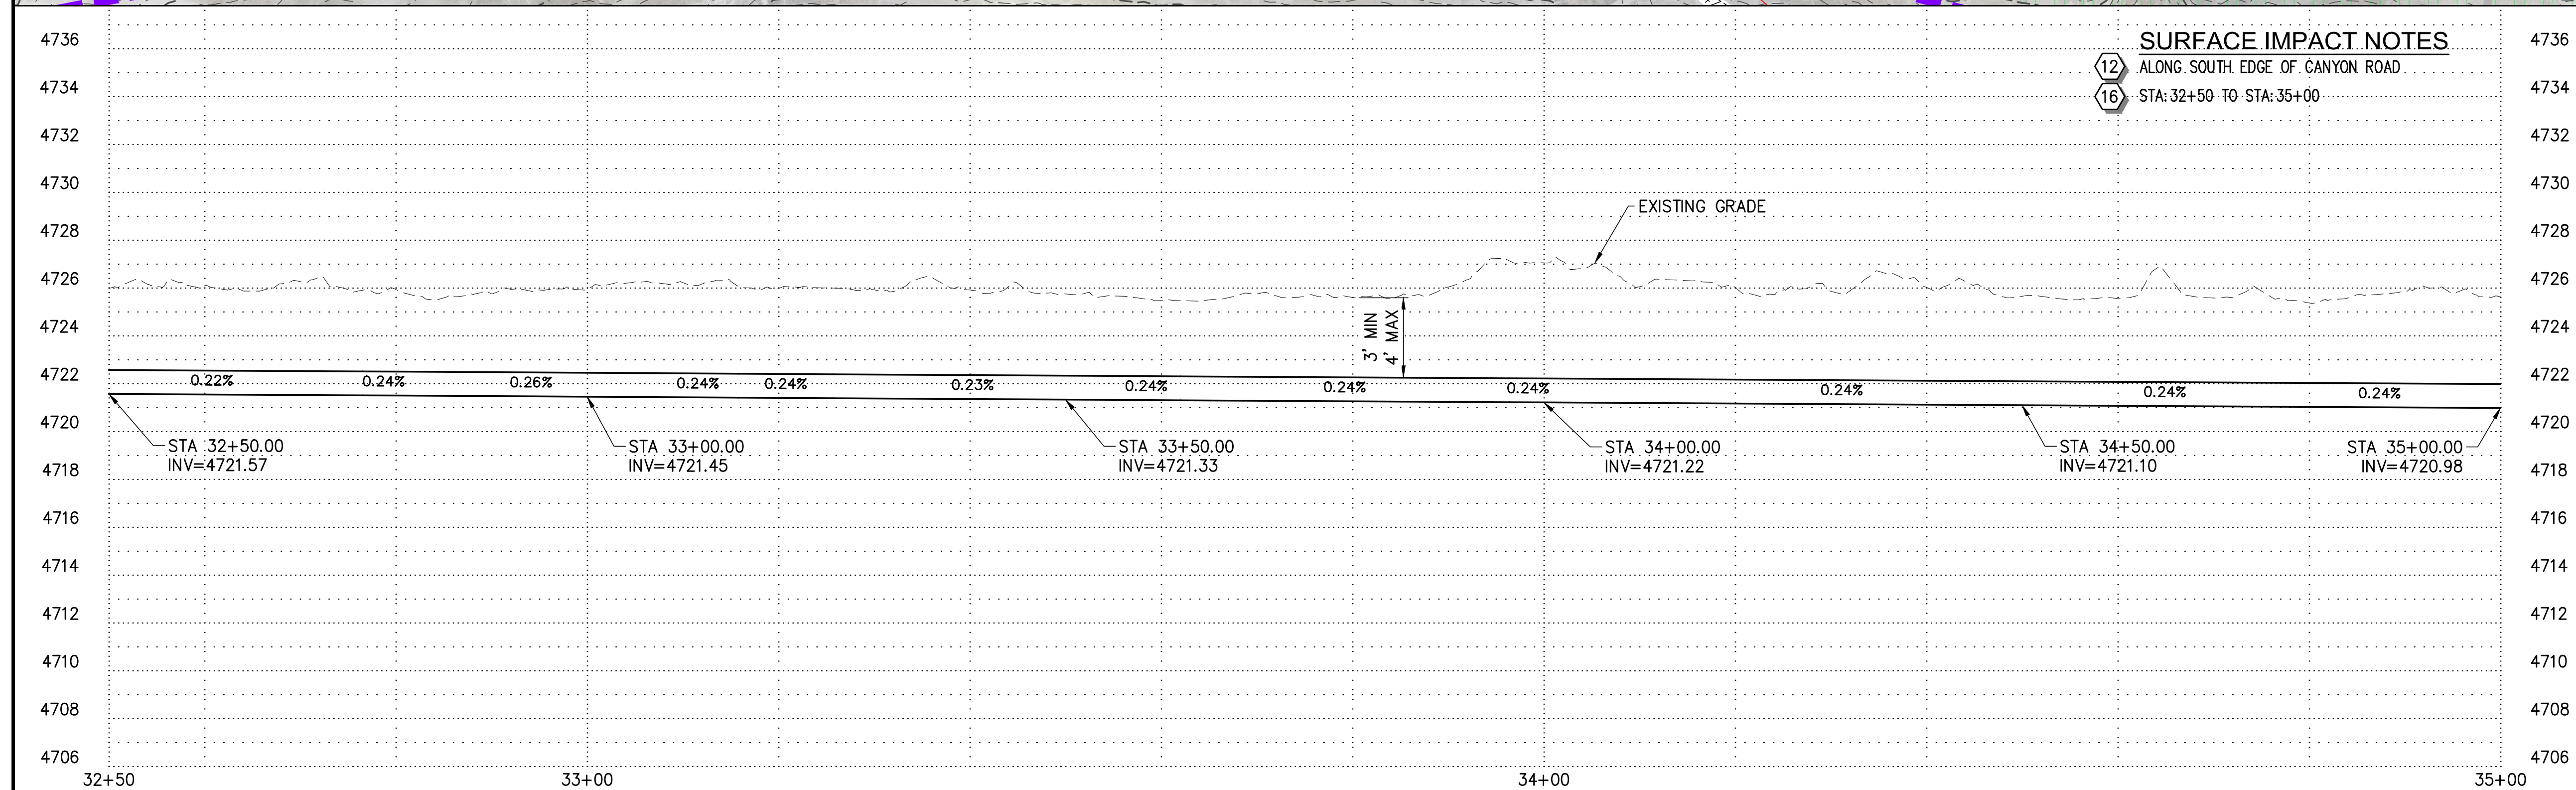

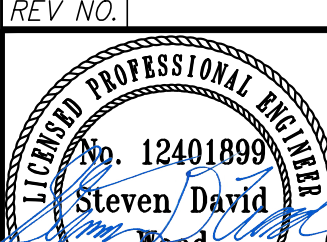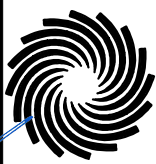
REV NO.				COMMENT			DATE
		 SUNRISE ENGINEERING					
		2100 NORTH MAIN STREET NORTH LOGAN, UTAH 84341 TEL 435.563.3734 www.sunrise-eng.com					
SMITHFIELD IRRIGATION COMPANY							
MILL RACE PRESSURIZED PIPELINE							
PRESSURIZED PIPELINE							
PLAN AND PROFILE							
SEI NO.	DESIGNED	DRAWN		CHECKED	SHEET NO.		PP10
12499	HP	JJ		SDW	15 of 26		

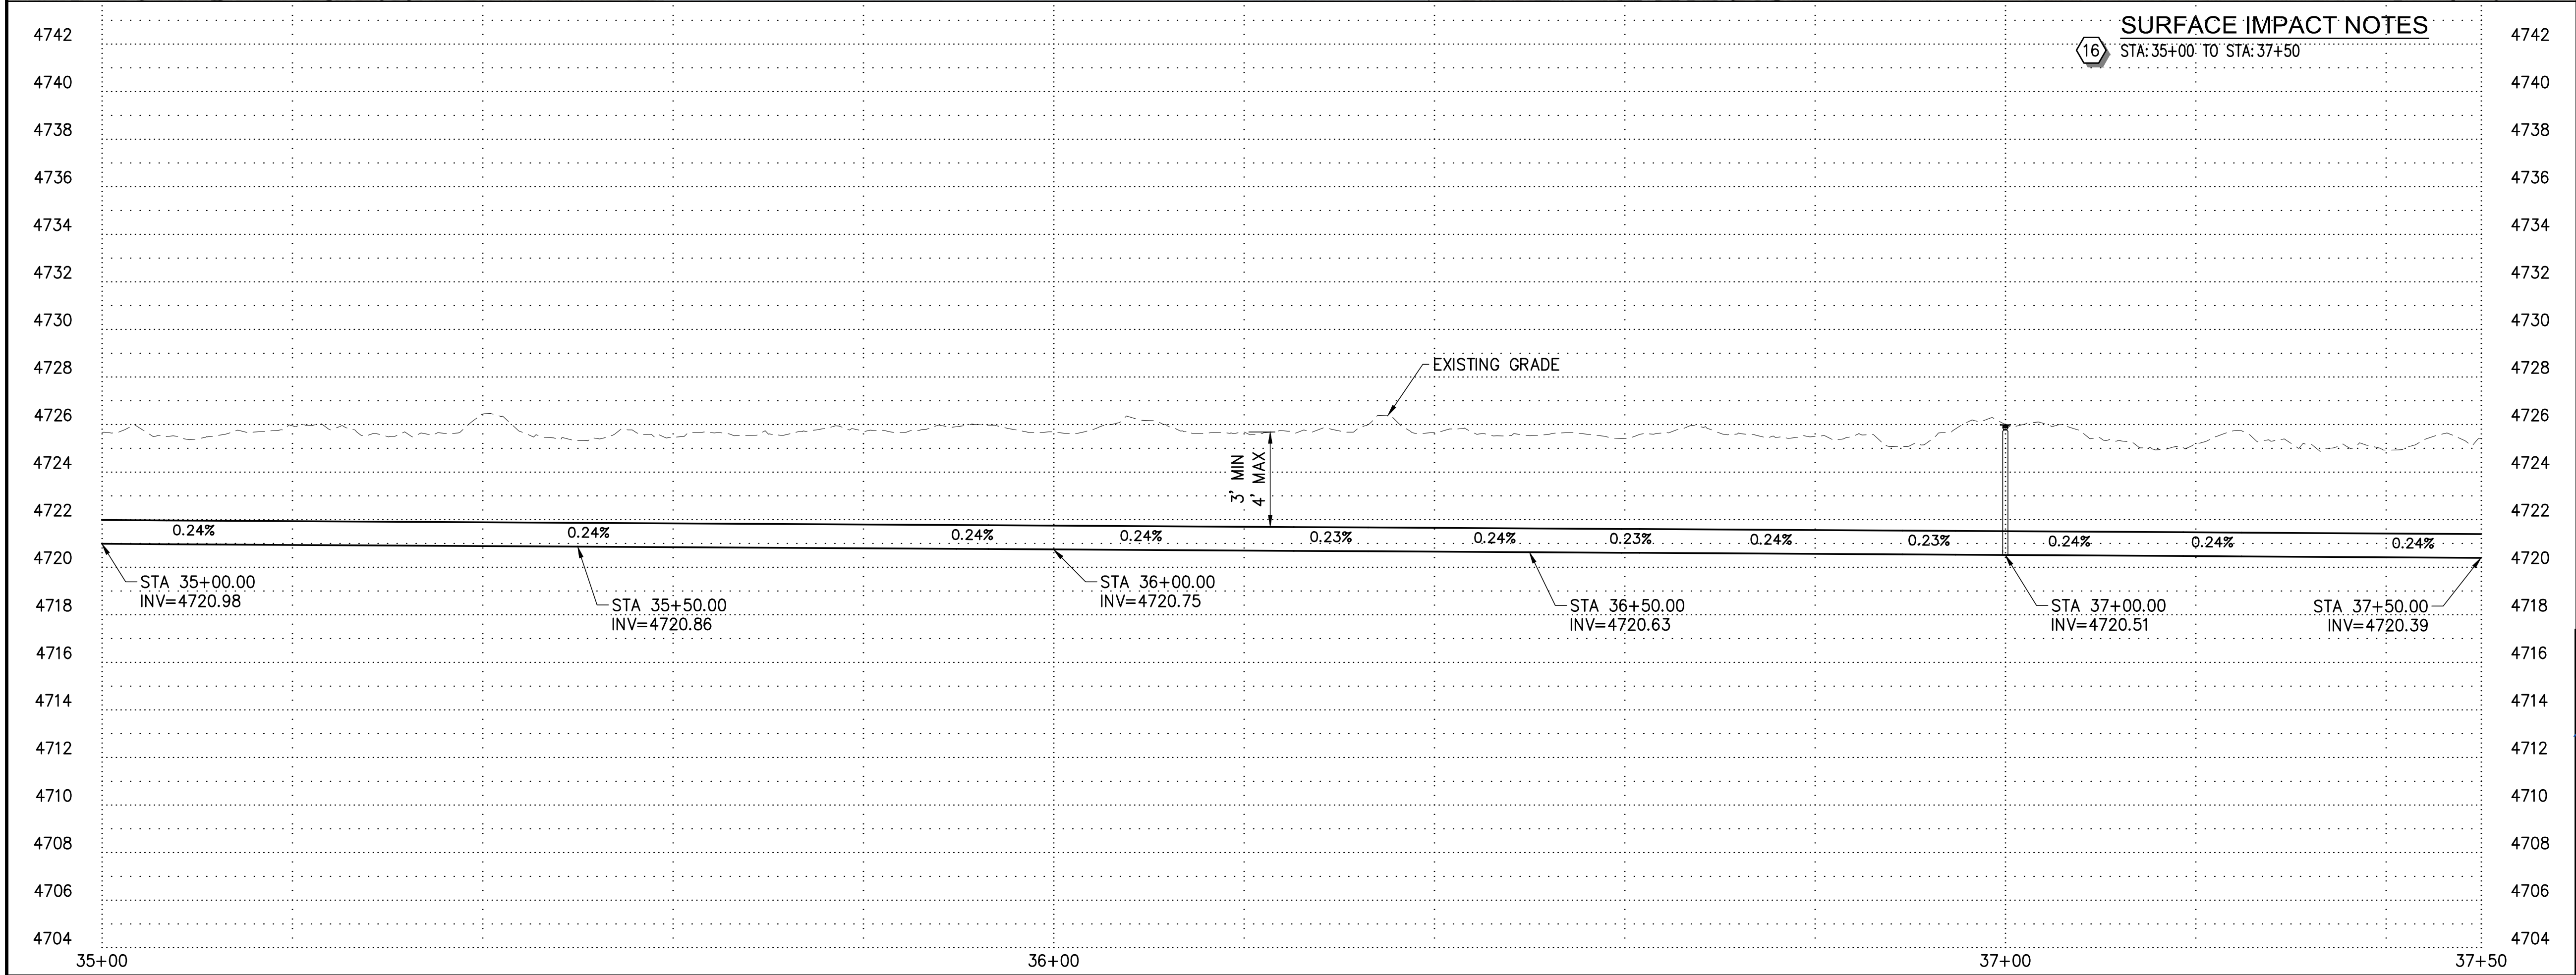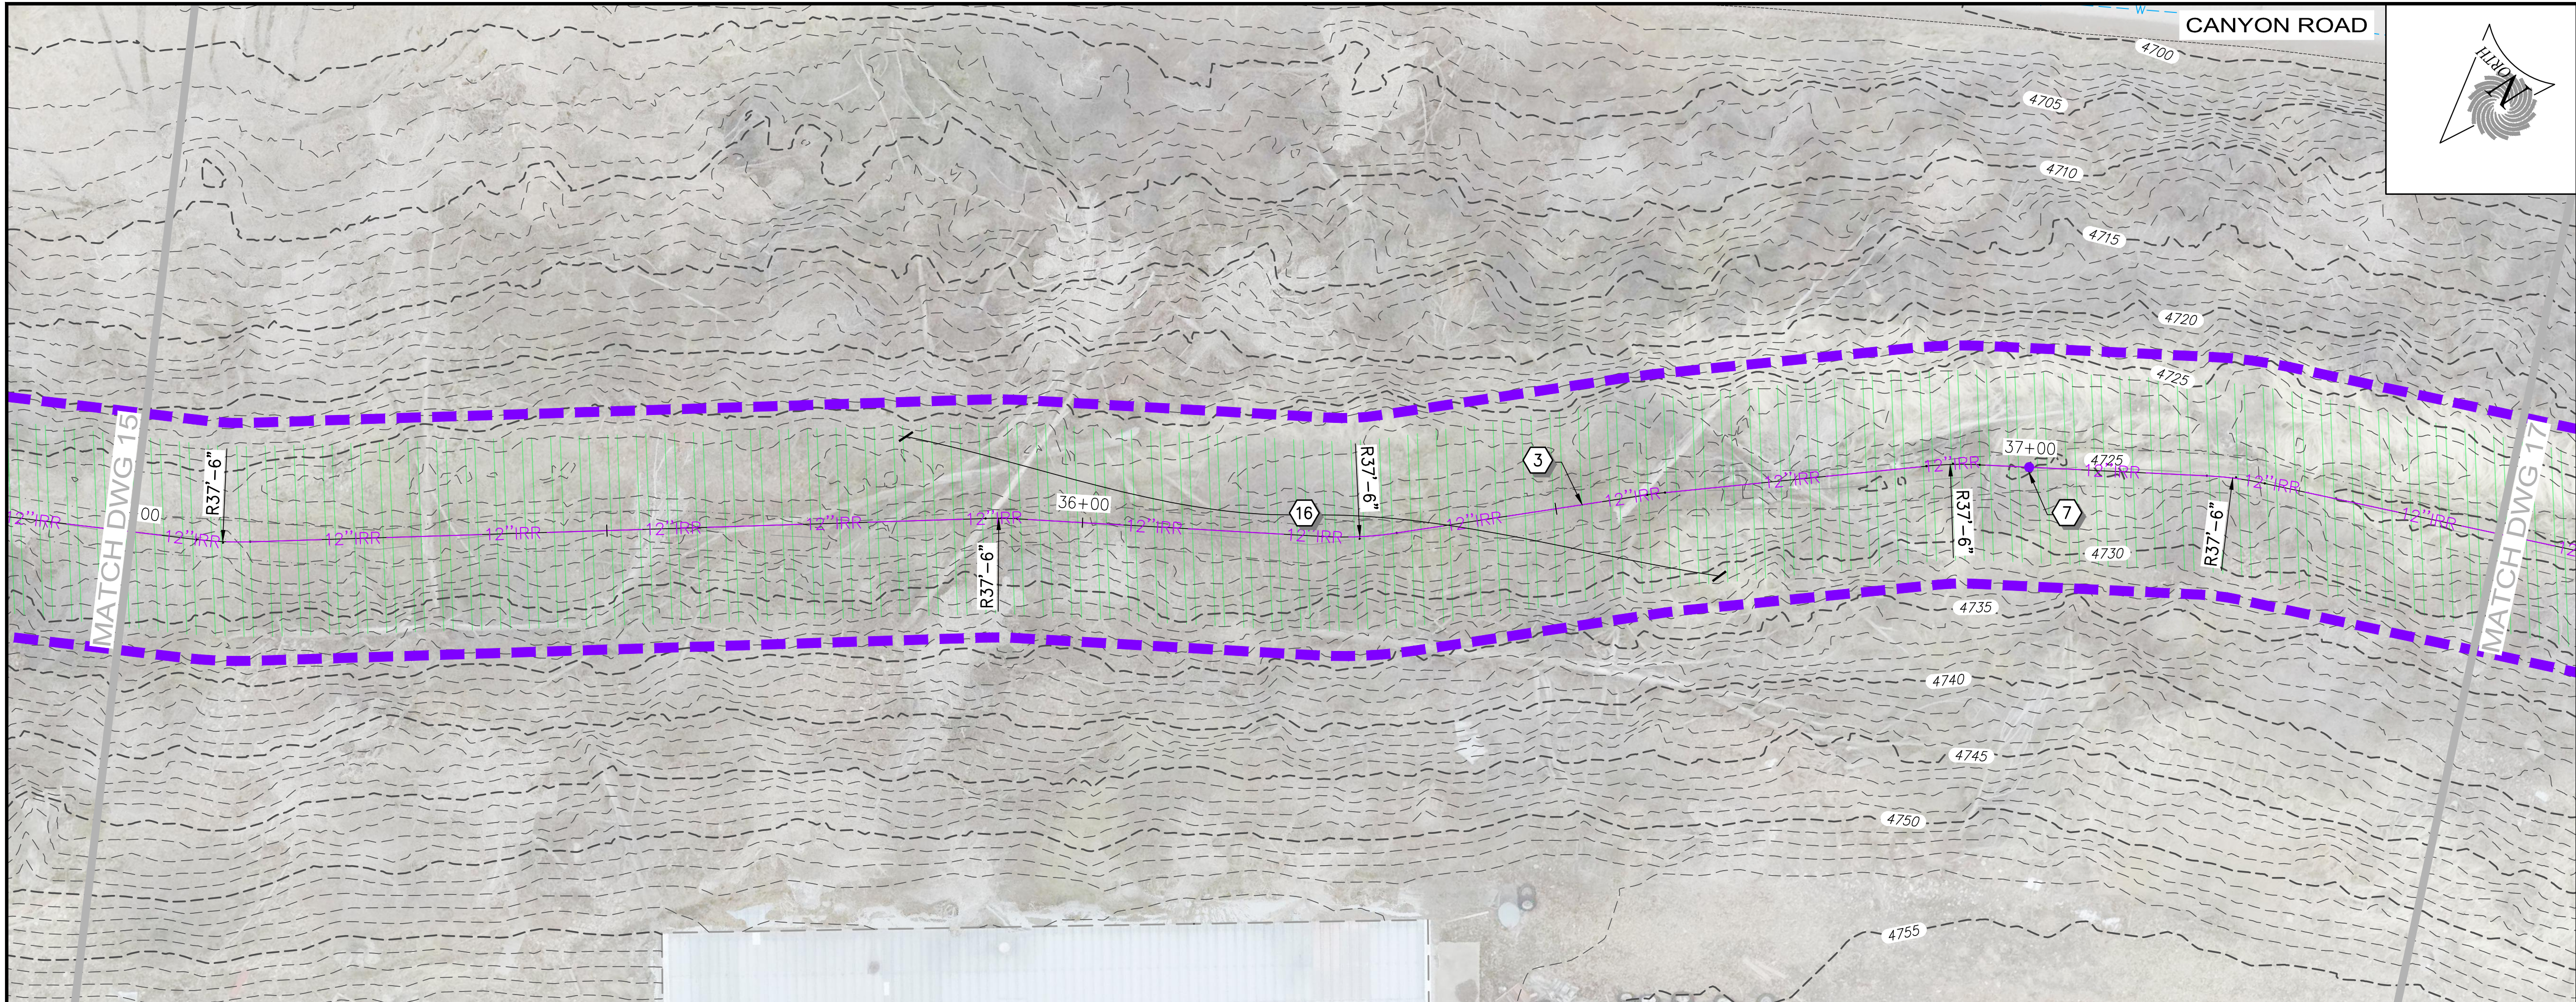

- ### CONSTRUCTION NOTES
- 1 PROPERTY LINES
 - 2 INSTALL 18" HDPE DR11 PIPE
 - 3 INSTALL 12" HDPE DR11 PIPE
 - 4 INSTALL FITTING PER PLAN
 - 5 INSTALL ISOLATION VALVE
 - 6 INSTALL AIR / VAC ASSEMBLY
 - 7 INSTALL TRACER WIRE CURB BOX
 - 8 INSTALL MEADOW LARK CROSSING - IN CONCRETE CULVERT, AREA SURROUNDING 12" PIPE IS TO BE CLEANED AND FILLED WITH FLOWABLE FILL - PIPE IS TO BE SECURED WITH STAINLESS STEEL STRAPS
 - 9 INSTALL SUMMIT CREEK CROSSING
 - 10 INSTALL METER MANHOLE
 - 11 INSTALL DIRECTIONAL BORE W/ 12" HDPE DR11 PIPE - NO TRACER WIRE REQUIRED AT BORE
 - 12 RESTORE AREA WITH LANDSCAPING SOD OR MATCHING LANDSCAPING LEVEL WITH SURROUNDING AREA
 - 13 RESTORE AREA WITH GRAVEL MATCHING EXISTING GRAVEL SURFACE - RESTORED AREA TO HAVE 3" MIN GRAVEL
 - 14 PROTECT EXISTING ROCK WALLS IN PLACE
 - 15 PROTECT EXISTING CONCRETE STRUCTURE IN PLACE
 - 16 VEGETATION IN AREA TO BE TRIMMED / REMOVED AS NEEDED FOR PIPE INSTALLATION
 - 17 PLACE ROCKS ALONG BANK WHERE LAND OWNERS HAVE LINED THEIR BANKS
 - 18 CONNECTION #1
 - 19 CONNECTION #2
 - 20 INSTALL 4" HDPE DR11 PIPE
 - 21 INSTALL 8" HDPE DR11 PIPE
 - 22 INSTALL 4" PERFORATED MANHOLE
 - 23 INSTALL SERVICE CONNECTION
 - 24 INFILL OLD IRRIGATION DITCH FOR 20' EAST AND WEST OF PIPE CROSSING - COMPACT TO 90%
 - 25 SAWCUT ASPHALT TO PROVIDE CLEAN EDGE - REMOVE ASPALT PAVEMENT
 - 26 REPLACE ASPHALT PAVEMENT
 - 27 RESTORE GRAVEL DRIVEWAY
 - 28 REMOVE CURB AND GUTTER OR SIDEWALK IN FULL SECTIONS
 - 29 REPLACE SIDEWALK / ADA RAMP
 - 30 REPLACE CURB AND GUTTER
 - 31 INSTALL 8" C900 PIPE FROM REDUCER AND SPLICE INTO EXISTING PIPES W/ COUPLER
 - 32 EXISTING PUMP HOUSE REPLUMBING

SCALE
0 10' 20'
HORIZ: 1" = 10' : 22 x 34
HORIZ: 1" = 20' : 11 x 17
VERT: 1" = 4' : 22 x 34
VERT: 1" = 8' : 11 x 17

811 Know what's below.
Call before you dig.
1-800-662-4111


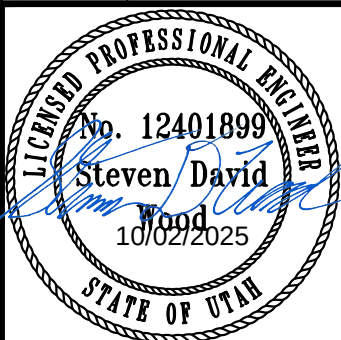


SUNRISE
ENGINEERING

2100 NORTH MAIN STREET
NORTH LOGAN, UTAH 84341
TEL 435.563.3734
www.sunrise-eng.com

SMITHFIELD IRRIGATION COMPANY
MILL RACE PRESSURIZED PIPELINE
PRESSURIZED PIPELINE
PLAN AND PROFILE

SEI NO.	DESIGNED	DRAWN	CHECKED	SHEET NO.	
12499	HP	JJ	SDW	16 of 26	PP11

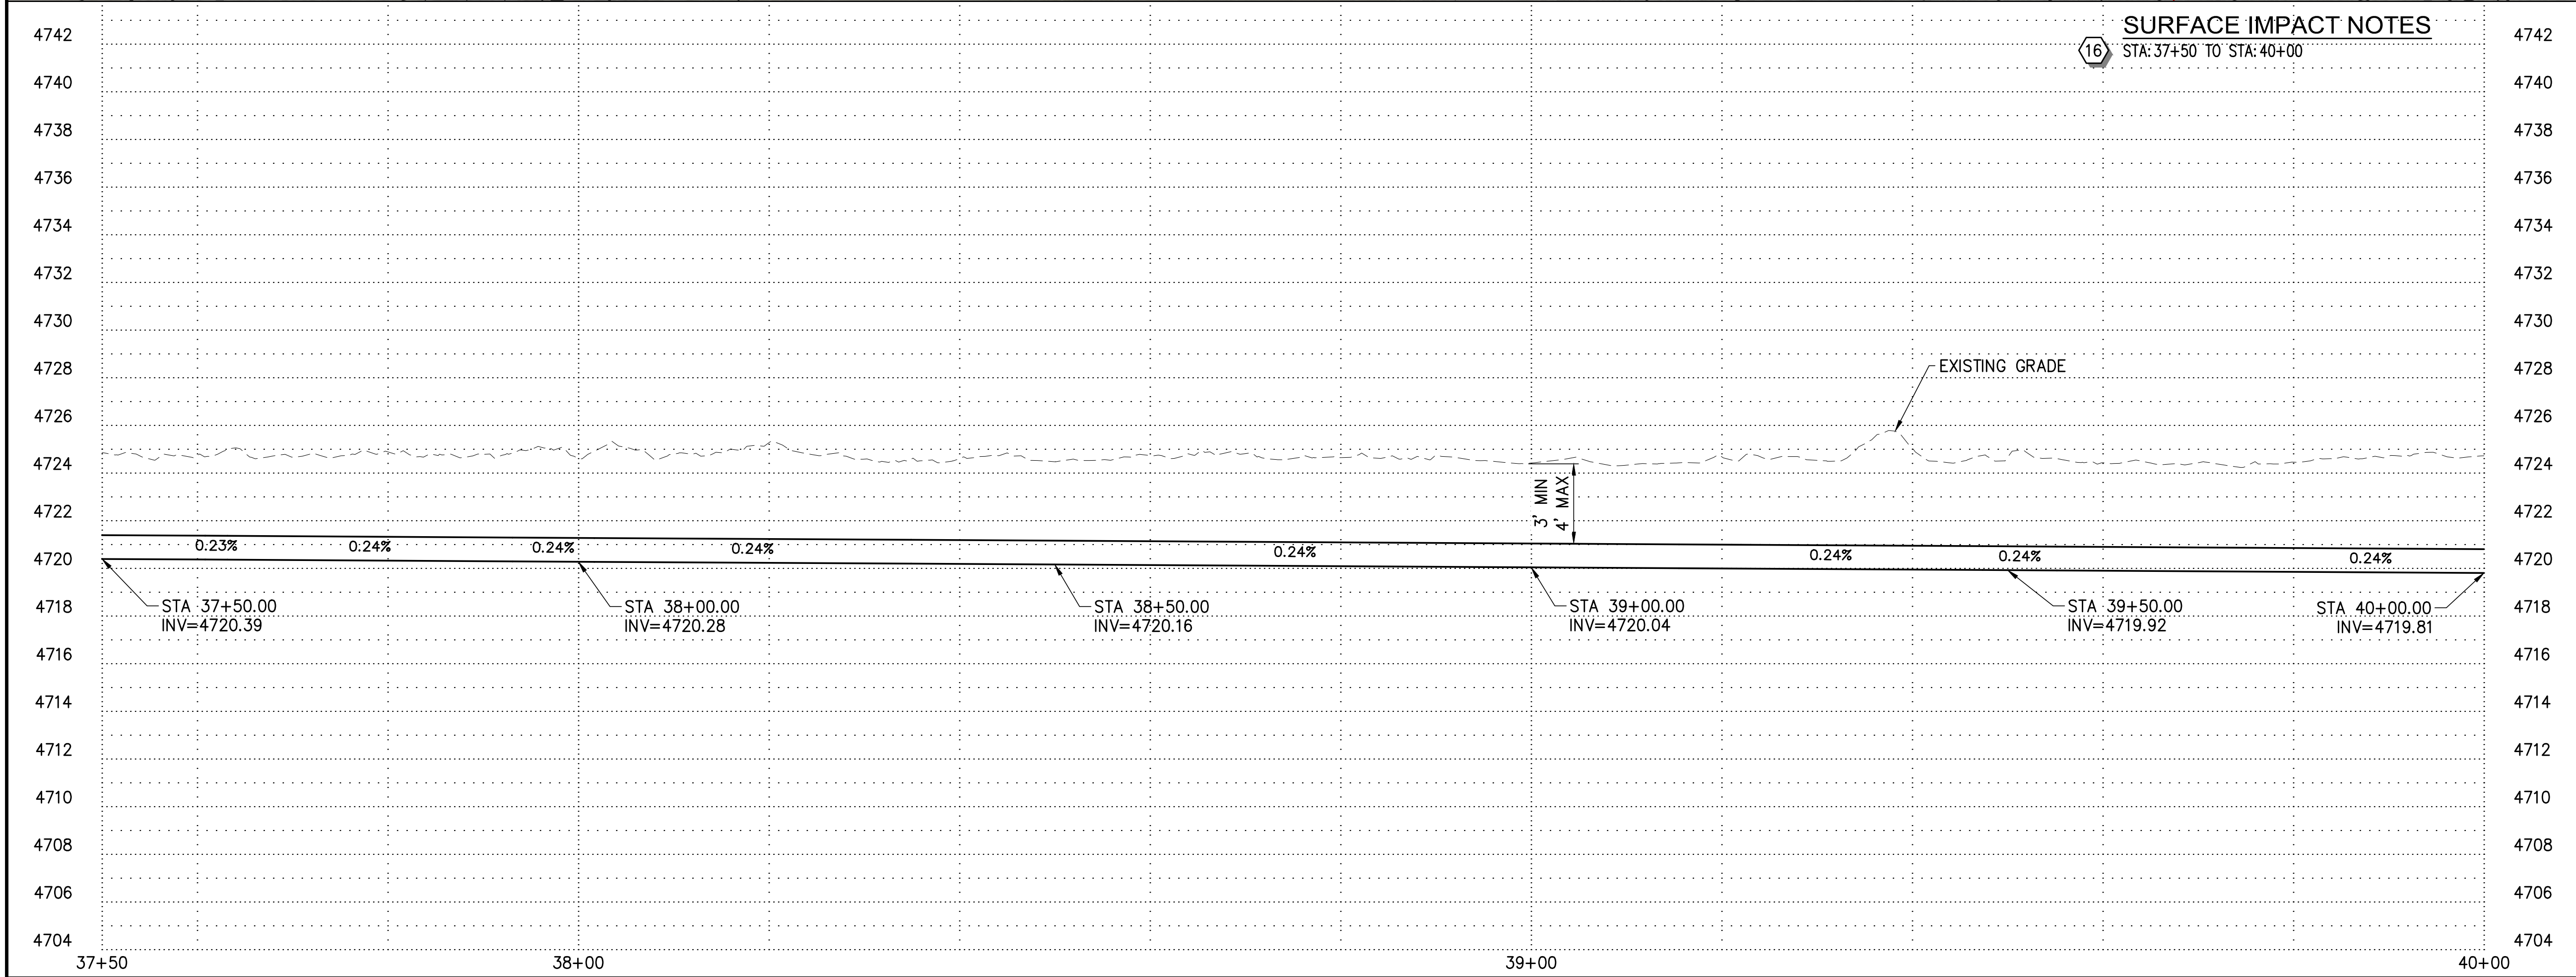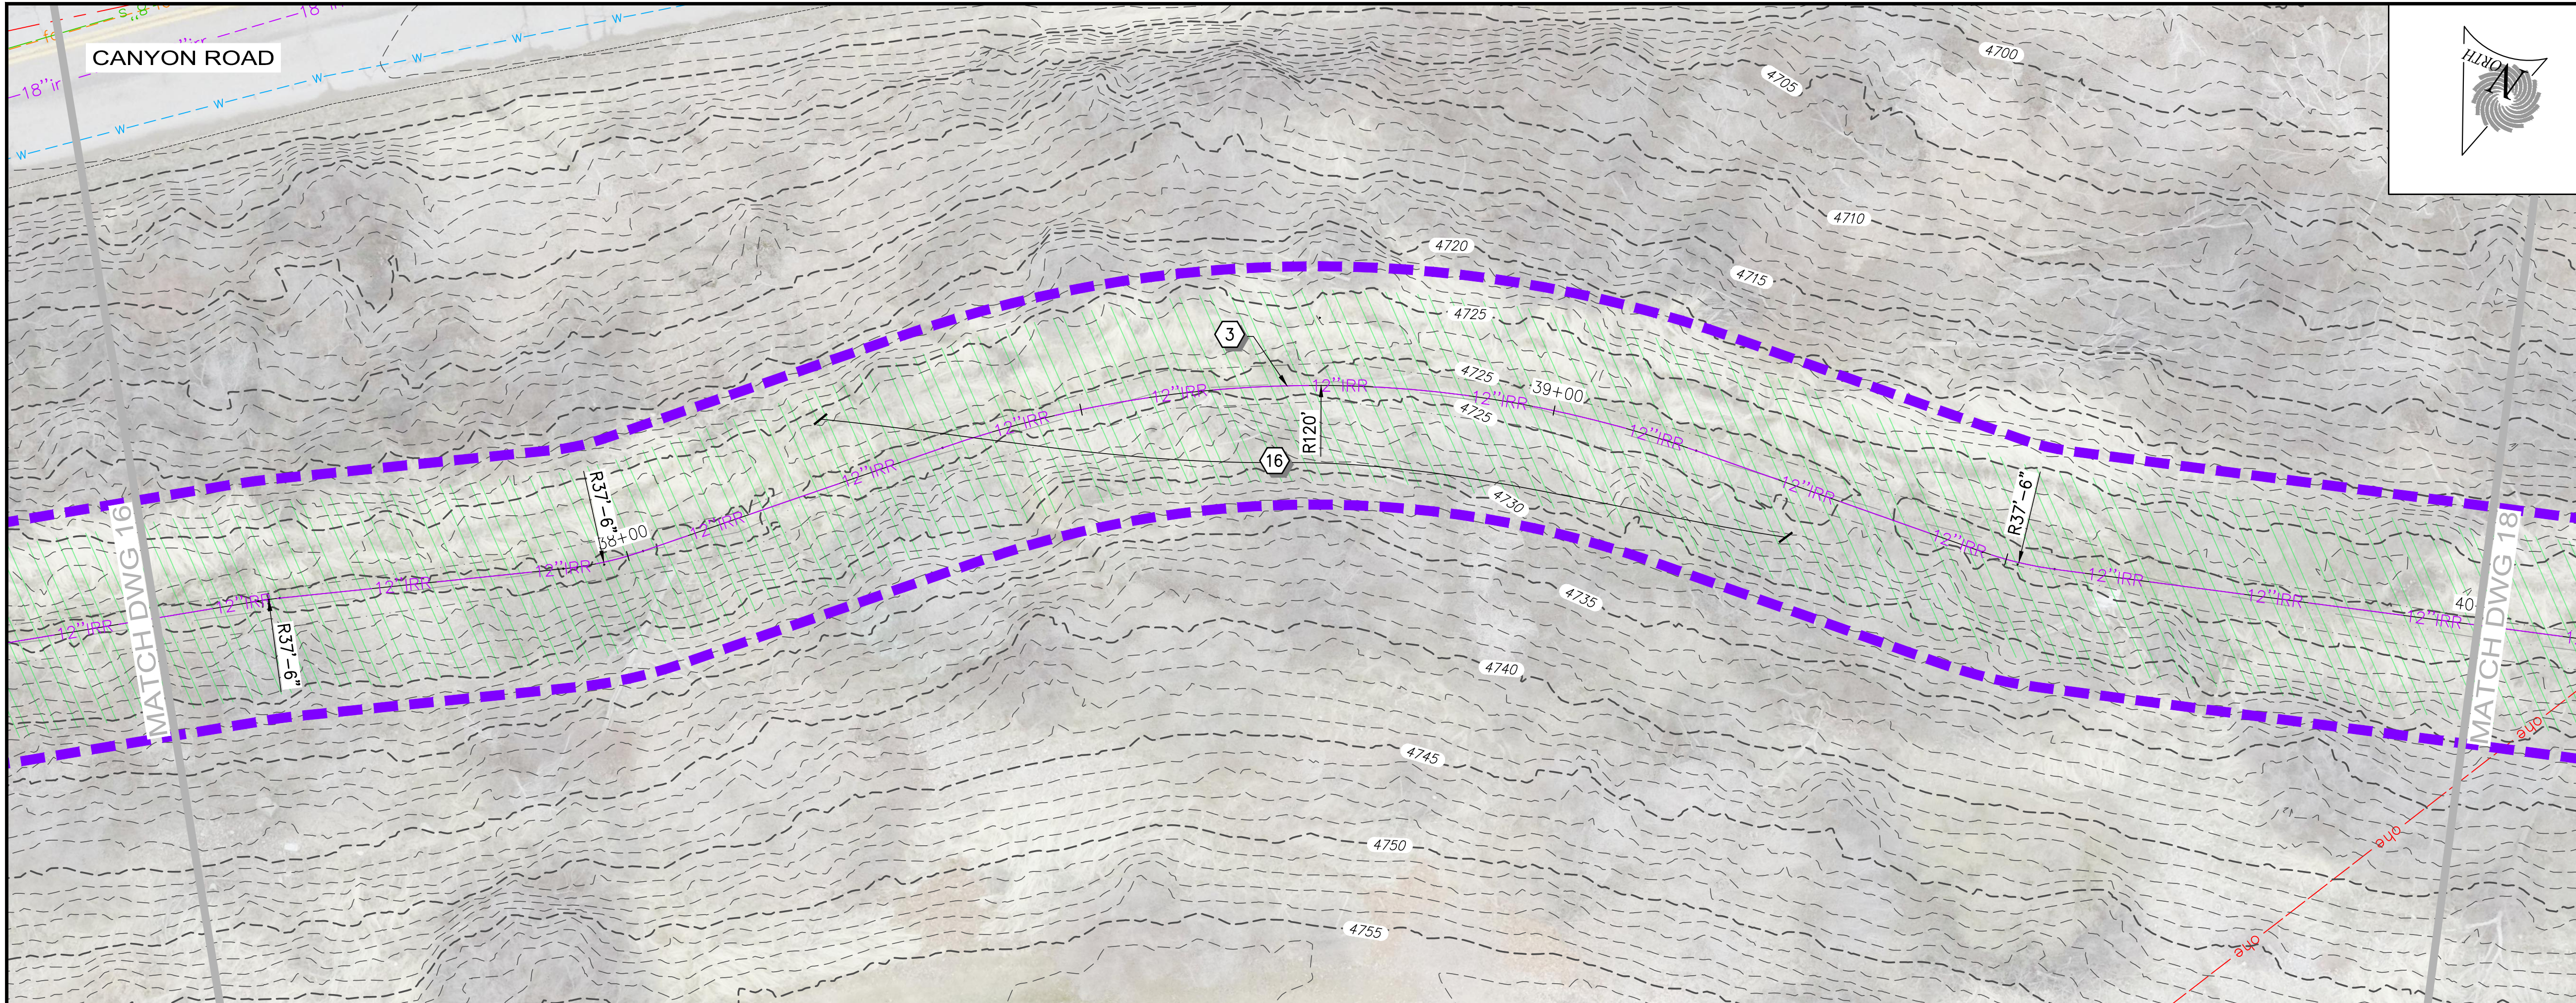

- ### CONSTRUCTION NOTES
- 1 PROPERTY LINES
 - 2 INSTALL 18" HDPE DR11 PIPE
 - 3 INSTALL 12" HDPE DR11 PIPE
 - 4 INSTALL FITTING PER PLAN
 - 5 INSTALL ISOLATION VALVE
 - 6 INSTALL AIR / VAC ASSEMBLY
 - 7 INSTALL TRACER WIRE CURB BOX
 - 8 INSTALL MEADOW LARK CROSSING - IN CONCRETE CULVERT, AREA SURROUNDING 12" PIPE IS TO BE CLEANED AND FILLED WITH FLOWABLE FILL - PIPE IS TO BE SECURED WITH STAINLESS STEEL STRAPS
 - 9 INSTALL SUMMIT CREEK CROSSING
 - 10 INSTALL METER MANHOLE
 - 11 INSTALL DIRECTIONAL BORE W/ 12" HDPE DR11 PIPE - NO TRACER WIRE REQUIRED AT BORE
 - 12 RESTORE AREA WITH LANDSCAPING SOD OR MATCHING LANDSCAPING LEVEL WITH SURROUNDING AREA
 - 13 RESTORE AREA WITH GRAVEL MATCHING EXISTING GRAVEL SURFACE - RESTORED AREA TO HAVE 3" MIN GRAVEL
 - 14 PROTECT EXISTING ROCK WALLS IN PLACE
 - 15 PROTECT EXISTING CONCRETE STRUCTURE IN PLACE
 - 16 VEGETATION IN AREA TO BE TRIMMED / REMOVED AS NEEDED FOR PIPE INSTALLATION
 - 17 PLACE ROCKS ALONG BANK WHERE LAND OWNERS HAVE LINED THEIR BANKS
 - 18 CONNECTION #1
 - 19 CONNECTION #2
 - 20 INSTALL 4" HDPE DR11 PIPE
 - 21 INSTALL 8" HDPE DR11 PIPE
 - 22 INSTALL 4" PERFORATED MANHOLE
 - 23 INSTALL SERVICE CONNECTION
 - 24 INFILL OLD IRRIGATION DITCH FOR 20' EAST AND WEST OF PIPE CROSSING - COMPACT TO 90%
 - 25 SAWCUT ASPHALT TO PROVIDE CLEAN EDGE - REMOVE ASPALT PAVEMENT
 - 26 REPLACE ASPHALT PAVEMENT
 - 27 RESTORE GRAVEL DRIVEWAY
 - 28 REMOVE CURB AND GUTTER OR SIDEWALK IN FULL SECTIONS
 - 29 REPLACE SIDEWALK / ADA RAMP
 - 30 REPLACE CURB AND GUTTER
 - 31 INSTALL 8" C900 PIPE FROM REDUCER AND SPLICE INTO EXISTING PIPES W/ COUPLER
 - 32 EXISTING PUMP HOUSE REPLUMBING

SCALE
0 10' 20'

HORIZ: 1" = 10' : 22 x 34
HORIZ: 1" = 20' : 11 x 17
VERT: 1" = 4' : 22 x 34
VERT: 1" = 8' : 11 x 17

811 Know what's below.
Call before you dig.
1-800-662-4111

REV NO.	COMMENT	DATE


SUNRISE ENGINEERING
2100 NORTH MAIN STREET
NORTH LOGAN, UTAH 84341
TEL 435.563.3734
www.sunrise-eng.com

SMITHFIELD IRRIGATION COMPANY
MILL RACE PRESSURIZED PIPELINE
PRESSURIZED PIPELINE
PLAN AND PROFILE

SEI NO. 12499	DESIGNED HP	DRAWN JJ	CHECKED SDW	SHEET NO. 17 of 26	PP12
------------------	----------------	-------------	----------------	-----------------------	-------------

BID SET

E:\Smithfield Irrigation Company\12499 - SIC Diversion System Improvements Project 2025\DWG\Sheets\SIC-D5-18-12 INCH-PP12.dwg Oct 02, 2025 4:47pm joley

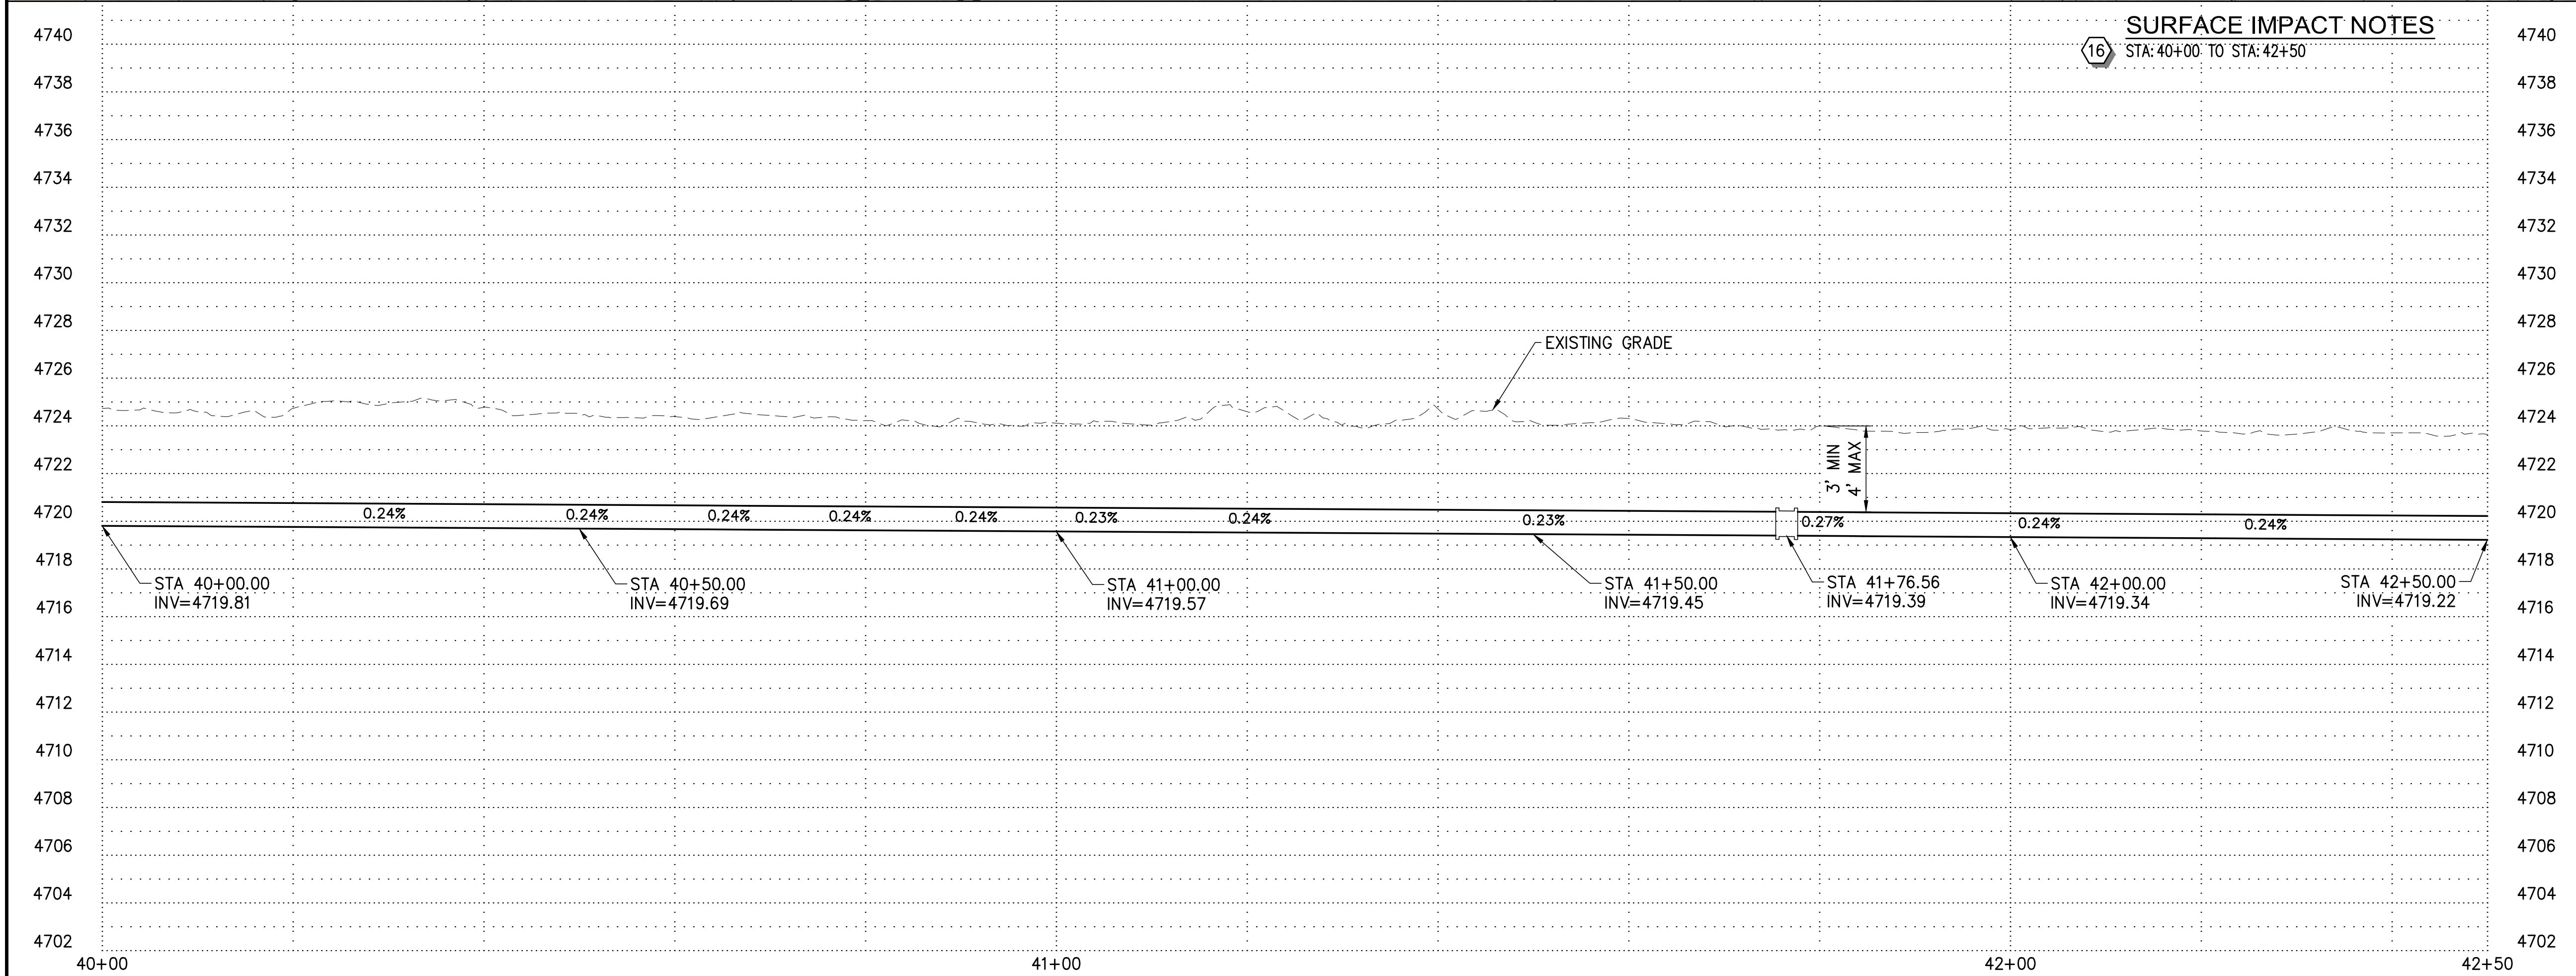

CONSTRUCTION NOTES

- 1 PROPERTY LINES
- 2 INSTALL 18" HDPE DR11 PIPE
- 3 INSTALL 12" HDPE DR11 PIPE
- 4 INSTALL FITTING PER PLAN
- 5 INSTALL ISOLATION VALVE
- 6 INSTALL AIR / VAC ASSEMBLY
- 7 INSTALL TRACER WIRE CURB BOX
- 8 INSTALL MEADOW LARK CROSSING - IN CONCRETE CULVERT, AREA SURROUNDING 12" PIPE IS TO BE CLEANED AND FILLED WITH FLOWABLE FILL - PIPE IS TO BE SECURED WITH STAINLESS STEEL STRAPS
- 9 INSTALL SUMMIT CREEK CROSSING
- 10 INSTALL METER MANHOLE
- 11 INSTALL DIRECTIONAL BORE W/ 12" HDPE DR11 PIPE - NO TRACER WIRE REQUIRED AT BORE
- 12 RESTORE AREA WITH LANDSCAPING SOD OR MATCHING LANDSCAPING LEVEL WITH SURROUNDING AREA
- 13 RESTORE AREA WITH GRAVEL MATCHING EXISTING GRAVEL SURFACE - RESTORED AREA TO HAVE 3" MIN GRAVEL
- 14 PROTECT EXISTING ROCK WALLS IN PLACE
- 15 PROTECT EXISTING CONCRETE STRUCTURE IN PLACE
- 16 VEGETATION IN AREA TO BE TRIMMED / REMOVED AS NEEDED FOR PIPE INSTALLATION
- 17 PLACE ROCKS ALONG BANK WHERE LAND OWNERS HAVE LINED THEIR BANKS
- 18 CONNECTION #1
- 19 CONNECTION #2
- 20 INSTALL 4" HDPE DR11 PIPE
- 21 INSTALL 8" HDPE DR11 PIPE
- 22 INSTALL 4" PERFORATED MANHOLE
- 23 INSTALL SERVICE CONNECTION
- 24 INFILL OLD IRRIGATION DITCH FOR 20' EAST AND WEST OF PIPE CROSSING - COMPACT TO 90%
- 25 SAWCUT ASPHALT TO PROVIDE CLEAN EDGE - REMOVE ASPALT PAVEMENT
- 26 REPLACE ASPHALT PAVEMENT
- 27 RESTORE GRAVEL DRIVEWAY
- 28 REMOVE CURB AND GUTTER OR SIDEWALK IN FULL SECTIONS
- 29 REPLACE SIDEWALK / ADA RAMP
- 30 REPLACE CURB AND GUTTER
- 31 INSTALL 8" C900 PIPE FROM REDUCER AND SPLICE INTO EXISTING PIPES W/ COUPLER
- 32 EXISTING PUMP HOUSE REPLUMBING

SURFACE IMPACT NOTES

16 STA: 40+00. TO STA: 42+50

SCALE

0 10' 20'

HORIZ: 1" = 10' : 22 x 34
HORIZ: 1" = 20' : 11 x 17
VERT: 1" = 4' : 22 x 34
VERT: 1" = 8' : 11 x 17

811 Know what's below.
Call before you dig.
1-800-662-4111

REV. NO. COMMENT DATE

1		
2		
3		
4		
5		
6		
7		
8		
9		
10		
11		
12		
13		
14		
15		
16		
17		
18		
19		
20		
21		
22		
23		
24		
25		
26		
27		
28		
29		
30		
31		
32		



SUNRISE ENGINEERING










2100 NORTH MAIN STREET
NORTH LOGAN, UTAH 84341
TEL 435.563.3734
www.sunrise-eng.com


SMITHFIELD IRRIGATION COMPANY

MILL RACE PRESSURIZED PIPELINE
PRESSURIZED PIPELINE
PLAN AND PROFILE



SEI NO. 12499	DESIGNED HP	DRAWN JJ	CHECKED SDW	SHEET NO. 18 of 26	PP13
------------------	----------------	-------------	----------------	-----------------------	------

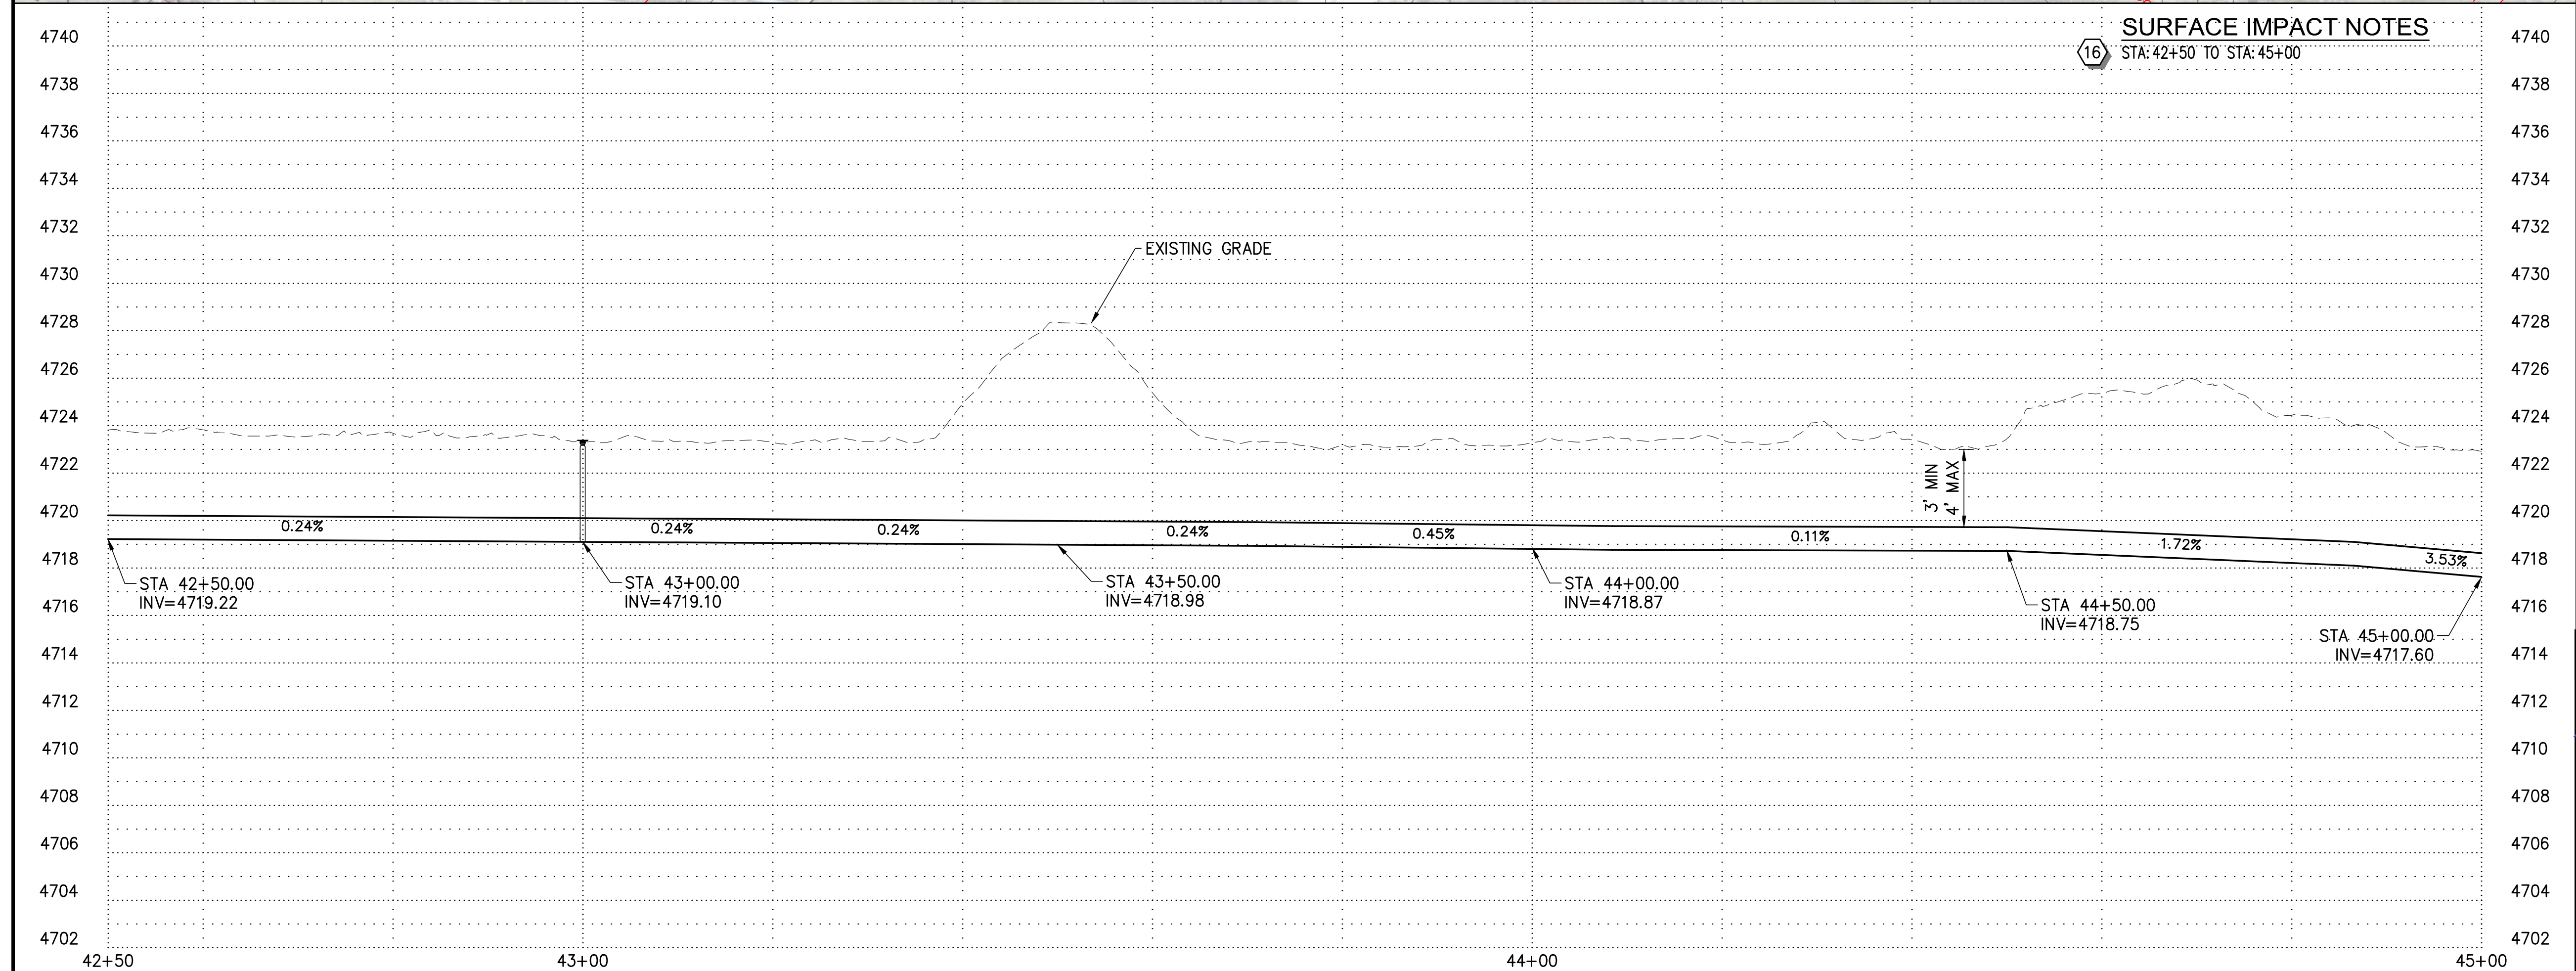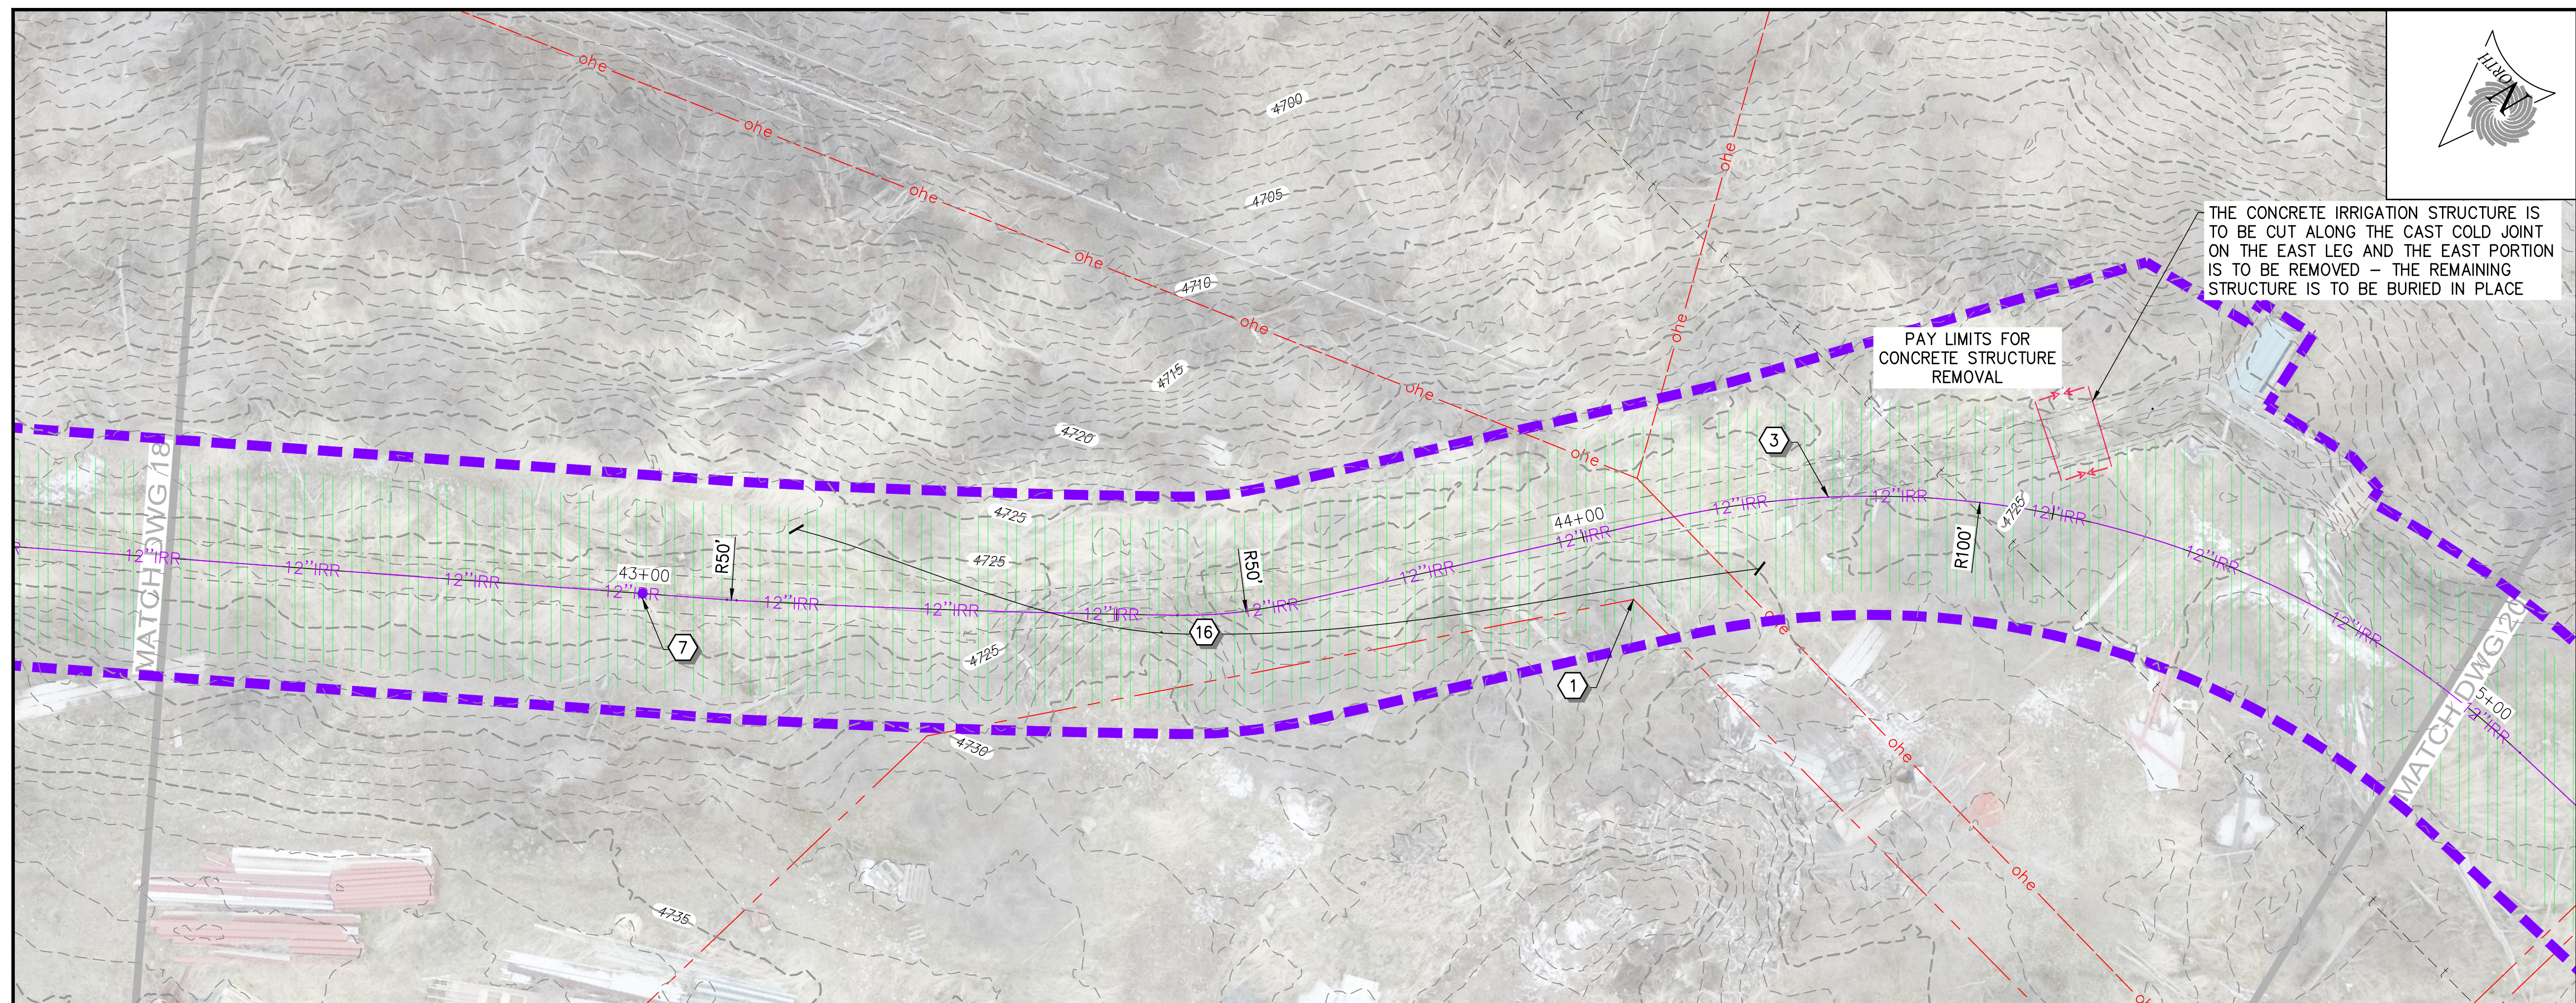

         - ## CONSTRUCTION NOTES
- 1 PROPERTY LINES
 - 2 INSTALL 18" HDPE DR11 PIPE 
 - 3 INSTALL 12" HDPE DR11 PIPE 
 - 4 INSTALL FITTING PER PLAN
 - 5 INSTALL ISOLATION VALVE 
 - 6 INSTALL AIR / VAC ASSEMBLY 
 - 7 INSTALL TRACER WIRE CURB BOX 
 - 8 INSTALL MEADOW LARK CROSSING - IN CONCRETE CULVERT, AREA SURROUNDING 12" PIPE IS TO BE CLEANED AND FILLED WITH DOWABLE FILL - PIPE IS TO BE SECURED WITH STAINLESS STEEL STRAPS 
 - 9 INSTALL SUMMIT CREEK CROSSING 
 - 10 INSTALL METER MANHOLE 
 - 11 INSTALL DIRECTIONAL BORE W/ 12" HDPE DR11 PIPE - NO TRACER WIRE REQUIRED AT BORE
 - 12 RESTORE AREA WITH LANDSCAPING SOD OR MATCHING LANDSCAPING LEVEL WITH SURROUNDING AREA
 - 13 RESTORE AREA WITH GRAVEL MATCHING EXISTING GRAVEL SURFACE - RESTORED AREA TO HAVE 3" MIN GRAVEL
 - 14 PROTECT EXISTING ROCK WALLS IN PLACE
 - 15 PROTECT EXISTING CONCRETE STRUCTURE IN PLACE
 - 16 VEGETATION IN AREA TO BE TRIMMED / REMOVED AS NEEDED FOR PIPE INSTALLATION
 - 17 PLACE ROCKS ALONG BANK WHERE LAND OWNERS HAVE LINED THEIR BANKS
 - 18 CONNECTION #1 
 - 19 CONNECTION #2 
 - 20 INSTALL 4" HDPE DR11 PIPE 
 - 21 INSTALL 8" HDPE DR11 PIPE 
 - 22 INSTALL 4" PERFORATED MANHOLE 
 - 23 INSTALL SERVICE CONNECTION 
 - 24 INFILL OLD IRRIGATION DITCH FOR 20' EAST AND WEST OF PIPE CROSSING - COMPACT TO 90%
 - 25 SAWCUT ASPHALT TO PROVIDE CLEAN EDGE - REMOVE ASPHALT PAVEMENT
 - 26 REPLACE ASPHALT PAVEMENT 
 - 27 RESTORE GRAVEL DRIVEWAY 
 - 28 REMOVE CURB AND GUTTER OR SIDEWALK IN FULL SECTIONS
 - 29 REPLACE SIDEWALK / ADA RAMP 
 - 30 REPLACE CURB AND GUTTER 
 - 31 INSTALL 8" C900 PIPE FROM REDUCER AND SPLICE INTO EXISTING PIPES W/ COUPLER 
 - 32 EXISTING PUMP HOUSE REPLUMBING 

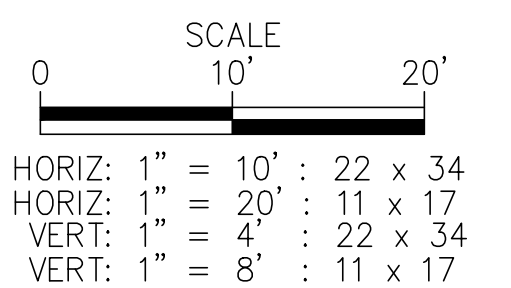



REV NO.	COMMENT	DATE
---------	---------	------

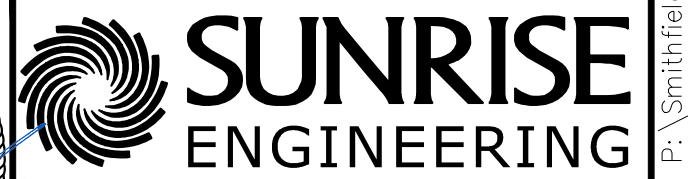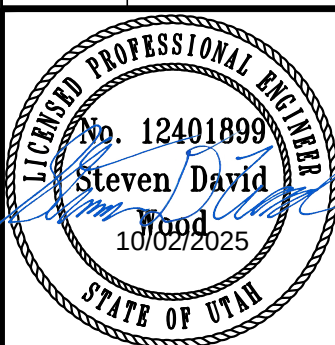




2100 NORTH MAIN STREET
NORTH LOGAN, UTAH 84341
TEL 435.563.3734
www.sunrise-eng.com

SMITHFIELD IRRIGATION COMPANY
MILL RACE PRESSURIZED PIPELINE
PRESSURIZED PIPELINE
PLAN AND PROFILE

SEI NO. 12499	DESIGNED HP	DRAWN JJ	CHECKED SDW	SHEET NO. 19 of 26	PP14
------------------	----------------	-------------	----------------	-----------------------	------

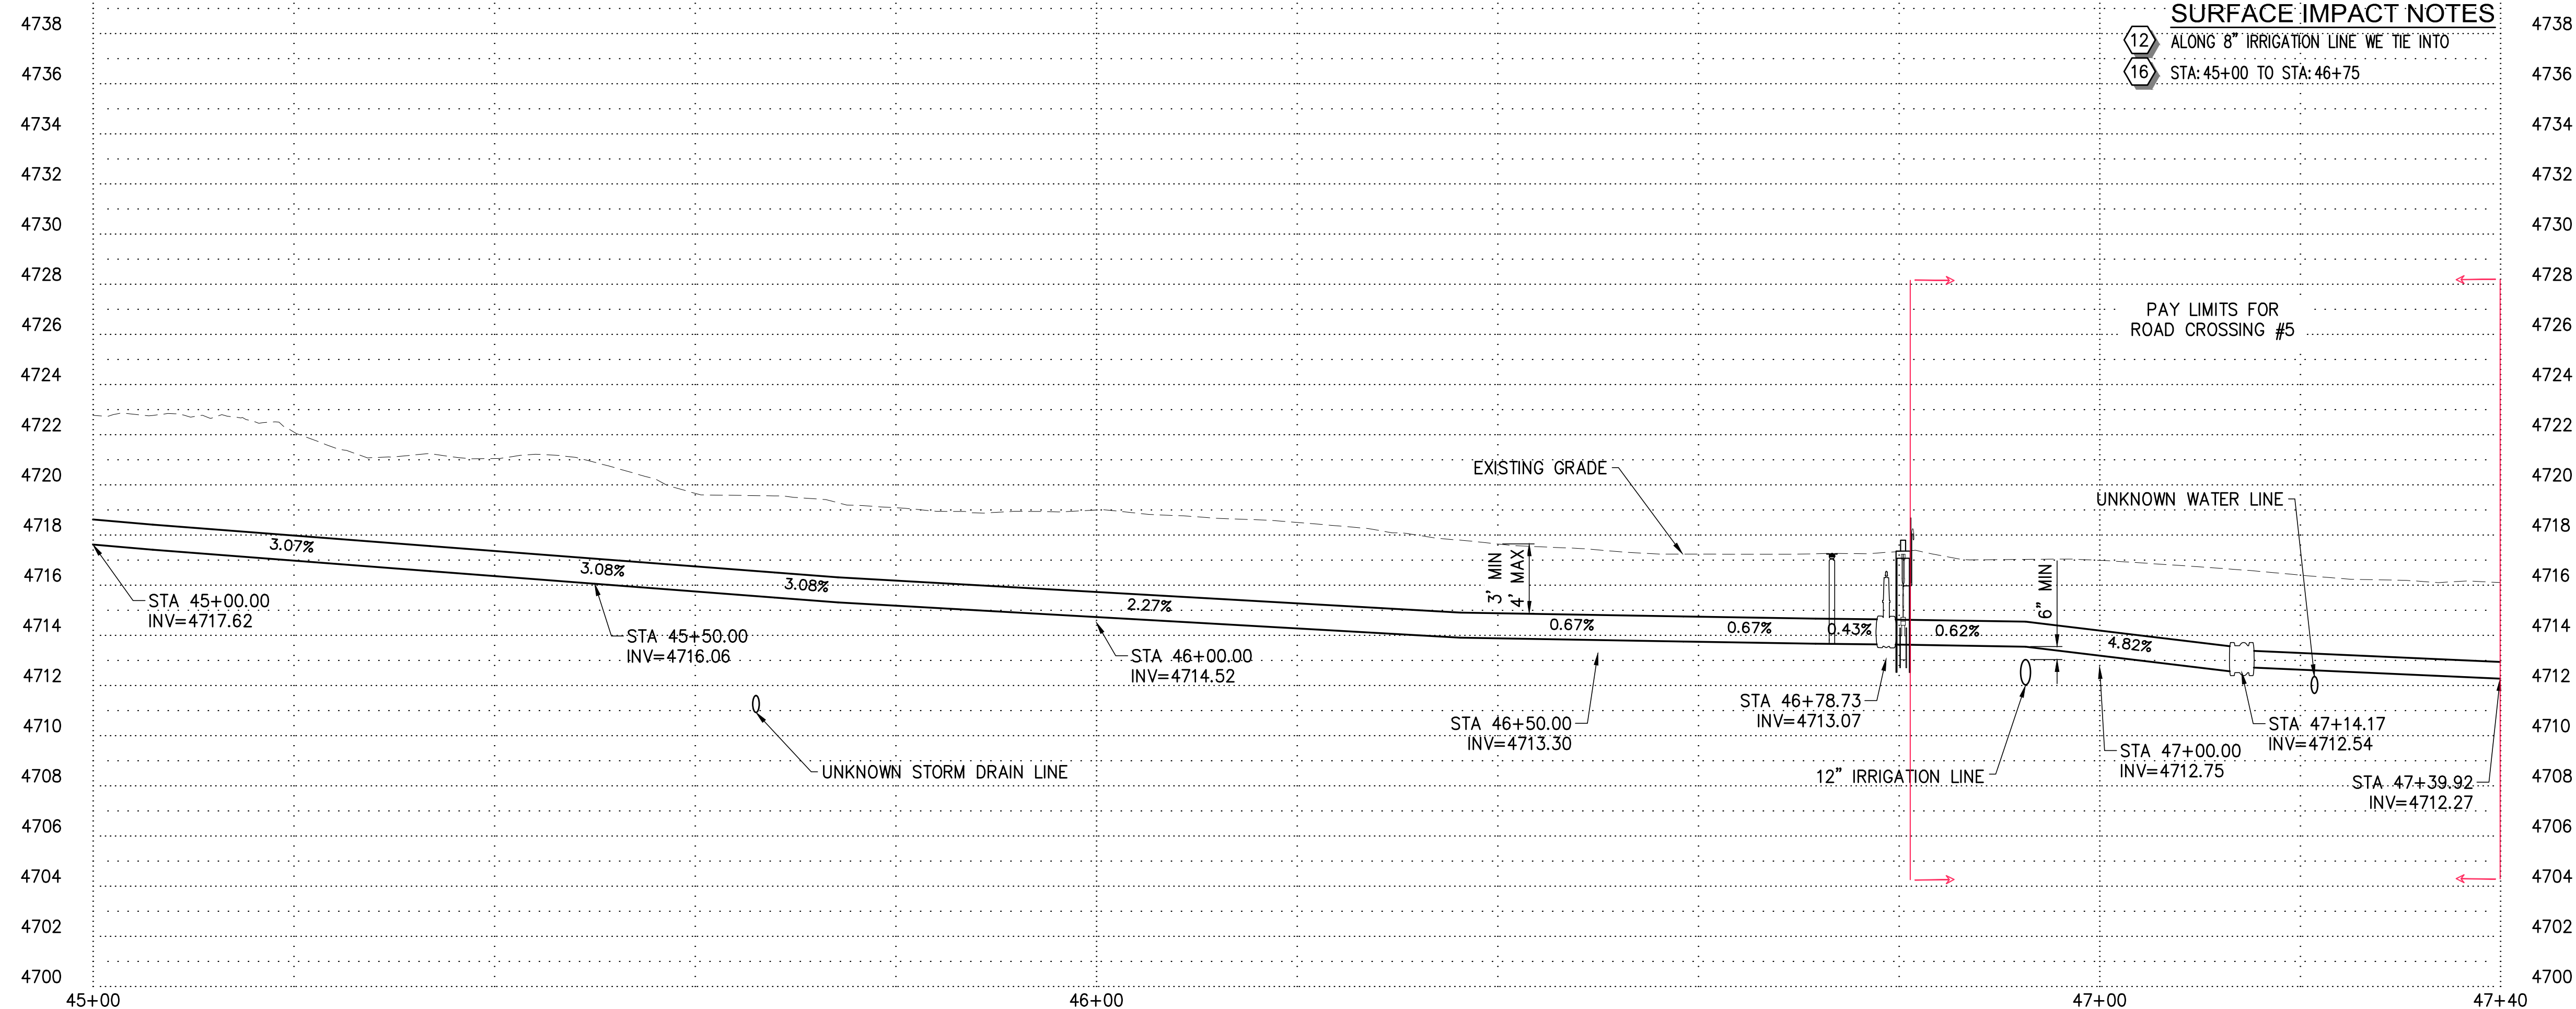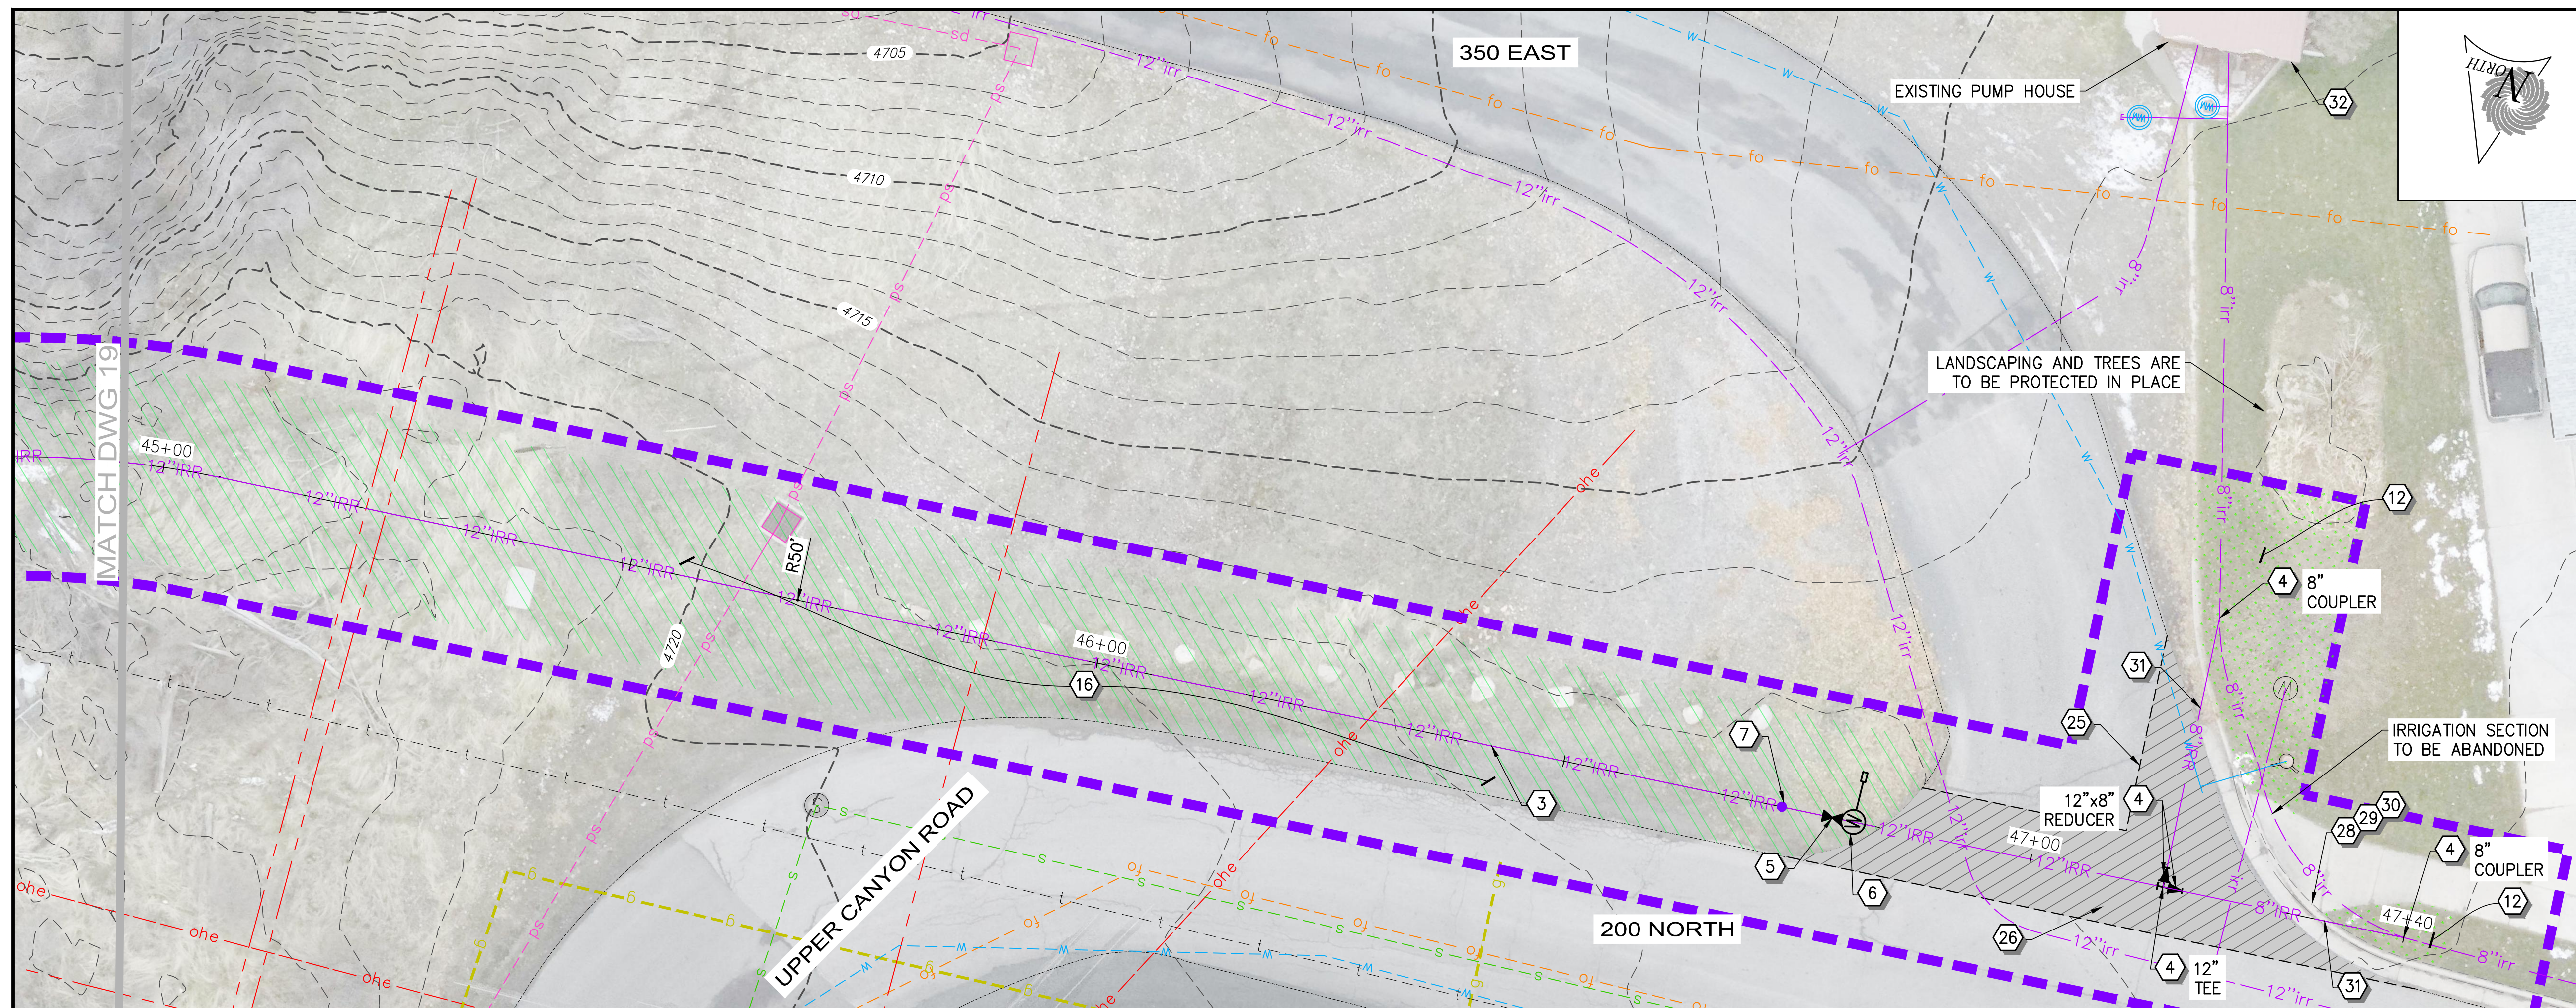

- ## CONSTRUCTION NOTES
- 1 PROPERTY LINES
 - 2 INSTALL 18" HDPE DR11 PIPE (A,B,C D1)
 - 3 INSTALL 12" HDPE DR11 PIPE (A,B,C D1)
 - 4 INSTALL FITTING PER PLAN
 - 5 INSTALL ISOLATION VALVE (D D1)
 - 6 INSTALL AIR / VAC ASSEMBLY (E D1)
 - 7 INSTALL TRACER WIRE CURB BOX (G D1)
 - 8 INSTALL MEADOW LARK CROSSING - IN CONCRETE CULVERT, AREA SURROUNDING 12" PIPE IS TO BE CLEANED AND FILLED WITH FLOWABLE FILL. PIPE IS TO BE SECURED WITH STAINLESS STEEL STRAPS (F D1)
 - 9 INSTALL SUMMIT CREEK CROSSING (K D1)
 - 10 INSTALL METER MANHOLE (E D2)
 - 11 INSTALL DIRECTIONAL BORE W/ 12" HDPE DR11 PIPE - NO TRACER WIRE REQUIRED AT BORE
 - 12 RESTORE AREA WITH LANDSCAPING SOD OR MATCHING LANDSCAPING LEVEL WITH SURROUNDING AREA
 - 13 RESTORE AREA WITH GRAVEL MATCHING EXISTING GRAVEL SURFACE - RESTORED AREA TO HAVE 3" MIN GRAVEL
 - 14 PROTECT EXISTING ROCK WALLS IN PLACE
 - 15 PROTECT EXISTING CONCRETE STRUCTURE IN PLACE
 - 16 VEGETATION IN AREA TO BE TRIMMED / REMOVED AS NEEDED FOR PIPE INSTALLATION
 - 17 PLACE ROCKS ALONG BANK WHERE LAND OWNERS HAVE LINED THEIR BANKS
 - 18 CONNECTION #1 (H D1)
 - 19 CONNECTION #2 (J D1)
 - 20 INSTALL 4" HDPE DR11 PIPE (A,B,C D1)
 - 21 INSTALL 8" HDPE DR11 PIPE (A,B,C D1)
 - 22 INSTALL 4" PERFORATED MANHOLE (A,B D2)
 - 23 INSTALL SERVICE CONNECTION (D D3)
 - 24 INFILL OLD IRRIGATION DITCH FOR 20' EAST AND WEST OF PIPE CROSSING - COMPACT TO 90%
 - 25 SAWCUT ASPHALT TO PROVIDE CLEAN EDGE - REMOVE ASPALT PAVEMENT
 - 26 REPLACE ASPHALT PAVEMENT (C D2)
 - 27 RESTORE GRAVEL DRIVEWAY (C D3)
 - 28 REMOVE CURB AND GUTTER OR SIDEWALK IN FULL SECTIONS
 - 29 REPLACE SIDEWALK / ADA RAMP (A D3)
 - 30 REPLACE CURB AND GUTTER (B D3)
 - 31 INSTALL 8" C900 PIPE FROM REDUCER AND SPLICE INTO EXISTING PIPES W/ COUPLER (A,B,C D1)
 - 32 EXISTING PUMP HOUSE REPLUMBING (A D5)

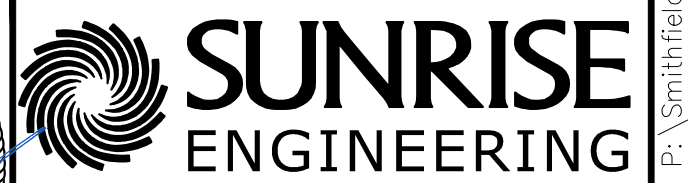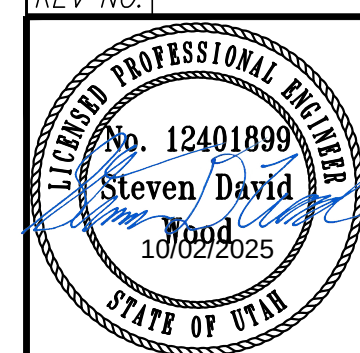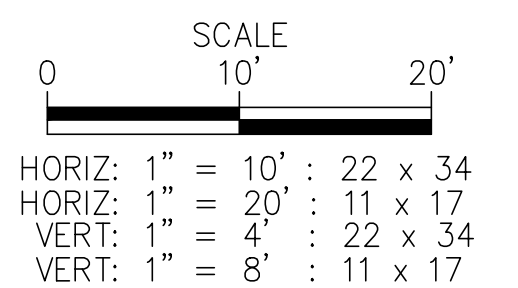

2100 NORTH MAIN STREET
NORTH LOGAN, UTAH 84341
TEL 435.563.3734
www.sunrise-eng.com

SMITHFIELD IRRIGATION COMPANY
MILL RACE PRESSURIZED PIPELINE
PRESSURIZED PIPELINE
PLAN AND PROFILE

SEI NO. 12499	DESIGNED HP	DRAWN JJ	CHECKED SDW	SHEET NO. 20 of 26	PP15
------------------	----------------	-------------	----------------	-----------------------	------

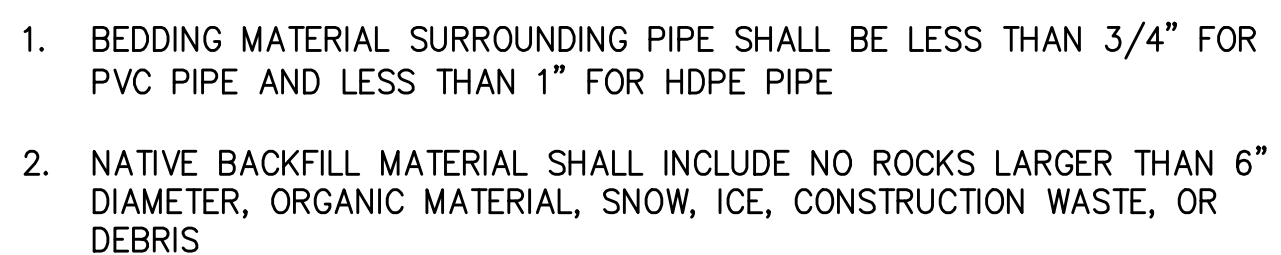


Diagram illustrating the cross-section of a pipeline installation, showing the following layers and dimensions:

- (4") ROAD BASE - COMPACTED - MATCH EXISTING GRADE
- EXISTING SURFACE MATERIAL
- COMPACT NATIVE MATERIAL
- UTILITY TAPE
- TRACER WIRE
- PIPE BEDDING MATERIAL 3/4" MINUS GRAVEL
- PIPELINE PER PLAN

Dimensions:

- VARIES 2' MIN (Road Base)
- 12" MIN (Compact Native Material)
- 9" MIN (Pipe Bedding Material on each side)
- 6" MIN (Pipeline diameter)

1. SEE TRENCH EXCAVATION AND BACKFILL SPEC 02200 FOR COMPACTION REQUIREMENTS.
2. A MAXIMUM 3/4" FOR ALL BEDDING MATERIAL
3. ALL AREAS WHERE THIS DETAIL IS USED, THE CONTRACTOR WILL BE RESPONSIVE FOR IT UNDER THE BASE BID
4. ALL PIPE FITTINGS ARE INCIDENTAL TO THE PIPE & WILL BE ACCOUNTED FOR IN THE PIPE INSTALLATION BID ITEMS

1. SAW CUT PAVEMENT EDGES. APPLY A HOT-POUR RUBBERIZED ASPHALT JOINT SEALANT OR APPROVED EQUAL, APPLIED AFTER PATCH IS INSTALLED.
2. FOR ASPHALT CONSTRUCTION WITHIN THE CITY ROW USE 3 INCHES OF APPROVED HOT MIX ASPHALT (HMA), PG-GRADE 58-28 ASPHALT BINDER, 1/2 INCH NOMINAL MAX; OVER 4 INCHES UNTREATED BASE COURSE (UTBC GRADE 1) PER APWA 32 11 23; OVER 12 INCHES A-1-A GRANULAR BORROW (GB) PER APWA 31 05 13. PROVIDE DOCUMENTATION OF COMPACTION.

- ### 3. TRENCH DETAIL IN EXISTING CITY ROADS

TRACER WIRE CURB BOX

GATE VALVE OR BUTTERFLY VALVE (SIZE INDICATED ON PLAN) RATED FOR DIRECT BURY, 25:1 MIN GEAR BOX ON VALVE.

DRAIN ROCK

CONCRETE THRUST BLOCK W/ TIE DOWN RODS

PIPELINE PER PLAN

BOTTOM OF PVC VALVE BOX TO BE "DOG-HOUSED" OVER VALVE NUT

PVC VALVE BOX SIZED TO FIT OVER THE ACTUATOR FLANGE AND OPERATING NUT

12"


3" MIN

- NOTE:
1. VALVES 12" AND SMALLER USE GATE VALVE
 2. VALVES LARGER THAN 12" USE BUTTERFLY VALVE

Diagram illustrating the assembly of a concrete collar and valve box for a tracer wire:

- CONCRETE COLLAR 6" THICK, 18" ϕ
- LID STAMPED "IRRIGATION"
- SECURE TRACER WIRE W/ 24" PIGTAIL
- ATTACH TRACER WIRE ON THE INSIDE OF VALVE BOX
- 2" CAST IRON VALVE BOX (ADJUSTABLE, SCREW TYPE)

811 Know what's **below**.
Call before you dig.
 1-800-662-4111

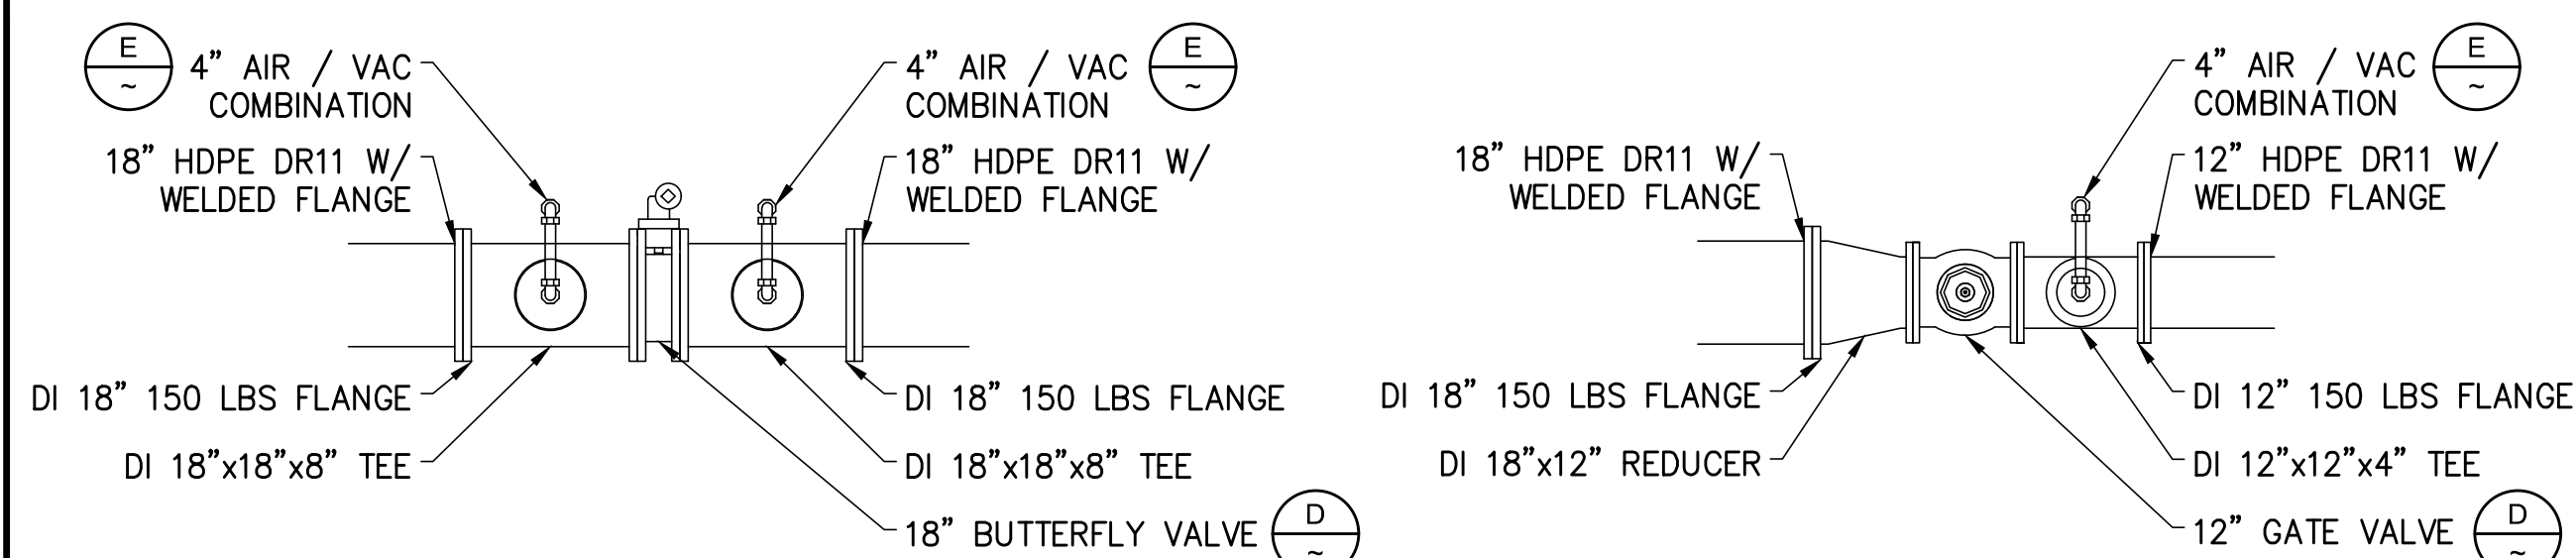

12"Ø DI OR GALVANIZED STEEL PIPE

AREA BETWEEN PIPE AND CONCRETE (BETWEEN FLANGES) TO BE FILLED WITH FLOWABLE FILL

BOX CULVERT BRIDGE

STAINLESS STEEL STRAP SECURED TO CONCRETE W/ 4" CONCRETE ANCHORS - 4' O.C.

SECTION THROUGH BOX CULVERT AT MEADOW LARK CROSSING

DI 12" 45° ELBOW – 45° HORIZONTAL 0° VERTICAL

PAY LIMIT FOR MEADOW LARK CROSSING

43'-1"

DI 12" 45° ELBOW – 45° HORIZONTAL 0° VERTICAL

DI 12" CLASS 150 FLANGE

DI 12" HDPE DR11 W/ WELDED FLANGE

2'-0"

20'-1 3/4"

3'-7 3/4"

DI 12" HDPE DR11 W/ WELDED FLANGE

DI 12" CLASS 150 FLANGE

2'-0"

45° HORIZONTAL 45° VERTICAL

PIPE MATERIAL TO BE:

- DUCTILE IRON PIPE, EPOXY COATED INSIDE AND OUTSIDE
- MILD STEEL PIPE, 3/8" THICKNESS, COATED THROUGH HOT DIP GALVANIZING PROCESS

DETAIL - MEADOW LARK CROSSING

NOT TO SCALE PLAN VIEW

(3) STEEL PIPE SUPPORTS WELDED TO I-BEAM – BUILT FROM 6" MILD STEEL 1/2"

- PIPE MATERIAL TO BE:
- DUCTILE IRON PIPE, EPOXY COATED INSIDE AND OUTSIDE
 - MILD STEEL PIPE, 3/8" THICKNESS, COATED THROUGH HOT DIP GALVANIZING PROCESS

ELBOW -
45° HORIZONTAL
0° VERTICAL

DI 12" 90°
ELBOW -
0° HORIZONTAL
90° VERTICAL

12" HDPE DR11 W/
WELDED FLANGE

DI 12" CLASS
150 FLANGE

PIPE ENCASEMENT

(3) STEEL PIPE SUPPORTS WELDED TO
I-BEAM - BUILT FROM 6" MILD STEEL 1/2"
THICK PIPE W/ A HALF CIRCLE CRADLE

46'-6 3/4"

3" THREADED
PENETRATION
W/ AIR VAC

PAY LIMIT FOR SUMMIT
CREEK CROSSING

3" THREADED
PENETRATION
W/ AIR VAC

6" MIN

5'-3 1/4"

I BEAM: W12x87

12" DI CAP END FOR DRAIN
W/ 3" THREADED
PENETRATION W/ BALL VALVE

WELDED SECTION OF
I-BEAM TO LIFT
I-BEAM HORIZONTAL

12" DI TEE

DI 12" 45° ELBOW -
0° HORIZONTAL 45° VERTICAL

12" HDPE DR11 W/
WELDED FLANGE

DI 12" CLASS
150 FLANGE

PIPE ENCASEMENT


5'

5'

(C
D2)

(D
D2)

- PIPE MATERIAL TO BE:
- DUCTILE IRON PIPE, EPOXY COATED INSIDE AND OUTSIDE
 - MILD STEEL PIPE, 3/8" THICKNESS, COATED THROUGH HOT DIP GALVANIZING PROCESS

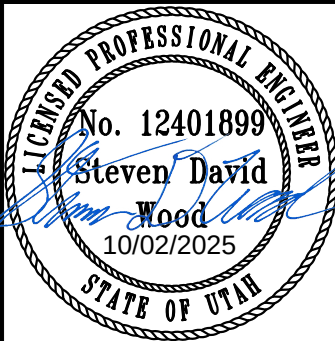REV NO.		COMMENT		DATE	
		 SUNRISE ENGINEERING			
		2100 NORTH MAIN STREET NORTH LOGAN, UTAH 84341 TEL 435.563.3734 www.sunrise-eng.com			
SMITHFIELD IRRIGATION COMPANY					
MILL RACE PRESSURIZED PIPELINE					
DETAILS					
PIPELINE DETAILS					
SEI NO. 12499	DESIGNED HP	DRAWN JJ	CHECKED SDW	SHEET NO. 21 of 26	P1



INSTALL 8" BALL CHECK VALVE
(FLOWMATIC OR APPROVED EQUAL)
FL TO FL W/ BUTTERFLY VALVE
AND INSTALL 8" FLANGE ADAPTER
- FL TO PE ON DISCHARGE SIDE

SAMPLE TAPS TO BE PROTECTED IN PLACE

6"
MIN


CUT 8" DI PIPE CLEANLY AT A 90° ANGLE
- CUT TO BE MIN 6" FROM NEAREST TAP
- THE CUT IS TO BE POSITIONED TO
PROVIDE ENOUGH ROOM FOR THE CHECK
VALVE AND ADAPTER INSTALLATION WITH
NO NEED FOR ADDITIONAL DI PIPE
INSTALLATION - ENGINEER TO VERIFY
CUT LOCATION PRIOR TO CUTTING

REMOVE ADAPTER AND DI
PIPE BETWEEN BUTTERFLY
VALVE AND CUT



Know what's below.
Call before you dig.
1-800-662-4111

REV NO.	COMMENT	DATE

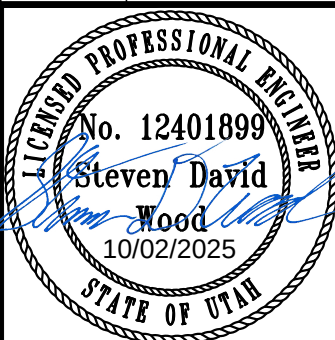

SUNRISE
ENGINEERING
2100 NORTH MAIN STREET
NORTH LOGAN, UTAH 84341
TEL 435.563.3734
www.sunrise-eng.com


SMITHFIELD IRRIGATION COMPANY
MILL RACE PRESSURIZED PIPELINE
DETAILS
EXISTING PUMP HOUSE REPLUMBING

SEI NO.	DESIGNED	DRAWN	CHECKED	SHEET NO.	
12499	HP	JJ	SDW	25 of 26	D5

A DETAIL - EXISTING PUMP HOUSE REPLUMBING
~ NOT TO SCALE


CONCRETE THRUST BLOCK
RESTRAINING SYSTEM DETAILS

NOTE
CONTRACTOR SHALL USE EITHER MEGALUG OR
CONCRETE THRUST RESTRAINING SYSTEM FOR
THE ENTIRE PROJECT.

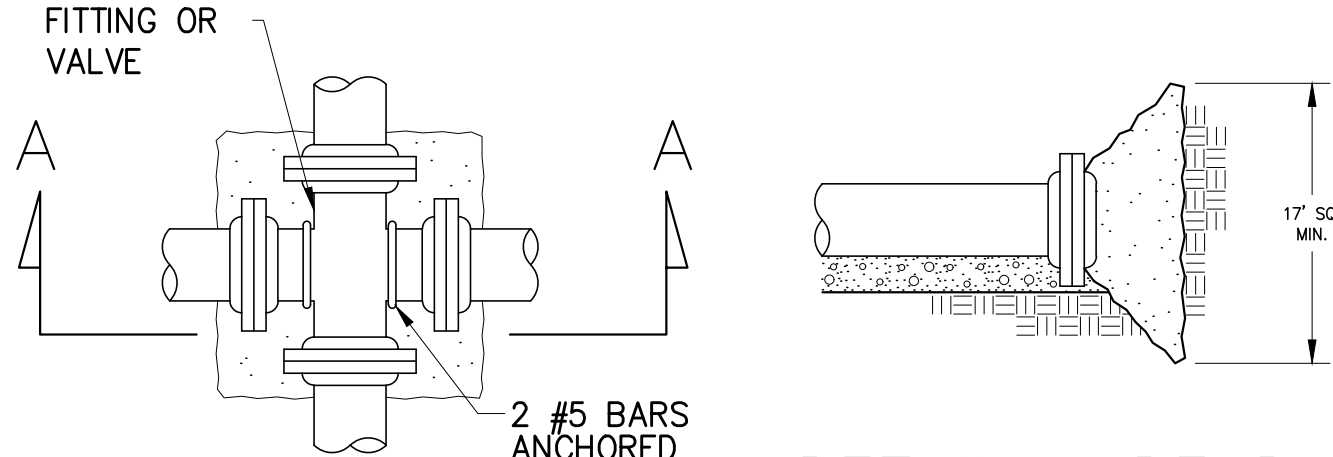

PLAN — THRUST BLOCK

DETAIL — DEAD END
THRUST BLOCK

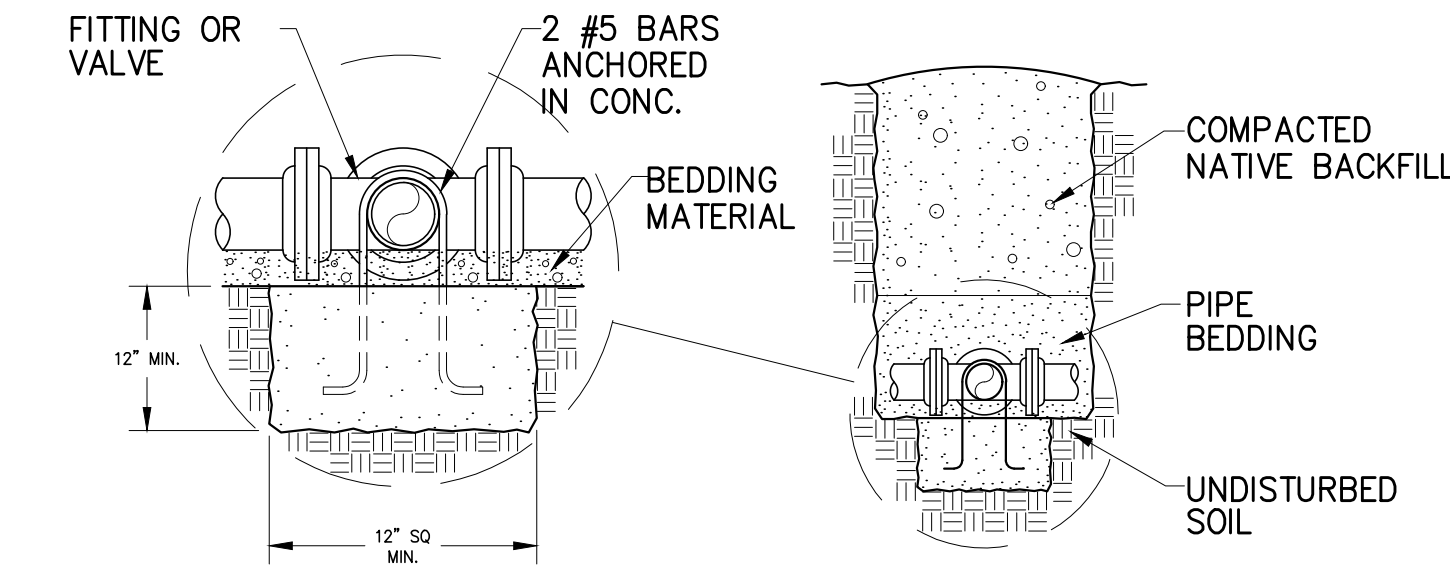

SECTION A-A

THRUST BLOCK BEARING AREA IN SQ. FT.

PIPE SIZE	CROSS	TEE	WYE	DEAD END	VALVE	90° BEND	45° BEND	22.5° BEND	11.25° BEND
4	2.4	1.7	1.7	1.7	1.7	2.4	1.3	1.0	1.0
6	5.4	3.8	3.8	3.8	3.8	5.4	2.9	1.5	1.0
8	9.6	6.8	6.8	6.8	6.8	9.6	5.2	2.7	1.4
10	15.0	10.6	10.6	10.6	10.6	15.0	8.1	4.2	2.1
12	21.5	15.2	15.2	15.2	15.2	21.5	11.7	6.0	3.0
14	29.3	20.7	20.7	20.7	20.7	29.3	15.9	8.1	4.1
16	38.2	27.0	27.0	27.0	27.0	38.2	20.7	10.6	5.3
18	48.4	34.2	34.2	34.2	34.2	48.4	26.2	13.4	6.7
20	59.7	42.2	42.2	42.2	42.2	59.7	32.3	16.5	8.3
24	85.9	60.8	60.8	60.8	60.8	85.9	46.5	23.7	11.9

REDUCER

D2 \ D1	6	8	10	12	14	16	18	20	24
4	2.1	5.1	8.8	13.4	—	—	—	—	—
6	—	3.0	6.7	11.3	16.8	23.1	—	—	—
8	—	—	3.8	8.4	13.8	20.1	27.2	—	—
10	—	—	—	4.6	10.1	16.3	23.5	31.4	—
12	—	—	—	—	5.5	11.7	18.8	26.8	45.2
14	—	—	—	—	—	6.3	13.4	21.3	39.8
16	—	—	—	—	—	—	7.1	15.1	33.5
18	—	—	—	—	—	—	—	8.0	26.3
20	—	—	—	—	—	—	—	—	18.4

NOTES:

- ALL THRUST BLOCK BEARING FACES SHALL BE PLACED AGAINST UNDIS-
TURBED SOIL OR APPROVED COMPACTED BACKFILL.
- SQUARE ALL EDGES TO RECEIVE CONCRETE.
- CONCRETE SHALL BE CLASS C.
- CALCULATED ON 200 PSI TEST PRESSURE AND ALLOWABLE BEARING
PRESSURE OF 1500 LBS. PER SQ. FT.
- IN POORER SOILS SPECIAL DESIGN IS REQUIRED.
- ALL FITTINGS AND VALVES SHALL BE ANCHORED WITH TWO #5 REBAR.
ONLY ONE REQ'D FOR REDUCER
- CENTER ALL FITTINGS OVER THRUST BLOCKS.

A
~
DETAIL - THRUST BLOCK
NOT TO SCALE

NOTE

CONTRACTOR SHALL USE EITHER MEGALUG OR
CONCRETE THRUST RESTRAINING SYSTEM FOR
THE ENTIRE PROJECT.

MEGALUG
THRUST RESTRAINING SYSTEM DETAILS

* CALCULATIONS DERIVED FROM EBAA IRON SALES

BASED ON:
TEST PRESSURE 200 PSI
SOIL TYPE: GM — SILTY GRAVEL, GRAVEL-SAND-SILT MIXTURE
BURIAL DEPTH: 4 FT.
TRENCH TYPE: 5 — PIPE BEDDED IN COMPACTED GRANULAR

MATERIAL TO THE CENTER LINE OF PIPE, 4" MIN. UNDER PIPE.
COMPACTED GRANULAR OR SELECT MATERIAL TO TOP OF PIPE.
(APPROX. 90% STANDARD PROCTOR, AASHTO T-99)
SAFETY FACTOR: 1.5

PVC VERTICLE BEND RESTRAINED LENGTHS IN FT. (L ₁ —BEFORE CONNECTION/L ₂ —AFTER CONNECTION)										
BEND ANGLE	PIPE SIZE									
11.25	4	6	8	10	12	14	16	18	20	24
22.5	4/1	5/2	7/2	9/3	10/3	12/4	13/4	15/5	16/5	19/6
45	8/3	11/4	15/5	17/6	21/7	24/8	27/9	30/9	33/10	38/12
45	16/5	23/8	30/10	36/12	43/14	49/16	56/18	62/20	68/21	79/25

CALCULATIONS BASED ON THE ELEVATION OF THE PIPE REMAINING CONSTANT WITH
THE CONTOUR OF THE GROUND. FOR TWO WAY FLOW, SUCH AS FOUND IN
DISTRIBUTION SYSTEMS, USE L₁ ON BOTH SIDES OF FITTING.

PVC HORIZONTAL BEND RESTRAINED LENGTHS L, IN FT.										
BEND ANGLE	PIPE SIZE									
11.25	4	6	8	10	12	14	16	18	20	24
22.5	1	2	2	3	3	4	4	5	5	6
45	3	4	5	6	7	8	9	9	10	12
90	5	8	10	12	14	16	18	20	21	25
90	13	18	24	29	34	38	43	47	52	60

1. ALL JOINTS WITHIN THE "L" DISTANCE SHALL BE RESTRAINED

PVC TEE RESTRAINED LENGTHS L, IN FT.										
BRANCH SIZE DIA.	RUN SIZE DIAMETER									
	4	6	8	10	12	14	16	18	20	24
4	*	*	*	*	*	*	*	*	*	*
6	—	*	*	*	*	*	*	*	*	*
8	—	—	*	*	*	*	*	*	*	*
10	—	—	—	*	*	*	*	*	*	*
12	—	—	—	—	*	*	*	*	*	*
14	—	—	—	—	—	*	*	*	*	*
16	—	—	—	—	—	—	7	*	*	*
18	—	—	—	—	—	—	—	20	4	*
20	—	—	—	—	—	—	—	—	34	3
24	—	—	—	—	—	—	—	—	—	60

* = FOR THIS CONDITION NEED ONLY RESTRAIN THE OUTLETS OF TEE

NOTES:

- RESTRAIN THE THREE MECHANICAL JOINTS ON THE TEE.
- ALL JOINTS WITHIN THE "L" DISTANCE ON THE BRANCH SIDE OF TEE SHALL
BE RESTRAINED AND ALL JOINTS WITHIN 18' ON THE RUN SIDE OF THE TEE
SHALL BE RESTRAINED.

PVC REDUCER RESTRAINED LENGTHS L, IN FT.
(SMALL SIDE/LARGE SIDE)


D2 \ D1	6	8	10	12	14	16	18	20	24
4	42/29	100/52	171/71	258/90	—	—	—	—	—
6	—	40/31	88/54	147/75	217/95	297/113	—	—	—
8	—	—	37/29	82/55	135/77	197/98	266/117	—	—
10	—	—	—	36/30	79/56	128/80	183/100	244/120	—
12	—	—	—	—	36/30	77/57	123/80	174/102	293/142
14	—	—	—	—	—	35/30	74/57	118/81	219/124
16	—	—	—	—	—	—	34/30	73/57	161/104
18	—	—	—	—	—	—	—	34/30	111/82
20	—	—	—	—	—	—	—	—	70/57

1. ALL JOINTS WITHIN THE "L" DISTANCE SHALL BE RESTRAINED

PVC DEAD END RESTRAINED LENGTHS L, IN FT.

PIPE SIZE									
4	6	8	10	12	14	16	18	20	24
39	55	73	88	104	119	134	149	163	192

1. ALL JOINTS WITHIN THE "L" DISTANCE SHALL BE RESTRAINED

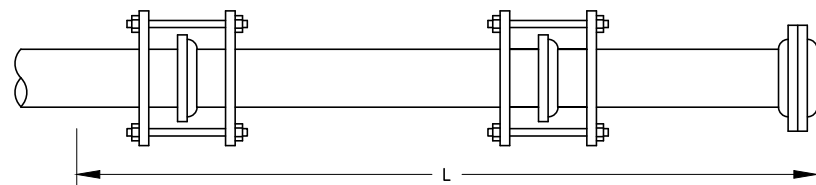

EXAMPLE:
PIPE TYPE = DIP
PIPE SIZE = 10"
L = 57'

B
~
DETAIL - MECHANICAL THRUST RESTRAINING SYSTEM DETAILS FOR PRESSURE SYSTEMS
NOT TO SCALE

DIP VERTICLE BEND RESTRAINED LENGTHS IN FT. (L ₁ —BEFORE CONNECTION/L ₂ —AFTER CONNECTION)										
BEND ANGLE	PIPE SIZE									
11.25	4	6	8	10	12	14	16	18	20	24
22.5	2/1	4/2	5/2	6/2	7/3	8/3	8/4	9/4	10/4	12/5
45	5/2	7/3	9/4	11/5	13/6	15/6	17/7	19/8	21/9	24/10
45	11/5	15/6	20/8	23/10	28/12	32/13	36/15	40/17	43/18	51/21

CALCULATIONS BASED ON THE ELEVATION OF THE PIPE REMAINING CONSTANT WITH
THE CONTOUR OF THE GROUND.

DIP HORIZONTAL BEND RESTRAINED LENGTHS L, IN FT.										
BEND ANGLE	PIPE SIZE									
11.25	4	6	8	10	12	14	16	18	20	24
22.5	1	2	2	2	3	3	4	4	4	5
45	2	3	4	5	6	6	7	8	9	10
90	5	6	8	10	12	13	15	17	18	21
90	11	15	20	24	28	32	36	40	44	51

1. ALL JOINTS WITHIN THE "L" DISTANCE SHALL BE RESTRAINED

DIP TEE RESTRAINED LENGTHS L, IN FT.										
BRANCH SIZE DIA.	RUN SIZE DIAMETER									
	4	6	8	10	12	14	16	18	20	24
4	*	*	*	*	*	*	*	*	*	*
6	—	*	*	*	*	*	*	*	*	*
8	—	—	*	*	*	*	*	*	*	*
10	—	—	—	*	*	*	*	*	*	*
12	—	—	—	—	*	*	*	*	*	*
14	—	—	—	—	—	*	*	*	*	*
16	—	—	—	—	—	—	12	2	*	*
18	—	—	—	—	—	—	—	21	12	*
20	—	—	—	—	—	—	—	—	30	12
24	—	—	—	—	—	—	—	—	—	47

* = FOR THIS CONDITION NEED ONLY RESTRAIN THE OUTLETS OF TEE

NOTES:

- RESTRAIN THE THREE MECHANICAL JOINTS ON THE TEE.
- ALL JOINTS WITHIN THE "L" DISTANCE ON THE BRANCH SIDE OF TEE SHALL
BE RESTRAINED AND ALL JOINTS WITHIN 18' ON THE RUN SIDE OF THE TEE
SHALL BE RESTRAINED.

DIP REDUCER RESTRAINED LENGTHS L, IN FT.
(SMALL SIDE/LARGE SIDE)


D2 \ D1	6	8	10	12	14	16	18	20	24
4	27/18	65/34	110/46	166/58	—	—	—	—	—
6	—	26/20	57/35	95/48	140/61	192/73	—	—	—
8	—	—	24/19	53/35	87/50	127/63	171/75	—	—
10	—	—	—	—	51/36	82/51	118/64	158/77	—
12	—	—	—	—	—	23/20	49/37	79/52	112/66
14	—	—	—	—	—	—	22/20	48/37	76/52
16	—	—	—	—	—	—	—	22/19	47/37
18	—	—	—	—	—	—	—	—	22/19
20	—	—	—	—	—	—	—	—	—

1. ALL JOINTS WITHIN THE "L" DISTANCE SHALL BE RESTRAINED


DIP DEAD END RESTRAINED LENGTHS L, IN FT.

PIPE SIZE									
4	6	8	10	12	14	16	18	20	24
25	36	47	57	67	76	86	95	105	123


1. ALL JOINTS WITHIN THE "L" DISTANCE SHALL BE RESTRAINED

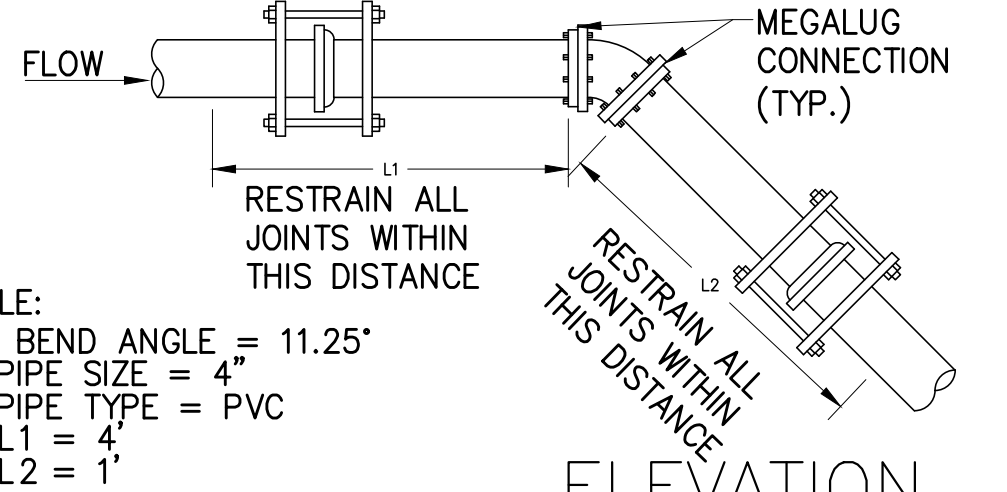


EXAMPLE:
GIVEN: BEND ANGLE = 11.25°
PIPE SIZE = 4"
PIPE TYPE = PVC
L₁ = 4'
L₂ = 1'

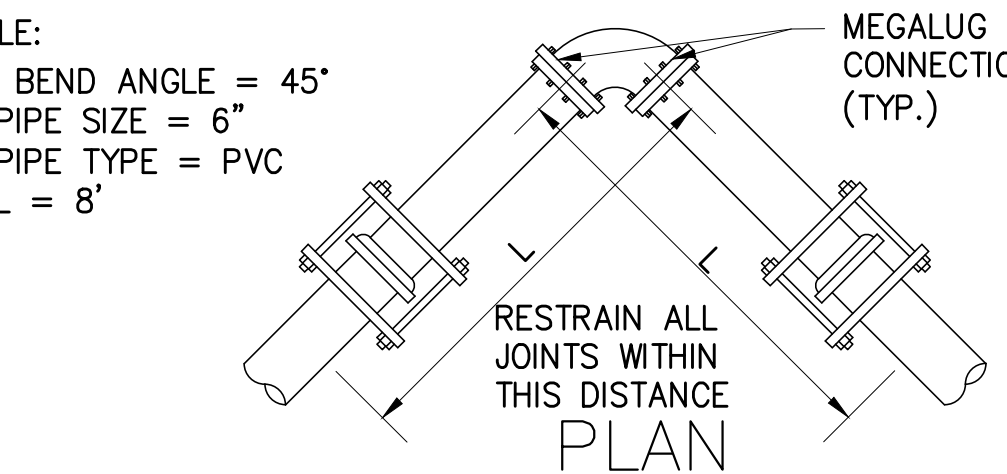

EXAMPLE:
GIVEN: BEND ANGLE = 45°
PIPE SIZE = 6"
PIPE TYPE = PVC
L = 8'

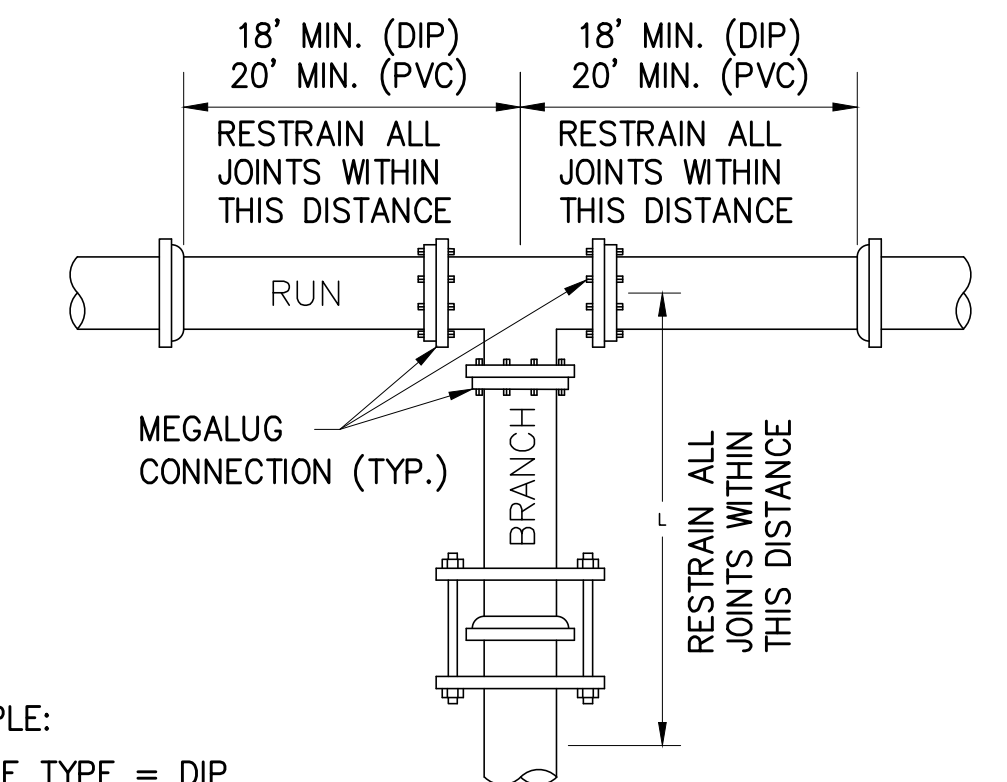

EXAMPLE:
PIPE TYPE = DIP
PIPE SIZE = 16"
L = 12'

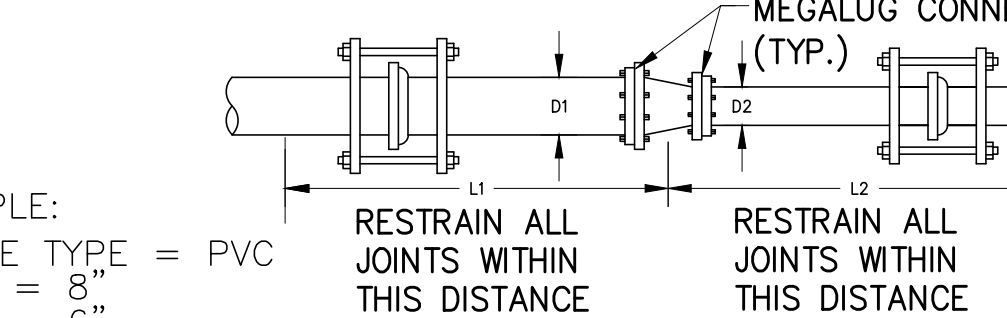

EXAMPLE:
PIPE TYPE = PVC
D₁ = 8"
D₂ = 6"
L₁ = 31'
L₂ = 40'

811 Know what's below.
Call before you dig.
1-800-662-4111

REV. NO.	COMMENT	DATE

2100 NORTH MAIN STREET
NORTH LOGAN, UTAH 84341
TEL 435.563.3734
www.sunrise-eng.com

SMITHFIELD IRRIGATION COMPANY

MILL RACE PRESSURIZED PIPELINE

DETAILS
THRUST BLOCK DETAILS

SEI NO.	DESIGNED	DRAWN	CHECKED	SHEET NO.	
12499	HP	JJ	SDW	26 of 26	D6