


STORAGE WAREHOUSE EXPANSION FOR:
WEST POINT DAIRY PRODUCTS

HYRUM,

UTAH

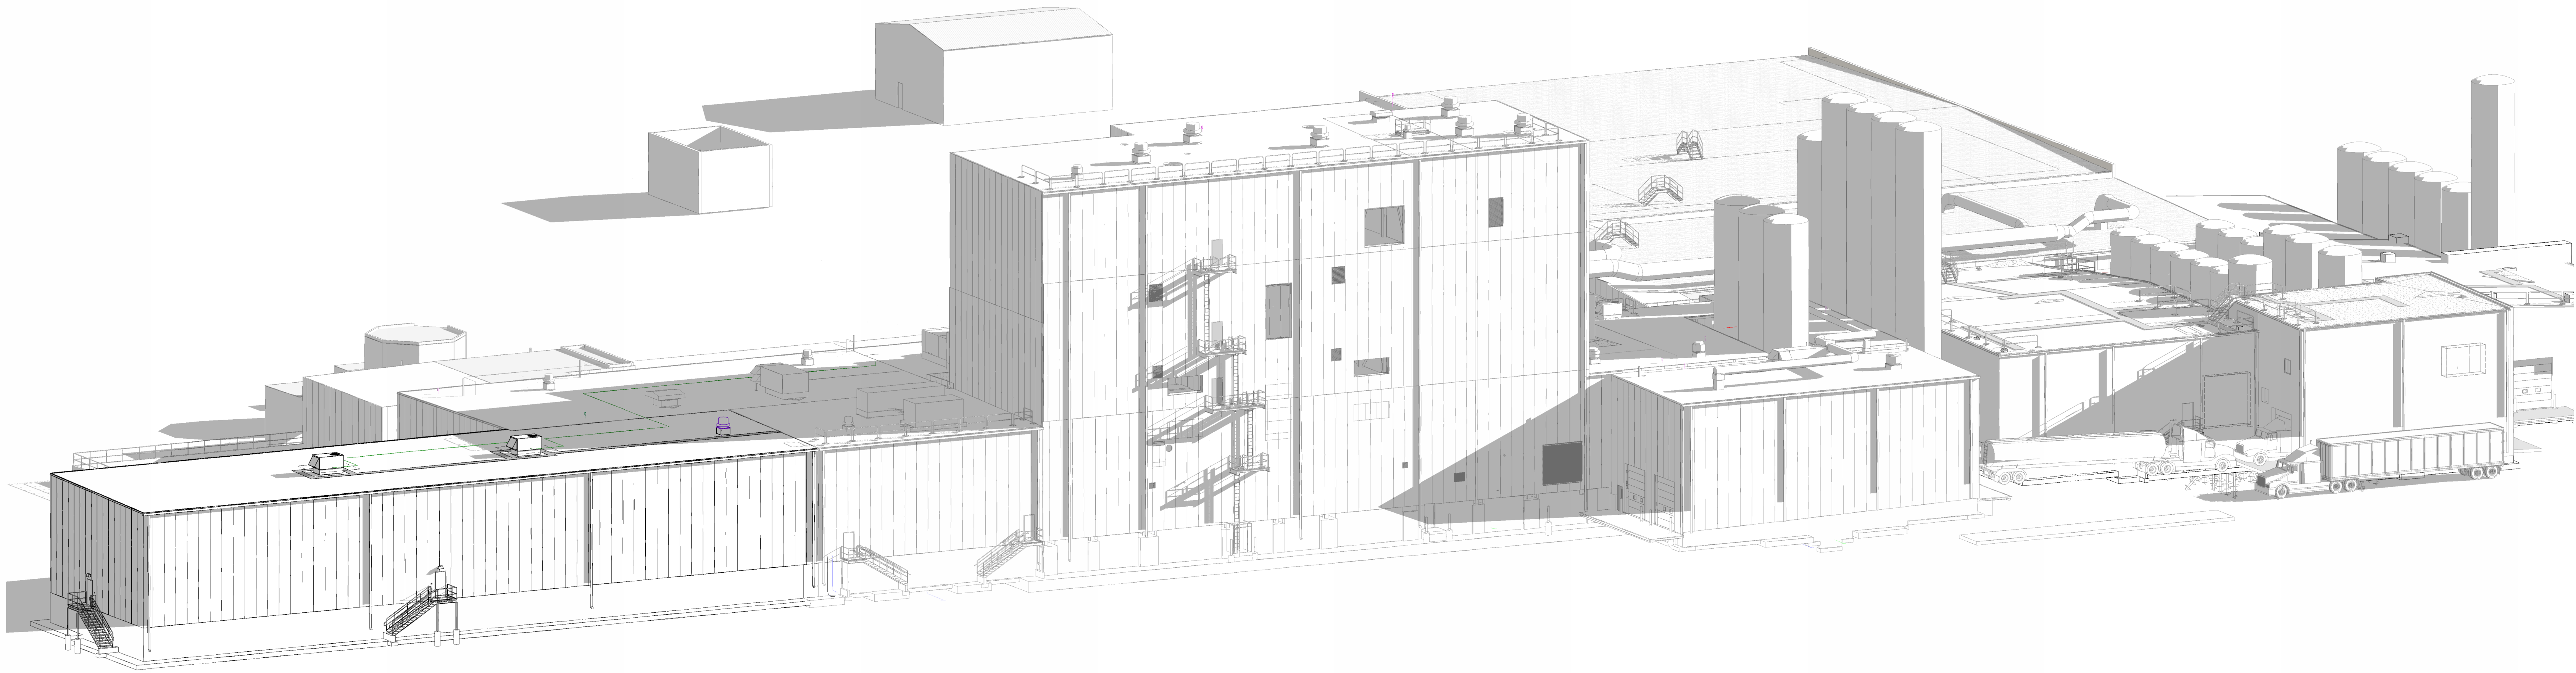


ISOMETRIC LOOKING SOUTHWEST


PROJECT CONTACTS

OWNER INFORMATION: LAVERNE GREGORICH 570 NORTH 500 WEST HYRUM, UT 84319	PROJECT MANAGER DAVID KOENES Phone: (920)322-1673 E-mail: david.koenes@excelengineer.com	ARCHITECTURAL: DAN ST. LOUIS Phone: (920)322-1672 E-mail: daniel.stlouis@excelengineer.com	CIVIL: JASON DAYE Phone: (920)322-1687 E-mail: jason.daye@excelengineer.com
STRUCTURAL: KEVIN CLINARD Phone: (920)322-1715 E-mail: kevin.clinard@excelengineer.com	ELECTRICAL: ADAM GRONERT Phone: (920)322-1660 E-mail: adam.gronert@excelengineer.com	HVAC: DOUG ELGERSMA Phone: (920)322-1676 E-mail: douglas.elgersma@excelengineer.com	PLUMBING & FIRE PROTECTION: JAY OESTREICH Phone: (920)322-1691 E-mail: jay.oestreich@excelengineer.com

LOCATION MAP

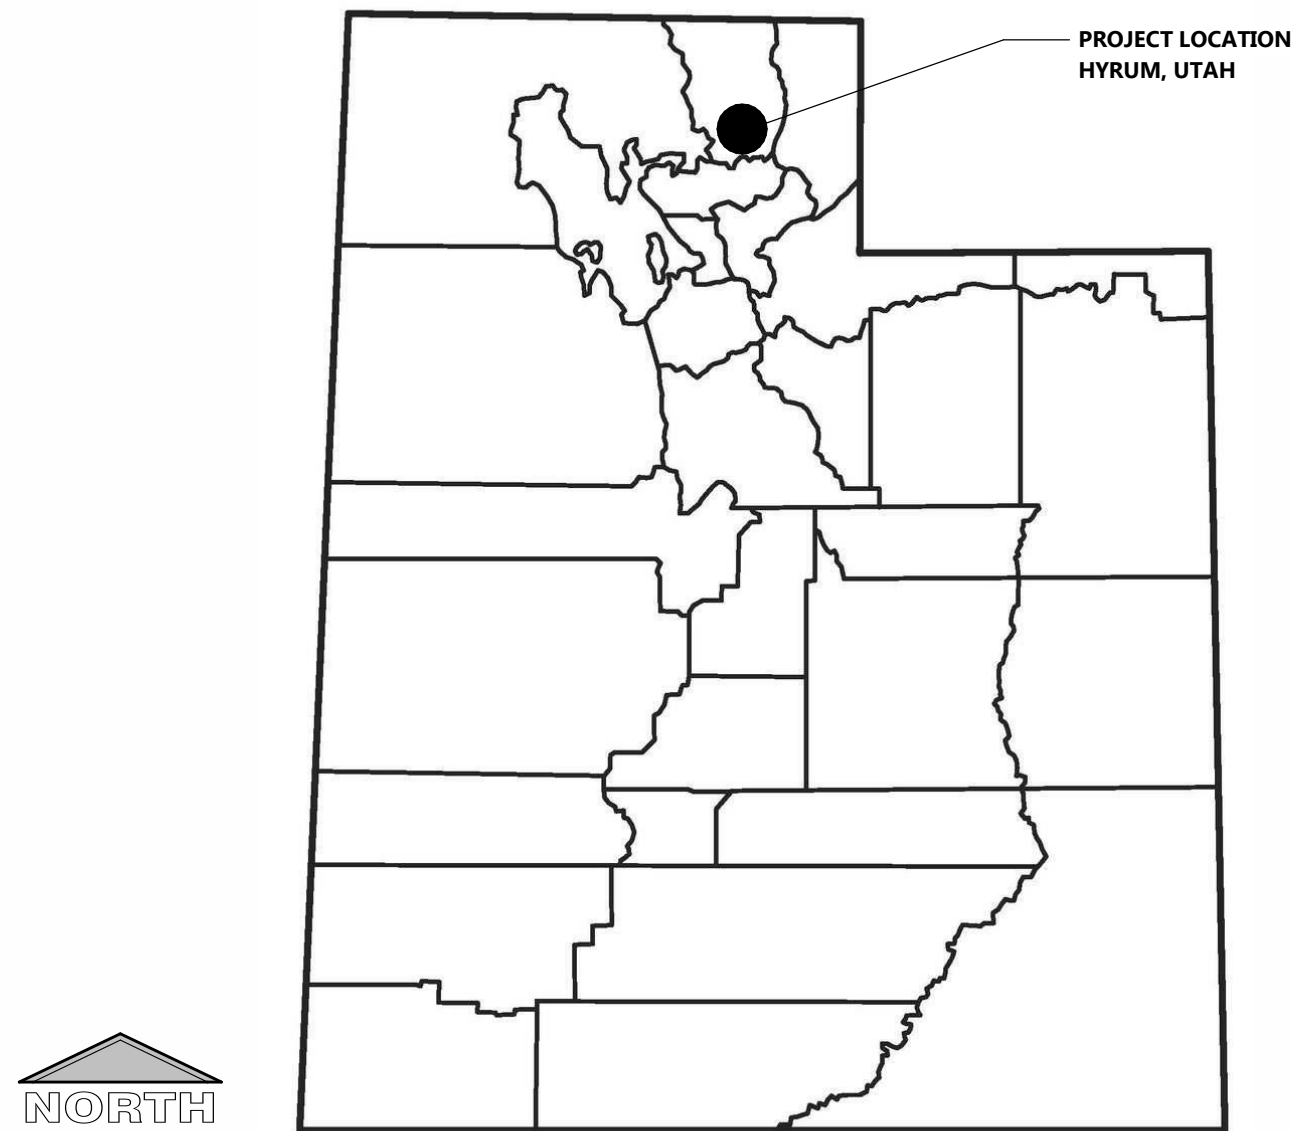

SYMBOLS LEGEND

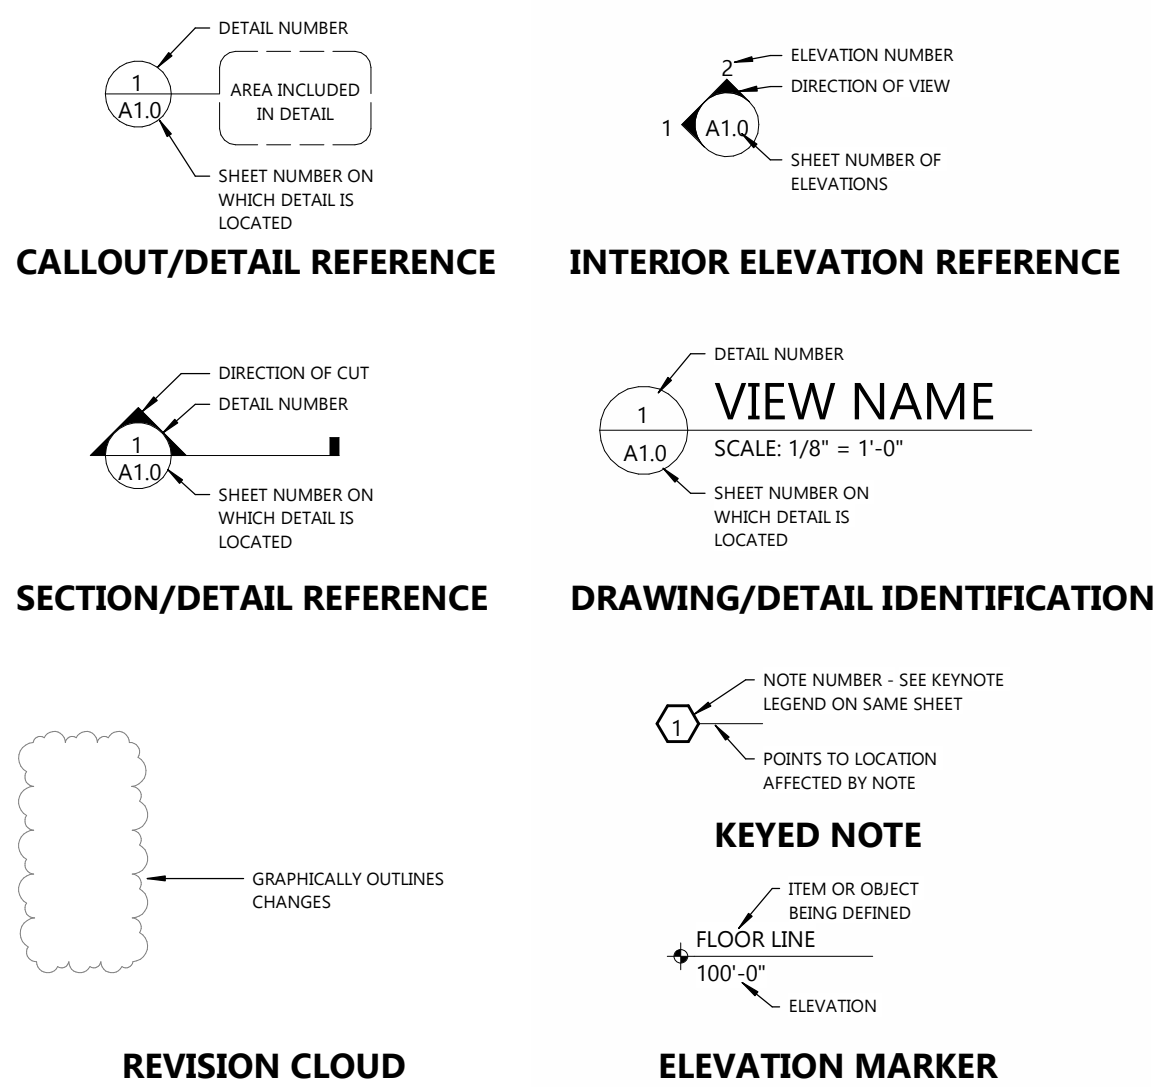

SHEET INDEX

SHEETS BELOW INTENDED TO BE PRINTED IN: COLOR. REFER TO DIGITAL FORMAT DRAWINGS IF PRINTED GRAYSCALE TO ENSURE SCOPE CLARITY

NUMBER	SHEET NAME / DESCRIPTION	SHEET STATUS	LATEST SHEET ISSUE	
			NUMBER	DATE
GENERAL				
T1.0	TITLE SHEET	IFB	IFB	APR. 17, 2026
T1.1	PROJECT INFORMATION	IFB	IFB	APR. 17, 2026
T1.1L	LIFE SAFETY PLAN	IFB	IFB	APR. 17, 2026
T1.1PH	PROJECT PHASING PLAN	IFB	IFB	APR. 17, 2026
T2.0	SPECIAL INSPECTION REQUIREMENTS	IFB	IFB	APR. 17, 2026
CIVIL				
CIVIL	SEE EXCEL JOB# 250231400			
ARCHITECTURAL				
AD1.1	FIRST FLOOR DEMOLITION PLAN - AREA OF WORK	IFB	IFB	APR. 17, 2026
AD1.3	ROOF DEMOLITION PLAN - AREA OF WORK	IFB	IFB	APR. 17, 2026
A1.0	OVERALL FIRST FLOOR PLAN	IFB	IFB	APR. 17, 2026
A1.1	FIRST FLOOR PLAN - AREA OF WORK	IFB	IFB	APR. 17, 2026
A1.3	ROOF PLAN	IFB	IFB	APR. 17, 2026
A2.0	EXTERIOR ELEVATIONS	IFB	IFB	APR. 17, 2026
A3.0	BUILDING SECTIONS	IFB	IFB	APR. 17, 2026
A4.0	WALL SECTIONS & DETAILS	IFB	IFB	APR. 17, 2026
A4.1	DETAILS	IFB	IFB	APR. 17, 2026
A4.2	STAIR SECTIONS & DETAILS	IFB	IFB	APR. 17, 2026
A6.0	SCHEDULES	IFB	IFB	APR. 17, 2026
STRUCTURAL				
S0.1	SPECIFICATIONS	IFB	IFB	APR. 17, 2026
S0.2	DESIGN CRITERIA	IFB	IFB	APR. 17, 2026
S1.1	FOUNDATION PLAN	IFB	IFB	APR. 17, 2026
S1.1S	CONCRETE FLOOR SLAB PLAN	IFB	IFB	APR. 17, 2026
S2.0	FOUNDATION SCHEDULES	IFB	IFB	APR. 17, 2026
S2.1	PEMB ANCHOR BOLT SETTING PLAN	IFB	IFB	APR. 17, 2026
S2.2	SLAB ON GRADE SCHEDULES AND DETAILS	IFB	IFB	APR. 17, 2026
S2.3	FOUNDATION DETAILS	IFB	IFB	APR. 17, 2026
FIRE PROTECTION				
FP0.1	LEGEND AND SPECIFICATIONS	IFB	IFB	APR. 17, 2026
FP1.1	FIRST FLOOR PLAN - AREA OF WORK	IFB	IFB	APR. 17, 2026
HVAC				
H0.1	LEGEND AND SPECIFICATIONS	IFB	IFB	APR. 17, 2026
H0.1.1	FIRST FLOOR DEMOLITION PLAN	IFB	IFB	APR. 17, 2026
H1.1	FIRST FLOOR PLAN	IFB	IFB	APR. 17, 2026
H1.3	ROOF PLAN	IFB	IFB	APR. 17, 2026
H3.0	DETAILS	IFB	IFB	APR. 17, 2026
H4.0	SCHEDULES	IFB	IFB	APR. 17, 2026
ELECTRICAL				
E0.1	LEGEND AND SPECIFICATIONS	IFB	IFB	APR. 17, 2026
E0.2	SPECIFICATIONS	IFB	IFB	APR. 17, 2026
E1.1L	FIRST FLOOR PLAN - AREA 'A' - LIGHTING	IFB	IFB	APR. 17, 2026
E1.1P	FIRST FLOOR PLAN - AREA 'A' - POWER	IFB	IFB	APR. 17, 2026
E1.1S	FIRST FLOOR PLAN - AREA 'A' - SYSTEMS	IFB	IFB	APR. 17, 2026
E1.3	ROOF PLAN	IFB	IFB	APR. 17, 2026
E4.0	PANEL SCHEDULES	IFB	IFB	APR. 17, 2026
E6.0	LIGHT FIXTURE SCHEDULE	IFB	IFB	APR. 17, 2026

PROJECT INFORMATION

STORAGE WAREHOUSE EXPANSION FOR:
WEST POINT DAIRY PRODUCTS
570 NORTH 500 WEST • HYRUM, UT 84319

PROFESSIONAL SEAL

SHEET DATES

ISSUED FOR BUDGET
IFB APR. 17, 2026

JOB NUMBER

250429500

SHEET NUMBER

T1.0

PROJECT INFORMATION

APPLICABLE BUILDING CODES

2021 INTERNATIONAL BUILDING CODE
2021 INTERNATIONAL EXISTING BUILDING CODE - LEVEL 2
2021 INTERNATIONAL ENERGY CONSERVATION CODE
2021 INTERNATIONAL MECHANICAL CODE
2021 INTERNATIONAL FUEL GAS CODE
2021 INTERNATIONAL FIRE CODE
2020 NATIONAL ELECTRICAL CODE
2021 INTERNATIONAL PLUMBING CODE
2017 ICC/ANSI A117.1 ACCESSIBILITY CODE

BUILDING SCOPE AND SPECIAL NOTES

THE PURPOSE OF THIS BUILDING ADDITION IS TO EXPAND STORAGE CAPABILITIES AT THIS FACILITY.

OCCUPANCY CLASSIFICATION AND USE

THE BUILDING ADDITION IS CLASSIFIED AS STORAGE GROUP S-1 - 2021 IBC SECTION 306.2 - STORAGE MODERATE HAZARD

OCCUPANCY CLASSIFICATIONS WITHIN BUILDING INCLUDE:
BUSINESS GROUP B 2021 IBC SECTION 304.1 - BUSINESS
FACTORY GROUP F-1 2021 IBC SECTION 306.2 - FACTORY INDUSTRIAL MODERATE HAZARD
STORAGE GROUP S-1 2021 IBC SECTION 311.2 - MODERATE HAZARD STORAGE
HIGH HAZARD GROUP H 2021 IBC SECTION 307 - HIGH HAZARD

2021 IBC SECTION 508
• NON SEPARATED USES w/ MIXED OCCUPANCY
• BUILDING IS DESIGNED FOR F-1 OCCUPANCY (MOST RESTRICTIVE)

2021 IBC SECTION 508.2
• ACCESSORY OCCUPANCY CLASSIFICATIONS WITHIN BUILDING INCLUDE HIGH-HAZARD GROUPS H-3 & H-4

2021 IBC SECTIONS 307.1 & 508.4
• THE HIGH-HAZARD GROUPS H-3 & H-4 ARE SEPARATED FROM THE REMAINDER OF THE BUILDING WITH 2-HOUR FIRE BARRIERS.

CONSTRUCTION CLASSIFICATION

2021 IBC SECTION 602.2 TYPE II(B) CONSTRUCTION
ENTIRE BUILDING IS FULLY EQUIPPED w/ AN AUTOMATIC SPRINKLER SYSTEM PER N.F.P.A.

OCCUPANCY SEPARATION

2021 IBC SECTIONS 307.1 & 508.4
• THE HIGH-HAZARD GROUPS H-3 & H-4 ARE SEPARATED FROM THE REMAINDER OF THE BUILDING WITH A 2-HOUR FIRE BARRIER.

FIRE PROTECTION AND LIFE SAFETY SYSTEMS

PORTABLE FIRE EXTINGUISHERS
2021 IBC SECTION 906
• PORTABLE FIRE EXTINGUISHERS PROVIDED IN OCCUPANCIES AND LOCATIONS AS REQUIRED - SEE CODE REVIEW FLOOR PLAN

BUILDING SIZE

EXIST. FIRST LEVEL FLOOR AREA 128,669 S.F.
EXIST. SECOND LEVEL FLOOR AREA 24,495 S.F.
EXIST. BUILDING AREA 153,164 S.F.
PROPOSED FIRST LEVEL FLOOR AREA 11,520 S.F.
PROPOSED SECOND LEVEL FLOOR AREA 0 S.F.
PROPOSED BUILDING AREA 164,684 S.F.
TOTAL FIRST LEVEL FLOOR AREA 139,909 S.F.
TOTAL SECOND LEVEL FLOOR AREA 24,495 S.F.
TOTAL BUILDING AREA 164,684 S.F.

GENERAL BUILDING HEIGHTS AND AREAS

GENERAL HEIGHT AND AREA DETERMINED BASED ON TYPE OF CONSTRUCTION, OCCUPANCY CLASSIFICATION, AND THE PRESENCE OF A AUTOMATIC SPRINKLER SYSTEM.

ALLOWABLE BUILDING HEIGHT IN FEET:

2021 IBC TABLE 504.3 (75) MAX HEIGHT - SPRINKLERED

ALLOWABLE NUMBER OF STORIES ABOVE GRADE PLANE:

2021 IBC TABLE 504.4 (3) STORIES - SPRINKLERED (BASED ON THE MOST RESTRICTIVE OCCUPANCY 'F1')

ALLOWABLE AREA FACTOR IN SQUARE FEET:

2021 IBC SECTION 507.5 THE AREA OF A GROUP B, F, M, OR S BUILDING NO MORE THAN TWO STORIES ABOVE GRADE PLANE SHALL NOT BE LIMITED WHERE THE BUILDING IS EQUIPPED THROUGHOUT WITH AN AUTOMATIC SPRINKLER SYSTEM IN ACCORDANCE WITH SECTION 903.3.1.1 AND IS SURROUNDED AND ADJOINED BY PUBLIC WAYS OR YARDS NOT LESS THAN 60 FEET IN WIDTH.

PROJECT HEIGHT & AREA:

• PROVIDED BUILDING HEIGHT IN FEET = 3'
• PROVIDED STORIES ABOVE GRADE PLANE = (1)
• PROVIDED BUILDING AREA IN SQUARE FEET = 20,085

FIRE AND SMOKE PROTECTION FEATURES

FIRE WALLS:

2021 IBC SECTION 706
• NO NEW FIREWALLS

FIRE BARRIERS:

2021 IBC SECTION 707
• SEE PLAN FOR LOCATION OF ELECTRICAL ROOMS, CHEM STORAGE ROOMS, ETC. REQUIRING SEPARATION BY FIRE BARRIERS IN ACCORDANCE WITH SECTION 707 AND TABLE 508.4

FIRE PARTITIONS:

2021 IBC SECTION 708

PENETRATIONS:

2021 IBC SECTION 714
• ALL PENETRATION OF HORIZONTAL AND WALL ASSEMBLIES SHALL COMPLY WITH THIS SECTION

OPENING FIRE PROTECTION ASSEMBLY RATINGS AND MARKINGS:

2021 IBC SECTION 716
• ALL OPENINGS COMPLY WITH THIS SECTION AND NFPA-80
• ALL OPENINGS COMPLY WITH TABLE 716.1 FOR OPENING FIRE PROTECTION ASSEMBLIES, RATINGS, AND MARKINGS - SEE DOOR SCHEDULE AND FIRE BARRIERS AS SHOWN ON PLAN

FIRE DETECTION IS REQUIRED:

• BUILDING ACCESS IS REQUIRED EVERY 125'-0" (2021 IFC - 3206.7.5)
• MAXIMUM STORAGE HEIGHT OF PRODUCT IS 40'-0"
• MAXIMUM PILE DIMENSION IS LIMITED TO 120'-0"
• MAXIMUM PILE VOLUME IS LIMITED TO 400,000 C.F.
• IFC 506.1 KEY BOX AT APPROVED LOCATIONS
• SMOKE AND HEAT REMOVAL IS NOT REQUIRED PER 3206.2 (EXCEPTION I)
SMOKE & HEAT REMOVAL NOT REQUIRED WHERE STORAGE AREAS ARE PROTECTED BY EITHER EARLY SUPPRESSION FAST RESPONSE (ESFR) SPRINKLER SYSTEMS OR CONTROL MODE SPECIAL APPLICATION SPRINKLERS WITH A RESPONSE TIME INDEX OF 50 (METERS-SECONDS) OR LESS THAT ARE LISTED TO CONTROL A FIRE IN THE STORED COMMODITIES WITH 12 OR FEWER SPRINKLERS, INSTALLED IN ACCORDANCE WITH NFPA-13

FIRE DEPARTMENT ACCESS DOORS ARE NOT REQUIRED IN AN EXTERIOR WALL THAT DOES NOT FACE A FIRE APPARATUS ACCESS ROAD PROVIDED THAT ALL OF THE FOLLOWING CONDITIONS OCCUR:
1. THE OPPOSITE EXTERIOR WALL FACES A FIRE APPARATUS ACCESS ROAD.
2. THE OPPOSITE EXTERIOR WALL IS PROVIDED WITH FIRE DEPARTMENT ACCESS DOORS.
3. THE ENTIRE INTERIOR SURFACE OF THE EXTERIOR WALL IS LESS THAN 150 FEET AWAY FROM A FIRE DEPARTMENT ACCESS DOOR.
4. THE BUILDING IS EQUIPPED THROUGHOUT WITH AN AUTOMATIC SPRINKLER SYSTEM IN ACCORDANCE WITH SECTION 903.3.1.1.

OCCUPANT LOADS

OCCUPANT LOADS BASED ON 2021 IBC TABLE 1004.5 FOR NEW & EXISTING BUILDING.

	ROOM OR SPACE DESIGNATION	CLASSIFICATION OF OCCUPANCY FOR USE	TABULAR DENSITY (SF/PERSON)	FLOOR AREA (S.F.)	CALCULATED OCCUPANT LOAD	TOTAL ACTUAL OCCUPANT LOAD	NOTES
EXISTING BUILDING	PRODUCTION	F-1 (FACTORY)	100 GROSS	49,699	497	247	THIS IS BASED ON THREE SHIFTS PER DAY 7 DAYS PER WEEK. AS A RESULT, ACTUAL OCCUPANCY AT ANY ONE TIME IS HALF OF THIS VALUE OR 100 OCCUPANTS AT ONE TIME.
	BUSINESS	B (ACCESSORY BUSINESS USE)	150 GROSS	7,797	52		
	STORAGE	S-1 (STORAGE)	500 GROSS	23,739	47		
EXIST. MILK PLANT	OCCUPIED INDUSTRIAL AREA	F-1 (INDUSTRIAL)	100 GROSS	7,809	23 *	23 *	THIS IS BASED ON THREE SHIFTS PER DAY 7 DAYS PER WEEK. AS A RESULT, ACTUAL OCCUPANCY AT ANY ONE TIME IS HALF OF THIS VALUE OR 12 OCCUPANTS AT ONE TIME.
	PROCESS EQUIPMENT ROOMS	ACCESSORY STORAGE AREA	300 GROSS	51,316			
	WAREHOUSE	S-1 (STORAGE)	500 GROSS	24,703			
NEW ADDITION	BUSINESS	B (ACCESSORY TO F-1)	150 GROSS	686	24	0	THIS IS BASED ON THREE SHIFTS PER DAY 7 DAYS PER WEEK. AS A RESULT, ACTUAL OCCUPANCY AT ANY ONE TIME IS HALF OF THIS VALUE OR 24 OCCUPANTS AT ONE TIME.
	WAREHOUSE	S-1 (STORAGE)	500 GROSS	11,520			
	TOTAL OCCUPANCY				643	270	BASED ON COMMENTS ABOVE AT ANY ONE TIME IS ACTUALLY 136 OCCUPANTS

* BUILDING OCCUPANT LOAD AS APPROVED BY AHJ - 2020 PROJECT

SANITARY FIXTURES

PLUMBING FIXTURE FACTORS BASED ON 2021 IBC TABLE 2902.1

OCCUPANCY			WATER CLOSETS			LAVATORIES			DRINK FOUNTAINS		
TYPE	EXIST. CAPACITY	NEW CAPACITY	FACTORS	# M. FIX.	# F. FIX.	FACTORS	# M. FIX.	# F. FIX.	FACTORS	# FIX.	
B GROUP (OFFICE)	39 PERSONS	0	1/25 (FIRST 50) 1/50 (AFTER)	.8	.8	1/40 (FIRST 80) 1/80 (AFTER)	.5	.5	1/100	.4	
S GROUP (STORAGE)	4 PERSONS	0	1/100	.02	.02	1/100	.02	.02	1/1000	.004	
F GROUP (FACTORY)	180 PERSONS	227 PERSONS	1/100	1.14	1.14	1/100	1.14	1.14	1/400	.57	
TOTAL		270 PERSONS		1.96	1.96		1.66	1.66		.87	
PROVIDED FIXTURES				5 (WC) 2 (URINAL)	1.96		5	7		6 (EXIST.) BOTTLED WATER DISPENSERS	

2021 IBC SECTION 2902.3.3
• THE PATH OF TRAVEL TO TOILET FACILITIES DOES NOT EXCEED 500'

HIGH PILE STORAGE

2021 INTERNATIONAL FIRE CODE
• IFC SECTION 102.6
• IFC SECTION 105.5.24
• IFC CHAPTERS 2 TO 4
• IFC SECTIONS 501 TO 502 AND 504 TO 510
• IFC SECTIONS 601 TO 605 AND 607 TO 609
• IFC CHAPTERS 7 AND 8
• IFC SECTIONS 901.1 TO 901.4.2, 901.4.4 TO 909.18.9, AND 909.20 TO 913
• IFC CHAPTERS 10 AND 12 TO 21
• IFC SECTION 2211.7
• IFC CHAPTERS 23 TO 29, 31 TO 33, 36, 37, AND 39 TO 47

FIRE APPARATUS ACCESS LANES:

THE WAREHOUSE PORTION OF THE ADDITION IS DESIGNED FOR AND INTENDED TO BE USED FOR HIGH PILE COMBUSTIBLE STORAGE OF FROZEN AND REFRIGERATED FOODS PACKAGED IN COMBUSTIBLE CONTAINERS

FIRE APPARATUS ACCESS ROADS & ACCESS:

ACCESS ROADS MUST EXTEND TO WITHIN 150 FEET OF ALL FIRE FIGHTING ACCESS DOORS

INTERNATIONAL FIRE CODE:

FIRE FIGHTING ACCESS DOORS ARE TO BE PLACED IN THE EXTERIOR WALLS OF THE STORAGE AREA AND SPACED A MAX. OF 100'-0" O.C.

REQUIRED SIGNAGE:

ACCESSIBILITY SIGNAGE IS TO BE DESIGNED AND INSTALLED AS PER ANSI A117.1, 2003
• SIGNAGE FOR DIRECTION OF ACCESSIBLE EXIT DOORS
• ELECTRICAL ROOM AND CHEMICAL ROOM SIGNAGE REQUIREMENTS PER SECTION 605.3.1 OF THE FIRE CODE

MEANS OF EGRESS

2021 IBC TABLE 1017.2
• 250 FT. EXIT ACCESS TRAVEL DISTANCE (SPRINKLERED)

STAIRS:

2021 IBC SECTION 1005.3.1 (EXCEPTION 4)
• STAIRWAY EGRESS WIDTH PER OCCUPANT SERVED = 2" (SPRINKLERED)
• (199) TOTAL OCCUPANTS x 0.2" = 39.8" EGRESS WIDTH REQUIRED
• PROVIDED STAIRWAY EGRESS WIDTH = 184" = 16" STAIRS OF VARYING WIDTH
• STAIR WIDTH CALCULATION ACCOUNTS FOR EACH AREA BEING EXITED BY STAIR
2021 IBC SECTION 1011.2
• NOTE THAT MINIMUM STAIR WIDTH IS 44" - THEREFORE PROJECT IS IN EXCESS OF CALCULATION
• SECTION 1011.2 EXCEPTION 1 ALLOWS FOR 36" MINIMUM STAIR WIDTH WHERE LESS THAN 50 OCCUPANTS WILL USE A GIVEN STAIR.

OTHER EGRESS COMPONENTS:

2021 IBC SECTION 1005.3.2 (EXCEPTION 4)
• EGRESS WIDTH PER OCCUPANT SERVED = 0.15" (SPRINKLERED)
• (329) TOTAL CALCULATED OCCUPANTS x 0.15" = 49.35" EGRESS WIDTH REQUIRED
• PROVIDED MINIMUM EGRESS WIDTH = 34" CLEAR AT EACH 36" DOOR
• PROVIDED CUMULATIVE EGRESS WIDTH = 170" = (5) 36" WIDE DOORS
• EGRESS WIDTH CALCULATION ACCOUNTS FOR NEW & EXISTING AREA DISCHARGING THROUGH THE NEW CONSTRUCTION AREAS.

NUMBER OF DOORS AND EXIT ACCESS DOORWAYS:

2021 IBC TABLE 1006.2.1
• SPACES WITH (1) EXIT OR EXIT ACCESS DOOR
• CALCULATED OCCUPANT LOAD IS LESS THAN 49
• MAXIMUM COMMON PATH OF EGRESS TRAVEL DISTANCE IS LESS THAN 100'

2021 IBC SECTION 1006.3.1

• MINIMUM NUMBER OF EXITS OR ACCESS TO EXITS PER STORY
• UPPER FLOORS ARE UNOCCUPIED EQUIPMENT ACCESS PLATFORMS. IN THE EVENT PERSONS ARE ON THE PLATFORM, THE EXISTING RATED STAIR TOWER IS AVAILABLE FOR EXITING.

EXIT SIGNS:

2021 IBC SECTION 1013
• EXITS AND EXIT ACCESS DOORS MARKED BY APPROVED EXIT SIGNAGE
• EXIT SIGN PLACEMENT SHALL BE SUCH THAT ANY POINT IN AN EXIT ACCESS CORRIDOR OR EXIT PASSAGEWAY IS WITHIN 100' (SEE CODE REVIEW FLOOR PLAN FOR LOCATIONS)

ACCESSIBLE MEANS OF EGRESS:

2021 IBC SECTION 1009
• ALL MEANS OF EGRESS ARE AT GRADE.

COMMON PATH OF EGRESS TRAVEL:

2021 IBC SECTION 1006.2.1
• COMMON PATH OF EGRESS TRAVEL IS 100' BASED ON 'F' OCCUPANCY - SPRINKLERED.

ELEVATORS:

• AN EXISTING ELEVATOR IS PROVIDED IN THE DRYER AREA OF THIS FACILITY.

EXTERIOR WALL OPENINGS

2021 IBC TABLE 705.8
• BUILDING PERMITTED TO HAVE UNLIMITED UNPROTECTED OPENINGS DUE TO FIRE SEPARATION DISTANCE TO PROPERTY LINE IS GREATER THAN 30 FT.

HIGH PILE STORAGE REQUIREMENTS (IFC 2021)

THE WAREHOUSE PORTION OF THE ADDITION IS DESIGNED FOR AND INTENDED TO BE USED FOR HIGH PILE COMBUSTIBLE STORAGE OF REFRIGERATED FOODS PACKAGED IN CLASS III COMMODITIES PER SECTION 3203.8

THE BUILDING IS TO MEET THE HIGH PILE STORAGE REQUIREMENTS OF 2015-IFC CHAPTER 32 2021 IFC - TABLE 3206.2 (12,001 - 500,000 S.F. STORAGE AREA)

2021 INTERNATIONAL FIRE CODE (IFC)
• THE BUILDING IS FULLY SPRINKLERED
• FIRE DETECTION IS REQUIRED
• BUILDING ACCESS IS REQUIRED EVERY 125'-0" (2021 IFC - 3206.7.5)
• MAXIMUM STORAGE HEIGHT OF PRODUCT IS 40'-0"
• MAXIMUM PILE DIMENSION IS LIMITED TO 120'-0"
• MAXIMUM PILE VOLUME IS LIMITED TO 400,000 C.F.
• IFC 506.1 KEY BOX AT APPROVED LOCATIONS
• SMOKE AND HEAT REMOVAL IS NOT REQUIRED PER 3206.2 (EXCEPTION I)

SMOKE & HEAT REMOVAL NOT REQUIRED WHERE STORAGE AREAS ARE PROTECTED BY EITHER EARLY SUPPRESSION FAST RESPONSE (ESFR) SPRINKLER SYSTEMS OR CONTROL MODE SPECIAL APPLICATION SPRINKLERS WITH A RESPONSE TIME INDEX OF 50 (METERS-SECONDS) OR LESS THAT ARE LISTED TO CONTROL A FIRE IN THE STORED COMMODITIES WITH 12 OR FEWER SPRINKLERS, INSTALLED IN ACCORDANCE WITH NFPA-13

FIRE DEPARTMENT ACCESS DOORS ARE NOT REQUIRED IN AN EXTERIOR WALL THAT DOES NOT FACE A FIRE APPARATUS ACCESS ROAD PROVIDED THAT ALL OF THE FOLLOWING CONDITIONS OCCUR:
1. THE OPPOSITE EXTERIOR WALL FACES A FIRE APPARATUS ACCESS ROAD.
2. THE OPPOSITE EXTERIOR WALL IS PROVIDED WITH FIRE DEPARTMENT ACCESS DOORS.
3. THE ENTIRE INTERIOR SURFACE OF THE EXTERIOR WALL IS LESS THAN 150 FEET AWAY FROM A FIRE DEPARTMENT ACCESS DOOR.
4. THE BUILDING IS EQUIPPED THROUGHOUT WITH AN AUTOMATIC SPRINKLER SYSTEM IN ACCORDANCE WITH SECTION 903.3.1.1.

GENERAL PROJECT INFORMATION



Always a Better Plan

100 Camelot Drive
Fond du Lac, WI 54935
920-926-9800
excelengineer.com

PROJECT INFORMATION

STORAGE WAREHOUSE EXPANSION FOR:
WEST POINT DAIRY PRODUCTS
570 NORTH 500 WEST • HYRUM, UT 84319

PROFESSIONAL SEAL

SHEET DATES

ISSUED FOR BUDGET

IFB APR. 17, 2026

SHEET NUMBER

T1.1


NOT FOR CONSTRUCTION

JOB NUMBER

250429500

SHEET NUMBER

T1.1

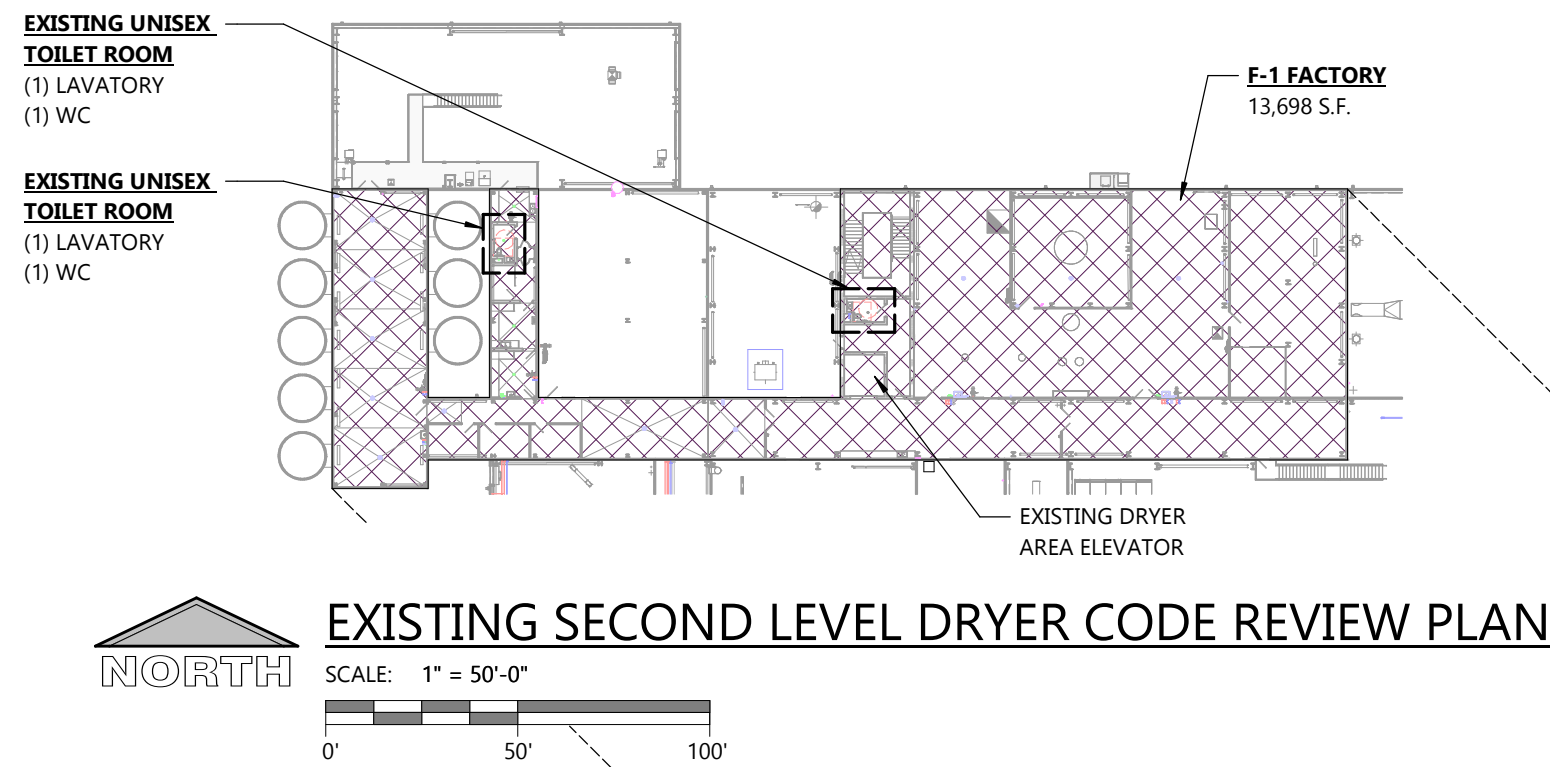

TOTAL BUILDING AREA
EXISTING BUILDING = 143,447 S.F.
NEW CREAM RECEIVING BUILDING EXPANSION = 22,847 S.F.
NEW CREAM RECEIVING BUILDING EXPANSION = 165 S.F.
NEW STORAGE WAREHOUSE = 11,520 S.F.
177,979 S.F.

SPRINKLER MUST BE ADDED TO EXISTING BUILDING WHERE CYAN

EXISTING BUILDING
PRODUCTION, STORAGE, WELFARE, MILK RECEIVING, DRYER, & EVAPORATOR
FACTORY F-1 (GRAY)
STORAGE S-1 (DIAGONAL HATCH)
TYPE II(B) CONSTRUCTION
PARTIALLY SPRINKLERED
64,583 S.F.

EXISTING TOILET ROOMS
MEN'S
(2) LAVATORIES
(2) URINALS
(2) WC
WOMEN'S
(3) LAVATORIES
(2) WC

EXISTING UNISEX TOILET ROOM
(1) LAVATORY
(1) WC

EXIST. SECOND LEVEL CODE REVIEW PLAN

SCALE: 1" = 50'-0"
0' 50' 100'

FUTURE AS/RS EXPANSION
STORAGE S-1
TYPE II(B) CONSTRUCTION
FULLY SPRINKLERED
63,133 S.F.



CODE REVIEW PLAN

SCALE: 1" = 50'-0"
0' 50' 100'

FUTURE DOCK, MECHANICALS, WELFARE, & GARAGE
JOB# 250429500
BUSINESS B-1
STORAGE S-1
TYPE II(B) CONSTRUCTION
FULLY SPRINKLERED
47,722 S.F.

S-1 STORAGE (EXISTING)
F-1 FACTORY (EXISTING)
F-1 FACTORY (NEW)
S-1 STORAGE (NEW)

PROJECT INFORMATION

STORAGE WAREHOUSE EXPANSION FOR:
WEST POINT DAIRY PRODUCTS
570 NORTH 500 WEST • HYRUM, UT 84319

PROFESSIONAL SEAL


SHEET DATES

ISSUED FOR BUDGET	
IFB	APR. 17, 2026


JOB NUMBER
250429500

SHEET NUMBER

T1.1L

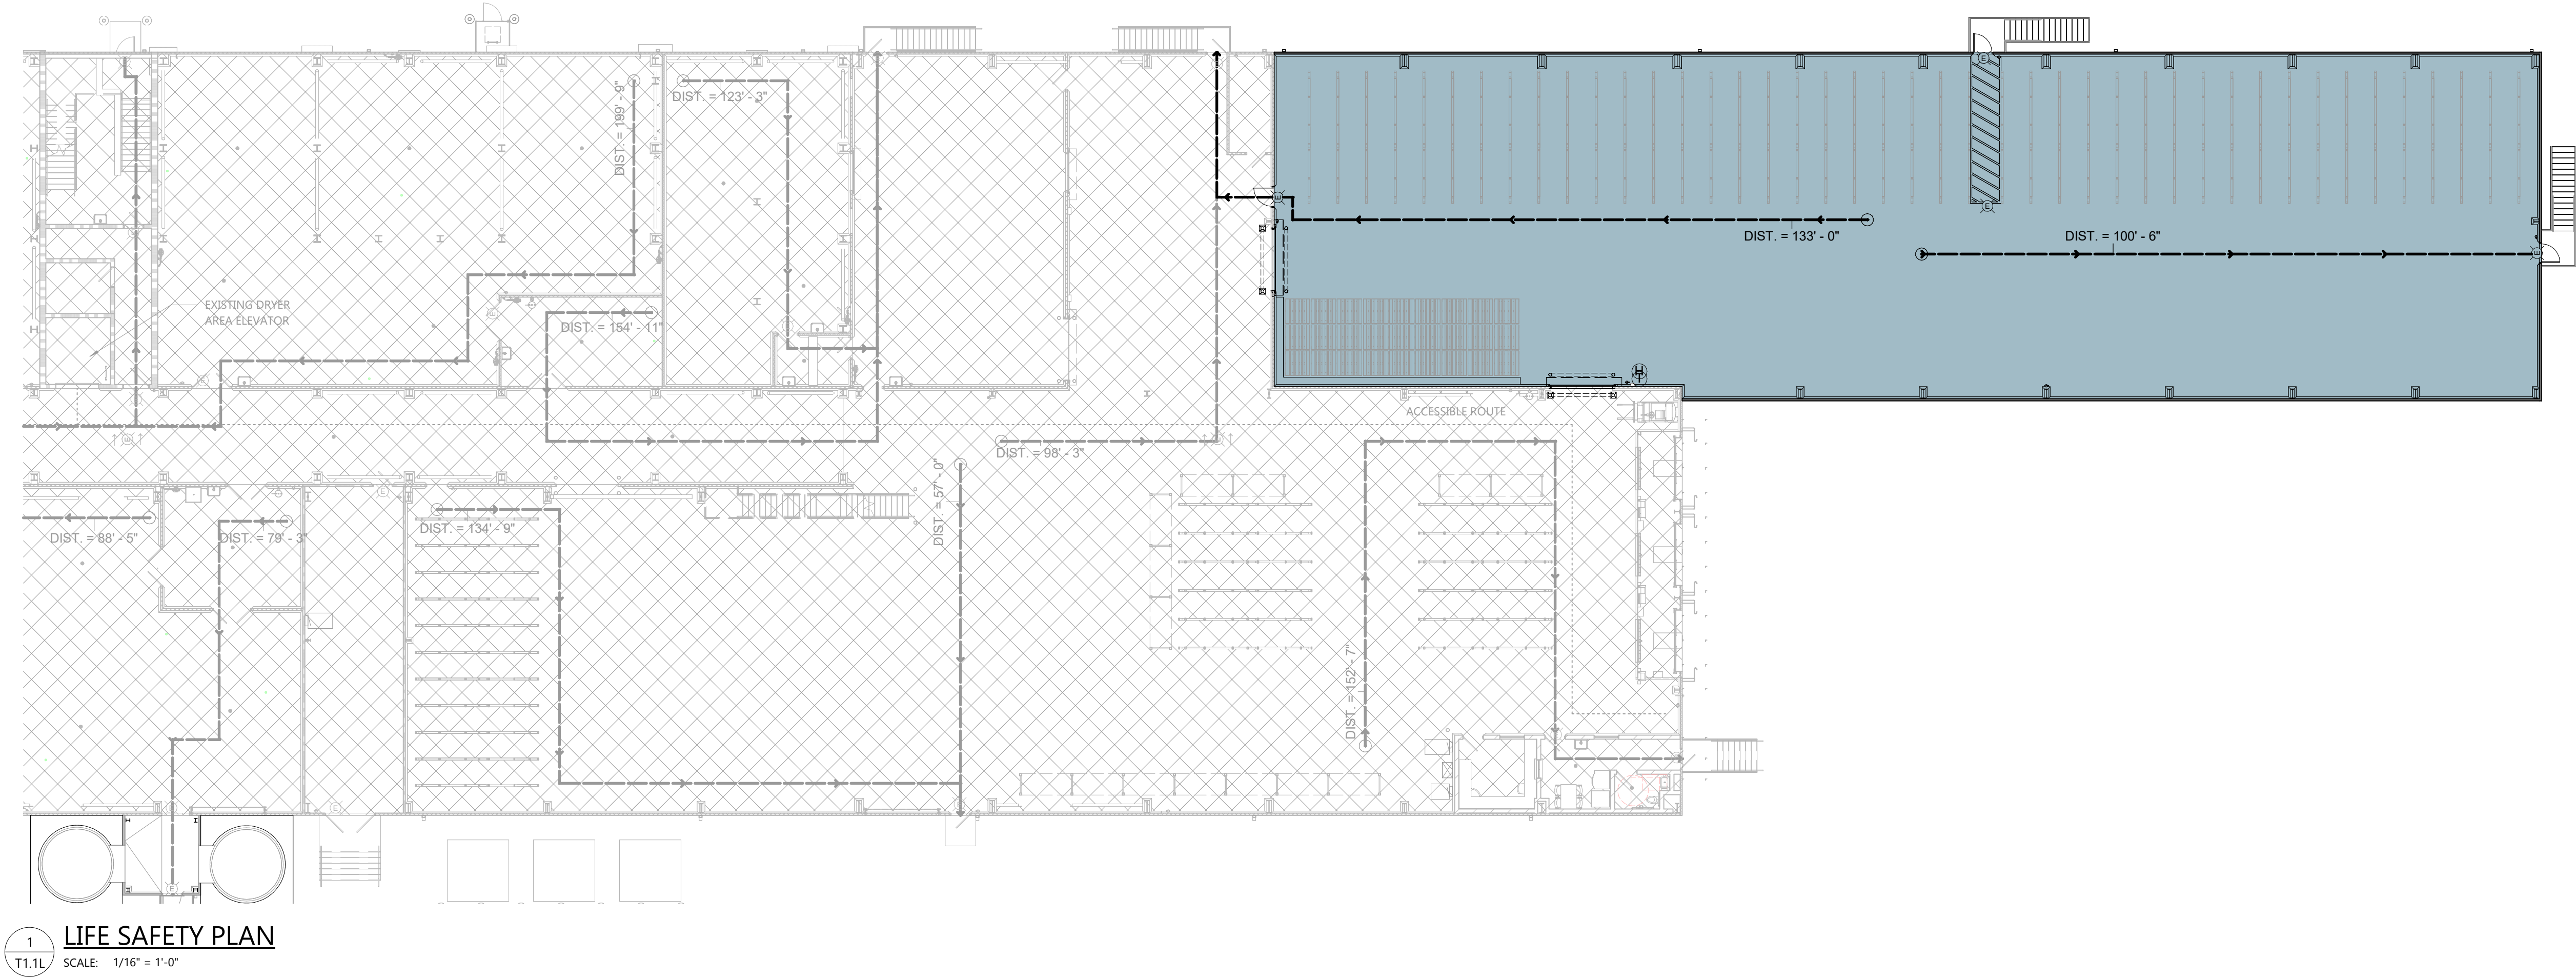

NOT FOR CONSTRUCTION

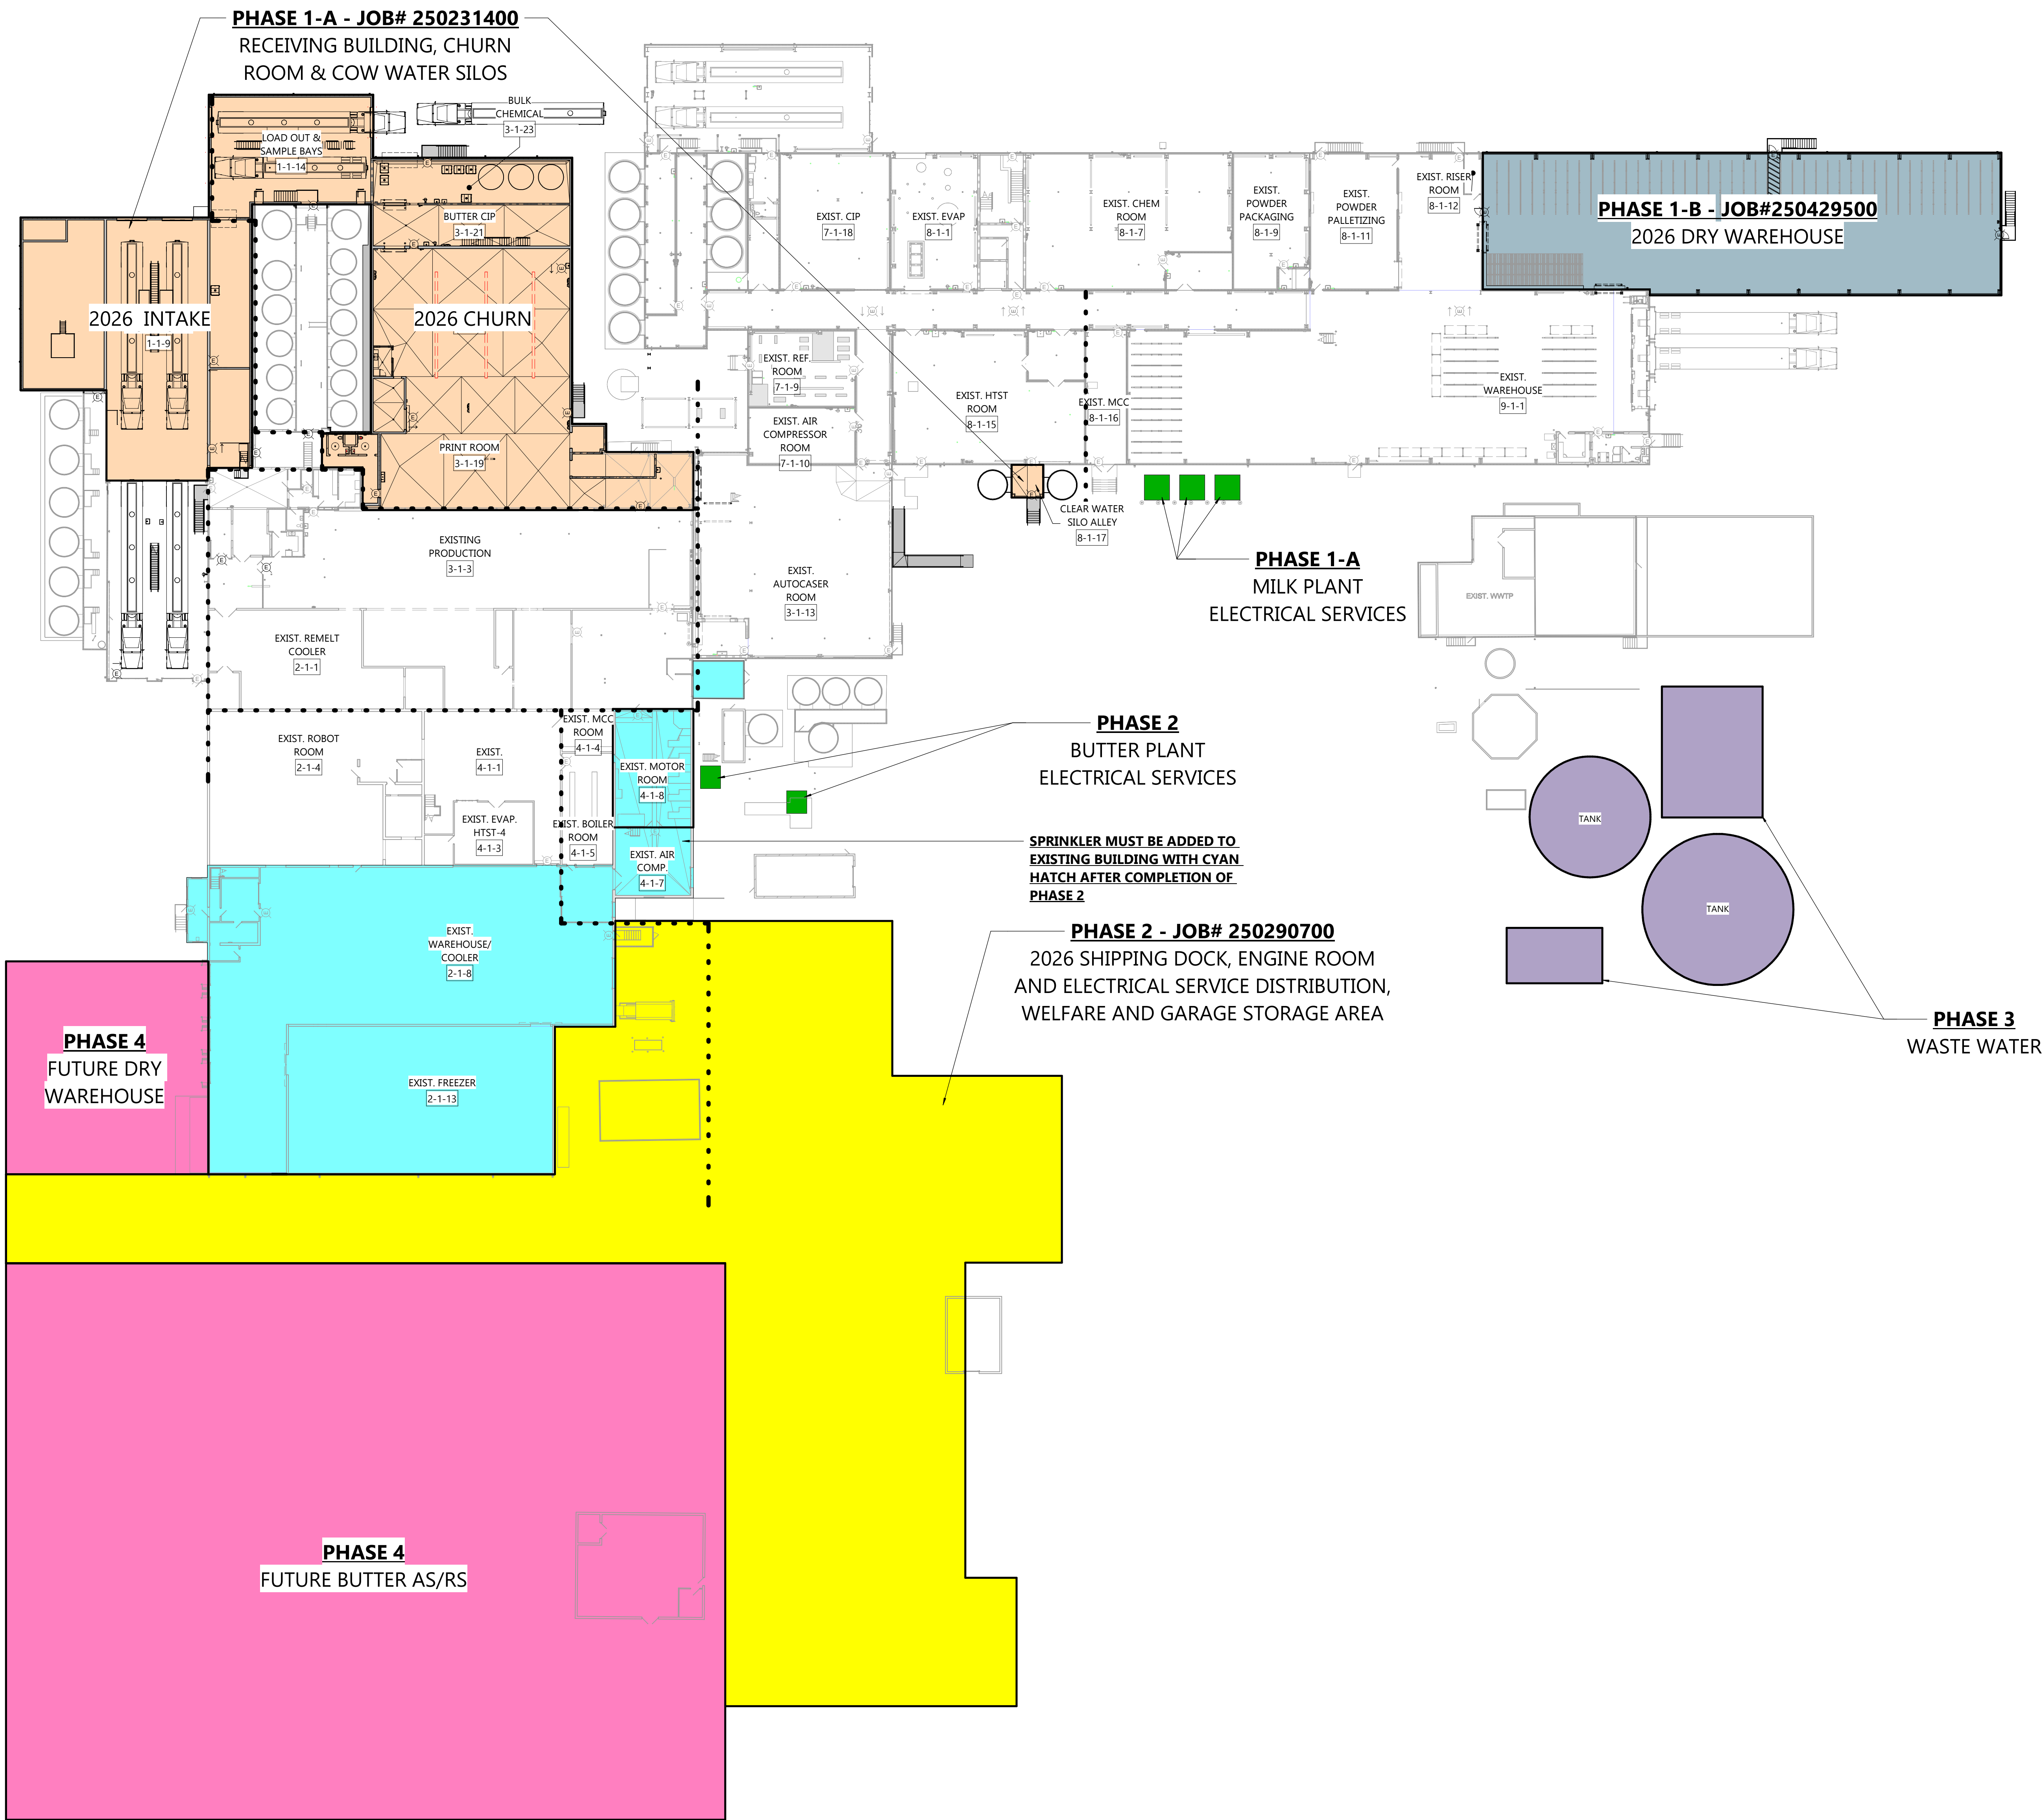

PHASING NOTES

- PHASE 1-A:** RECEIVING BUILDING AND CHURN ROOM ADDITIONS, INCLUDING COW WATER SILOS.
- PHASE 1-B:** DRY WAREHOUSE SPACE TO REPLACE SHRIMP BUILDING. PRE-ENGINEERED METAL BUILDING WITH IMP WALLS AND TRADITIONAL RUBBER ROOF-MEMBRANE SYSTEM. VERY LIMITED ELECTRICAL AND HVAC SCOPES. NO WATER OR PLUMBING SCOPE INSIDE THIS AREA.
- FIRE PROTECTION:**
- WILL NEED TO WORK WITH LOCAL AUTHORITY TO ALLOW PHASE 1 AND PHASE 1B TO BE OCCUPIED PRIOR TO COMPLETION OF PHASE 2.
 - THIS WILL LEAVE A SMALL PORTION OF THE EXISTING FACILITY UNPROTECTED AS INDICATED (IN CYAN) ON THIS SHEET.
 - PHASE 1 AND PHASE 2 ARE TO BE FIRE PROTECTED FROM THE EXISTING SYSTEM.
 - DUE TO WATER SUPPLY ISSUES WE CAN NOT ADDRESS SPACES WITHIN THE EXISTING BUILDING (IN CYAN) UNTIL PHASE 2 IS COMPLETE.
 - FIRE PROTECTION IS THE PRIMARY AREA OF CONCERN TO BE DISCUSSED WITH CACHE COUNTY AHI.
- PHASE 2:** SHIPPING DOCK, ENGINE ROOM AND ELECTRICAL SERVICE DISTRIBUTION, WELFARE AND GARAGE STORAGE AREA. THESE AREAS WILL BE A SINGLE PHASE OF CONSTRUCTION. AREA WILL INCLUDE A FIRE PUMP AND WATER RESERVOIR FOR SPRINKLER SYSTEMS OF THIS ADDITION, THE FUTURE AS/RS AND ABILITY TO BACK FEED SYSTEMS IN THE AREAS ALREADY WITH SPRINKLERS.
- SHRIMP BUILDING WILL BE REMOVED DURING THIS PHASE.
- PHASE 3:** WASTE WATER
- PHASE 4:** FUTURE PHASE - BUTTER AS/RS & DRY WAREHOUSE

EXCEL

Always a Better Plan

100 Camelot Drive
Fond du Lac, WI 54935
920-926-9800
excelengineer.com

PROJECT INFORMATION

STORAGE WAREHOUSE EXPANSION FOR:
WEST POINT DAIRY PRODUCTS
570 NORTH 500 WEST • HYRUM, UT 84319

PROFESSIONAL SEAL

NOT FOR CONSTRUCTION

SHEET DATES	
ISSUED FOR BUDGET	
IFB	APR. 17, 2026

JOB NUMBER	250429500
SHEET NUMBER	T1.1PH

SPECIAL INSPECTIONS REQUIREMENTS

IN PROGRESS - SCHEDULE OF SPECIAL INSPECTIONS SERVICES				
MATERIAL / ACTIVITY	SERVICE	APPLICABLE		
		Y/N	EXTENT	
1705.1.1 SPECIAL CASES				
SPECIAL INSPECTIONS AND TESTS SHALL BE REQUIRED FOR ANY PROPOSED WORK THAT IS, IN THE OPINION OF THE BUILDING OFFICIAL, UNUSUAL IN ITS NATURE.	AS REQ'D BY BUILDING OFFICIAL	Y	AS REQ'D BY BUILDING OFFICIAL	
1705.2.1 STRUCTURAL STEEL CONSTRUCTION				
1. FABRICATOR AND ERECTOR DOCUMENTS (VERIFY REPORTS AND CERTIFICATES AS LISTED IN AISC 360, SECTION N 3.2 FOR COMPLIANCE WITH CONSTRUCTION DOCUMENTS)	SUBMITTAL REVIEW	Y	EACH SUBMITTAL	
2. MATERIAL VERIFICATION OF STRUCTURAL STEEL	SHOP AND FIELD INSPECTION	Y	PERIODIC	
3. STRUCTURAL STEEL WELDING:				
A. INSPECTION TASKS PRIOR TO WELDING (OBSERVE, OR PERFORM FOR EACH WELDED JOINT OR MEMBER, THE QA TASKS LISTED IN AISC 360, TABLE N5.4-1)	SHOP AND FIELD INSPECTION	Y	OBSERVE OR PERFORM AS NOTED	
B. INSPECTION TASKS DURING WELDING (OBSERVE, OR PERFORM FOR EACH WELDED JOINT OR MEMBER, THE QA TASKS LISTED IN AISC 360, TABLE N5.4-2)	SHOP AND FIELD INSPECTION	Y	OBSERVE OR PERFORM AS NOTED	
C. INSPECTION TASKS AFTER WELDING (OBSERVE, OR PERFORM FOR EACH WELDED JOINT OR MEMBER, THE QA TASKS LISTED IN AISC 360, TABLE N5.4-3)	SHOP AND FIELD INSPECTION	Y	OBSERVE OR PERFORM AS NOTED	
D. NONDESTRUCTIVE TESTING (NDT) OF WELDED JOINTS:				
1) COMPLETE PENETRATION GROOVE WELDS 5/16" OR GREATER IN RISK CATEGORY III OR IV	SHOP OR FIELD ULTRASONIC TESTING - 100%	Y	PERIODIC	
2) COMPLETE PENETRATION GROOVE WELDS 5/16" OR GREATER IN RISK CATEGORY II	SHOP OR FIELD ULTRASONIC TESTING - 10% OF WELDS MINIMUM	Y	PERIODIC	
3) WELDED JOINTS SUBJECT TO FATIGUE WHEN REQUIRED BY AISC 360, APPENDIX 3, TABLE A-3.1	SHOP OR FIELD RADIOGRAPHIC OR ULTRASONIC TESTING	Y	PERIODIC	
4) FABRICATOR'S NDT REPORTS WHEN FABRICATOR PERFORMS NDT	VERIFY REPORTS	Y	EACH SUBMITTAL	
4. STRUCTURAL STEEL BOLTING:				
A. INSPECTION TASKS PRIOR TO BOLTING (OBSERVE, OR PERFORM TASKS FOR EACH BOLTED CONNECTION, IN ACCORDANCE WITH QA TASKS LISTED IN AISC 360, TABLE N5.6-1)	SHOP AND FIELD INSPECTION	Y	OBSERVE OR PERFORM AS NOTED	
B. INSPECTION TASKS DURING BOLTING (OBSERVE THE QA TASKS LISTED IN AISC 360, TABLE N5.6-2)	SHOP AND FIELD INSPECTION	Y	OBSERVE	
1) PRE-TENSIONED AND SLIP-CRITICAL JOINTS				
A) TURN-OF-NUT WITH MATCHING MARKINGS	SHOP AND FIELD INSPECTION	Y	PERIODIC	
B) DIRECT TENSION INDICATOR	SHOP AND FIELD INSPECTION	Y	PERIODIC	
C) TWIST-OFF TYPE TENSION CONTROL BOLT	SHOP AND FIELD INSPECTION	Y	PERIODIC	
D) TURN-OF-NUT WITHOUT MATCHING MARKINGS	SHOP AND FIELD INSPECTION	Y	CONTINUOUS	
E) CALIBRATED WRENCH	SHOP AND FIELD INSPECTION	Y	CONTINUOUS	
2) SNUG-TIGHT JOINTS	SHOP AND FIELD INSPECTION	Y	PERIODIC	
C. INSPECTION TASKS AFTER BOLTING (PERFORM TASKS FOR EACH BOLTED CONNECTION IN ACCORDANCE WITH QA TASKS LISTED IN AISC 360, TABLE N5.6-3)	SHOP AND FIELD INSPECTION	Y	PERFORM	
5. VISUAL INSPECTION OF EXPOSED CUT SURFACES OF GALVANIZED STRUCTURAL STEEL MAIN MEMBERS AND EXPOSED CORNERS OF THE RECTANGULAR HSS FOR CRACKS SUBSEQUENT TO GALVANIZING	SHOP OR FIELD INSPECTION	Y	PERIODIC	
6. EMBEDMENTS (VERIFY DIAMETER, GRADE, TYPE, LENGTH, EMBEDMENT. SEE 1705.3 FOR ANCHORS)	FIELD INSPECTION	Y	PERIODIC	
7. VERIFY MEMBER LOCATIONS, BRACES, STIFFENERS, AND APPLICATION OF JOINT DETAILS AT EACH CONNECTION COMPLY WITH CONSTRUCTION DOCUMENTS	FIELD INSPECTION	Y	PERIODIC	
1705.2.2 COLD-FORMED STEEL DECK				
1. MANUFACTURER DOCUMENTS (VERIFY REPORTS AND CERTIFICATES AS LISTED IN SDI QA/QC, SECTION 2.2.1 AND 2.2.2 FOR COMPLIANCE WITH CONSTRUCTION DOCUMENTS)	SUBMITTAL REVIEW	Y	EACH SUBMITTAL	
2. MATERIAL VERIFICATION OF STEEL DECK, MECHANICAL FASTENERS AND WELDING MATERIALS	SHOP AND FIELD INSPECTION	Y	PERIODIC	
3. COLD-FORMED STEEL DECK PLACEMENT:				
A. INSPECTION TASKS PRIOR TO DECK PLACEMENT (PERFORM THE QA TASKS LISTED IN SDI QA/QC, APPENDIX 1 TABLE 1.1)	SHOP AND FIELD INSPECTION	Y	PERFORM	
B. INSPECTION TASKS AFTER DECK PLACEMENT (PERFORM THE QA TASKS LISTED IN SDI QA/QC, APPENDIX 1 TABLE 1.2)	SHOP AND FIELD INSPECTION	Y	PERFORM	
4. COLD-FORMED STEEL DECK WELDING:				
A. INSPECTION TASKS PRIOR TO WELDING (OBSERVE THE QA TASKS LISTED IN SDI QA/QC, APPENDIX 1 TABLE 1.3)	SHOP AND FIELD INSPECTION	Y	OBSERVE	
B. INSPECTION TASKS DURING WELDING (OBSERVE THE QA TASKS LISTED IN SDI QA/QC, APPENDIX 1 TABLE 1.4)	SHOP AND FIELD INSPECTION	Y	OBSERVE	
C. INSPECTION TASKS AFTER WELDING (PERFORM THE QA TASKS LISTED IN SDI QA/QC, APPENDIX 1 TABLE 1.5)	SHOP AND FIELD INSPECTION	Y	PERFORM	
5. COLD-FORMED STEEL DECK MECHANICAL FASTENING:				
A. INSPECTION TASKS PRIOR TO MECHANICAL FASTENING (OBSERVE THE QA TASKS LISTED IN SDI QA/QC, APPENDIX 1 TABLE 1.6)	SHOP AND FIELD INSPECTION	Y	OBSERVE	
B. INSPECTION TASKS DURING MECHANICAL FASTENING (OBSERVE THE QA TASKS LISTED IN SDI QA/QC, APPENDIX 1 TABLE 1.7)	SHOP AND FIELD INSPECTION	Y	OBSERVE	
C. INSPECTION TASKS AFTER MECHANICAL FASTENING (PERFORM THE QA TASKS LISTED IN SDI QA/QC, APPENDIX 1 TABLE 1.8)	SHOP AND FIELD INSPECTION	Y	PERFORM	
1705.2.3 OPEN-WEB STEEL JOISTS AND JOIST GIRDERS				
1. INSTALLATION OF OPEN-WEB STEEL JOISTS AND JOIST GIRDERS.				
A. END CONNECTIONS - WELDING OR BOLTED.	PER SII C/J OR SII 100	Y	PERIODIC	
B. BRIDGING - HORIZONTAL OR DIAGONAL:				
1) STANDARD BRIDGING.	PER SII C/J OR SII 100	Y	PERIODIC	
2) BRIDGING THAT DIFFERS FROM THE SPECIFICATIONS LISTED IN SII C/J OR SII 100.		Y	PERIODIC	
1705.2.4 COLD-FORMED STEEL TRUSSES SPANNING 60 FEET OR GREATER				
NOT APPLICABLE				
1705.3 CONCRETE CONSTRUCTION				
1. INSPECT REINFORCEMENT, INCLUDING PRESTRESSING TENDONS, AND VERIFY PLACEMENT.	SHOP AND FIELD INSPECTION	Y	PERIODIC	
2. REINFORCING BAR WELDING:				
A. VERIFICATION OF WELDABILITY OF BARS OTHER THAN ASTM A706.	SHOP AND FIELD INSPECTION	N	PERIODIC	
B. INSPECTION OF SINGLE-PASS FILLET WELDS 5/16 OR LESS IN SIZE.	SHOP AND FIELD INSPECTION	N	PERIODIC	
C. INSPECTION OF ALL OTHER WELDS.	SHOP AND FIELD INSPECTION	N	CONTINUOUS	

3. INSPECTION OF ANCHORS CAST IN CONCRETE.		SHOP AND FIELD INSPECTION	Y	PERIODIC
4. INSPECTION OF ANCHORS POST-INSTALLED IN HARDENED CONCRETE MEMBERS PER RESEARCH REPORTS, OR, IF NO SPECIFIC REQUIREMENTS ARE PROVIDED, REQUIREMENTS SHALL BE PROVIDED BY THE REGISTERED DESIGN PROFESSIONAL, AND APPROVED BY THE BUILDING OFFICIAL, INCLUDING VERIFICATION OF ANCHOR TYPE, ANCHOR DIMENSIONS, HOLE DIMENSIONS, HOLE CLEANING PROCEDURES, ANCHOR SPACING, EDGE DISTANCES, CONCRETE MINIMUM THICKNESS, ANCHOR EMBEDMENT AND TIGHTENING TORQUE				PERIODIC OR AS REQUIRED BY THE RESEARCH REPORT ISSUED BY AN APPROVED SOURCE
A. ADHESIVE ANCHORS INSTALLED IN HORIZONTALLY OR UPWARDLY-INCLINED ORIENTATION THAT RESIST SUSTAINED TENSION LOADS.		FIELD INSPECTION	Y	CONTINUOUS
B. MECHANICAL AND ADHESIVE ANCHORS NOT DEFINED IN 4A.		FIELD INSPECTION	Y	PERIODIC
5. VERIFY USE OF APPROVED DESIGN MIX		SHOP AND FIELD INSPECTION	Y	PERIODIC
6. PRIOR TO CONCRETE PLACEMENT, FABRICATE SPECIMENS FOR STRENGTH TESTS, PERFORM SLUMP AND AIR CONTENT TESTS, AND DETERMINE THE TEMPERATURE OF THE CONCRETE.		SHOP AND FIELD INSPECTION	Y	CONTINUOUS
7. INSPECTION OF CONCRETE AND SHOTCRETE PLACEMENT FOR PROPER APPLICATION TECHNIQUES		SHOP AND FIELD INSPECTION	Y	CONTINUOUS
8. VERIFY MAINTENANCE OF SPECIFIED CURING TEMPERATURE AND TECHNIQUES.		SHOP AND FIELD INSPECTION	Y	PERIODIC
9. INSPECTION OF PRESTRESSED CONCRETE:				
A. APPLICATION OF PRESTRESSING FORCE		SHOP AND FIELD INSPECTION	N	CONTINUOUS
B. GROUTING OF BONDED PRESTRESSING TENDONS		SHOP AND FIELD INSPECTION	N	CONTINUOUS
10. INSPECT ERECTION OF PRECAST CONCRETE MEMBERS		FIELD INSPECTION	N	PERIODIC
11. FOR PRECAST CONCRETE DIAPHRAGM CONNECTIONS OR REINFORCEMENT AT JOINTS CLASSIFIED AS MODERATE OR HIGH DEFORMABILITY ELEMENTS (MDE OR HDE) IN STRUCTURES ASSIGNED TO SEISMIC DESIGN CATEGORY C, D, E, OR F, INSPECT SUCH CONNECTIONS AND REINFORCEMENT IN THE FIELD FOR:				
A. INSTALLATION OF THE EMBEDDED PARTS.		FIELD INSPECTION	N	CONTINUOUS
B. COMPLETION OF THE CONTINUITY OF REINFORCEMENT ACROSS JOINTS.		FIELD INSPECTION	N	CONTINUOUS
C. COMPLETION OF CONNECTIONS IN THE FIELD.		FIELD INSPECTION	N	CONTINUOUS
12. INSPECT INSTALLATION TOLERANCES OF PRECAST CONCRETE DIAPHRAGM CONNECTIONS FOR COMPLIANCE WITH ACI 550.5.		FIELD INSPECTION	N	PERIODIC
13. VERIFY IN-SITU CONCRETE STRENGTH, PRIOR TO STRESSING OF TENDONS IN POST TENSIONED CONCRETE AND PRIOR TO REMOVAL OF SHORES AND FORMS FROM BEAMS AND STRUCTURAL SLABS		REVIEW FIELD TESTING AND LABORATORY REPORTS	N	PERIODIC
14. INSPECTION OF FORMWORK FOR SHAPE, LINES, LOCATION AND DIMENSIONS		FIELD INSPECTION	Y	PERIODIC
15. CONCRETE STRENGTH TESTING AND VERIFICATION OF COMPLIANCE WITH CONSTRUCTION DOCUMENTS		FIELD TESTING AND REVIEW OF LABORATORY REPORTS	Y	PERIODIC
1705.4 MASONRY CONSTRUCTION				NOT APPLICABLE
1705.4.1 GLASS UNIT MASONRY AND MASONRY VENEER IN RISK CATEGORY IV.				NOT APPLICABLE
1705.5 WOOD CONSTRUCTION				NOT APPLICABLE
1705.5.3 MASS TIMBER CONSTRUCTION (TYPES IV-A, IV-B, AND IV-C CONSTRUCTION)				NOT APPLICABLE
1705.6 SOILS				
1. VERIFY MATERIALS BELOW SHALLOW FOUNDATIONS ARE ADEQUATE TO ACHIEVE THE DESIGN BEARING CAPACITY.		FIELD INSPECTION	Y	PERIODIC
2. VERIFY EXCAVATIONS ARE EXTENDED TO PROPER DEPTH AND HAVE REACHED PROPER MATERIAL.		FIELD INSPECTION	Y	PERIODIC
3. PERFORM CLASSIFICATION AND TESTING OF COMPACTED FILL MATERIALS.		FIELD INSPECTION	Y	PERIODIC
4. DURING FILL PLACEMENT, VERIFY USE OF PROPER MATERIALS AND PROCEDURES IN ACCORDANCE WITH THE PROVISIONS OF THE APPROVED GEOTECHNICAL REPORT. VERIFY DENSITIES AND LIFT THICKNESSES DURING PLACEMENT AND COMPACTION OF COMPACTED FILL.		FIELD INSPECTION	Y	CONTINUOUS
5. PRIOR TO PLACEMENT OF CONTROLLED FILL, INSPECT SUBGRADE AND VERIFY THAT SITE HAS BEEN PREPARED PROPERLY.		FIELD INSPECTION	Y	PERIODIC
1705.7 DRIVEN DEEP FOUNDATIONS				NOT APPLICABLE
1705.8 CAST-IN-PLACE DEEP FOUNDATIONS				NOT APPLICABLE
1705.9 HELICAL PILE FOUNDATIONS				NOT APPLICABLE
1705.10 STRUCTURAL INTEGRITY OF DEEP FOUNDATION ELEMENTS				
WHENEVER THERE IS A REASONABLE DOUBT AS TO THE STRUCTURAL INTEGRITY OF A DEEP FOUNDATION ELEMENT, AN ENGINEERING ASSESSMENT SHALL BE REQUIRED. THE ENGINEERING ASSESSMENT SHALL INCLUDE TESTS FOR DEFECTS PERFORMED IN ACCORDANCE WITH ASTM D4945, ASTM D5882, ASTM D6760 OR ASTM D7949, OR OTHER APPROVED METHOD.		FIELD INSPECTION	Y	AS- REQUIRED
1705.11 FABRICATED ITEMS				NOT APPLICABLE
1705.12.1 STRUCTURAL WOOD SPECIAL INSPECTIONS FOR WIND RESISTANCE				NOT APPLICABLE
1705.12.2 COLD-FORMED STEEL SPECIAL INSPECTIONS FOR WIND RESISTANCE				NOT APPLICABLE
1705.12.3 WIND-RESISTING COMPONENTS				NOT APPLICABLE
1705.13.1 STRUCTURAL STEEL SPECIAL INSPECTIONS FOR SEISMIC RESISTANCE				
1. SEISMIC FORCE-RESISTING SYSTEMS IN SDC B, C, D, E, OR F.		SHOP AND FIELD INSPECTION	Y	IN ACCORDANCE WITH AISC 341
2. STRUCTURAL STEEL ELEMENTS IN SDC B, C, D, E, OR F OTHER THAN THOSE IN ITEM 1, INCLUDING STRUTS, COLLECTORS, CHORDS AND FOUNDATION ELEMENTS.		SHOP AND FIELD INSPECTION	Y	IN ACCORDANCE WITH AISC 341
1705.13.2 STRUCTURAL WOOD SPECIAL INSPECTIONS FOR SEISMIC RESISTANCE				
1705.13.3 COLD-FORMED STEEL LIGHT-FRAME CONSTRUCTION SPECIAL INSPECTIONS FOR SEISMIC RESISTANCE				
1705.13.4 DESIGNATED SEISMIC SYSTEMS VERIFICATION SPECIAL INSPECTIONS FOR SEISMIC RESISTANCE				
1705.13.5 ARCHITECTURAL COMPONENTS SPECIAL INSPECTIONS FOR SEISMIC RESISTANCE				
1. FOR SDC D, E, OR F, INSPECTION DURING THE ERECTION AND FASTENING OF EXTERIOR CLADDING AND INTERIOR OR EXTERIOR VENEER MORE THAN 30 FEET ABOVE GRADE OR WALKING SURFACE AND WEIGHING MORE THAN 5 PSF.		FIELD INSPECTION	N	PERIODIC
2. FOR SDC D, E, OR F, INSPECTION DURING THE ERECTION AND FASTENING OF INTERIOR NONBEARING WALLS MORE THAN 30 FEET ABOVE GRADE OR WALKING SURFACE AND WEIGHING MORE THAN 15 PSF.		FIELD INSPECTION	N	PERIODIC
3. FOR SDC D, E, OR F, INSPECTION DURING THE ERECTION AND FASTENING OF EXTERIOR NONBEARING WALLS MORE THAN 30 FEET ABOVE GRADE OR WALKING SURFACE.		FIELD INSPECTION	Y	PERIODIC
4. FOR SDC D, E, OR F, INSPECTION DURING ANCHORAGE OF ACCESS FLOORS		FIELD INSPECTION	N	PERIODIC

1705.13.6 PLUMBING, MECHANICAL AND ELECTRICAL COMPONENTS SPECIAL INSPECTIONS FOR SEISMIC RESISTANCE				
1. INSPECTION DURING THE ANCHORAGE OF ELECTRICAL EQUIPMENT FOR EMERGENCY OR STANDBY POWER SYSTEMS IN SDC C, D, E OR F	FIELD INSPECTION	Y	PERIODIC	
2. INSPECTION DURING THE ANCHORAGE OF OTHER ELECTRICAL EQUIPMENT IN SDC E OR F	FIELD INSPECTION	N	PERIODIC	
3. INSPECTION DURING INSTALLATION AND ANCHORAGE OF PIPING SYSTEMS DESIGNED TO CARRY HAZARDOUS MATERIALS, AND THEIR ASSOCIATED MECHANICAL UNITS IN SDC C, D, E OR F	FIELD INSPECTION	Y	PERIODIC	
4. INSPECTION DURING THE INSTALLATION AND ANCHORAGE OF HVAC DUCTWORK DESIGNED TO CONTAIN HAZARDOUS MATERIALS IN SDC C, D, E OR F	FIELD INSPECTION	Y	PERIODIC	
5. INSPECTION DURING THE INSTALLATION AND ANCHORAGE OF VIBRATION ISOLATION SYSTEMS IN SDC C, D, E OR F WHERE NOMINAL CLEARANCE OF 1/4 INCH OR LESS IS REQUIRED BY THE APPROVED CONSTRUCTION DOCUMENTS	FIELD INSPECTION	N	PERIODIC	
6. INSPECTION DURING INSTALLATION OF MECHANICAL AND ELECTRICAL EQUIPMENT, INCLUDING DUCT WORK, PIPING SYSTEMS AND THEIR STRUCTURAL SUPPORTS, WHERE AUTOMATIC FIRE SPRINKLER SYSTEMS ARE INSTALLED IN STRUCTURES ASSIGNED TO SDC C, D, E OR F TO VERIFY ONE OF THE FOLLOWING UNLESS FLEXIBLE SPRINKLER HOSE FITTINGS ARE USED:				
A. ASCE/SEI 7, SECTION 13.2.4 MINIMUM REQUIRED CLEARANCES HAVE BEEN PROVIDED.	FIELD INSPECTION	Y	PERIODIC	
B. A THREE INCH OR GREATER NOMINAL CLEARANCE HAS BEEN PROVIDED BETWEEN FIRE PROTECTION SPRINKLER SYSTEM DROPS AND SPRIGS AND STRUCTURAL MEMBERS NOT USED COLLECTIVELY OR INDEPENDENTLY TO SUPPORT THE SPRINKLERS; EQUIPMENT ATTACHED TO THE BUILDING STRUCTURE, AND OTHER SYSTEMS' PIPING.	FIELD INSPECTION	Y	PERIODIC	
1705.13.7 STORAGE RACKS SPECIAL INSPECTIONS FOR SEISMIC RESISTANCE				
INSPECTION DURING THE ANCHORAGE OF STORAGE RACKS 8 FEET OR GREATER IN HEIGHT IN STRUCTURES ASSIGNED TO SDC D, E OR F.				
1. MATERIALS USED, TO VERIFY COMPLIANCE WITH ONE OR MORE OF THE MATERIAL TEST REPORTS IN ACCORDANCE WITH THE APPROVED CONSTRUCTION DOCUMENTS.	FIELD INSPECTION	Y	PERIODIC	
2. FABRICATED STORAGE RACK ELEMENTS.	FIELD INSPECTION	Y	PERIODIC	
3. STORAGE RACK ANCHORAGE INSTALLATION.	FIELD INSPECTION	Y	PERIODIC	
4. COMPLETED STORAGE RACK SYSTEM, TO INDICATE COMPLIANCE WITH THE APPROVED CONSTRUCTION DOCUMENTS	FIELD INSPECTION	Y	PERIODIC	
1705.13.8 SEISMIC ISOLATION SYSTEMS				
NOT APPLICABLE				
1705.13.9 COLD-FORMED STEEL SPECIAL BOLTED MOMENT FRAMES				
NOT APPLICABLE				
1705.14.1 STRUCTURAL STEEL TESTING FOR SEISMIC RESISTANCE				
1. NONDESTRUCTIVE TESTING OF STRUCTURAL STEEL IN THE SEISMIC FORCE-RESISTING SYSTEMS IN ACCORDANCE WITH AISC 341 IN STRUCTURES ASSIGNED TO SDC B, C, D, E, OR F.	FIELD TEST	Y	PERIODIC	
2. NONDESTRUCTIVE TESTING OF STRUCTURAL STEEL ELEMENTS IN THE SEISMIC FORCE-RESISTING SYSTEMS NOT COVERED IN ITEM 1 ABOVE, INCLUDING STRUTS, COLLECTORS, CHORDS, AND FOUNDATION ELEMENTS IN ACCORDANCE WITH AISC 341 IN STRUCTURES ASSIGNED TO SDC B, C, D, E, OR F.	FIELD TEST	Y	PERIODIC	
1705.14.2 SEISMIC CERTIFICATION OF NONSTRUCTURAL COMPONENTS				
1. REVIEW CERTIFICATE OF COMPLIANCE FOR NON-STRUCTURAL COMPONENTS IN STRUCTURES ASSIGNED TO SDC B, C, D, E, OR F.	CERTIFICATE OF COMPLIANCE REVIEW	Y	EACH SUBMITTAL	
1705.14.3 SEISMIC CERTIFICATION OF DESIGNATED SEISMIC SYSTEMS				
REVIEW CERTIFICATE OF COMPLIANCE FOR DESIGNATED SEISMIC SYSTEM SUBJECT TO THE REQUIREMENTS OF ASCE 7, SECTION 13.2.4 AS NOTED ON THE CONSTRUCTION DOCUMENTS, IN STRUCTURES ASSIGNED TO SDC C, D, E OR F	CERTIFICATE OF COMPLIANCE REVIEW	Y	EACH SUBMITTAL	
1705.14.4 SEISMIC ISOLATION SYSTEMS				
NOT APPLICABLE				
1705.15 SPRAYED FIRE-RESISTANT MATERIALS				
NOT APPLICABLE				
1705.16 MASTIC AND INTUMESCENT FIRE-RESISTIVE MATERIALS				
NOT APPLICABLE				
1705.17 EXTERIOR INSULATION AND FINISH SYSTEMS (EIFS)				
NOT APPLICABLE				
1705.18 FIRE-RESISTANT PENETRATIONS AND JOINTS				
1. INSPECT PENETRATION FIRESTOP SYSTEMS	FIELD TESTING	Y	PER ASTM E2174	
2. INSPECT FIRE-RESISTANT JOINT SYSTEMS	FIELD TESTING	Y	PER ASTM E2393	
1705.19 SMOKE CONTROL SYSTEMS				
NOT APPLICABLE				
1705.20 SEALING OF MASS TIMBER CONSTRUCTION				
NOT APPLICABLE				
END OF SCHEDULE				

ARCHITECTURAL SPECIFICATIONS

DIVISION 00 PROCUREMENT AND CONTRACTING

00 72 00 GENERAL CONDITIONS

A. THE AIA GENERAL CONDITIONS A201 LATEST EDITION IS A PART OF THESE DOCUMENTS. COPIES ARE ON FILE AT THE OFFICE OF EXCEL ENGINEERING, INC.

00 73 16 INSURANCE REQUIREMENTS

- A. PRIOR TO COMMENCEMENT OF WORK, THE CONTRACTOR SHALL SUBMIT TO THE OWNER CERTIFICATE OF INSURANCE FOR NOT LESS THAN THE FOLLOWING LIMITS:
- WORKER'S COMPENSATION AND EMPLOYERS' LIABILITY:
 - PER STATUTORY LIMITS
 - COMMERCIAL GENERAL LIABILITY:
 - GENERAL AGGREGATE: \$2,000,000
 - PRODUCTS AND COMPLETED OPERATIONS AGGREGATE: \$2,000,000
 - PERSONAL AND ADVERTISING INJURY: \$100,000
 - EACH OCCURRENCE: \$100,000
 - CONTRACTOR SHALL LIST EXCEL ENGINEERING, INC. AS ADDITIONAL INSURED.

DIVISION 01 GENERAL REQUIREMENTS

01 11 00 SUMMARY OF WORK

- A. THE PLANS AND SPECIFICATIONS ARE INTENDED TO GIVE A DESCRIPTION OF THE WORK. NO DEVIATION FROM THE PLANS AND SPECIFICATIONS SHALL BE MADE WITHOUT THE WRITTEN CONSENT OF EXCEL ENGINEERING, INC. THE CONTRACTOR IS TO CLARIFY ANY DISCREPANCIES WITH EXCEL ENGINEERING, INC. PRIOR TO BIDDING. THE CONTRACTOR SHALL VISIT THE SITE TO VERIFY EXISTING CONDITIONS AND ACCESS TO THE WORK AREA.
- B. REFERENCE TO "GENERAL CONTRACTOR" OR "GC" IN THE CONSTRUCTION DOCUMENTS IS INTENDED TO REPRESENT THE CONTRACTOR RESPONSIBLE FOR OVERALL COORDINATION AND COORDINATION OF THE WORK. THE "GC" COULD BE A GENERAL CONTRACTOR, CONSTRUCTION MANAGER OR ANY OTHER CONTRACTOR RESPONSIBLE FOR THE OVERALL PROJECT. IT IS THE RESPONSIBILITY OF THE GC TO ASSIGN RESPONSIBILITY FOR ALL WORK.
- C. THE FOLLOWING LIST IS INTENDED TO ADD THE GC IN DIRECTING THE SUBCONTRACTORS REGARDING RESPONSIBILITY OF WORK. THE DRAWINGS MAY OR MAY NOT IDENTIFY RESPONSIBILITY FOR THESE SCOPE OF WORK. THIS LIST IS INTENDED TO PROVIDE THE GC AN AID TO ASSIGN THIS WORK SO SCOPE OF WORK IS PROPERLY BID. THE LIST IS NOT INTENDED TO BE ALL INCLUSIVE AND IT REMAINS THE RESPONSIBILITY OF THE GC TO ENSURE ALL SCOPE OF WORK ARE ASSIGNED AND PROVIDED.
- TEMPORARY ELECTRIC SERVICE
 - TEMPORARY PHONE / INTERNET
 - TEMPORARY HEATING
 - TEMPORARY WATER
 - TEMPORARY TOILETS
 - PERMITS AND SALES TAX
 - DEMOLITION
 - INTERIOR CONCRETE EQUIPMENT PADS
 - EXTERIOR CONCRETE EQUIPMENT PADS AND POLE BASES
 - OPENINGS IN EXISTING CONSTRUCTION
 - REINFORCING STEEL JOISTS FOR HANGING LOADS
 - LARGE OPENINGS IN METAL DECK
 - SMALL OPENINGS IN POLYURETHANE
 - BOX OUT OPENINGS IN MOULDED CONCRETE AND FOUNDATION WALLS
 - LARGE OPENINGS IN INSULATED METAL PANELS
 - SMALL OPENINGS IN INSULATED METAL PANELS
 - TRIM AROUND INSULATED METAL PANEL OPENINGS
 - PATCHING OPENINGS IN FLOORS, WALLS, AND ROOF
 - ROOFING, FLASHING, AND INSULATION AT ROOF CURBS
 - EXCAVATION AND BACKFILL FOR MEP WORK
 - SAW CUTTING AND REMOVAL OF FLOOR FOR UTILITIES
 - CONCRETE FLOOR REPLACEMENT WHERE SAWCUT
 - INSTALLATION OF CEILING/WALL ACCESS PANELS
 - INSTALLATION OF ROOF CURBS AND ASSOCIATED BLOCKING
 - PAINTING
 - SEALANTS

01 11 13 WORK COVERED BY THE CONSTRUCTION DOCUMENTS

- A. THE FOLLOWING IS A GENERAL LIST OF WORK COVERED BY THE CONSTRUCTION DOCUMENTS. NOTE THAT THIS LISTING IS NOT ALL-INCLUSIVE OF THE WORK TO BE PERFORMED. THE CONTRACTOR IS STILL RESPONSIBLE FOR PROVIDING ALL WORK AS COVERED IN THE CONSTRUCTION DOCUMENTS.
- GENERAL REQUIREMENTS
 - SITE:
 - SITE DEMOLITION
 - EXISTING WORK
 - SITE UTILITIES
 - STORM DRAINAGE
 - CONCRETE CURBS
 - EXTERIOR CONCRETE
 - ASPHALT PAVING/MARKINGS
 - UNIT PAVERS
 - RETAINING WALLS
 - IRRIGATION SYSTEMS
 - CHAIN LINK FENCES AND GATES
 - DUMPSTER ENCLOSURES
 - LANDSCAPING
 - SITE SIGNAGE
 - CONCRETE:
 - CAST-IN-PLACE CONCRETE
 - METALS:
 - STRUCTURAL STEEL
 - STEEL JOISTS
 - METAL FABRICATIONS
 - THERMAL AND MOISTURE PROTECTION:
 - BUILDING INSULATION
 - METAL WALL PANELS
 - MEMBRANE ROOFING
 - ROOF WALKWAYS
 - JOINT SEALANTS
 - DOORS AND WINDOWS:
 - STEEL DOORS AND FRAMES
 - OVERHEAD DOORS
 - FINISHES:
 - PAINTING
 - SPECIAL CONSTRUCTION:
 - METAL BUILDING SYSTEMS
 - MECHANICAL:
 - PLUMBING
 - FIRE PROTECTION
 - HVAC
 - ELECTRICAL

01 11 16 WORK BY OWNER

- A. THE OWNER WILL BE RESPONSIBLE FOR THE FOLLOWING COSTS AND WORK WHICH ARE NOT PART OF THE CONTRACT DOCUMENTS. CONTRACTOR SHALL ASSIST THE OWNER IN COORDINATING THE SERVICE/WORK LISTED AS REQUIRED.
- BUILDER'S RISK INSURANCE
 - GAS UTILITY SERVICE AND ASSESSMENTS
 - ELECTRIC UTILITY SERVICE AND ASSESSMENTS
 - TELEPHONE UTILITY SERVICE AND ASSESSMENTS
 - CABLE UTILITY SERVICE AND ASSESSMENTS
 - IMPACT FEES
 - SURVEY RECERTIFICATION
 - HAZARDOUS MATERIAL REMOVAL
 - LANDSCAPING
 - EXTERIOR SIGNAGE
 - TELEPHONE SYSTEM
 - SECURITY SYSTEM
 - AV EQUIPMENT
 - INTERCOM
 - SOUND SYSTEM
 - DATA AND COMPUTER WIRING AND SYSTEMS
 - UNINTERRUPTIBLE POWER SUPPLY (UPS)
 - PRODUCT SHELVING / RACKS
 - SPECIAL INSPECTIONS. THE OWNER SHALL EMPLOY SPECIAL INSPECTORS TO PROVIDE INSPECTIONS DURING CONSTRUCTION AS REQUIRED BY PER CHAPTER 17 OF THE IBC. TESTS AND INSPECTIONS SHALL BE CONDUCTED BY TESTING AGENCIES APPROVED BY THE CODE ENFORCEMENT OFFICIAL. SEE SCHEDULE OF SPECIAL INSPECTIONS ON T2.0.

01 23 00 ALTERNATE BIDS

- A. ALTERNATE BID A1: PROVIDE COST FOR GALVANIZED GOALPOST/GUARD POST IN LBL OF THE STAINLESS STEEL GUARD POSTS CALLED OUT ON SHEET A6.0

01 25 13 PRODUCT SUBSTITUTION PROCEDURES

- A. REFERENCE TO MATERIALS OR SYSTEMS HEREIN BY NAME, MAKE OR CATALOG NUMBER IS INTENDED TO ESTABLISH A QUALITY STANDARD, AND NOT TO LIMIT COMPETITION. THE WORDS "OR APPROVED EQUIVALENT" ARE IMPLIED FOLLOWING EACH BRAND NAME/MODEL NUMBER UNLESS STATED OTHERWISE. "OR APPROVED EQUIVALENT" MATERIALS SHALL BE APPROVED BY EXCEL ENGINEERING, INC. PRIOR TO BIDS BEING ACCEPTED AND ACCEPTANCE FOR USE. PROVIDE A LETTER FROM THE MANUFACTURER CERTIFYING THAT THE PRODUCT MEETS OR EXCEEDS THE SPECIFIED PRODUCT.

01 31 00 PROJECT MANAGEMENT AND COORDINATION

- A. THE CONTRACTOR HAS THE SOLE RESPONSIBILITY FOR AND SHALL HAVE CONTROL OF CONSTRUCTION MEANS, METHODS, TECHNIQUES, SEQUENCES, AND SAFETY PRECAUTIONS AND PROCEDURES USED TO CONSTRUCT THE WORK.
- B. THE CONTRACTOR SHALL FURNISH ALL LABOR, MATERIAL (INCLUDING TAXES), AND EQUIPMENT AS NECESSARY TO COMPLETE THE WORK. PERMITS SHALL BE OBTAINED AND PAID FOR BY THE RESPECTIVE CONTRACTOR, INCLUDING TEMPORARY OCCUPANCY PERMIT IF REQUIRED.
- C. REVIT / AUTOCAD FILES OF CONSTRUCTION DOCUMENTS MAY BE OBTAINED BY CONTACTING EXCEL ENGINEERING, INC. 3 DIMENSIONAL MODEL MAY BE PROVIDED TO CONVEY DESIGN INTENT. FILE REQUESTS SHALL BE EMAILED TO EXCEL PROJECT MANAGER AND PROJECT ASSISTANT AND SHALL INCLUDE THE FOLLOWING INFORMATION:
- EXCEL ENGINEERING PROJECT NAME
 - EXCEL ENGINEERING PROJECT NUMBER
 - SHEET NUMBERS REQUESTED
- D. REVIT / AUTOCAD FILES REQUEST SHALL BE MADE TO:
- PROJECT MANAGER - (DANIEL ST. LOUIS AT DANIELSTLOUIS@EXCELENGINEER.COM)
 - PROJECT ASSISTANT - (LISA DICKMANN AT EOODSGROUP@EXCELENGINEER.COM)
- E. REVIT / AUTOCAD FILES WILL BE SENT BY EXCEL ENGINEERING, INC. CHOOSING AS SOON AS POSSIBLE.
- F. REVIT / AUTOCAD FILES SHALL NOT BE USED FOR COMPONENT SUBMITTALS OR SHOP DRAWINGS. SUBMITTALS AND SHOP DRAWINGS USING EXCEL ENGINEERING, INC. CAD FILES WILL BE RETURNED REJECTED AND UN-REVIEWED.
- G. ALL "REQUEST FOR INFORMATION" (RFI) SHALL BE MADE THROUGH THE GENERAL CONTRACTOR FOR LOGGING AND TRACKING PURPOSES. RFIs SHALL BE SUBMITTED TO THE EXCEL ENGINEERING PROJECT ASSISTANT. RFIs SHALL BE SUBMITTED ON AN ARCHITECT APPROVED FORM, NUMBER SEQUENCE AND INCLUDE THE FOLLOWING INFORMATION:
- EXCEL ENGINEERING PROJECT NAME

- EXCEL ENGINEERING PROJECT NUMBER
- DIVISION OF CONSTRUCTION REFERENCED
- POTENTIAL SCHEDULE IMPACTS
- POTENTIAL COST IMPACTS OF ANY SUGGESTED ALTERNATES FROM THE CONSTRUCTION DOCUMENTS

01 32 00 SCHEDULING OF WORK

- A. THE CONTRACTOR SHALL OBTAIN THE OWNER'S APPROVAL OF THE CONSTRUCTION SCHEDULE PRIOR TO PROCEEDING WITH THE WORK.

01 33 23 SHOP DRAWINGS, PRODUCT DATA, AND SAMPLES

- A. SUBMIT FOR APPROVAL ARCHITECTURAL, CIVIL, STRUCTURAL, HVAC, PLUMBING, FIRE PROTECTION AND ELECTRICAL SHOP DRAWINGS, PRODUCT DATA TEST RESULTS AND SAMPLES INDICATED IN THE CONSTRUCTION ADMINISTRATION SUBMITTAL LIST (CASL). SEE DISCIPLINE SPECIFICATIONS FOR DISCIPLINE SPECIFIC CASL.
- B. SHOP DRAWING SUBMITTALS SHALL BE MADE TO EXCEL ENGINEERING, INC. FOR APPROVAL PRIOR TO FABRICATION AND INSTALLATION.
- C. SUBMITTALS SHALL BE MADE BY ELECTRONIC SUBMISSION IN PORTABLE DOCUMENT FORMAT (PDF) UNLESS NOTED OTHERWISE. WHEN HARD COPY SUBMISSIONS ARE REQUIRED, COORDINATE WITH EXCEL ENGINEERING, INC. PRIOR TO SUBMISSION.
- D. SUBMITTALS SHALL BE MADE TO THE EXCEL ENGINEERING, INC. PROJECT ASSISTANT:
- LISA DICKMANN OR MICHELLE SCHAALMA AT EOODSGROUP@EXCELENGINEER.COM
- E. SUBMITTAL SHALL BE MADE USING APPROVED SUBMITTAL FORM CONTAINING AT MINIMUM THE FOLLOWING INFORMATION:
- EXCEL ENGINEERING PROJECT NAME
 - EXCEL ENGINEERING PROJECT NUMBER
 - SUBMITTAL DIVISION OF CONSTRUCTION
 - MATERIAL SUPPLIER / SUBCONTRACTOR
 - SUBMITTAL DESCRIPTION (i.e. CONCRETE MIX DESIGN)
- F. SUBMITTALS SHALL BE REVIEWED AND STAMPED BY THE CONTRACTOR PRIOR TO SUBMITTING FOR APPROVAL. CONTRACTOR SHALL COMPLETE ALL FIELD VERIFICATIONS PRIOR TO SUBMITTAL SUBMISSION.
- G. SUBMITTALS MUST BE 100% COMPLETE AND IN ONE (1) PACKAGE FOR THE ITEM BEING SUBMITTED. NON-COMPLATE SUBMITTALS WILL BE RETURNED TO THE CONTRACTOR WITHOUT COMMENT AND STAMPED "REJECTED-RESUBMIT". CONTRACTOR WHO KNOWINGLY WANTS TO SUBMIT NON-COMPLATE SUBMITTALS OR BREAK SINGLE SYSTEM SUBMITTALS INTO MULTIPLE SUBMITTALS WILL BE RESPONSIBLE TO ARRANGE WITH EXCEL ENGINEERING, INC. PRIOR TO SUBMITTING THE SUBMITTALS, AND TO COMPENSATE EXCEL ENGINEERING FOR THE EXTRA WORK INVOLVED.
- H. SHOP DRAWINGS SHALL CLEARLY INDICATE SPECIFIC MODEL BEING PROVIDED WHERE CUT SHEETS SHOW MULTIPLE MODELS.
- I. FAILURE TO SUBMIT SHOP DRAWINGS SHALL NOT RELIEVE THE CONTRACTOR FROM PROVIDING THE SPECIFIED EQUIPMENT AND MATERIALS.
- J. PHYSICAL SAMPLES FOR FINISHES ARE TO BE SUBMITTED TO EXCEL ENGINEERING, INC. FOR APPROVAL PRIOR TO INSTALLATION.
- K. BUILDING COMPONENTS REQUIRING SUBMISSION "FOR RECORD" TO THE AUTHORITY HAVING JURISDICTION REQUIRE SEALED AND SIGN HARD COPIES, PROVIDE TWO (2) HARD COPIES WITH WET SEAL AND ORIGINAL SIGNATURE IN ADDITION TO THE ELECTRONIC SUBMISSION IN PORTABLE DOCUMENT FORMAT (PDF).
- L. TEST RESULTS SHALL BE SUBMITTED FOR REVIEW PRIOR TO REVIEW OF SUBMITTALS.
- M. CONTRACTOR SHALL ALLOW 10 WORKING DAYS IN SCHEDULE FOR A/E TO REVIEW SUBMITTALS. IF SUBMITTALS REQUIRE AN EXPEDITED REVIEW PROCESS, CONTACT EXCEL ENGINEERING, INC. PRIOR TO SUBMITTING THE SUBMITTALS (S) TO MAKE THE APPROPRIATE ARRANGEMENT.
- N. SUBMITTALS REQUIRING RESUBMISSION SHALL HAVE CHANGES MADE TO A PREVIOUSLY REVIEWED SUBMITTAL DENOTED WITH REVISION CLOUDS AND TAGS IDENTIFYING CHANGES.
- O. ARCHITECTURAL CONSTRUCTION ADMINISTRATION SUBMITTAL LIST:
- INSULATION
 - INSULATED METAL PANELS
 - MEMBRANE ROOFING SYSTEMS
 - ROOFING ACCESSORIES
 - SEALANTS
 - HOLLOW METAL DOORS AND FRAMES
 - DOOR HARDWARE
 - PAINTING SYSTEMS
 - FIRE EXTINGUISHERS
 - METAL BUILDING SYSTEMS (PROVIDE "PRELIMINARY" AND "FOR RECORD" SUBMITTALS)
 - STRUCTURAL AND ARCHITECTURAL PLANS SHOW DIMENSIONS TO SIGNIFICANT WORKING POINTS. SHOP DRAWING DETAILERS AND SUPPLIERS ARE NOTIFIED FOR THE DETERMINATION OF ALL DIMENSIONS, PITCHES, ELEVATIONS, ETC. BEYOND THOSE NOTED AS NECESSARY TO THOROUGHLY DETAIL / FABRICATE THEIR WORK SHALL BE IN CONTACT A/E WITH ANY DISCREPANCIES FOUND.
 - IN NO CASE SHALL CHANGES BE MADE TO WORK SHOWN OR PROCEDURE SPECIFIED ON STRUCTURAL PLANS UNLESS FIRST APPROVED IN WRITING BY A/E. REVIEW SHOP DRAWINGS BY A/E DOES NOT CONSTITUTE ACCEPTANCE OF A DESIGN CHANGE. PROPOSED CHANGES BY CONTRACTOR MUST BE SUBMITTED IN RFI FORMAT AND MUST BE APPROVED IN THE SAME MANNER. CONTRACTOR REQUESTING CHANGE MAY BE BILLED ON A TIME AND EXPENSE BASIS BY A/E FOR ALL REDESIGN WORK, FOR ALL NEW SKETCHES PREPARED, AND FOR ALL ADDITIONAL REVIEW TIME RELATED TO THE CHANGES.

01 40 00 QUALITY REQUIREMENTS

- A. IN AS MUCH AS THE SPECIFICATIONS ARE BRIEF, THE CONTRACTOR SHALL PROVIDE WORKMANSHIP THAT IS NEAT, SECURE AND OF THE BEST QUALITY WITH THE BEST POSSIBLE APPEARANCE AND UTILITY MEETING ALL APPLICABLE STANDARDS. FAULTY WORK SHALL BE REPAIRED OR REPLACED AT NO COST TO THE OWNER. INDUSTRY STANDARDS SHALL BE USED AS THE GUIDE FOR QUALITY OF MATERIALS AND WORKMANSHIP.

01 41 00 REGULATORY REQUIREMENTS

- A. ALL APPLICABLE FEDERAL, STATE, AND LOCAL CODES, ORDINANCES AND REGULATIONS, INCLUDING THE REQUIREMENTS OF THE AMERICAN WITH DISABILITIES ACT (A.D.A.) ARE MADE PART OF THESE SPECIFICATIONS AND SHALL BE COMPLIED WITH AS FAR AS THEY APPLY TO WORK UNDER THIS CONTRACT.

01 45 00 QUALITY CONTROL

- A. NOTIFY ARCHITECT ONE WEEK IN ADVANCE TO SCHEDULE FINAL COMPLIANCE WALK-THRU PRIOR TO THIS WALK THRU. PROVIDE THE ARCHITECT WITH THE FIRE PROTECTION SYSTEM TEST REPORT AND A COPY OF THE ELEVATOR INSPECTION REPORT AS APPLICABLE. ALL COMPONENT SUBMITTALS SHOULD BE FILED AND AVAILABLE FOR REVIEW AT THE WALK THRU. THE BUILDING SHALL BE COMPLETE AND ALL SYSTEMS OPERATIONAL AT THE TIME OF THE WALK THRU. IF THE ARCHITECT IS REQUIRED TO MAKE ADDITIONAL VISITS DUE TO NON-COMPLIANCE, THEY WILL BE CHARGED TO THE REQUESTING CONTRACTOR.
- B. 45 33 SPECIAL INSPECTIONS
- SPECIAL INSPECTIONS PER IBC CHAPTER 17 ARE REQUIRED FOR THE PROJECT.
 - REQUIRED SPECIAL INSPECTIONS FOR THE PROJECT ARE LISTED ON T2.0 SHEETS.
 - OWNER HAS CONTRACTED THE SPECIAL INSPECTION WORK.
 - GC SHALL:
 - CREATE A PRE-CONSTRUCTION MEETING WITH SPECIAL INSPECTOR TO REVIEW SCOPE OF SPECIAL INSPECTIONS.
 - CREATE AND POST OR MAKE AVAILABLE THE SPECIAL INSPECTOR'S TESTING SCHEDULE AT THE JOB SITE.
 - PROVIDE ADEQUATE NOTIFICATION TO THOSE PARTIES DESIGNATED ON THE SCHEDULE SO THEY MAY PREPARE FOR AND SCHEDULE THEIR SERVICES. FAILURE TO SCHEDULE A SPECIAL INSPECTOR IN A TIMELY MANNER WILL NOT ALLOW FOR A CHANGE IN CONSTRUCTION SCHEDULE.
 - PROVIDE THE SPECIAL INSPECTOR ACCESS TO THE APPROVED PLANS AND SPECS AT THE JOB SITE.
 - PROVIDE THE SPECIAL INSPECTOR SAFE ACCESS TO THE WORK.
 - REVIEW ALL REPORTS ISSUED BY SPECIAL INSPECTORS AND RETAIN AT THE JOB SITE FOR REVIEW BY THE BUILDING OFFICIAL.
 - CORRECT IN A TIMELY MANNER DEFICIENCIES IDENTIFIED IN REPORTS.

01 52 00 CONSTRUCTION FACILITIES

- A. THE CONTRACTOR SHALL FURNISH TEMPORARY OFFICE, TOILET FACILITIES, WORKING TELEPHONE, ELECTRICITY, HEAT, WATER AND FIRE EXTINGUISHERS AS REQUIRED FOR COMPLETION OF THE WORK UNLESS THE OWNER HAS AGREED IN WRITING TO FURNISH OR WAIVE ANY OF THE ABOVE ITEMS.

01 53 00 TEMPORARY CONSTRUCTION

- A. THE CONTRACTOR SHALL FURNISH TEMPORARY BRACING OF ALL BUILDING ELEMENTS DURING CONSTRUCTION. TEMPORARY BRACING IS DESIGNED TO WITHSTAND CODE DESIGN LOADS. CONTRACTOR SHALL RETAIN SERVICES OF A PROFESSIONAL ENGINEER TO DESIGN AND SUPERVISE BRACING INSTALLATION IF THEY DO NOT HAVE THE EXPERTISE REQUIRED.

01 71 00 FIELD ENGINEERING

- A. THE CONTRACTOR SHALL PROVIDE ALL LAYOUT AS REQUIRED, COMPLETION FULLTIME ON SITE SUPERVISION, AND BROOM CLEANING OF CONSTRUCTION SITE INCLUDING DUMPSTERS FOR REFUSE DISPOSAL. THE CONTRACTOR SHALL BE RESPONSIBLE FOR ALL SAFETY ON SITE AND PROTECTION OF SITE PER LOCAL, STATE AND FEDERAL REQUIREMENTS.

01 78 00 CLOSEOUT SUBMITTALS

- A. THE CONTRACTOR SHALL FURNISH "AS-BUILT" DRAWINGS REFLECTING ALL CHANGES DURING CONSTRUCTION, PROVIDE TWO (2) COPIES OF OPERATING AND MAINTENANCE MANUALS TO OWNER FOR ALL FURNISHED EQUIPMENT.

01 78 36 WARRANTIES

- A. THE CONTRACTOR SHALL GUARANTEE ALL WORKMANSHIP AND MATERIALS FOR A PERIOD OF ONE YEAR AFTER SUBSTANTIAL COMPLETION OF THE PROJECT. FURNISH MANUFACTURER'S WRITTEN WARRANTIES FOR SPECIFIED EQUIPMENT STATING EFFECTIVE WARRANTY DATE.

01 91 13 GENERAL COMMISSIONING REQUIREMENTS

- A. COMMISSIONING ENCOMPASSES THE VERIFICATION THAT THE OPERATION OF APPLICABLE EQUIPMENT AND SYSTEMS MEET THE DESIGN SPECIFICATIONS AS DOCUMENTED THROUGH FUNCTIONAL TESTING. COMMISSIONING ACTIVITIES WILL BE LED BY THE COMMISSIONING PROVIDER (CMP).
- SEE DIVISION 22 08 00 COMMISSIONING OF PLUMBING FOR ADDITIONAL REQUIREMENTS.
 - SEE DIVISION 23 08 00 COMMISSIONING OF HVAC FOR ADDITIONAL REQUIREMENTS.
- B. GENERAL CONTRACTOR SHALL HIRE COMMISSIONING PROVIDER TO MEET 2021 IECC SECTION C408 REQUIREMENTS.
- THE GENERAL CONTRACTOR SHALL SCHEDULE PROJECT AND CONTRACTORS TO COMPLETE SYSTEM INSTALLATIONS, BALANCING AND STARTUP TO INCLUDE TIME REQUIRED BY COMMISSIONING PROVIDER FOR FUNCTIONAL TESTING (CALLED "ON-SITE FUNCTIONAL TESTING") BEFORE OWNER OCCUPANCY. THIS ACTIVITY SHALL NOT TAKE PLACE UNTIL ALL SUBMITTALS HAVE BEEN RECEIVED AND REVIEWED BY THE COMMISSIONING PROVIDER AND ALL SYSTEMS HAVE BEEN INSTALLED, STARTED UP AND ARE FULLY WITHIN INSULATION.
 - GC SHALL SCHEDULE SUBCONTRACTORS TO PARTICIPATE IN AND PERFORM COMMISSIONING PROCESS ACTIVITIES AND COORDINATE THE SCHEDULE WITH OWNER AND COMMISSIONING PROVIDER.
 - THE COMMISSIONING PROVIDER WILL DETERMINE THE COMMISSIONING TEAM, BUT WILL USUALLY INCLUDE THE DESIGN TEAM, GENERAL CONTRACTOR, SITE SUPERVISOR, HVAC, ELECTRICAL AND PLUMBING SUBCONTRACTORS.
 - COMMISSIONING TEAM MEMBERS SHALL BE REQUIRED TO PARTICIPATE IN THE FOLLOWING TEAM MEETINGS WHICH MAY TAKE PLACE VIA CONFERENCE CALL OR VIRTUAL MEETING:
 - PRE-COMMISSIONING KICKOFF MEETING: AN OVERVIEW OF THE COMMISSIONING PROCESS SUBMITTALS AND SCHEDULE AND REVIEW OF THE ON-SITE FUNCTIONAL TEST PROCESS PROCEDURE.
 - FUNCTIONAL TESTING MEETING: AN OVERVIEW OF ANY DEFICIENCIES FOUND DURING THE ON-SITE FUNCTIONAL TEST PROCESS. DEFICIENCIES WILL BE DOCUMENTED IN AN ISSUES LOG AND DISTRIBUTED TO ALL PARTIES.
 - COMMISSIONING TESTING AND SUBMITTALS:
 - PRE-FUNCTIONAL CHECKLIST SHALL BE PROVIDED TO EACH SUBCONTRACTOR BY CMP FOR COMPLETION.
 - THE GENERAL CONTRACTOR SHALL BE RESPONSIBLE FOR VERIFYING AND SIGN OFF THAT ALL PREFUNCTIONAL CHECKLISTS ARE COMPLETED AND SYSTEMS ARE TESTED BY EACH SUBCONTRACTOR BEFORE SCHEDULING COMMISSIONING. GC IS RESPONSIBLE FOR COST OF ADDITIONAL COMMISSIONING PROVIDER SITE VISITS DUE TO SYSTEMS NOT BEING READY.
 - TEST AND BALANCE REPORT SHALL BE PROVIDED TO THE OWNER, ENGINEER, AND COMMISSIONING PROVIDER PRIOR TO THE FUNCTIONAL TESTING DATE.
 - FUNCTIONAL TESTS SHALL BE COMPLETED UNDER THE OBSERVATION OF THE COMMISSIONING PROVIDER IN COLLABORATION WITH THE OTHER MEMBERS OF THE COMMISSIONING TEAM.

- TEST RESULTS ARE DOCUMENTED BY THE COMMISSIONING PROVIDER. FUNCTIONAL TESTS ARE DOCUMENTED TESTS OF THE DYNAMIC OPERATION OF THE EQUIPMENT AND SYSTEMS WITH THE GOAL OF VERIFYING THAT THE ACCEPTANCE CRITERIA ARE MET.
- COMMISSIONING PROVIDER WILL PROVIDE A PRELIMINARY COMMISSIONING REPORT TO THE OWNER AND INSPECTOR AND EXCEL ENGINEERING WHICH SHALL INCLUDE THE FOLLOWING:
 - ITEMIZATION OF DEFICIENCIES FOUND DURING TESTING THAT HAVE NOT BEEN CORRECTED AT THE TIME OF REPORT PREPARATION.
 - DEFERRED TESTS THAT CANNOT BE PERFORMED AT THE TIME OF REPORT PREPARATION BECAUSE OF CLIMATIC CONDITIONS.
 - CLIMATIC CONDITIONS REQUIRED FOR PERFORMANCE OF THE DEFERRED TESTS.
 - RESULTS OF FUNCTIONAL PERFORMANCE TESTS.
 - FUNCTIONAL PERFORMANCE TEST PROCEDURES USED DURING THE COMMISSIONING PROCESS, INCLUDING MEASURABLE CRITERIA FOR TEST ACCEPTANCE.
- GENERAL CONTRACTOR SHALL COORDINATE AND MONITOR SUBCONTRACTORS TO CORRECT IDENTIFIED DEFICIENCIES AND COORDINATE WITH COMMISSIONING PROVIDER FOLLOW-UP SITE VISITS FOR FINAL COMMISSIONING.
- COMMISSIONING PROVIDER SHALL PROVIDE FINAL COMMISSIONING REPORT TO THE OWNER WITHIN 90 DAYS OF THE DATE OF RECEIPT OF CERTIFICATE OF OCCUPANCY.
 - RESULTS OF FUNCTIONAL PERFORMANCE TESTS.
 - DEFICIENCIES FOUND DURING TESTING AND DETAILS OF CORRECTIVE MEASURES USED OR PROPOSED.

DIVISION 02 EXISTING CONDITIONS

02 41 19 SELECTIVE DEMOLITION

- A. CONDUCT DEMOLITION AND DEBRIS REMOVAL OPERATIONS TO ENSURE MINIMUM INTERFERENCE WITH ROADS, STREETS, WALKS, AND OTHER ADJACENT OCCUPIED AND USED FACILITIES.
- B. IT IS UNKNOWN WHETHER HAZARDOUS MATERIALS WILL BE ENCOUNTERED, DO NOT DISTURB, IMMEDIATELY NOTIFY ARCHITECT AND OWNER.
- C. DEMOLISH AND REMOVE EXISTING CONSTRUCTION ONLY TO THE EXTENT REQUIRED BY NEW CONSTRUCTION AND AS SHOWN ON THE DEMOLITION PLANS. USE METHODS REQUIRED TO COMPLETE THE WORK WITHIN LIMITATIONS OF GOVERNING REGULATIONS.
- D. EXCEPT FOR ITEMS INDICATED TO BE REUSED, SALVAGED, REINSTALLED OR TO REMAIN OWNER'S PROPERTY, REMOVE DEMOLISHED MATERIALS FROM PROJECT SITE AND LEGALLY DISPOSE OF THEM IN AN EPA APPROVED LANDFILL.

DIVISION 03 CONCRETE

03 30 00 CAST-IN-PLACE CONCRETE

- A. SEE STRUCTURAL SPECIFICATIONS.

DIVISION 05 METALS

05 12 00 STRUCTURAL STEEL FRAMING

- A. SEE STRUCTURAL SPECIFICATIONS.

05 21 00 STEEL JOIST FRAMING

- A. SEE STRUCTURAL SPECIFICATIONS.

05 31 00 STEEL DECKING

- A. SEE STRUCTURAL SPECIFICATIONS.

DIVISION 07 THERMAL AND MOISTURE PROTECTION

07 21 00 INSULATION

- A. ALL INSULATION MATERIALS AND INSTALLATION SHALL COMPLY WITH LOCAL AND STATE CODES.
- B. PERIMETER FOUNDATION INSULATION
- MANUFACTURER: DOW STYROFOAM SQUARE EDGE EXTRUDED POLYSTYRENE (XPS) INSULATION PANELS, 2.5 PSI MIN. VERTICAL COMPRESSIVE STRENGTH/IN MEASURED AT 10% STRAIN DEFORMATION OR AT YIELD, WHICHEVER OCCURS FIRST. THERMAL VALUE "R" VALUE OF 5.0 PER INCH, 2 INCHES THICK, R=10.
 - MANUFACTURER: RYNATHOAT FOAM GOLD GUARD FOUNDATION PERIMETER INSULATION EXTRUDED POLYSTYRENE (EPS) INSULATION, 2.5 PSI MIN. VERTICAL COMPRESSIVE STRENGTH/MEASURED AT 10% STRAIN DEFORMATION. THERMAL VALUE "R" VALUE OF 4.35 PER INCH, 2.3 INCHES THICK, R=10.
- C. SPRAY POLYURETHANE FOAM INSULATION
- MANUFACTURER: BASF WULFITE MAX
 - DENSITY IN PLACE: 1.8 TO 2.0 LB / CU FT.
 - COMPRESSIVE STRENGTH: GREATER THAN 25 PSI
 - CLOSED CELL CONTENT: ~95%
 - R-VALUE PER INCH: 7.4 PER 1" AT LESS THAN 3.5" — 7.1 PER 1" AT GREATER THAN 3.5"
 - VAPOR PERMEANCE: 1.09 PERMS — LESS THAN 1.0 PERMS AT 1.25" (CLASS II VAPOR RETARDER)
 - FLAME SPREAD INDEX: LESS THAN OR EQUAL TO 25
 - SMOKE DEVELOPED INDEX: LESS THAN OR EQUAL TO 450
 - AIR LEAKAGE: LESS THAN 0.02 AT 1" (AIR IMPERMEABLE INSULATION)
- D. THERMAL BARRIER / IGNITION BARRIER INTUMESCENT COATING
- MANUFACTURER: NO-BURN PLUS
 - THICKNESS AS REQUIRED BY MANUFACTURER TO MEET CODE.
 - COLOR SELECTED BY OWNER (WHITE, GRAY, DARK CHARCOAL).
- E. ROOF INSULATION
- SEE ROOF PLAN.

07 26 00 VAPOR RETARDERS

- A. UNDER SLAB
- MANUFACTURER: STEGO WRAP VAPOR BARRIER
 - 15 MIL POLYOLEFIN-BASED RESIN, ASTM E1745 CLASS A MAX PERM 0.01.
 - MINIMUM 2,200 GRAMS PUNCTURE RESISTANCE, ASTM D 1709
 - SEAL ALL JOINTS WITH MFR APPROVED TAPE OR MASTIC PER MFR INSTRUCTIONS.
 - CONTRACTOR SHALL VERIFY THICKNESS AND CLASS WITH CONCRETE PLACEMENT MEANS AND METHODS.

07 41 13 INSULATED METAL PANELS:

- A. MANUFACTURER SHALL DETERMINE IF A THICKER SHEET STEEL FACE IS REQUIRED BASED ON PANEL SPANS SHOWN ON PLANS AND TEMPERATURE EXPOSURE. INSULATED PANELS SHALL BE CONSTRUCTED USING MINIMUM 26 GAGE (UNLESS DETERMINED BY MANUFACTURER FOR THICKER SHEET STEEL FACE OR NOTED OTHERWISE ON PLANS) GALVANIZED SHEET STEEL (STAINLESS WHERE STAINLESS FINISH) WITH A FOAMED-IN-PLACE URETHANE CORE.
- B. THICKNESS OF INSULATED METAL PANEL SHALL BE AS NOTED ON THE DRAWINGS.
- C. PROVIDE SEALANT AS SPECIFIED IN PANEL TO PANEL (BOTH JOINTS OF DOUBLE JOINT) PANEL TO BASE CHANNEL, PANEL TO WALL ANGLE PANEL TO PANEL, STANDING SEAM AND TRIM AND FACE JOINTS WHERE INDICATED OR RECOMMENDED BY INSULATED PANEL MANUFACTURER.
- D. FINISHES:
- SEE PLANS FOR INTERIOR AND EXTERIOR FINISHES.
 - "WALK-OFF" FACE OF CEILING PANELS SHALL HAVE A GALVANIZED FINISH.
- E. PROVIDE METAL TRIM AND FASTENERS OF MATERIAL AND FINISH TO MATCH PANEL SURFACE TO WHICH IT IS TO BE SECURED.
- F. WHERE INTERNAL OPERATING TEMPERATURE IS LOWER THAN 50 DEGREES F SUCH AS PRODUCTION, COOLER OR FREEZER LOCATIONS, INSTALL MFM PEEL & SEAL POWERBOND 45 MIL TAPE ON WARM SIDE OF ALL PANEL TO PANEL, CORNER AND STACK JOINTS AND SEAL TO PANEL FACES.
- G. WALL PANELS:
- PANEL MANUFACTURER SHALL PROVIDE FASTENING TYPE AND PATTERN AT TOP AND BOTTOM OF PANELS AS WELL AS AT GIRTS OCCURRING AT VERTICAL SPACINGS INDICATED.
 - SEE STRUCTURAL SPECIFICATIONS FOR DELEGATED DESIGN REQUIREMENTS.
- H. FIRE PERFORMANCE CHARACTERISTICS
- METAL PANELS SHALL HAVE THERMAL BARRIERS MEETING THE FOLLOWING TESTING STANDARDS VERIFIED BY INDEPENDENT THIRD-PARTY TESTING AGENCIES. PANELS SHALL MEET THE REQUIREMENTS OF IBC CHAPTER 26 FOR FOAM PLASTIC INSULATION.
 - MAXIMUM FLAME SPREAD INDEX OF 25 AND SMOKE DEVELOPMENT INDEX OF 450 WHEN TESTED PER ASTM E84 OR UL 263.
 - TEMPERATURE TRANSMISSION FIRE TEST AND INTEGRITY FIRE TEST ON COMPLIANCE WITH ASTM E119 AND UL1715 OR NFPA 286 TO MEET NFPA 275 REQUIREMENTS.
 - VERTICAL AND LATERAL FIRE PROPAGATION REQUIREMENTS PER NFPA 285.

07 54 23 THERMOPLASTIC POLYOLEFIN (TPO) ROOFING

- A. INSTALLER SHALL BE APPROVED, AUTHORIZED OR LICENSED BY A MINIMUM OF TWO APPROVED SYSTEM MANUFACTURERS FOR MINIMUM OF 3 CONSECUTIVE YEARS TO INSTALL MANUFACTURER'S PRODUCTS AND IS ELIGIBLE TO RECEIVE MANUFACTURER'S WARRANTIES.
- B. PROVIDE FM APPROVALS ROOFNAP LISTING FOR CLASS 1 OR NONCOMBUSTIBLE CONSTRUCTION WITH SYSTEM SUBMITTALS.
- C. FASTENING SYSTEM SHALL BE CAPABLE OF WITHSTANDING WIND UPLIFT REQUIREMENTS INDICATED ON THE STRUCTURAL PLANS.
- D. CONDUCT ON-SITE PREINSTALLATION CONFERENCE WITH ALL TRADES INTERFACING OR ADJACENT TO THE ROOFING SYSTEM. INCLUDE MANUFACTURER'S REPRESENTATIVE.
- E. ALL COMPONENTS OF THE ROOFING SYSTEM SHALL BE PROVIDED FROM A SINGLE SOURCE INCLUDING ALL AUXILIARY AND ACCESSORIES MATERIALS FOR A COMPLETE INSTALLATION.
- F. COORDINATE INSTALLING MEMBRANE ROOFING SYSTEM COMPONENTS SO INSULATION IS NOT EXPOSED TO PRECIPITATION OR LEFT EXPOSED AT THE END OF THE WORKDAY.
- G. COMPLY WITH MEMBRANE ROOFING SYSTEM AND INSULATION MANUFACTURER'S WRITTEN INSTRUCTIONS AND DETAILS FOR INSTALLING ROOF INSULATION.
- H. FILL ALL GAPS EXCEEDING 1/4" IN WIDTH WITH INSULATION.
- I. INSTALL MEMBRANE ROOFING OVER AREA TO RECEIVE ROOFING ACCORDING TO MEMBRANE ROOFING SYSTEM MANUFACTURER'S WRITTEN INSTRUCTIONS.
- J. SEAM MEMBRANE ROOFING ACCORDING TO MANUFACTURER'S WRITTEN INSTRUCTIONS TO ENSURE A WATERIGHT SEAM INSTALLATION.
- K. INSTALL SHEET FLASHINGS AND PREFORMED FLASHING ACCESSORIES AND ADHERE TO SUBSTRATES ACCORDING TO MEMBRANE ROOFING SYSTEM MANUFACTURER'S WRITTEN INSTRUCTIONS.
- L. PROTECT ROOFING SYSTEM DURING DURATION OF CONSTRUCTION FROM DAMAGE FROM CONSTRUCTION ACTIVITIES. PROTECT AT ALL LOCATIONS WHERE CUTTING, GRINDING OR OTHER HOT WORK IS BEING COMPLETED.
- M. CONDUCT ROUTINE ROOF DEBRIS CLEANING AND INSPECTION DURING THE DURATION OF CONSTRUCTION ACTIVITIES.
- N. CLEAN OVERSPRAY OR SPILLAGE FROM ADJACENT CONSTRUCTION USING CLEANING AGENTS AND PROCEDURES RECOMMENDED BY MANUFACTURER OF AFFECTED CONSTRUCTION.
- O. SEE PLANS FOR SYSTEMS REQUIREMENTS INCLUDING WARRANTY, MATERIAL TYPE AND LOCATION OF USE.
- P. INCLUDE COPY OF MANUFACTURER'S FINAL INSTALLATION INSPECTION ACCEPTANCE REPORT AND WARRANTY UPON INSTALLATION COMPLETION.

07 92 00 SEALANTS

- A. GENERAL:
- IT IS THE INTENTION OF THIS SPECIFICATION THAT ALL JOINTS ARE TO RECEIVE SEALANT.
 - APPLY SEALANT IN ALL INDICATED LOCATIONS ACCORDING TO THE MANUFACTURER'S WRITTEN INSTRUCTIONS, INCLUDING BUT NOT LIMITED TO, JOINT WIDTH, SURFACE PREPARATION, PRIMERS, APPLICATION TEMPERATURE AND MATERIAL STORAGE.
 - APPLY SEALANT AFTER FINISH OPERATIONS ARE COMPLETE.
 - SEALANT COLOR TO MATCH ADJACENT FINISH.
 - PROVIDE APPROPRIATE SIZED BACKER RODS AND BOND BREAK AT ALL JOINTS UNLESS OTHERWISE NOTED IN THE MANUFACTURER'S INSTRUCTIONS.
 - SEE SCHEDULE ON PLANS.

DIVISION 08 OPENINGS

08 11 13 HOLLOW METAL DOORS AND FRAMES

- A. HOLLOW METAL FRAMES: COMPLY WITH ANSIS/D501 A230.11.

- SET FRAMES ACCURATELY IN POSITION, PLUMBED, ALIGNED, AND BRACED SECURELY UNTIL PERMANENT ANCHORS ARE SET. AFTER WALL CONSTRUCTION IS COMPLETE, REMOVE TEMPORARY BRACES, LEAVING SURFACES SMOOTH AND UNDAMAGED.
- AT FIRE PROTECTION RATED OPENINGS, INSTALL FRAMES ACCORDING TO NFPA 80.
- HOLLOW METAL DOORS: FIT HOLLOW METAL DOORS ACCURATELY IN FRAMES, WITHIN CLEARANCES, SHIM AS NECESSARY TO ACHIEVE CLEARANCES INDICATED.
- FIRE-RATED DOORS: INSTALL DOORS WITH CLEARANCES ACCORDING TO NFPA 80.
- SMOKE CONTROL DOORS: INSTALL DOORS ACCORDING TO NFPA 105.
- SEE PLAN FOR PRODUCT SPECIFICATION AND LOCATION. FURNISH AND INSTALL ALL DOORS AND FRAMES AS INDICATED ON THE PLANS.

08 37 13 HIGH-SPEED CEILING DOORS

- A. INSTALL HIGH-SPEED CEILING DOORS AND OPERATING EQUIPMENT COMPLETE WITH NECESSARY HARDWARE, ANCHORS, INSERTS, HANGERS, AND EQUIPMENT SUPPORTS, ACCORDING TO MANUFACTURER'S WRITTEN INSTRUCTIONS AND AS SPECIFIED.
- B. PROVIDE ACTIVATION DEVICES AS INDICATED TO CONTROL DOOR.
- C. ADJUST HARDWARE AND MOVING PARTS TO FUNCTION SMOOTHLY SO THAT DOORS OPERATE EASILY, FREE OF WARP, TWIST, OR DISTORTION. LUBRICATE BEARINGS AND SLIDING PARTS AS RECOMMENDED BY MANUFACTURER.
- D. SEE PLAN FOR PRODUCT SPECIFICATION AND LOCATION. FURNISH AND INSTALL ALL DOORS AS INDICATED ON THE PLANS.

08 71 00 HARDWARE

- A. REQUIREMENTS:
- ALL LOCKSETS SHALL BE LEVER TYPE AS REQUIRED TO MEET REQUIREMENTS OF A.D.A.
 - ALL OTHER HARDWARE SHALL CONFORM TO THE REQUIREMENTS OF A.D.A.
 - ALL EXIST DOORS SHALL BE EQUIPPED WITH LEVER TYPE OR PANIC TYPE EXIT HARDWARE OPENABLE FROM THE INSIDE WITHOUT THE USE OF A LATCH, KEY OR BOLT.
 - CONTRACTOR TO COORDINATE KEYING SCHEDULE WITH OWNER.
 - DOOR HARDWARE MUST BE INSTALLED ON DOORS WITH HEIGHTS REQUIRED TO COMPLY WITH GOVERNING REGULATIONS.
 - INSTALL EACH DOOR HARDWARE ITEM TO COMPLY WITH MANUFACTURER'S WRITTEN INSTRUCTIONS.
 - THRESHOLDS: SET THE THRESHOLD FOR DOORS AND ACCOUTS FOR DOORS IN FULL BED OF SEALANT.
 - ADJUSTMENT: ADJUST AND CHECK EACH OPERATING ITEM OF DOOR HARDWARE AND EACH DOOR TO ENSURE PROPER OPERATION OR FUNCTION OF EVERY UNIT. REPLACE UNITS THAT CANNOT BE ADJUSTED TO OPERATE AS INTENDED. ADJUST DOOR HARDWARE DEVICES TO COMPLY WITH REQUIREMENTS FOR FINAL OPERATION OR FUNCTION. VENTILATING EQUIPMENT AND TO COMPLY WITH REFERENCED ACCESSIBILITY REQUIREMENTS.
 - SEE PLAN FOR PRODUCT SPECIFICATION AND LOCATION. FURNISH AND INSTALL ALL HARDWARE AS INDICATED ON THE PLAN.

DIVISION 09 FINISHES

 
09 01 00 FINISHES

- A. REQUIREMENTS:
- PROVIDE AND INSTALL ALL FINISHES AS INDICATED ON PLANS.
 - INSTALL ALL MATERIALS PER MANUFACTURER'S RECOMMENDATIONS AND SPECIFICATIONS.
 - "FINISH" INSTALLER INSPECT SUBSURFACE AND PREPARE AS PER MANUFACTURER'S SPECIFICATIONS PRIOR TO INSTALLATION OF PRODUCT.
 - FINISHES TO MEET ALL CODE REQUIREMENTS AND REGULATIONS INCLUDING FLAME SPREAD AND SMOKE DEVELOPMENT.
- B. EXTRA MATERIAL:
- PROVIDE NEW, EXTRA MATERIAL OF EACH FINISH TYPE AND COLOR TO BE TURNED OVER TO OWNER AT JOB COMPLETION FOR THE FOLLOWING ITEMS:
 - PANIC: PROVIDE 1 GALLON FOR FIELD COLORS AND 1 QUART FOR ACCENT COLORS APPLIED.

09 10



FIRST FLOOR DEMOLITION PLAN - AREA OF WORK



SYMBOLS LEGEND


- EXISTING WALL TO REMAIN
- EXISTING WALL TO BE DEMOLISHED
- (1) HOUR FIRE RATED
- (2) HOUR FIRE RATED
- (3) HOUR FIRE RATED
- (4) HOUR FIRE RATED
- SEE PLAN FOR ALL WALL WIDTHS
- EXISTING DOOR TO REMAIN
- EXISTING DOOR TO BE DEMOLISHED
- EXISTING DOOR TO BE RELOCATED - SEE FLOOR PLAN FOR NEW LOCATION

GENERAL NOTES

- NOTIFY EXCEL ENGINEERING OF ANY DISCREPANCIES BETWEEN EXISTING PLANS AND FIELD CONDITIONS BEFORE REMOVAL.
- REVIEW WITH THE OWNER WHICH ITEMS ARE TO BE TURNED OVER TO THE OWNER BEFORE STARTING DEMOLITION WORK. REMOVE ANY ITEM NOT WANTED BY THE OWNER AND DISPOSE OF IN THE PROPER AND LEGAL MANNER.
- REMOVE ALL WALLS SHOWN RED. NOTIFY EXCEL ENGINEERING IF ANY OF THE WALLS ARE FOUND TO BE LOAD BEARING BEFORE REMOVAL.
- REMOVE ALL DOORS SHOWN RED INCLUDING FRAME AND ALL HARDWARE AND ACCESSORIES.
- REMOVE ALL WINDOWS SHOWN OR RED INCLUDING FRAME AND SILLS.
- REMOVE ALL MISC ITEMS SHOWN RED.
- CUT WALLS FOR INSTALLATION OF NEW ELECTRICAL RECEPTACLE AND SWITCH BOXES AND ASSOCIATED CONDUITS. SEE ELECTRICAL PLANS FOR LOCATIONS.
- CUT WALLS FOR INSTALLATION OF NEW BLOCKING OR BACKING IN EXISTING WALLS.
- NOT ALL NEW OPENINGS FOR MEP WORK ARE SHOWN IN WALLS AND FLOORS. PROVIDE ADDITIONAL OPENINGS NOT SHOWN FOR WORK.
- PROVIDE TEMPORARY ENCLOSURES FOR KEEPING THE FACILITY IN OPERATION DURING CONSTRUCTION. ENCLOSURE SHALL BE A WALLED-IN DUST BARRIER (WATERPROOF WHERE EXPOSED TO THE EXTERIOR). PROVIDE MEP WORK TO KEEP THE FACILITY OPERATIONAL. SPRINKLER CONTRACTOR SHALL REVIEW CONSTRUCTION SEQUENCING AND TEMPORARY WALLS WITH GENERAL CONTRACTOR AND MAINTAIN SPRINKLER COVERAGE IN EXISTING AREAS THROUGHOUT CONSTRUCTION. SEE PLAN FOR ENCLOSURE LOCATIONS.
- MAINTAIN REQUIRED EGRESS PATHS AND SAFETY PRECAUTIONS FOR CONSTRUCTION IN EXISTING OCCUPIED BUILDING.

DEMO PLAN KEYNOTES

- 1 REMOVE EXISTING WALL PANEL & GIRTS AS REQUIRED FOR NEW OPENING - SEE FLOOR PLAN FOR SIZE & LOCATION
- 2 REMOVE EXISTING CONCRETE CURB AS REQUIRED FOR NEW CONSTRUCTION.

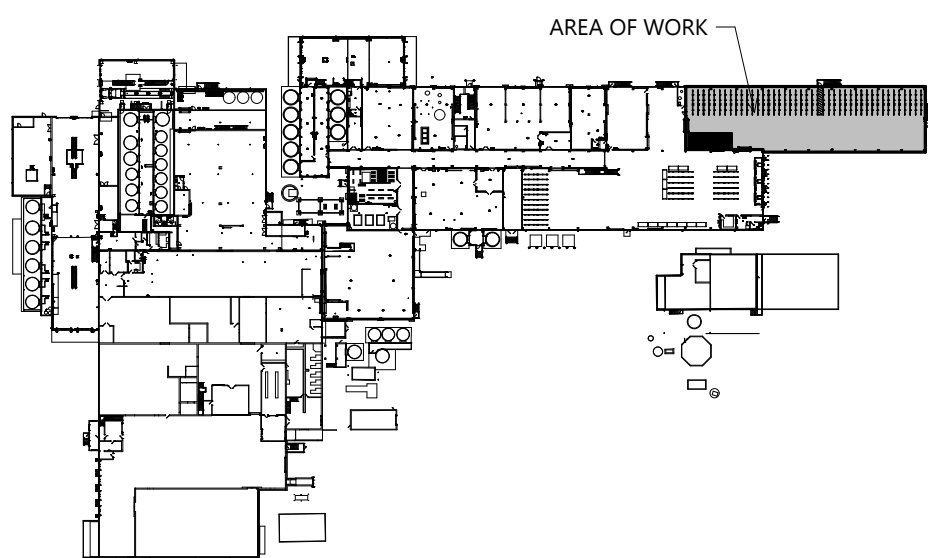

KEY PLAN

EXCEL
Always a Better Plan
100 Camelot Drive
Fond du Lac, WI 54935
920-926-9800
excelengineer.com

PROJECT INFORMATION

STORAGE WAREHOUSE EXPANSION FOR:
WEST POINT DAIRY PRODUCTS
570 NORTH 500 WEST • HYRUM, UT 84319

PROFESSIONAL SEAL

SHEET DATES

ISSUED FOR BUDGET
IFB APR. 17, 2026

JOB NUMBER

250429500

SHEET NUMBER

AD1.1

ARCHITECTURAL FIRST FLOOR DEMOLITION PLAN - AREA OF WORK

NOT FOR CONSTRUCTION



STORAGE WAREHOUSE EXPANSION FOR:
WEST POINT DAIRY PRODUCTS
570 NORTH 500 WEST • HYRUM, UT 84319

NOT FOR CONSTRUCTION

ISSUED FOR BUDGET

IFB APR. 17, 2026

250429500

AD1.3


- * NOTIFY ELEC. ENGINEERING OF ANY DISCREPANCIES BETWEEN EXISTING PLANS AND FIELD CONDITIONS BEFORE STARTING WORK.
- * REVIEW WITH THE OWNER WHICH ITEMS ARE TO BE TURNED OVER TO THE OWNER BEFORE STARTING CONSTRUCTION. ITEMS TO BE TURNED OVER MUST BE IDENTIFIED BY THE OWNER AND DISPOSED OF IN THE PROPER AND LEGAL MANNER.
- * REMOVE ALL WOODS SHOWN RED. NOTIFY ELEC. ENGINEERING IF ANY OF THE WOODS ARE FOUND TO BE LOAD BEARING BEFORE REMOVAL.
- * REMOVE ALL DOORS SHOWN RED INCLUDING FRAME AND SILL.
- * REMOVE ALL WINDOWS SHOWN RED INCLUDING FRAME AND SILL.
- * REMOVE ALL MUSIC ITEMS SHOWN RED.
- * CUT WALLS FOR INSTALLATION OF NEW ELECTRICAL RECEPTACLE AND SWITCH BOXES AND ASSOCIATED CONDUITS. SEE ELECTRICAL PLANS FOR LOCATIONS.
- * REMOVE ALL PARTS OF EXISTING NEW FLOORING OR BACKING IN EXISTING WALLS.
- * NOT ALL NEW OPENINGS FOR MEP WORK ARE SHOWN IN THIS SET OF PLANS. PROVIDE ADDITIONAL OPENINGS NOT SHOWN FOR WORK.
- * PROVIDE TEMPORARY ENCLOSURES FOR KEEPING THE WORK AREA DRY DURING CONSTRUCTION. EACH ENCLOSURE SHALL BE A WALLED-IN DUST BARRIER WATERPROOF WHEN EXPOSED TO THE EXTERIOR. PROVIDE A DRAINAGE SYSTEM FOR EACH ENCLOSURE. THE SPRINKLER CONTRACTOR SHALL REVIEW CONSTRUCTION SEQUENCING AND TEMPORARY WALLS WITH GENERAL CONTRACTOR AND MAINTAIN SPRINKLER COVERAGE IN EXISTING AREAS OF THE BUILDING. SEE PLAN FOR ENCLOSURE LOCATIONS.
- * MAINTAIN REQUIRED GREEN PATHS AND SIGHTS.
- * PREPARE DETAILS FOR CONSTRUCTION IN EXISTING OCCUPIED BUILDING.

3 REMOVE EXISTING TRIM & MODIFY TOP OF WALL AS REQUIRED TO TIE THE NEW ROOF WITH THE EXISTING ROOF.




ROOF DEMOLITION PLAN - AREA OF WORK

SCALE: $1/8" = 1'-0"$




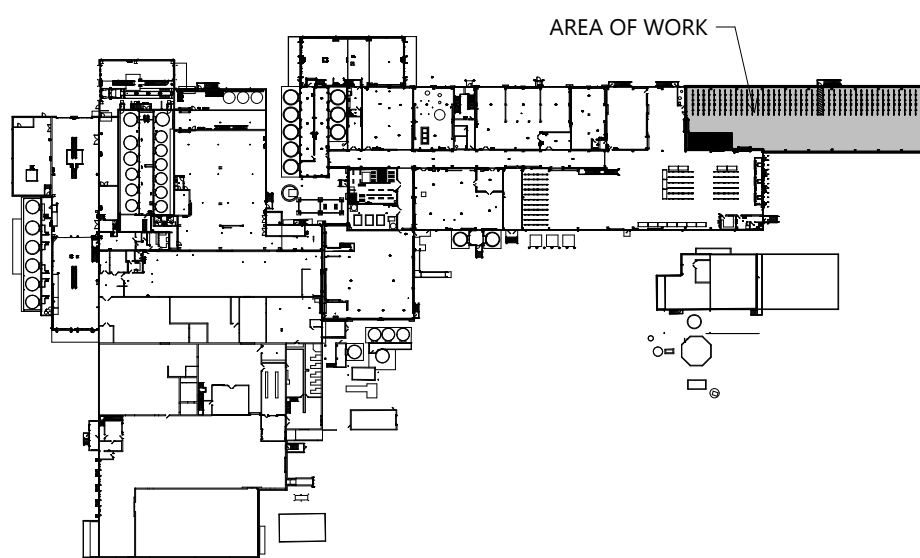


KEY PLAN

ARCHITECTURAL ROOF DEMOLITION PLAN - AREA OF WORK

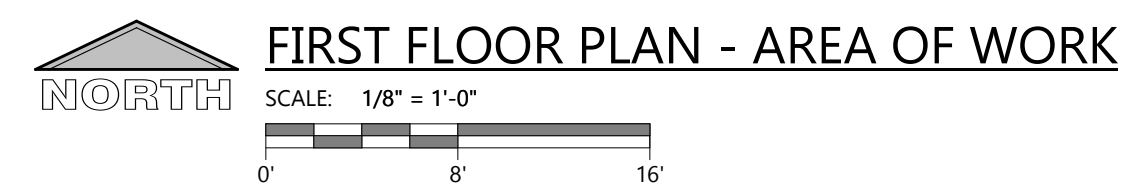

SYMBOLS LEGEND

    - | | |
|---|--|
|  | <p>EXTERIOR WALL TYPE</p> <ul style="list-style-type: none"> • SEE A4 SHEETS FOR WALL TYPES |
|  | <p>INTERIOR WALL TYPE</p> <ul style="list-style-type: none"> • SEE A4 SHEETS FOR WALL TYPES |
|  | <p>PRECAST WALL TYPE</p> <ul style="list-style-type: none"> • SEE A4 SHEETS FOR WALL TYPES |
|  | <p>IMP WALL TYPE</p> <ul style="list-style-type: none"> • SEE A4 SHEETS FOR WALL TYPES |
|  | <p>FIRE RATED WALL TYPE</p> <ul style="list-style-type: none"> • SEE A4 SHEETS FOR WALL TYPES |
|  | <p>SEE SHEET AXX
FOR CURB DETAILS</p> |
|  | <p>EXIT SIGNAGE</p> |
|  | <p>FIRE EXTINGUISHER</p> <ul style="list-style-type: none"> • SEE A5 SHEETS |
|  | <p>FIRE EXTINGUISHER w/ CABINET</p> <ul style="list-style-type: none"> • SEE A5 SHEETS |
|  | <p>GUARD POST/IGOL POST DESIGNATION</p> <ul style="list-style-type: none"> • SEE SHEET A6-X FOR DETAILS |
|  | <p>EXISTING WALL TO REMAIN</p> |
|  | <p>EXISTING WALL TO BE DEMOLISHED</p> |
|  | <p>STUD WALL</p> |
|  | <p>CONCRETE WALL</p> |
|  | <p>MASONRY VENEER</p> |
|  | <p>C.M.U. WALL</p> |
-
- | | |
|---|------------------------|
|  | (1) HOUR
FIRE RATED |
|  | (2) HOUR
FIRE RATED |
|  | (3) HOUR
FIRE RATED |
|  | (4) HOUR
FIRE RATED |
- SEE PLAN FOR ALL WALL WIDTHS
-
- | | |
|---|----------------------------|
|  | EXISTING DOOR
TO REMAIN |
|  | NEW DOOR |

GENERAL NOTES

- PATCH WALLS AT REMOVAL AND CONNECTION POINTS TO MATCH ADJACENT FINISHES.
- PATCH WALLS AND FLOOR TO MATCH EXISTING MATERIALS AND FINISHES WHERE REMOVAL OF EXISTING CONSTRUCTION OR FINISH LEAVES DAMAGED/UNFINISHED SURFACES.
- NOT ALL LINELINE OF OPENINGS AND PATCHING ARE SHOWN. INFILL ALL WALL OPENINGS TO MATCH EXISTING WALL CONSTRUCTION. PATCH ALL FLOOR OPENINGS TO MATCH EXISTING FLOOR FINISHES. CONDUIT, DUCTWORK, RECEPTACLES, SWITCHES, ETC. ARE REMOVED.
- PATCH WALLS TO MATCH EXISTING MATERIALS AND FINISH WHERE NEW ELECTRICAL BOXES AND CONDUITS ARE RECESSED/CONCEALED IN EXISTING WALLS. SEE ELECTRICAL PLANS FOR LOCATIONS.
- PATCH WALLS TO MATCH EXISTING MATERIALS AND FINISH WHERE NEW BLOCKING OR BACKING IS INSTALLED IN EXISTING WALLS.
- COORDINATE SCHEDULING OF WORK IN EXISTING OCCUPIED AREAS WITH OWNER. ACCESS TO AREAS DURING WORK HOURS IS DEPENDENT ON OWNER'S SCHEDULE.
- SEE SPECIFICATIONS FOR WORK BY OWNER. WORK BY OWNER SHOWN ON PLANS IS SUBJECT TO CHANGE. CONTRACTOR TO COORDINATE ALL SCHEDULING AND LOCATION REQUIREMENTS WITH OWNER/OWNER'S VENDOR.

FLOOR PLAN KEYNOTES

- | | |
|---|---|
| 1 | PAINT EPOXY YELLOW NO STORAGE STRIPE. VERIFY STRIPING
MOCKUP AND LAYOUT WITH OWNER. |
| 2 | PAINT HEAVY DUTY EPOXY WHITE WALL OFFSET STRIPE AT
PALLET STAGING. STRIPE SHALL BE 14" WIDE FROM FACE OF
CURB. VERIFY STRIPING MOCKUP AND LAYOUT WITH OWNER |
| 3 | RACKING PURCHASED AND INSTALLED BY OWNER |



PROJECT INFORMATION

STORAGE WAREHOUSE EXPANSION FOR:
WEST POINT DAIRY PRODUCTS
570 NORTH 500 WEST • HYRUM, UT 84319

PROFESSIONAL SEAL

SHEET DATES

ISSUED FOR BUDGET	
IFB	APR. 17, 2026

JOB NUMBER
250429500

SHEET NUMBER

A1.1

NOT FOR CONSTRUCTION

PROJECT INFORMATION

STORAGE WAREHOUSE EXPANSION FOR:
WEST POINT DAIRY PRODUCTS
570 NORTH 500 WEST • HYRUM, UT 84319

PROFESSIONAL SEAL

SHEET DATES

ISSUED FOR BUDGET
IFB APR. 17, 2026

JOB NUMBER
250429500

SHEET NUMBER

A1.3

ROOF LEGEND


- | | |
|------|---|
| RD | ROOF DRAIN |
| OFD | OVERFLOW DRAIN |
| DS | DOWNSPOUT |
| QFS | OVERFLOW SCUPPER |
| SB | SCUPPER BOX AND DOWNSPOUT |
| → | ROOF SLOPE DIRECTION |
| | ROOF STRUCTURE IS PITCHED TO ACHIEVE SLOPE |
| | TAPERED INSULATION AT MIN. 1/4" PER FOOT SLOPE UNLESS INDICATED OTHERWISE |
| | CRICKET ON HIGH SIDE OF ROOF EQUIPMENT |
| | WALKPATH. FIELD VERIFY WITH OWNER AND INSTALLED EQUIPMENT. |
| --- | CHANGE IN ROOFING SPEC |
| ---- | ROOF EXPANSION JOINT |

GENERAL ROOF NOTES:

- ROOFING CONTRACTOR SHALL PROVIDE MEMBRANE FORM FLASHING FOR ALL ROOF PENETRATIONS PER ROOF MEMBRANE MANUFACTURER'S REQUIREMENTS.
- SEE MECHANICAL DRAWINGS FOR LOCATION AND SIZE OF ALL ROOF PENETRATIONS AND CURBS REQUIRED FOR MECHANICAL EQUIPMENT.
- PIPE STANDS NOT INSTALLED ON CURBS SHALL BE INSTALLED ON SLEEPERS OR CONCRETE PADS 6" LARGER THAN EQUIPMENT.
- PROVIDE SINGLE PLY ROOFING MEMBRANE NOT ADHERED TO ROOF UNDER ALL FREE STANDING PIPE AND EQUIPMENT STANDS 6" LARGER THAN STANDS.
- PROVIDE WALKWAY FROM ROOF ACCESS TO ALL MOTORIZED EQUIPMENT AND SIDES OF EQUIPMENT REQUIRING ACCESS. PROVIDE PRICE PER FOOT. FIELD VERIFY.


ROOF PLAN KEYNOTES

- | | |
|----|---|
| 11 | CURB MOUNTED MECHANICAL EQUIPMENT. SEE "ROOF TOP EQUIPMENT CURB DETAIL" ON SHEET A1.4 |
|----|---|

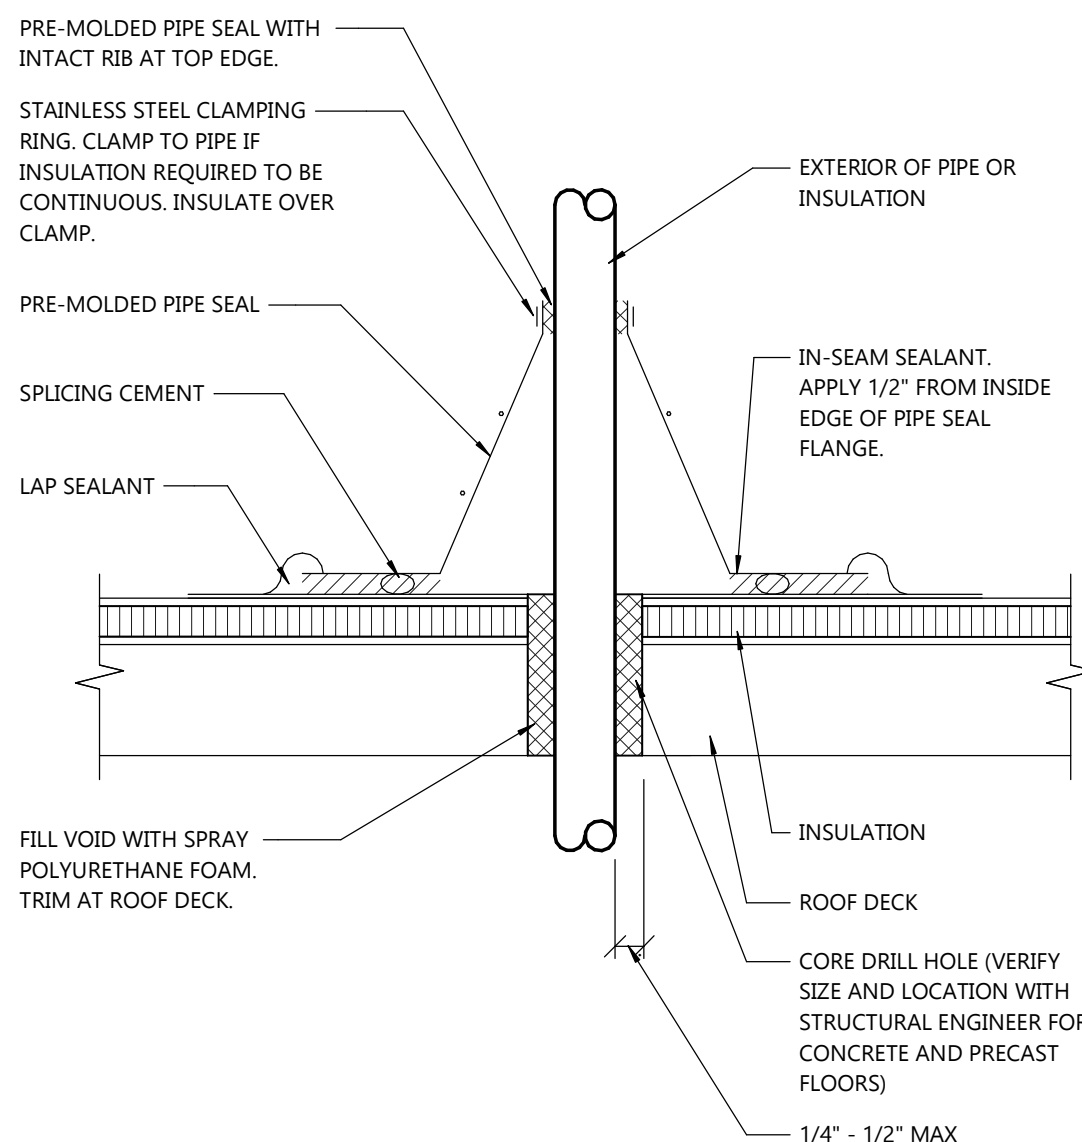


1 ROOF PIPE PENETRATION DETAIL

SCALE: 1 1/2" = 1'-0"

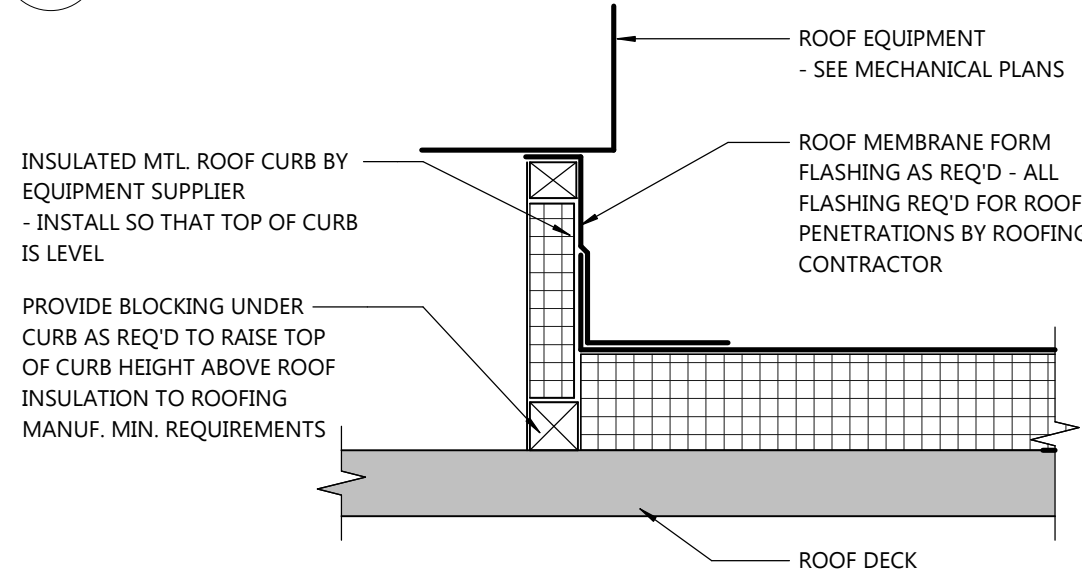


2 ROOF TOP EQUIPMENT CURB DETAIL

SCALE: 1 1/2" = 1'-0"

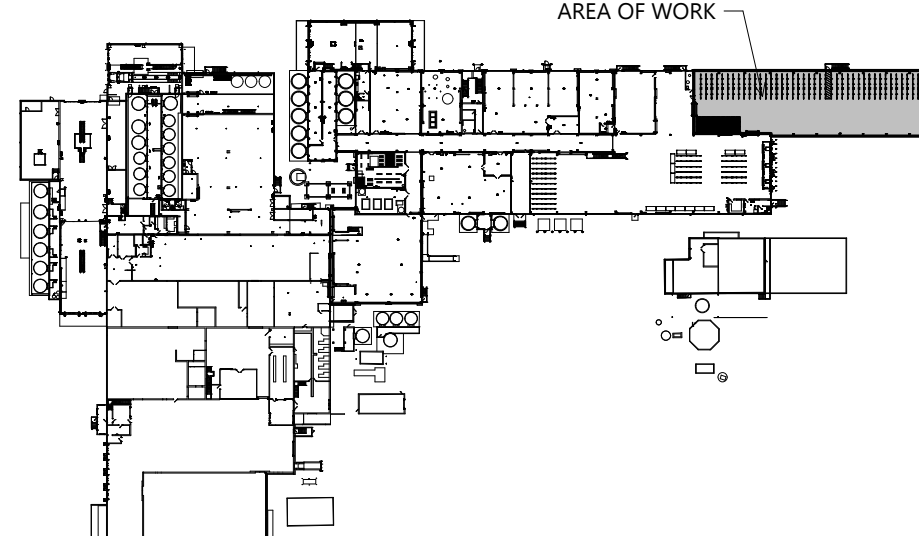


KEY PLAN

ARCHITECTURAL ROOF PLAN

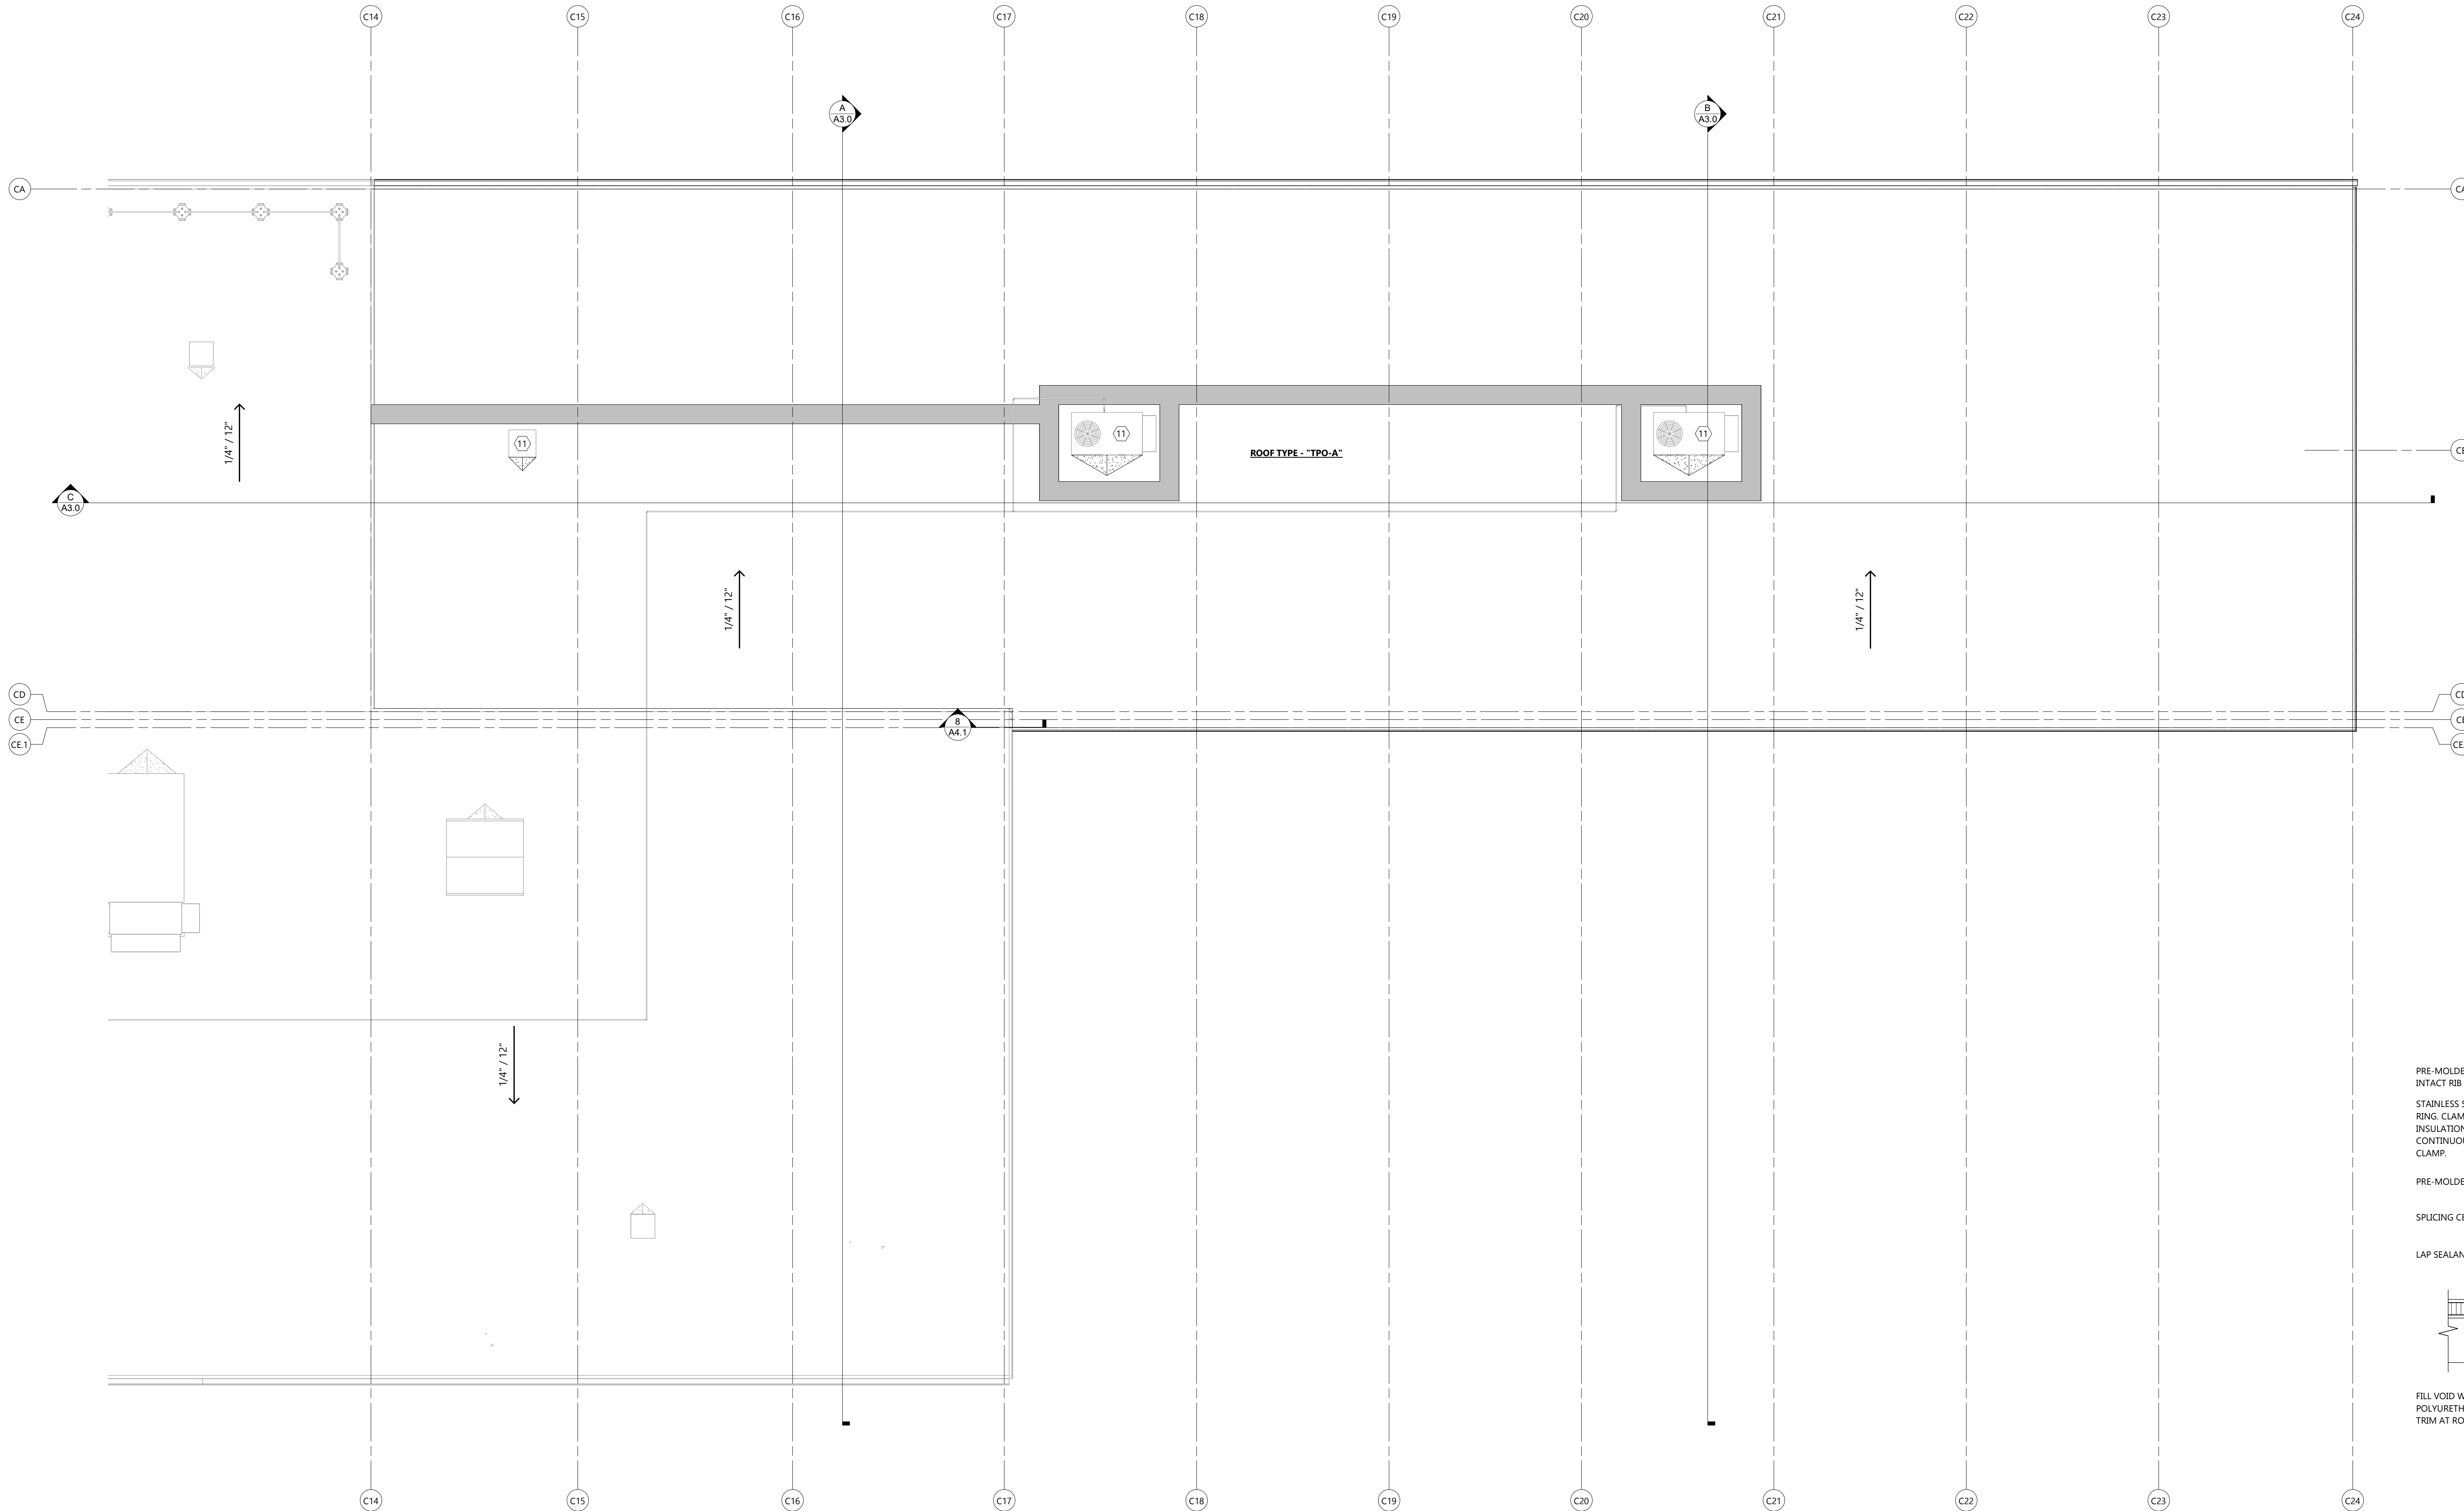

ROOF PLAN - AREA OF WORK

SCALE: 1/8" = 1'-0"

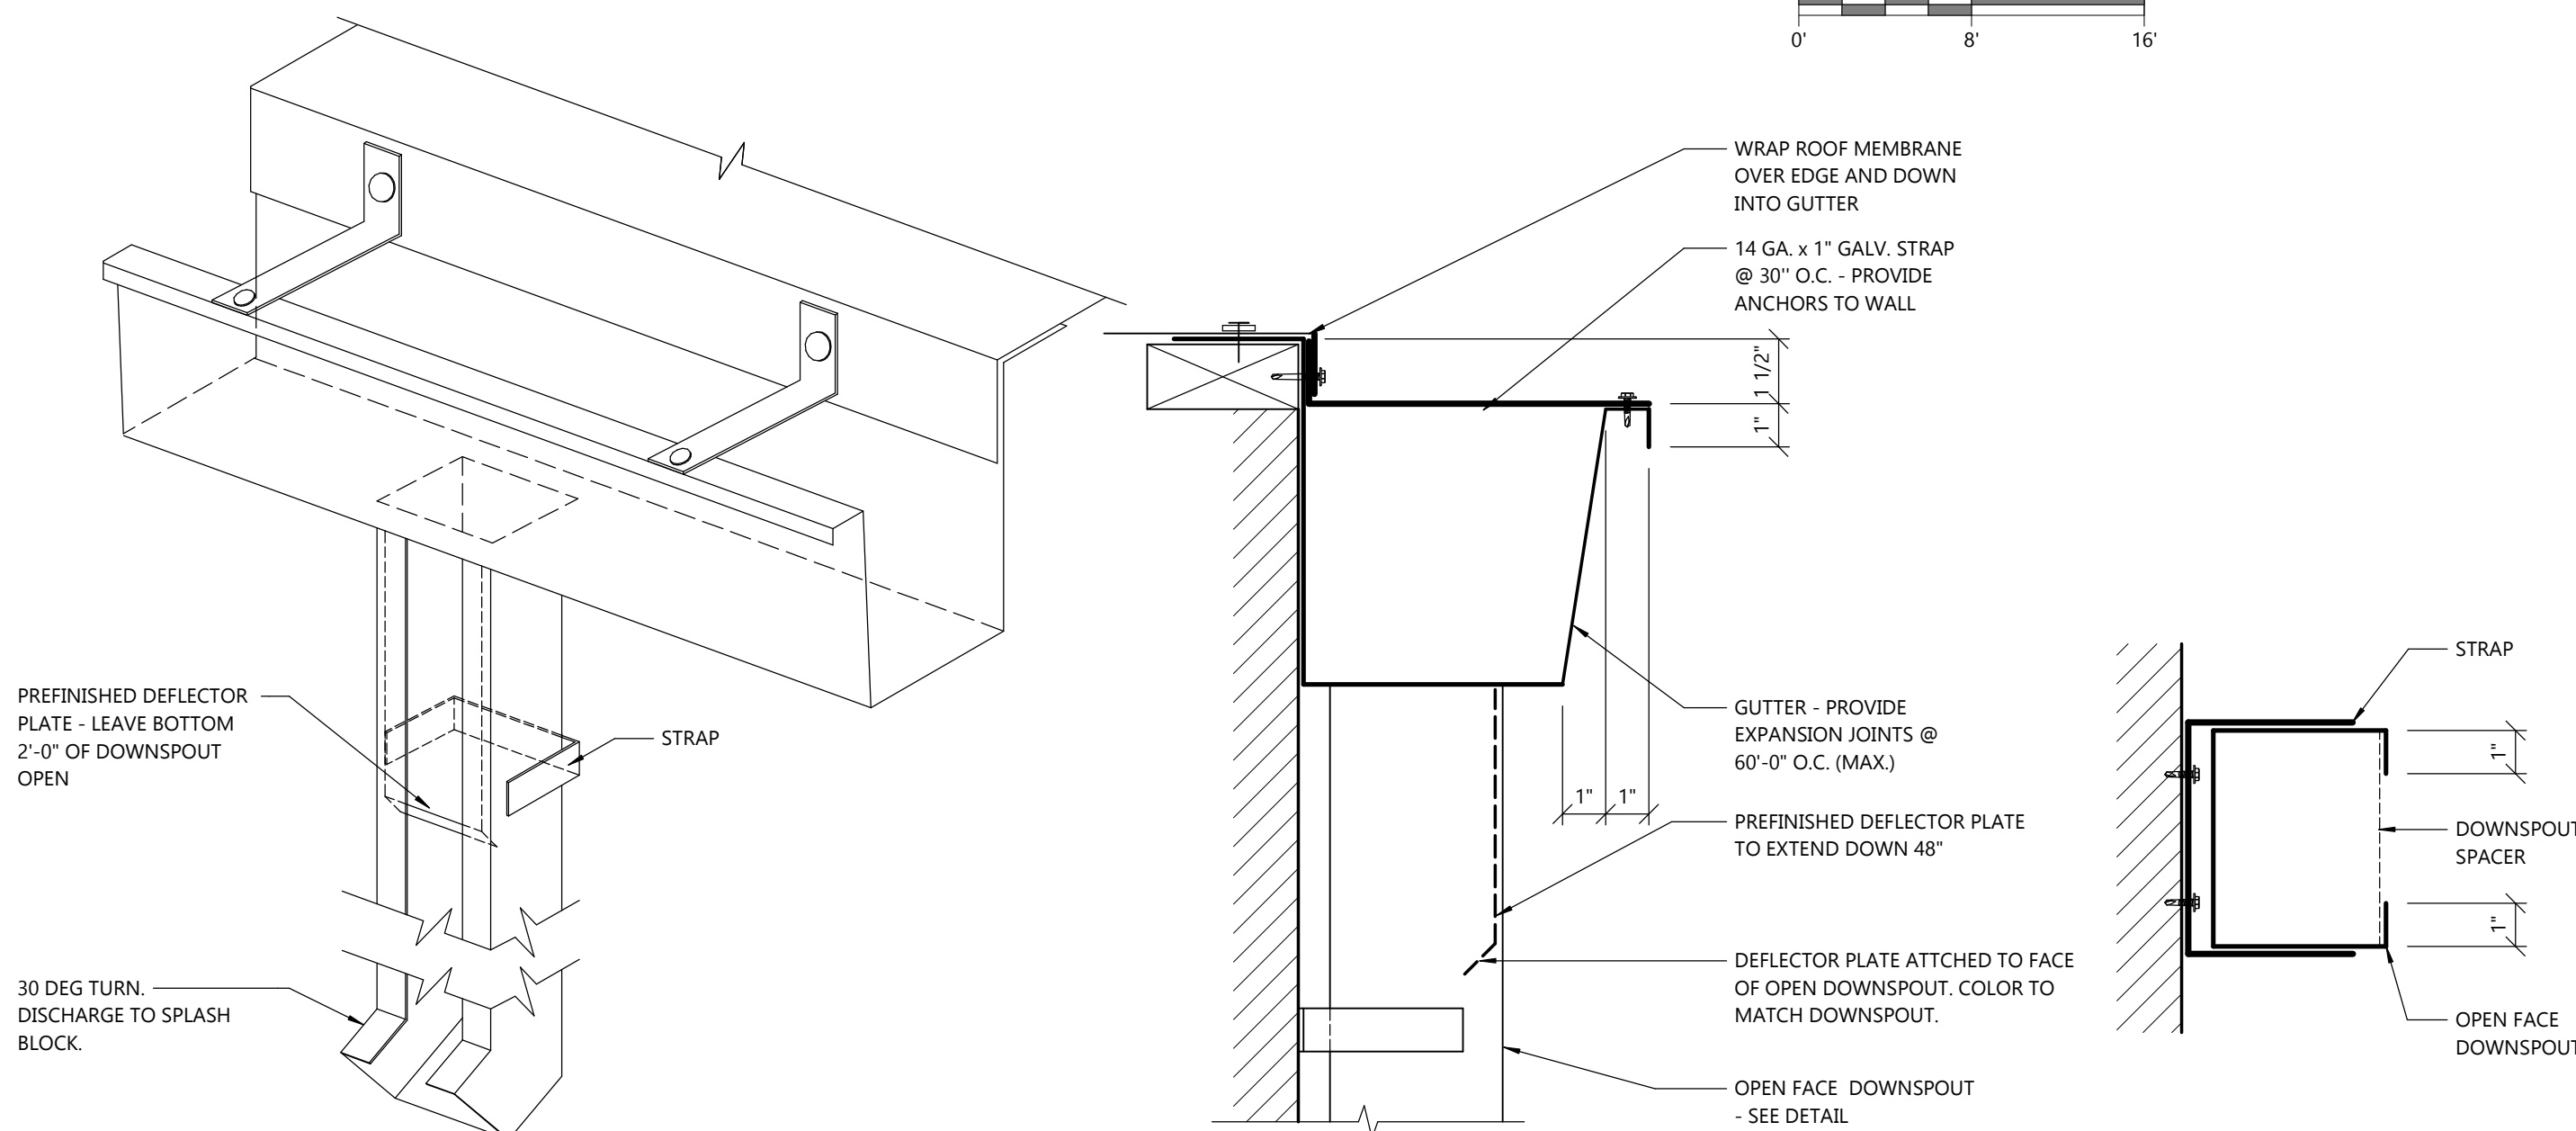

ISOMETRIC

GUTTER SECTION

DOWNSPOUT SECTION

3 GUTTER AND DOWNSPOUT DETAIL

SCALE: 3" = 1'-0"

ROOF SPECIFICATION
TYPE "TPO - A"

DECK	• METAL DECK
THERMAL BARRIER	• NONE
VAPOR MEMBRANE	• ROOF MEMBRANE MFR'S SELF-ADHERED VAPOR BARRIER MEMBRANE
INSULATION	• MINIMUM TWO LAYERS OF POLYISOCYANURATE (R-30) MOLD-RESISTANT PER ASTM D3273 / STAGGER JOINTS. • TAPERED INSULATION IS ADDITION TO LISTED R VALUE. • BASE LAYER MECH. FASTENED. SECOND LAYER FULLY ADHERED. • METAL DECK SHALL BE FULLY CLEANED AND OIL FREE PRIOR TO INSULATION INSTALLATION. FOLLOW ALL ADHESIVE AND INSULATION MFR'S RECOMMENDATION FOR CLEANING AND PREPARING METAL DECK. • ALL INSULATION JOINTS TO BE TIGHT.
TAPERED INSULATION	• WHERE SHOWN ON PLANS, 1/4" PER FOOT PERPENDICULAR TO VALLEY. POLYISOCYANURATE TO MATCH BASE INSULATION.
COVERBOARD	• NONE
MEMBRANE	• CARLSLE SURE-WELD, HOLCIM ELEVATE - ULTRAPLY, VERSICO - VERSIWELD • 60 MIL ADHERED WHITE THERMOPLASTIC POLYOLEFIN (TPO) • WELDED SEAMS • PROVIDE TPO WHITE WALKWAY ROLLS BY MEMBRANE MFR WITH RAISED TREAD PATTERN, WELD TO TPO ROOFING. • INSTALL PER MFRS INSTALLATION INSTRUCTIONS AND RECOMMENDATIONS. • PROVIDE 12" X 12" MEMBRANE SAMPLE WITH SHOP DRAWING SUBMITTAL. • AT CONTRACTOR OPTION, THE USE OF A FACTORY APPLIED ADHESIVE ACROSS ENTIRE SURFACE OF THE MEMBRANE ROLL IS ACCEPTABLE.
WARRANTY	• PROVIDE 15 YEAR TOTAL SYSTEM, LABOR AND MATERIAL WARRANTY, NO DOLLAR LIMIT FOR LEAKS, COMMENCING WITH THE DATE OF FINAL INSPECTION AND ACCEPTANCE BY ROOF MANUFACTURER. ALL PORTIONS OF ROOFING SYSTEM MUST MEET MFRS REQUIREMENTS FOR WARRANTY. • PROVIDE 2 YEAR CONTRACTORS WARRANTY ON MATERIALS (EXCLUDING MEMBRANE) AND WORKMANSHIP.

- SEE SPECIFICATIONS FOR ADDITIONAL REQUIREMENTS
- INSTALL MATERIALS IN ORDER OF LISTING FROM DECK TO MEMBRANE.

GUTTER & DOWNSPOUT SPECIFICATION

MANUFACTURER:
METAL-ERA, INC.

PRODUCT:
• SEAL TITE PRODUCT LINE

GUTTER:

- MATERIAL - 22 GAUGE GALVANIZED STEEL
- SIZE: 5" X 5"
- STYLE: INDUSTRIAL GUTTER IG-3 OR INDUSTRIAL GUTTER IG-8
- GUTTER HANGERS, EXTERNAL GUTTER BRACKET PER MANUFACTURERS RECOMMENDATIONS
- GUTTER ATTACHMENT SHALL MEET FM WIND UPLIFT PROTECTION.
- EXPANSION JOINTS TO BE FREE FLOW WITH COVER PLATE, SPACED AND INSTALLED PER MANUFACTURERS WRITTEN INSTALLATION INSTRUCTIONS.
- PROVIDE END CAPS AND ALL OTHER ACCESSORIES REQUIRED FOR A COMPLETE INSTALLATION


DOWNSPOUT:

- MATERIAL - 24 GAUGE GALVANIZED STEEL
- SIZE: 3" X 4" IN 12'-0" LENGTHS
- ATTACHMENT 14 GA. STRAPS STYLE 1 WITH A MINIMUM OF 3 STRAPS PER 12'-0" SECTION OF DOWNSPOUT
- OPEN FACE WITH SPACER, MINIMUM OF 3 PER 12'-0" SECTION OF DOWNSPOUT
- PROVIDE COLOR MATCHED INSERT
- PROVIDE ELBOWS AND ALL OTHER ACCESSORIES REQUIRED FOR A COMPLETE INSTALLATION


WARRANTY:

- 5 YEAR WARRANTY ON WORKMANSHIP COVERING REPLACEMENT OR REPAIR OF PRODUCTS THAT ARE DEFECTIVE IN MATERIAL OR WORKMANSHIP
- 20 YEAR TRANSFERABLE WARRANTY FOR PREFINISHED COIL-COATED STEEL COATED WITH KYNAR-500 STANDARD COLORS COVERING FADE, CHALK AND FILM INTEGRITY
- STARTING WITH DATE OF FINAL INSPECTION AND ACCEPTANCE.


NOT FOR CONSTRUCTION

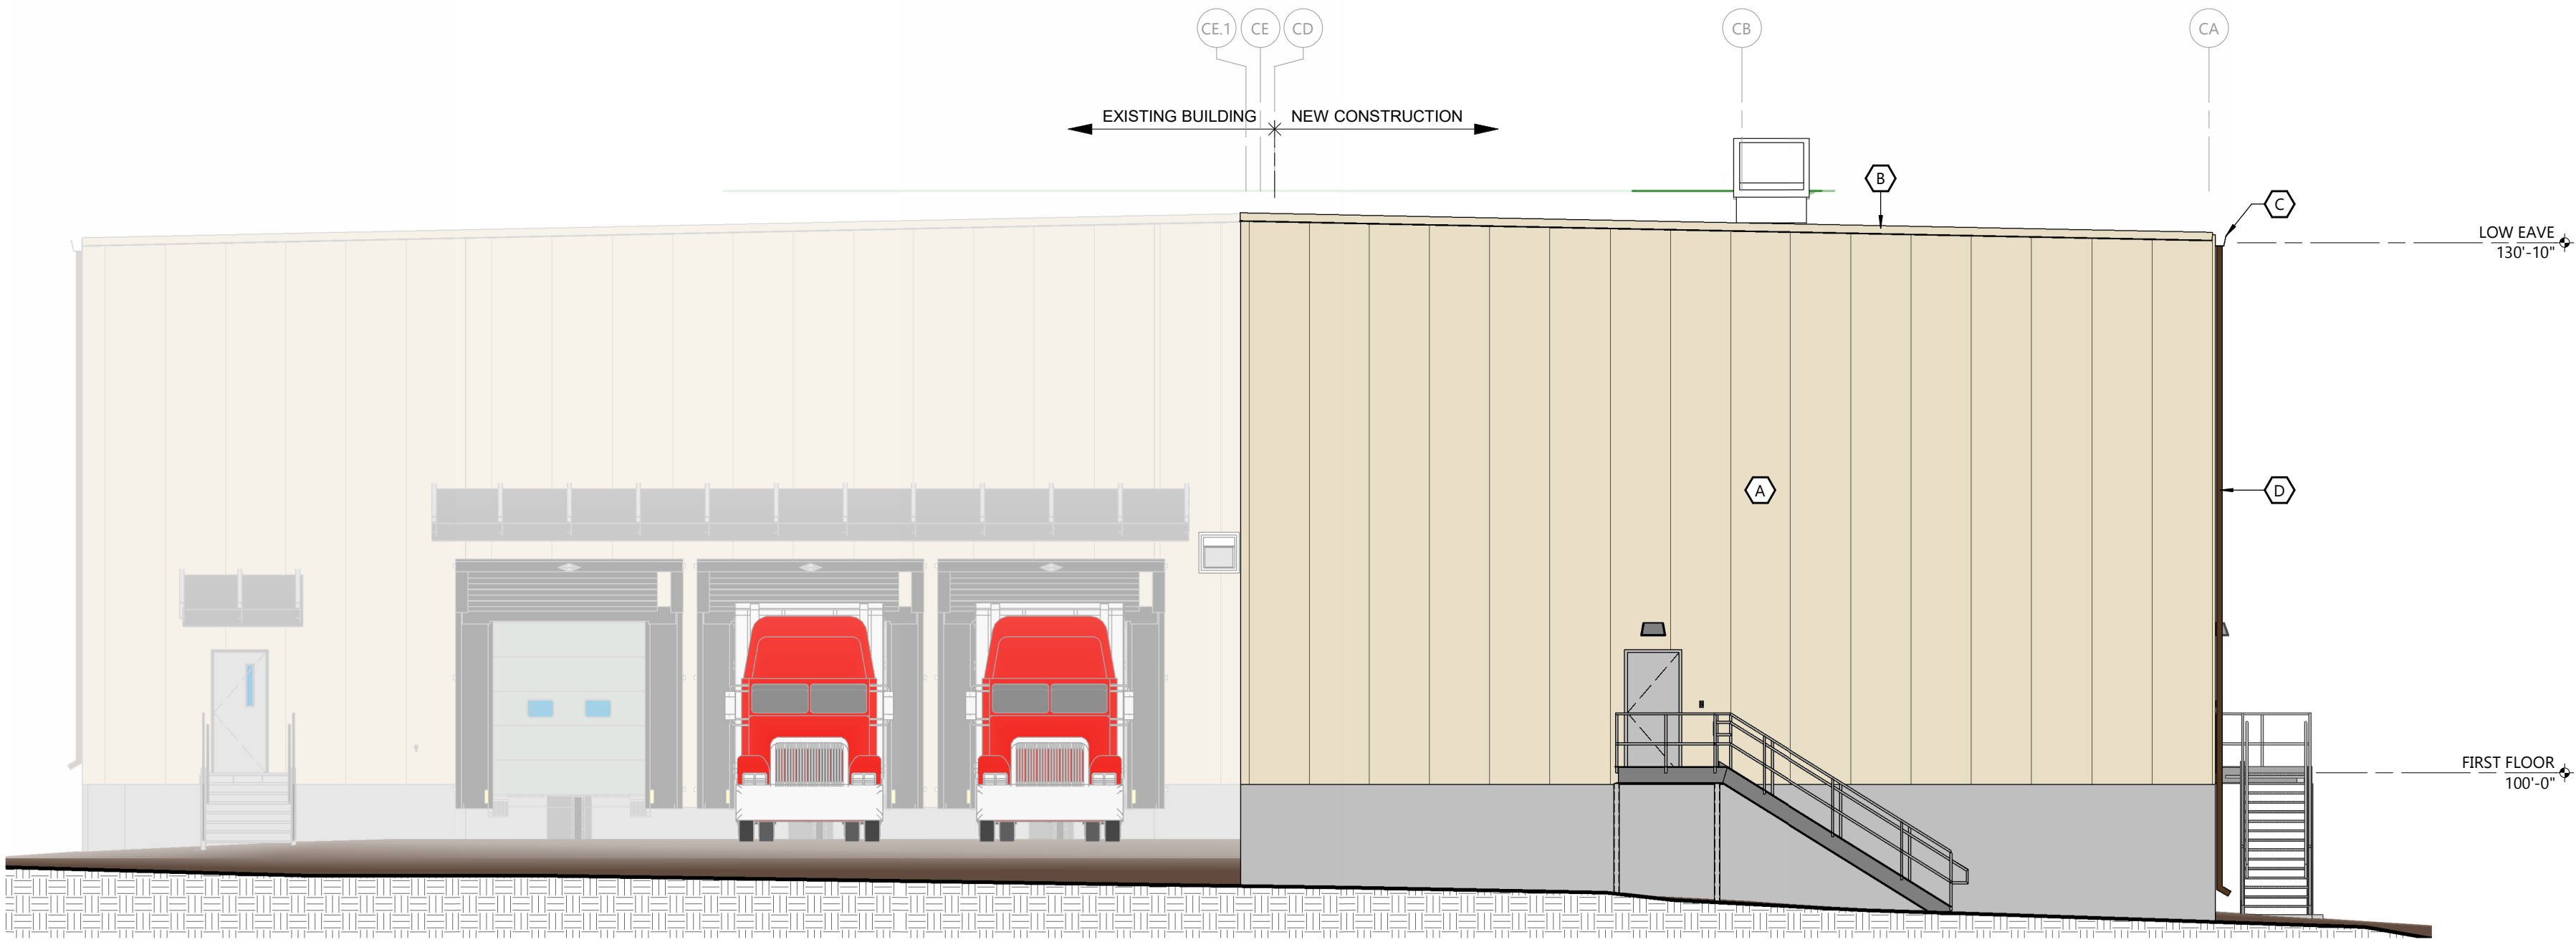

EAST ELEVATION
SCALE: 1/8" = 1'-0"

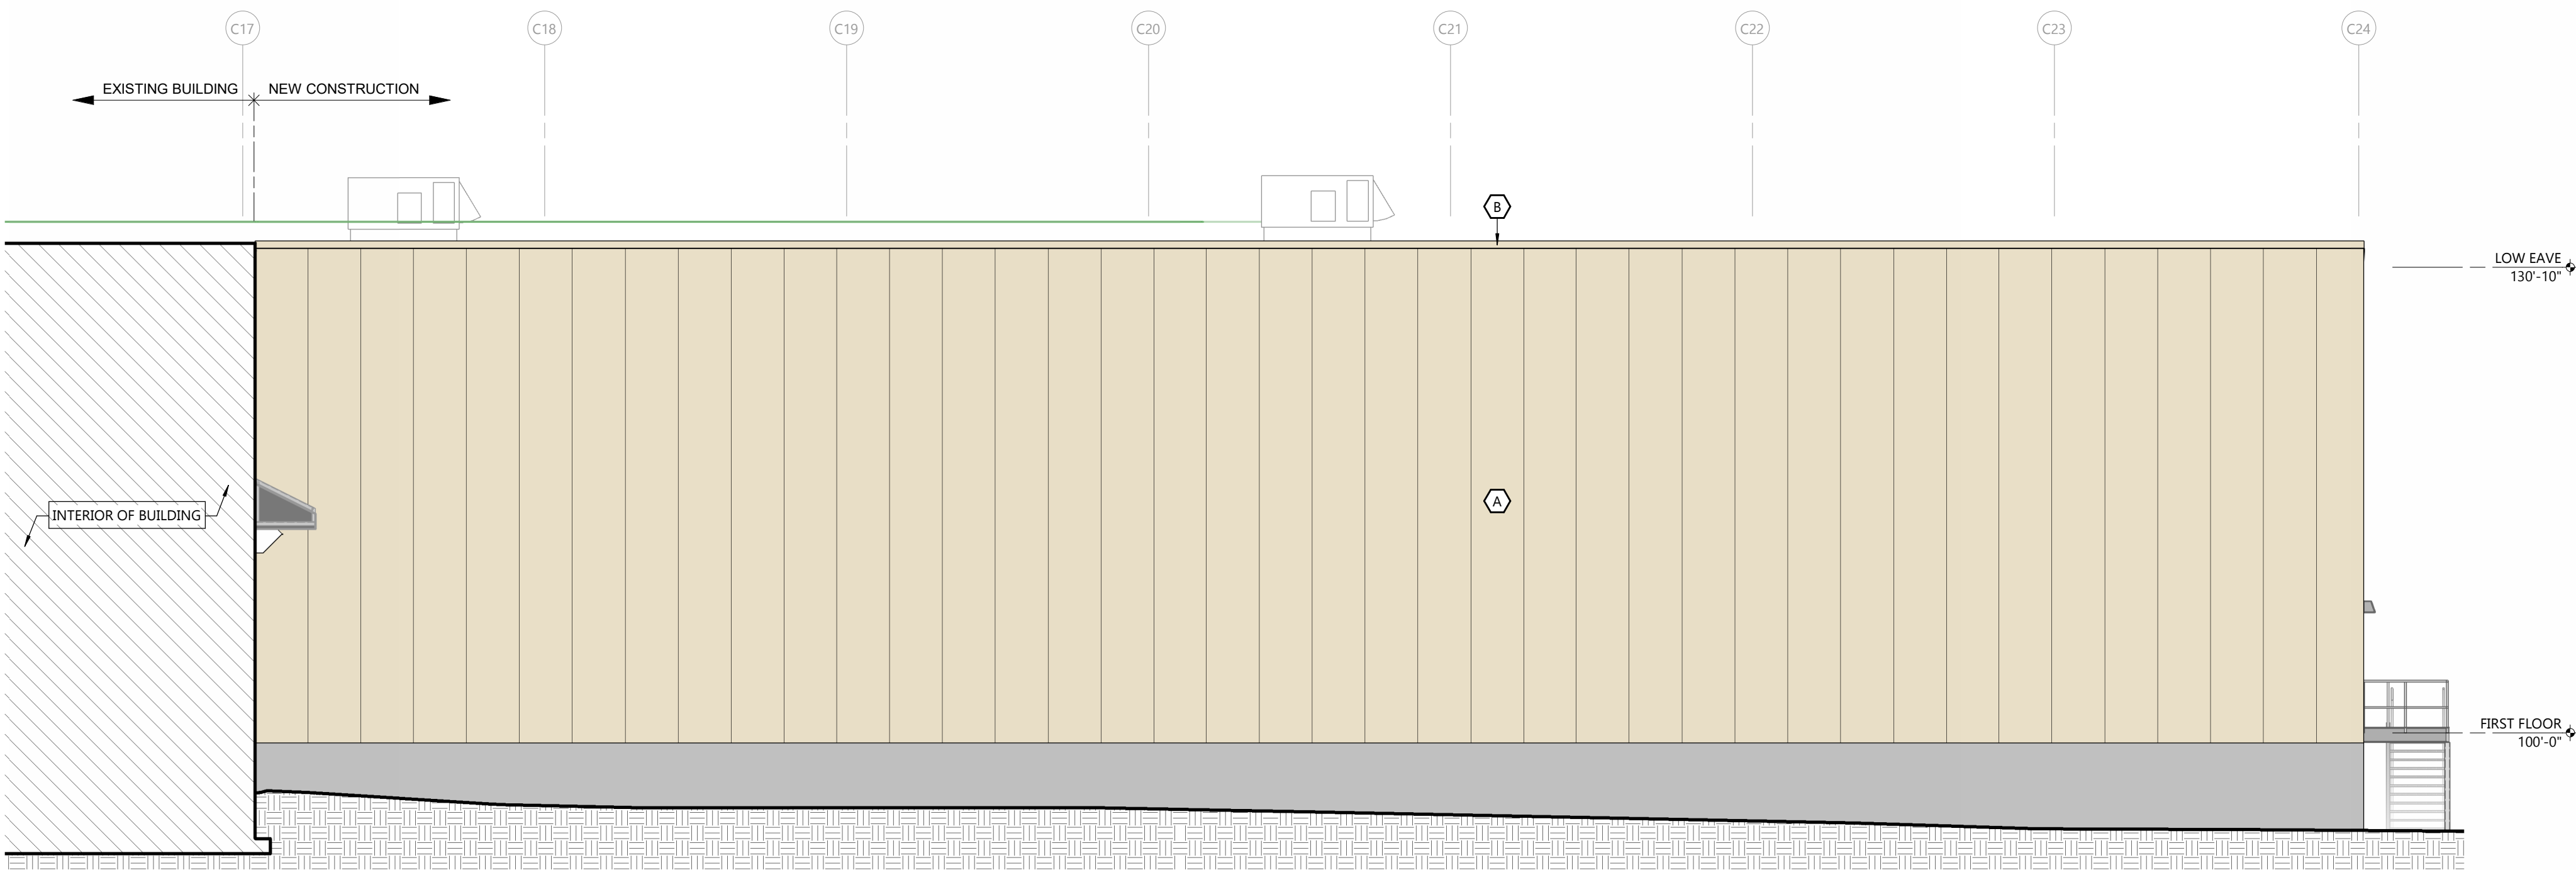

SOUTH ELEVATION
SCALE: 1/8" = 1'-0"

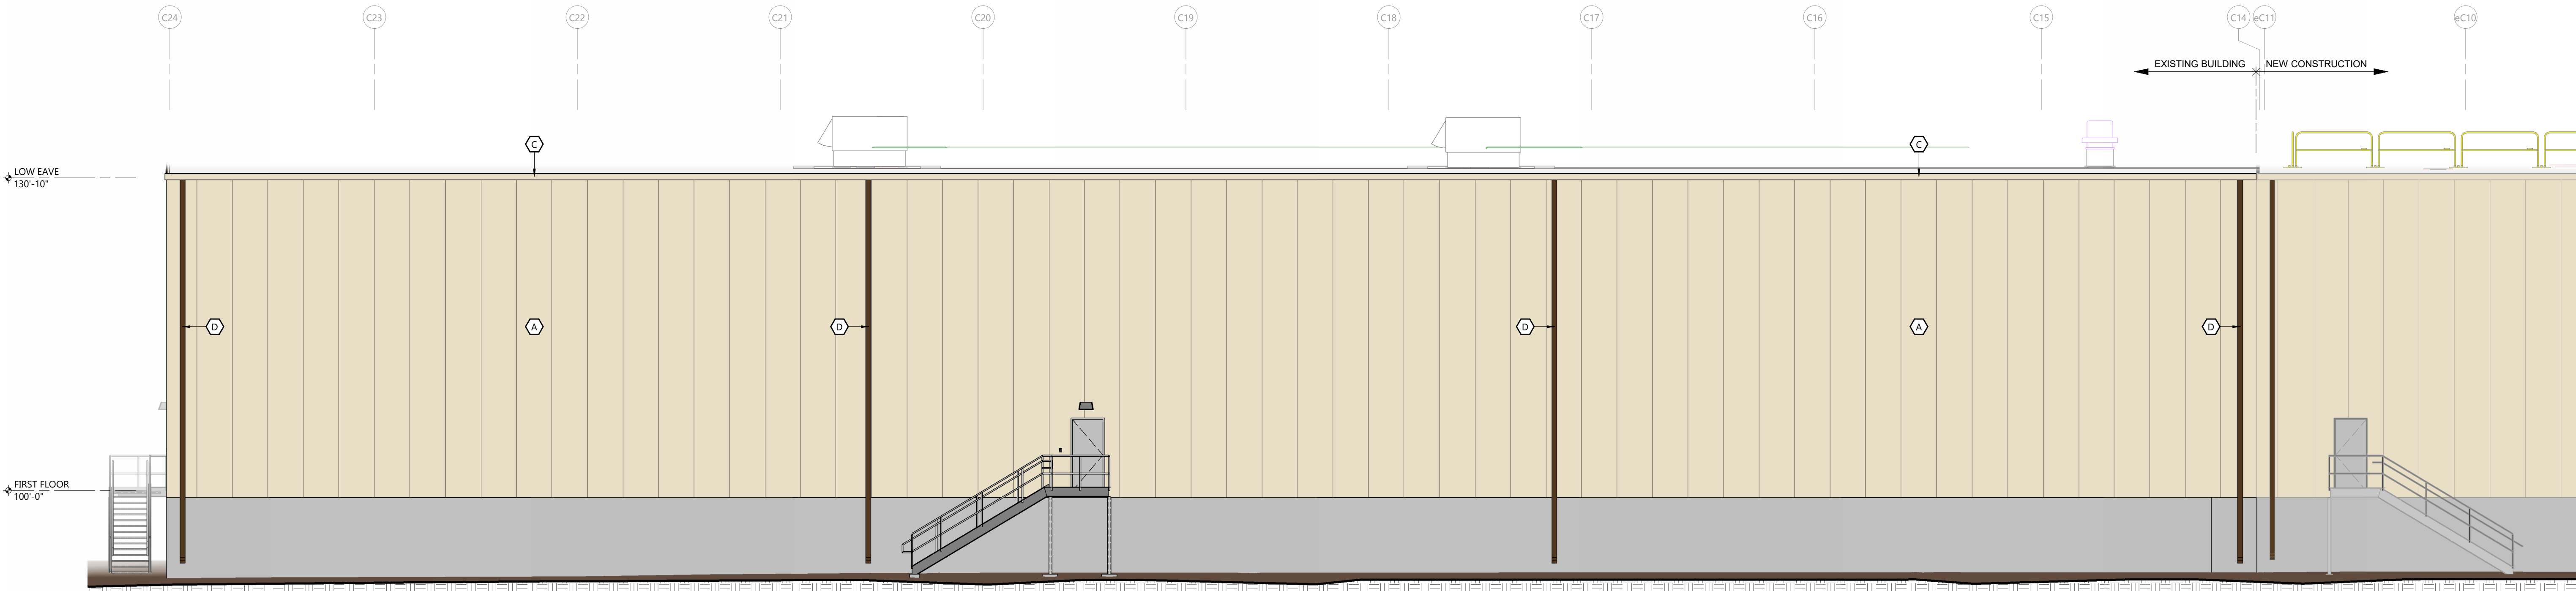

NORTH ELEVATION
SCALE: 1/8" = 1'-0"

GENERAL NOTES

1. SEE WALL SECTIONS FOR EXTERIOR WALL CONSTRUCTION

2. REFERENCE EXTERIOR ELEVATIONS FOR VENEER CONTROL JOINTS. SEE STRUCTURAL PLANS FOR CMU CONTROL JOINT LOCATIONS. VENEER CONTROL JOINTS AND CMU CONTROL JOINTS ARE NOT REQUIRED TO ALIGN.

EXTERIOR MATERIAL KEY

- INSULATED METAL PANEL (CLADDING)**
METL SPAN
CF MESA
COLOR: MATCH EXISTING
- PRE-FINISHED METAL TRIM**
COLOR: MATCH EXISTING
- PRE-FINISHED METAL GUTTER**
COLOR: MATCH EXISTING
- PRE-FINISHED METAL DOWNSPOUT**
COLOR: MATCH EXISTING



Always a Better Plan
100 Camelot Drive
Fond du Lac, WI 54935
920-926-9800
excelengineer.com

PROJECT INFORMATION

STORAGE WAREHOUSE EXPANSION FOR:
WEST POINT DAIRY PRODUCTS
570 NORTH 500 WEST • HYRUM, UT 84319

PROFESSIONAL SEAL

SHEET DATES

ISSUED FOR BUDGET

IFB APR. 17, 2026

JOB NUMBER

250429500

SHEET NUMBER

A2.0

ARCHITECTURAL EXTERIOR ELEVATIONS

NOT FOR CONSTRUCTION

PROJECT INFORMATION


STORAGE WAREHOUSE EXPANSION FOR:
WEST POINT DAIRY PRODUCTS
570 NORTH 500 WEST • HYRUM, UT 84319

PROFESSIONAL SEAL


SHEET DATES	
ISSUED FOR BUDGET	
IFB	APR. 17, 2026

JOB NUMBER
250429500


SHEET NUMBER
A3.0

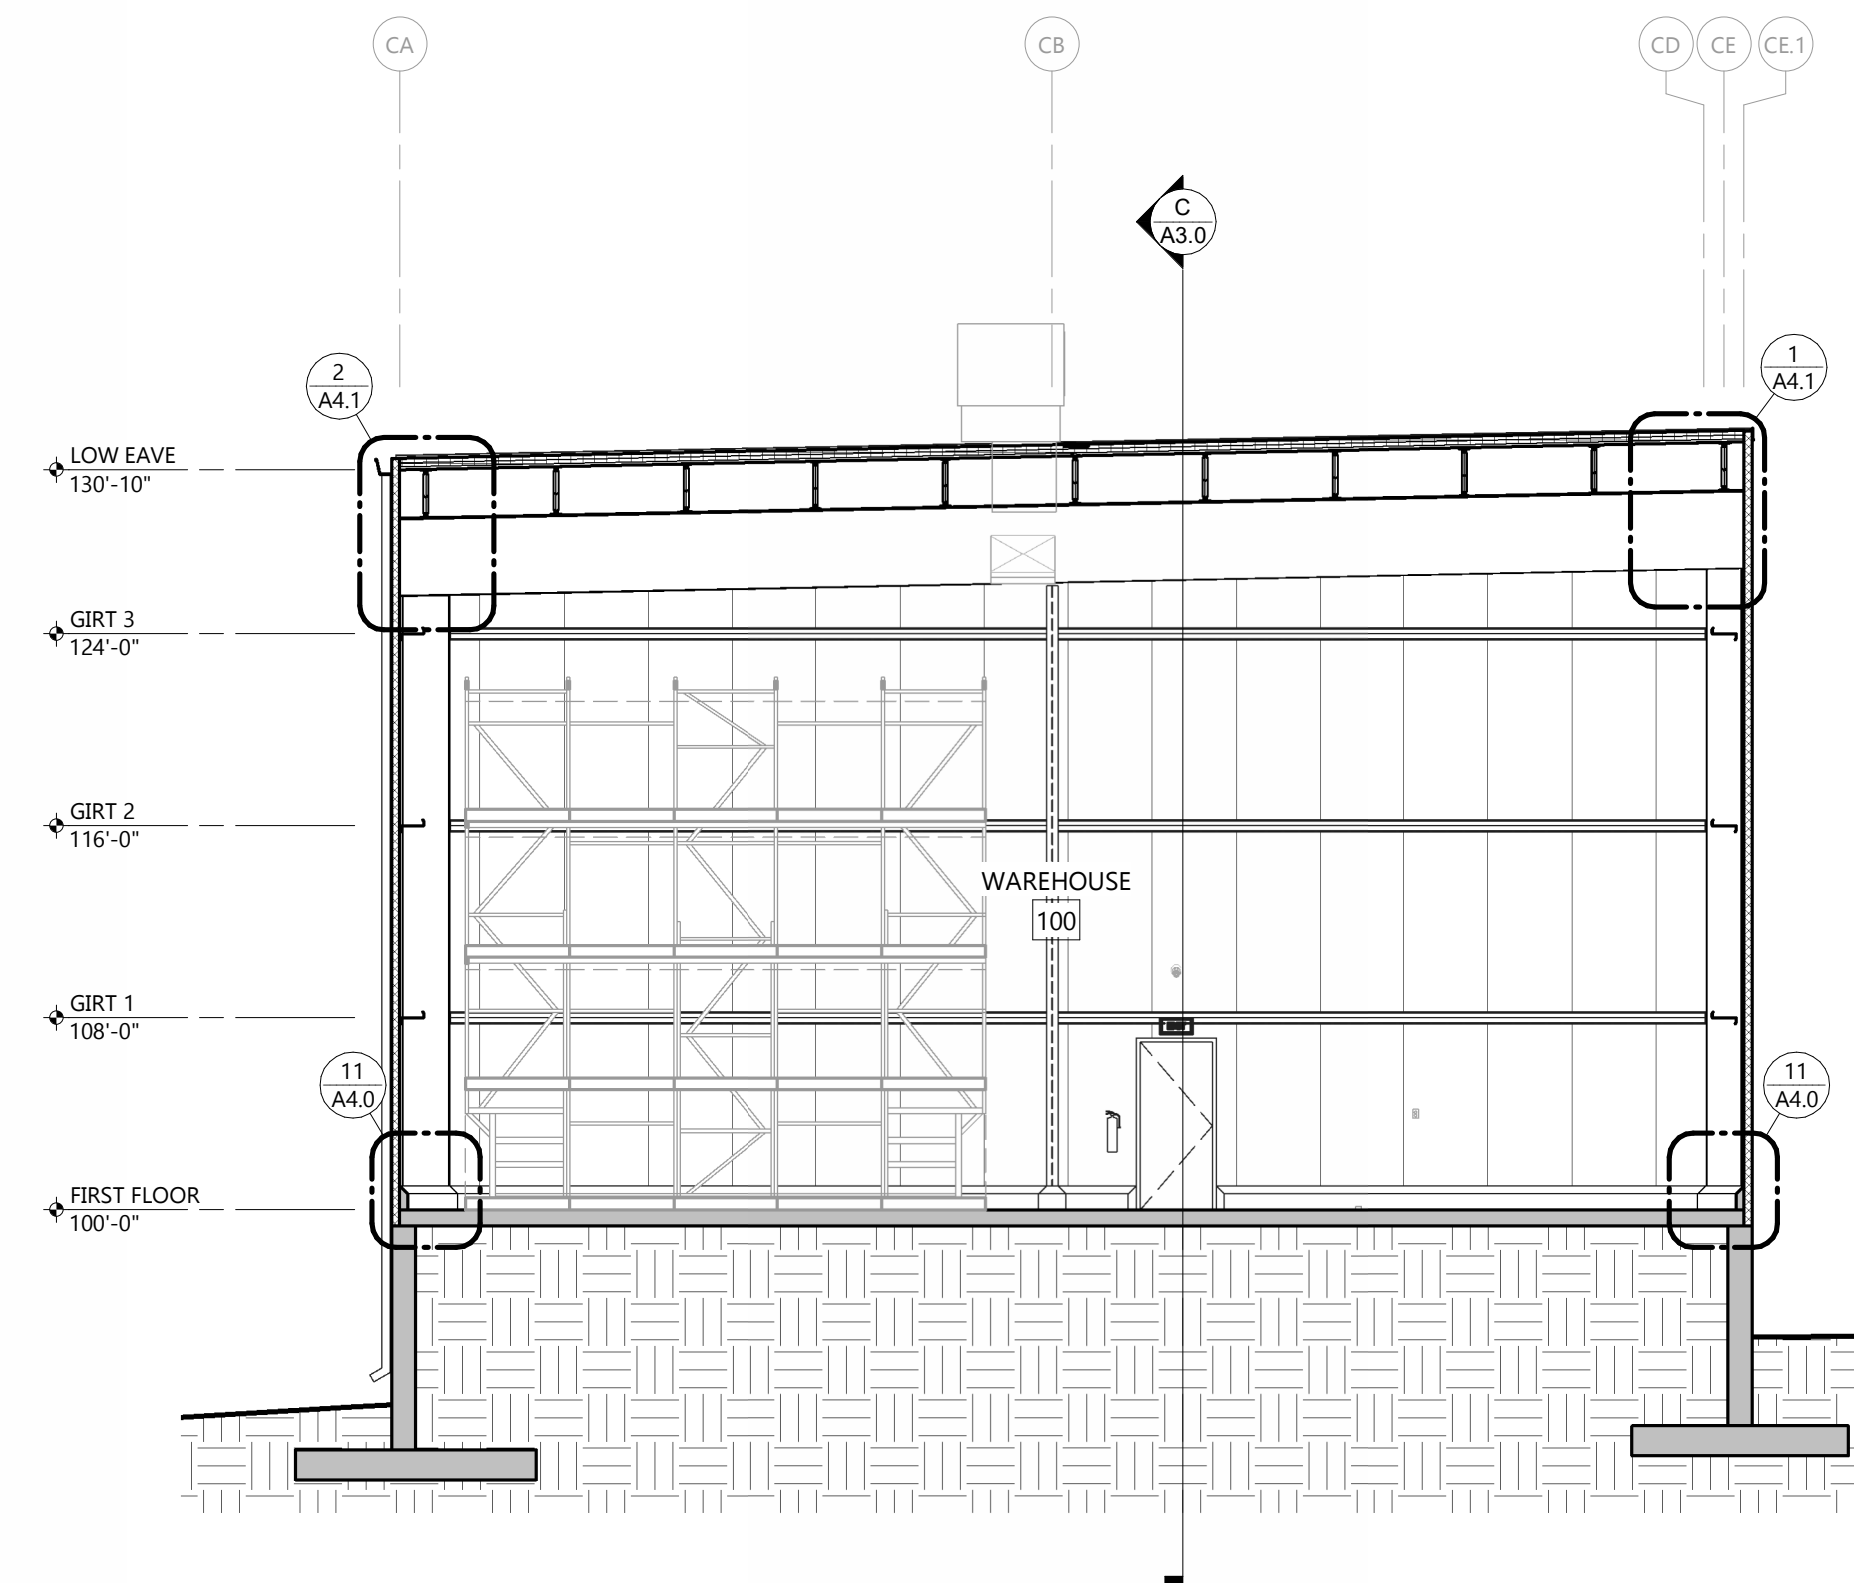

B BUILDING SECTION
A3.0 SCALE: 1/8" = 1'-0"

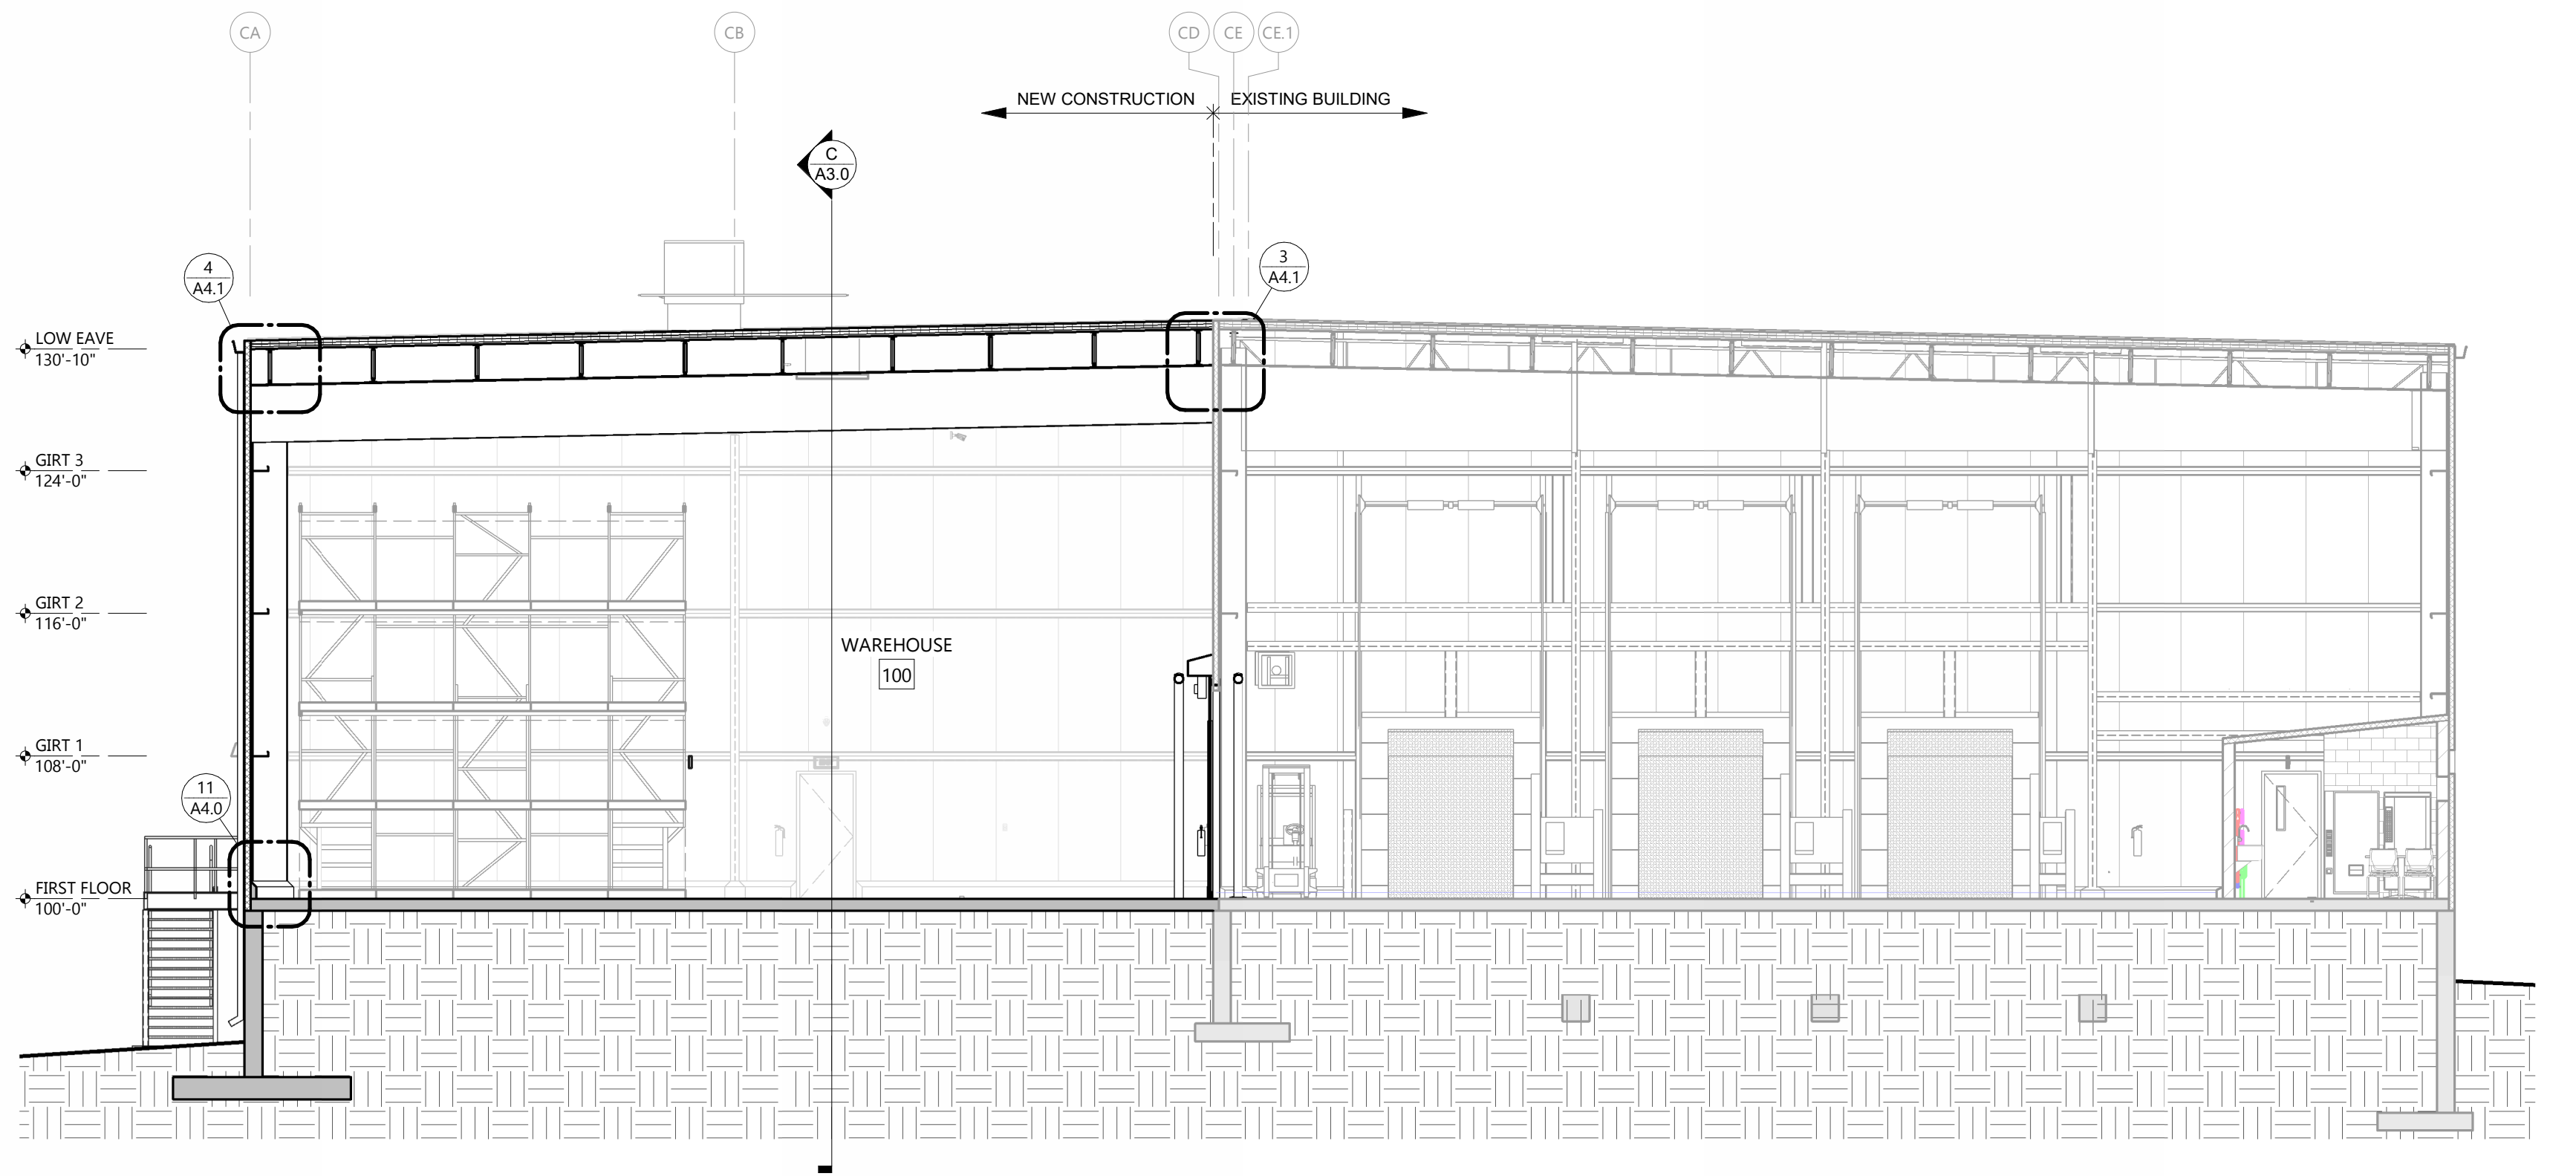

A BUILDING SECTION
A3.0 SCALE: 1/8" = 1'-0"

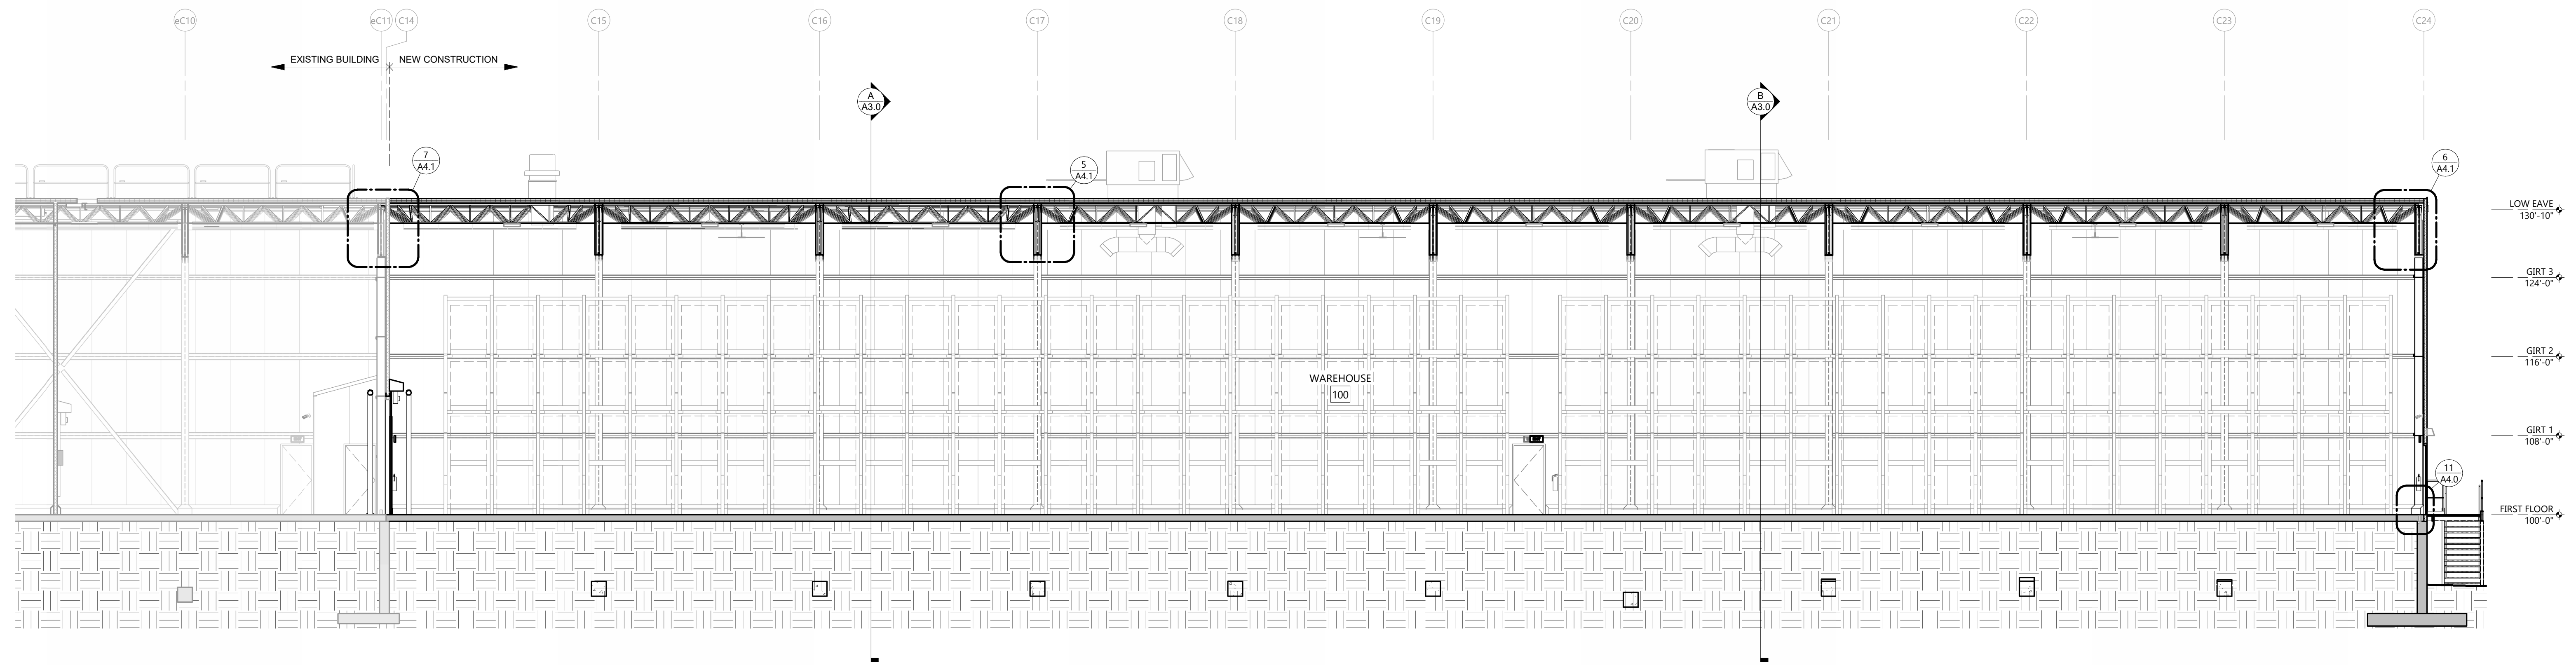

C BUILDING SECTION
A3.0 SCALE: 1/8" = 1'-0"

NOT FOR CONSTRUCTION

PROJECT INFORMATION

STORAGE WAREHOUSE EXPANSION FOR:
WEST POINT DAIRY PRODUCTS
570 NORTH 500 WEST • HYRUM, UT 84319

PROFESSIONAL SEAL

NOT FOR CONSTRUCTION

SHEET DATES

ISSUED FOR BUDGET

IFB APR. 17, 2026


JOB NUMBER

250429500

SHEET NUMBER


A4.0

ARCHITECTURAL WALL SECTIONS & DETAILS

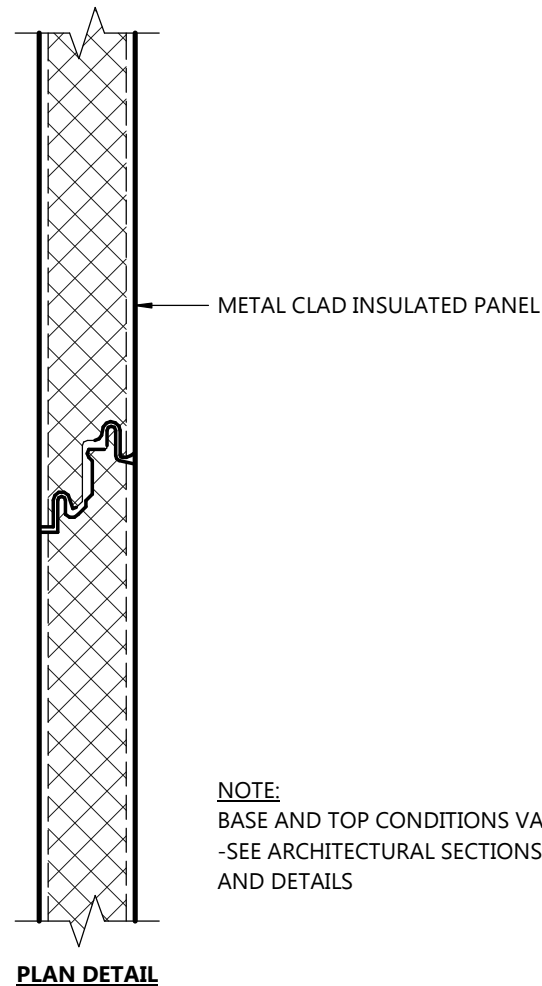


4IMP 4" INSULATED METAL PANEL
SEE A4 SHEETS FOR WALL TYPES NOT LISTED ABOVE


INTERIOR WALL TYPE - 4IMP

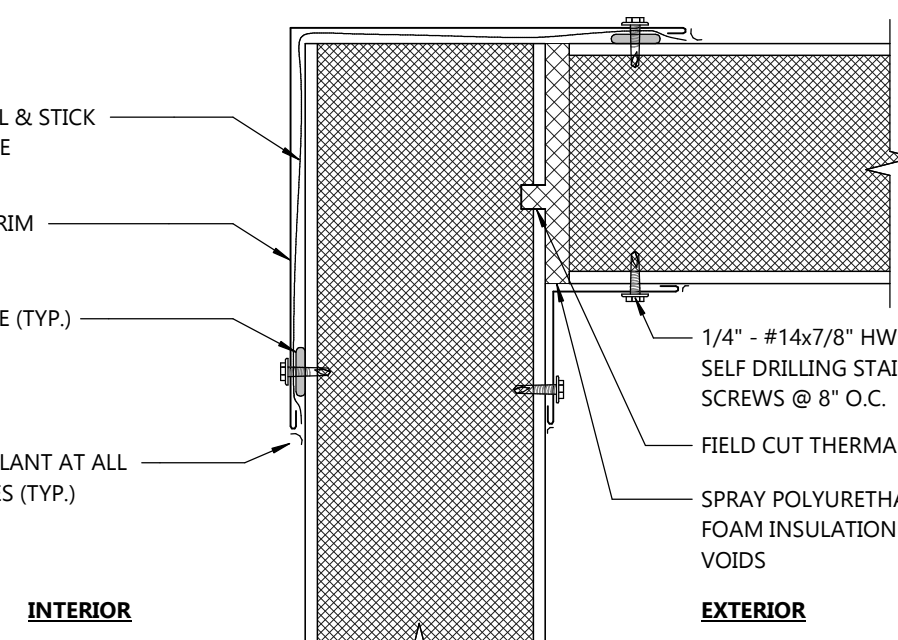


1 IMP WALL CORNER DETAIL
SCALE: 3\"/>

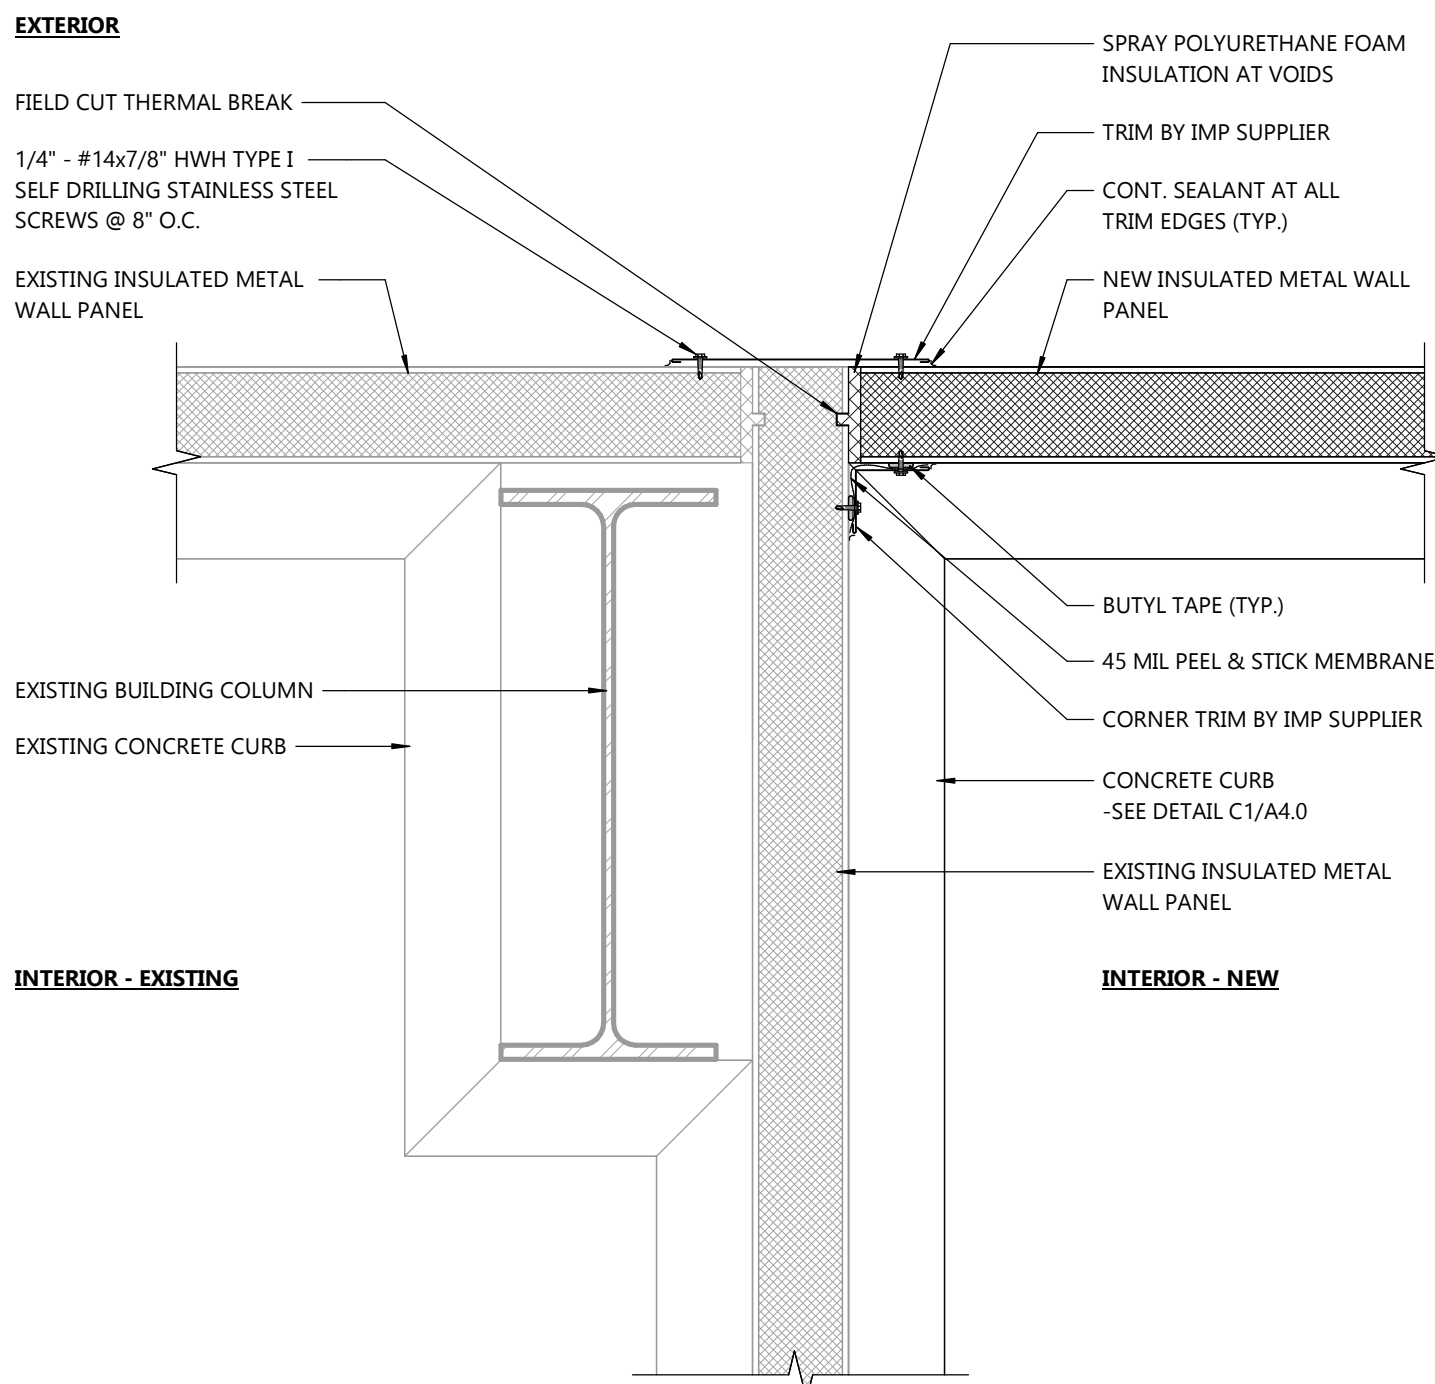


3 NEW TO EXISTING IMP WALL INTERSECTION DETAIL
SCALE: 1 1/2\"/>

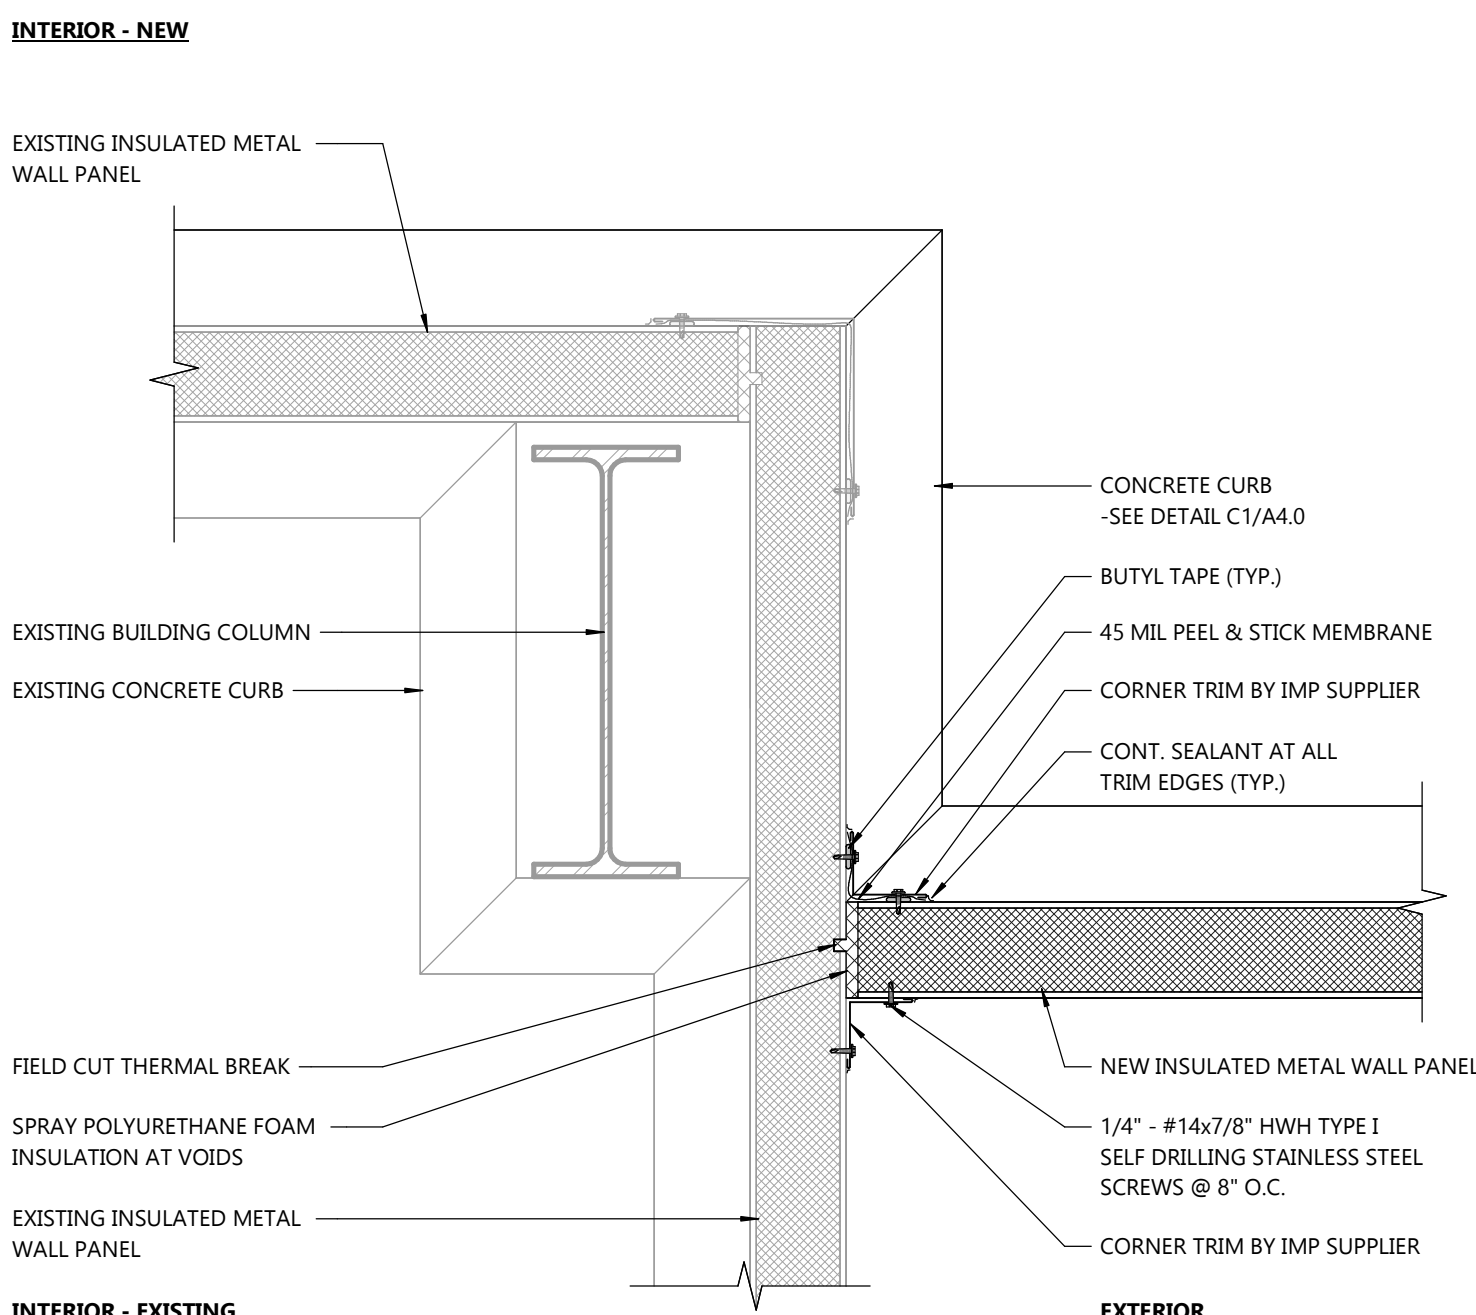


15 NEW TO EXISTING IMP WALL INTERSECTION DETAIL
SCALE: 1 1/2\"/>

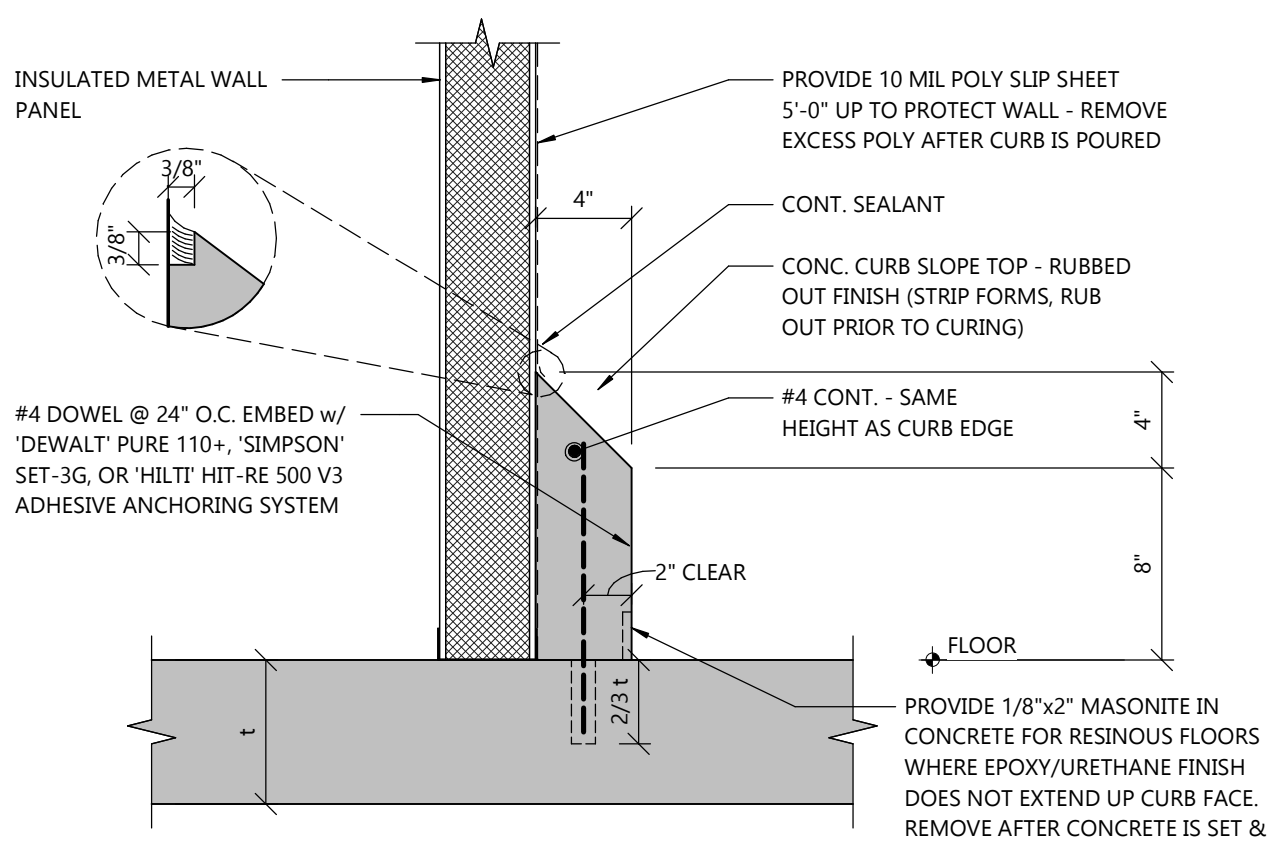


C1 CURB DETAIL
SCALE: 1 1/2\"/>

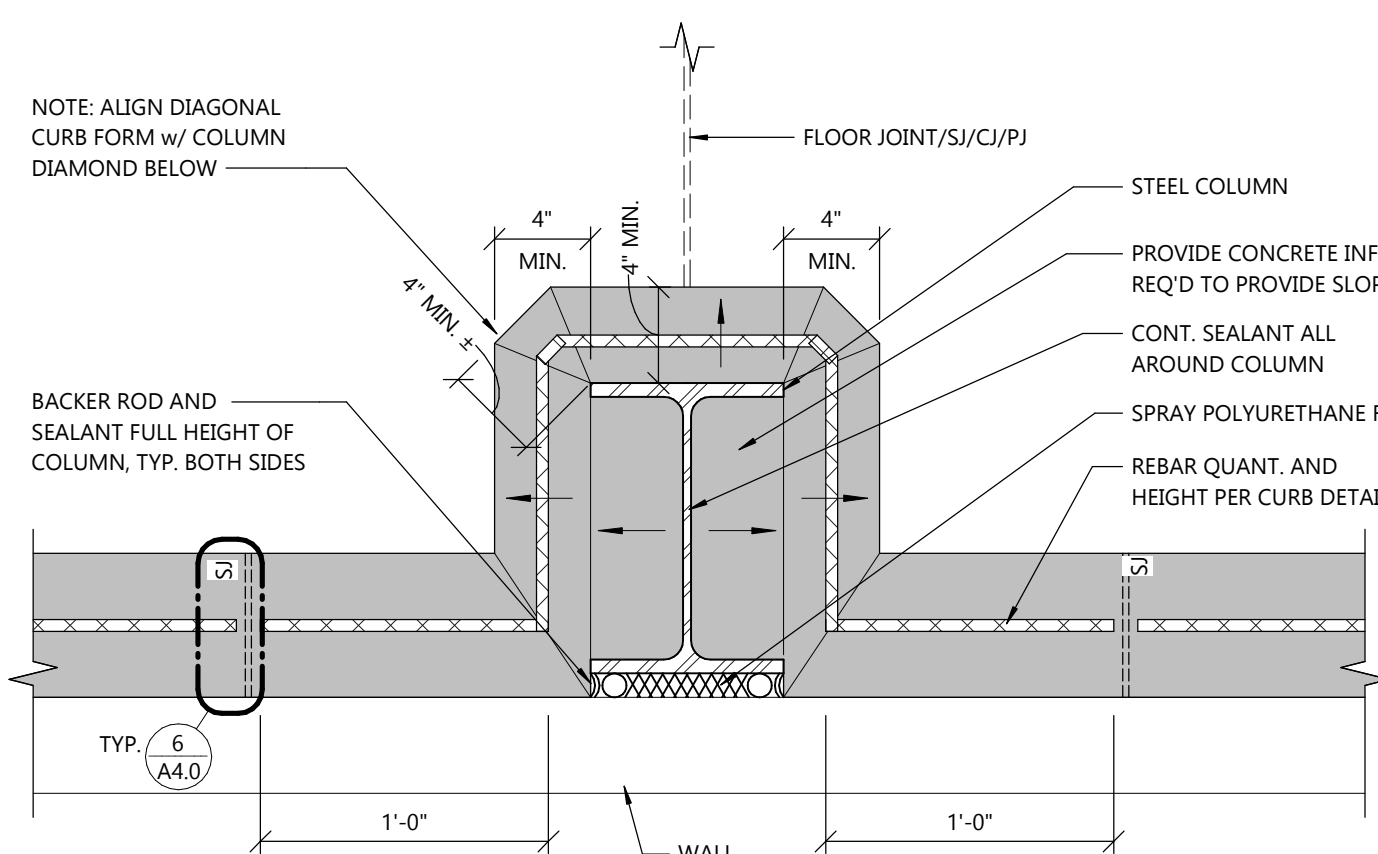


7 CURB AT COLUMN DETAIL
SCALE: 1 1/2\"/>

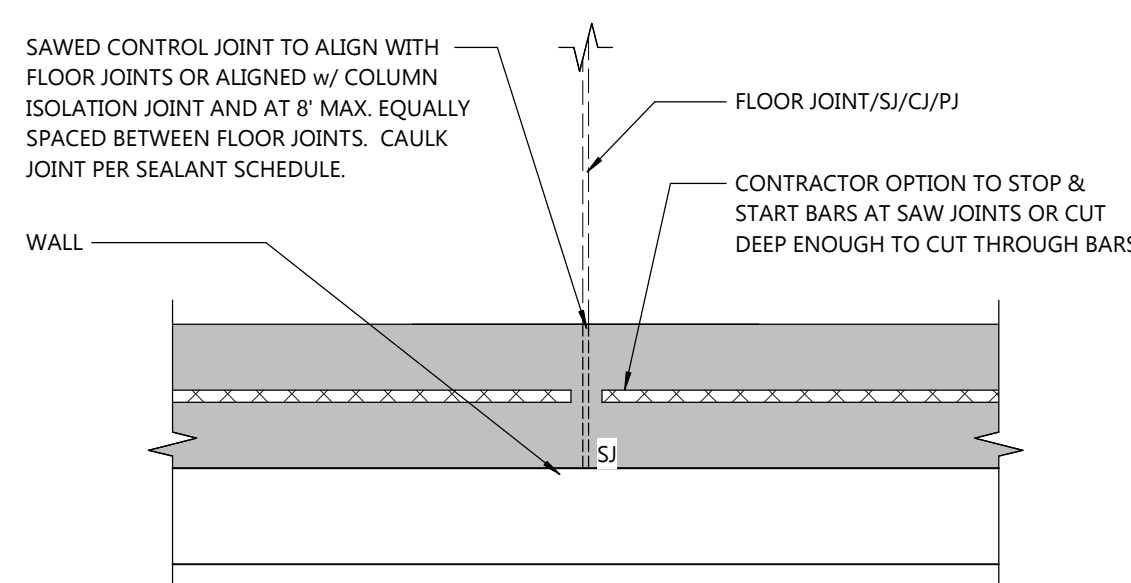


6 TYP. SAWED CONTROL JOINT
SCALE: 1 1/2\"/>

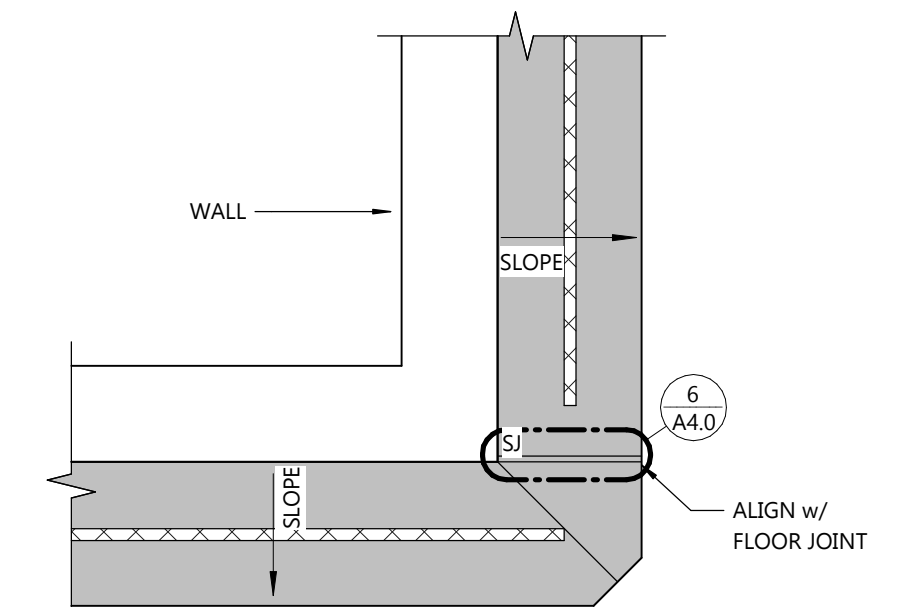


5 TYP. OUTSIDE CORNER
SCALE: 1 1/2\"/>

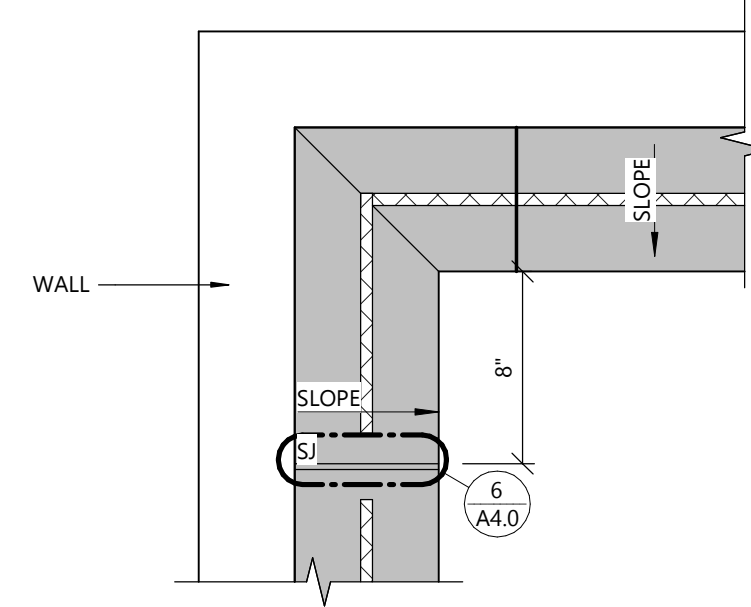


4 TYP. INSIDE CORNER
SCALE: 1 1/2\"/>

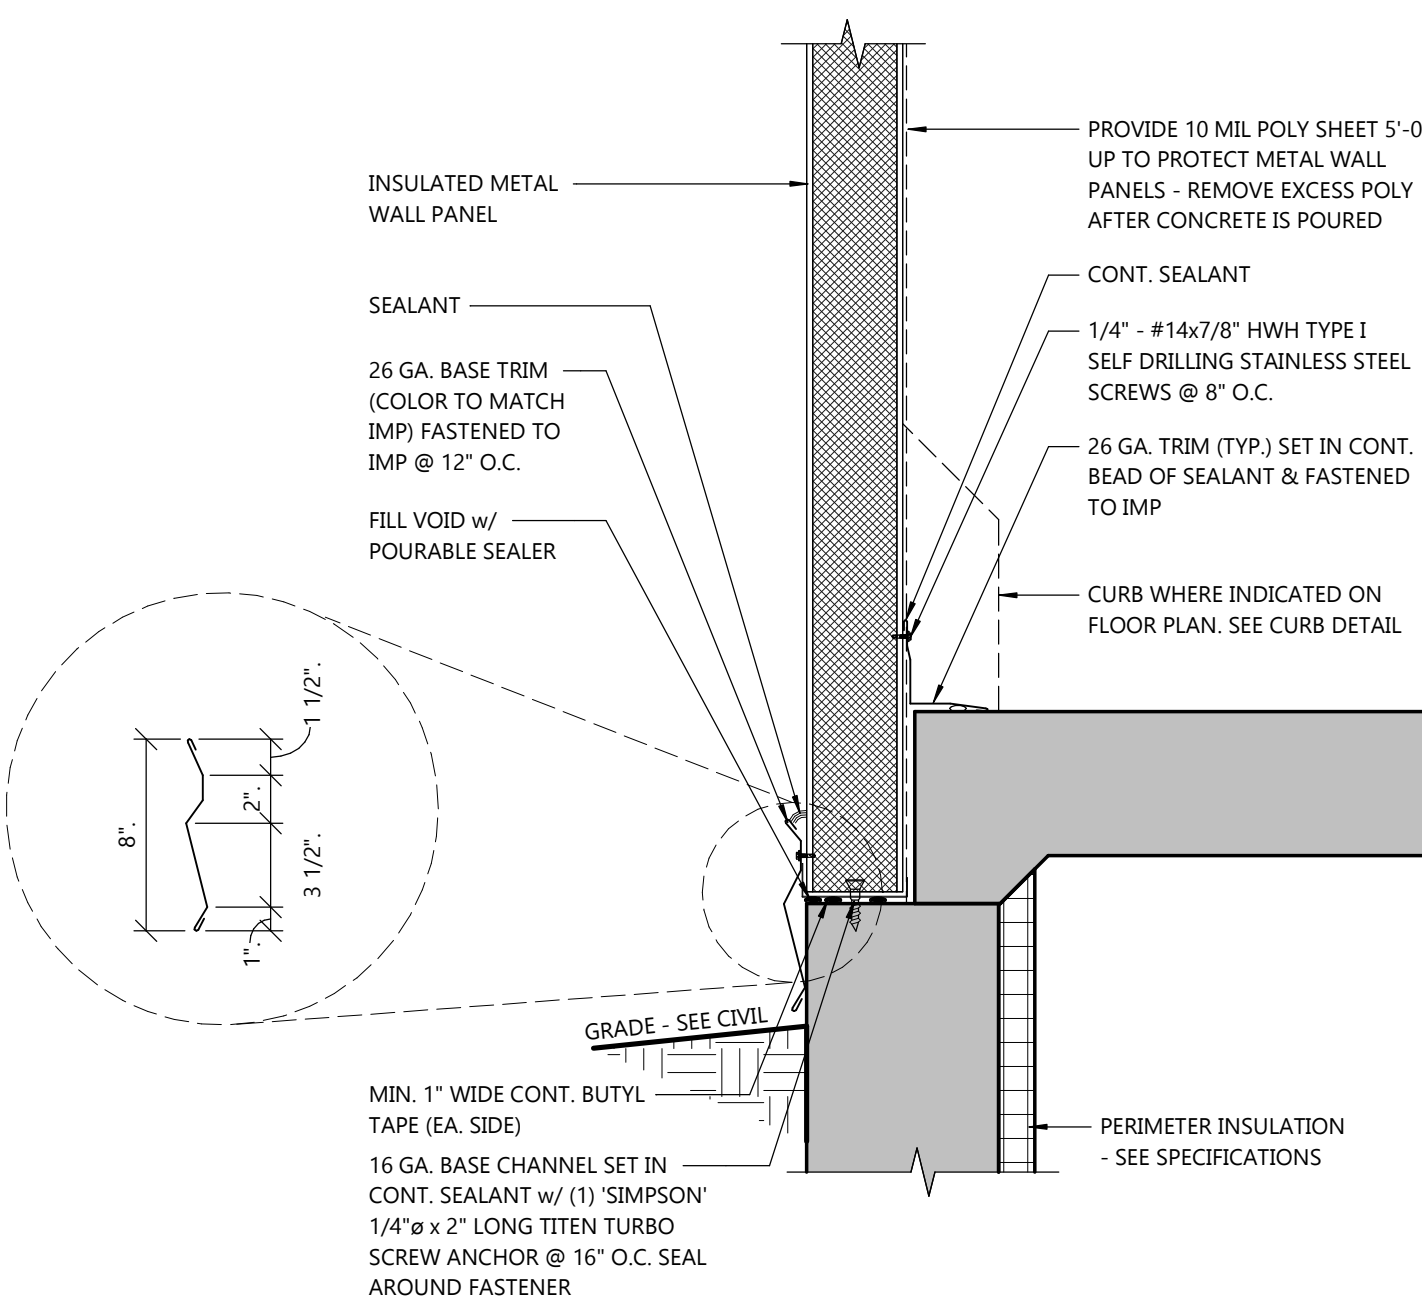


11 IMP BASE CONNECTION DETAILS
SCALE: 1 1/2\"/>

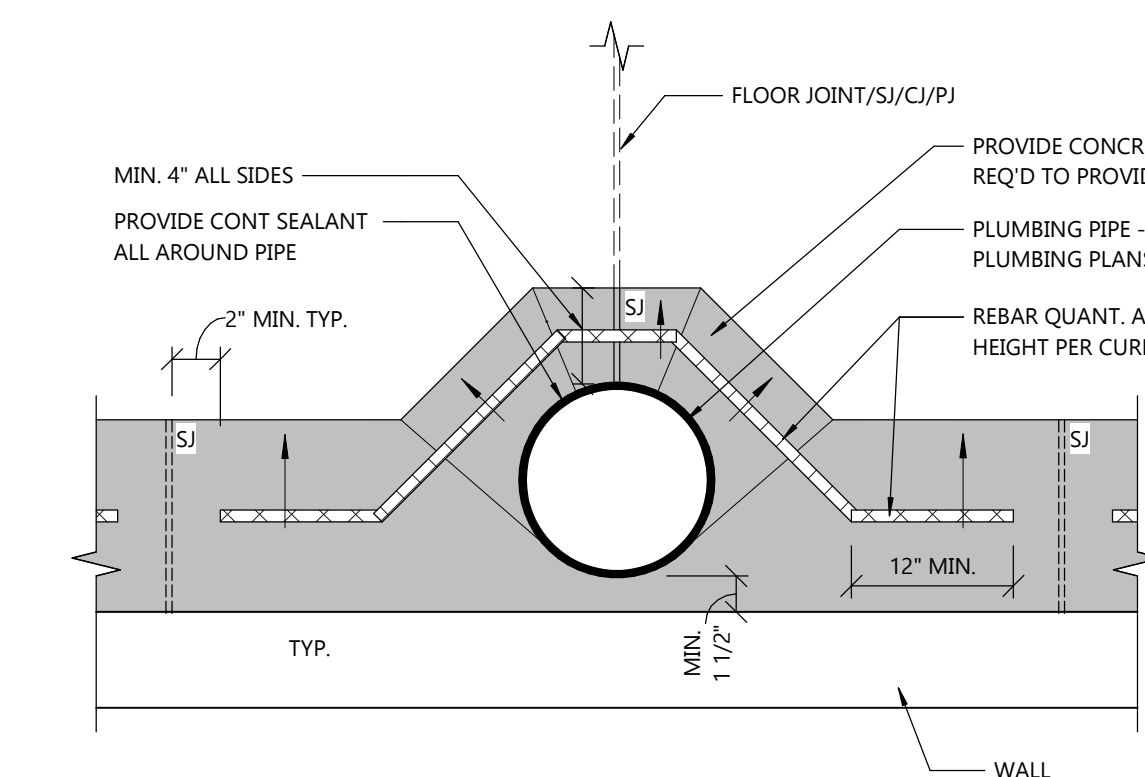


10 CURB AT PIPE DETAIL
SCALE: 1 1/2\"/>

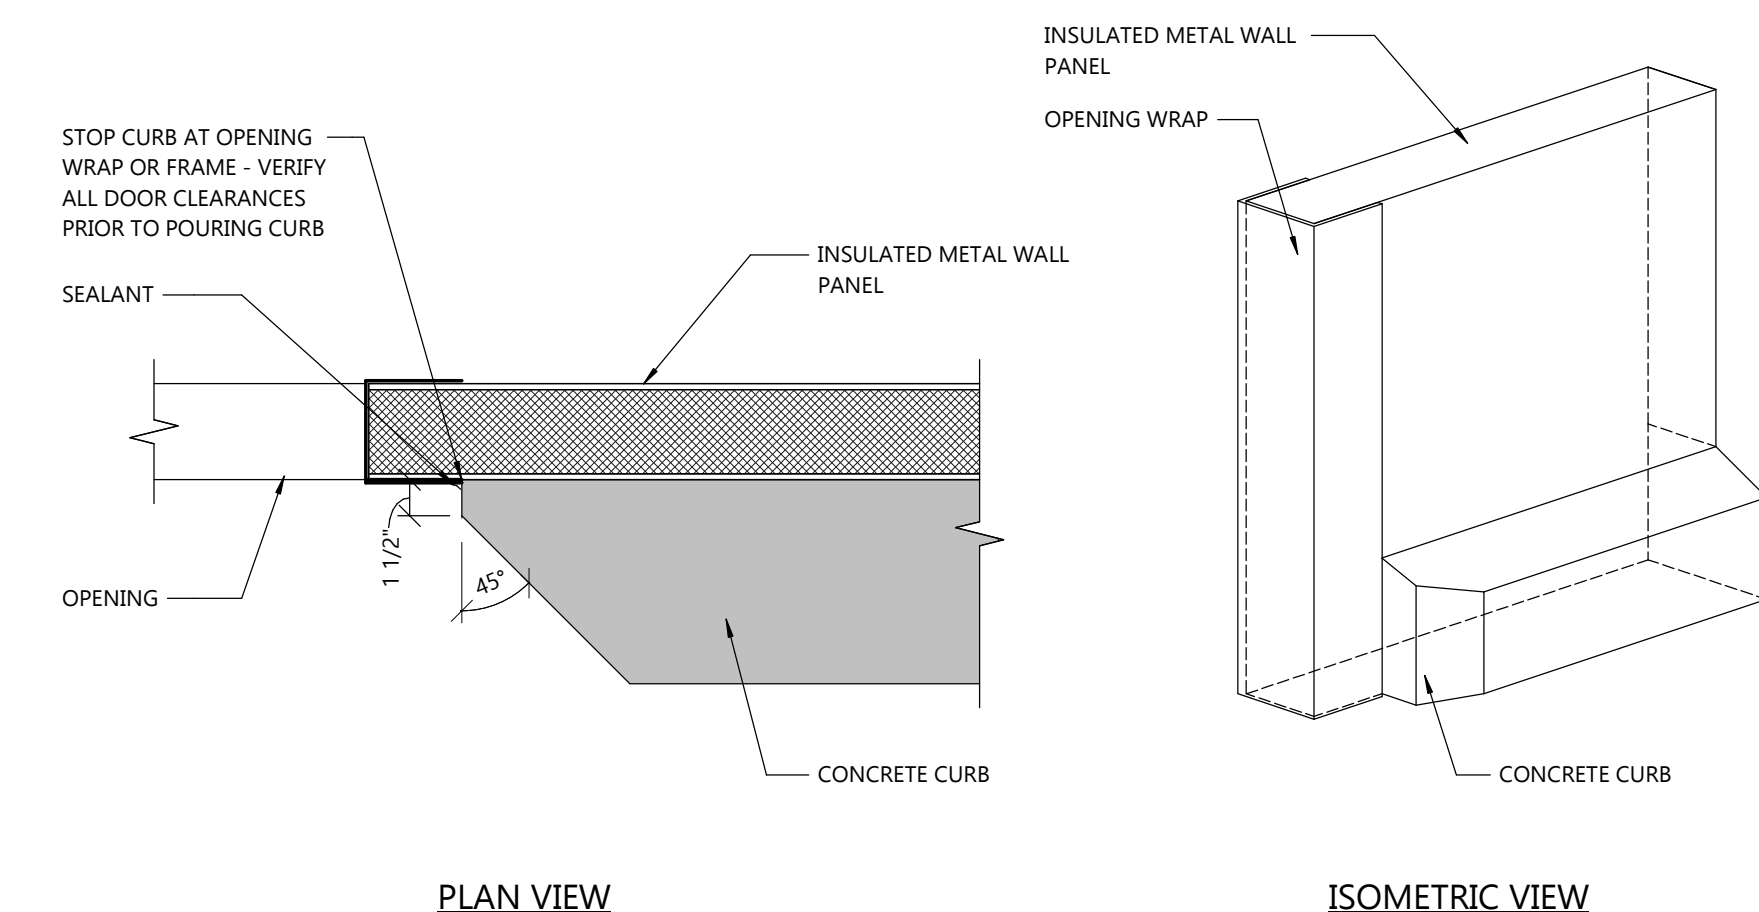


9 CURB RETURN AT IMP WALL OPENING DETAIL
SCALE: 1 1/2\"/>

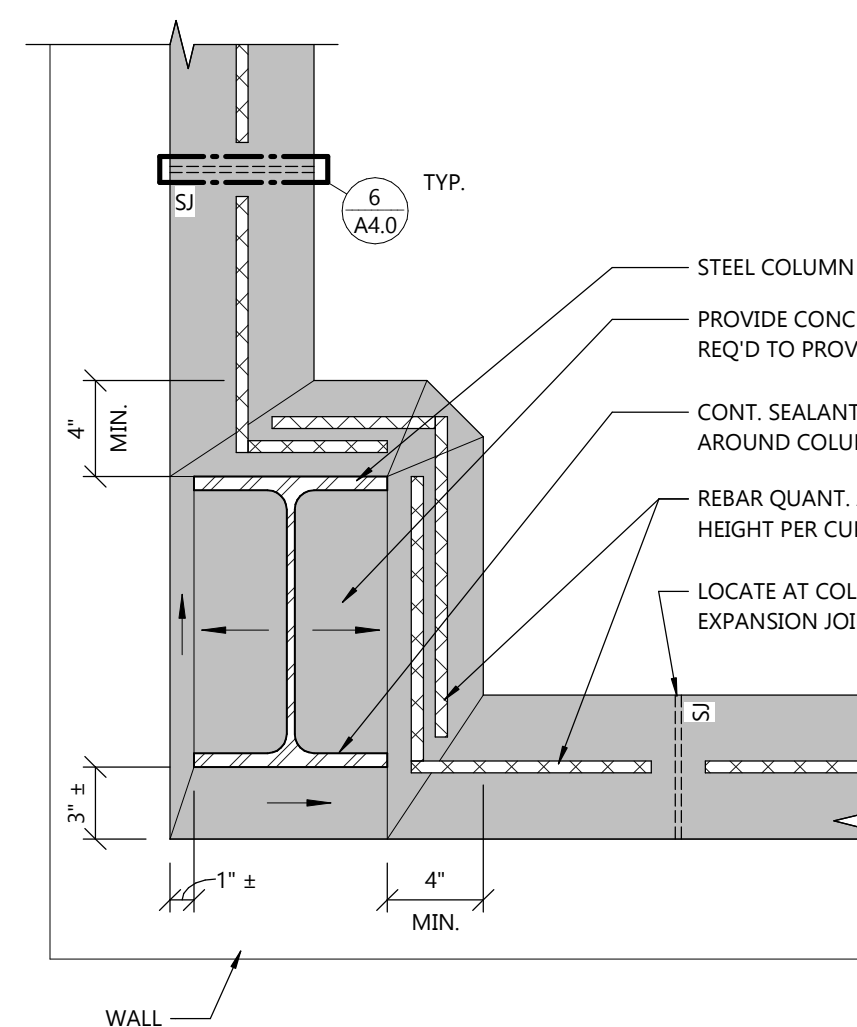

8 CURB AT COLUMN DETAIL
SCALE: 1 1/2\"/>

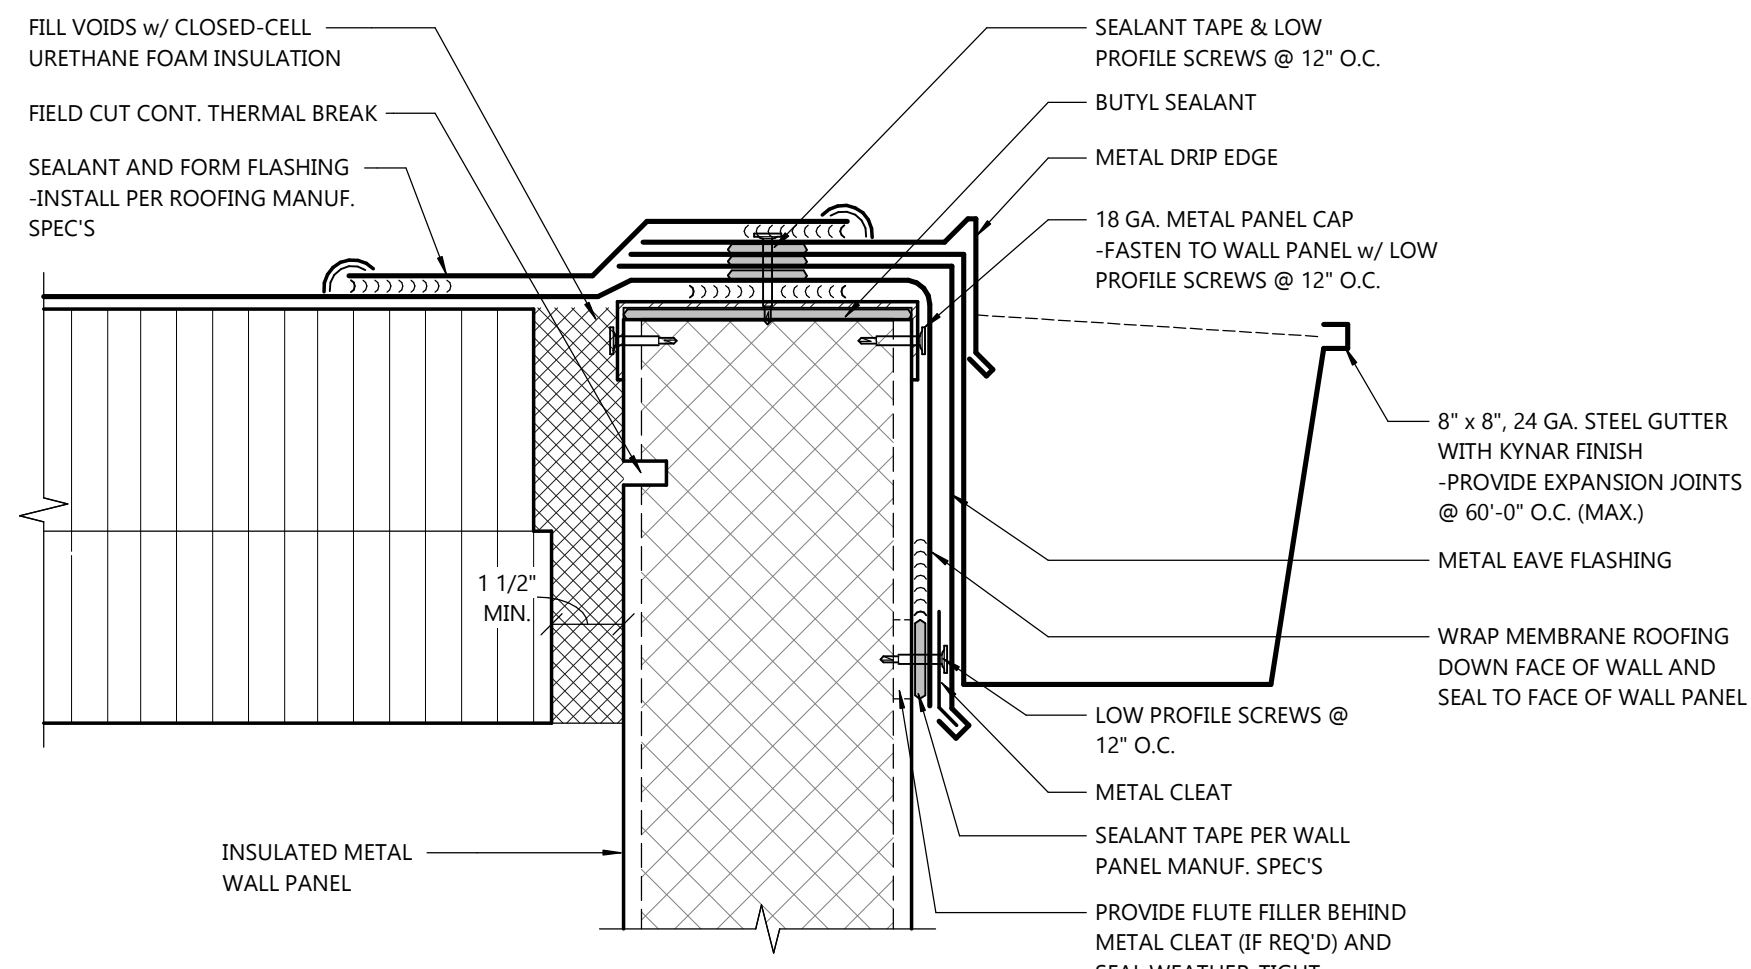

13 IMP WALL DETAIL
SCALE: 3\"/>

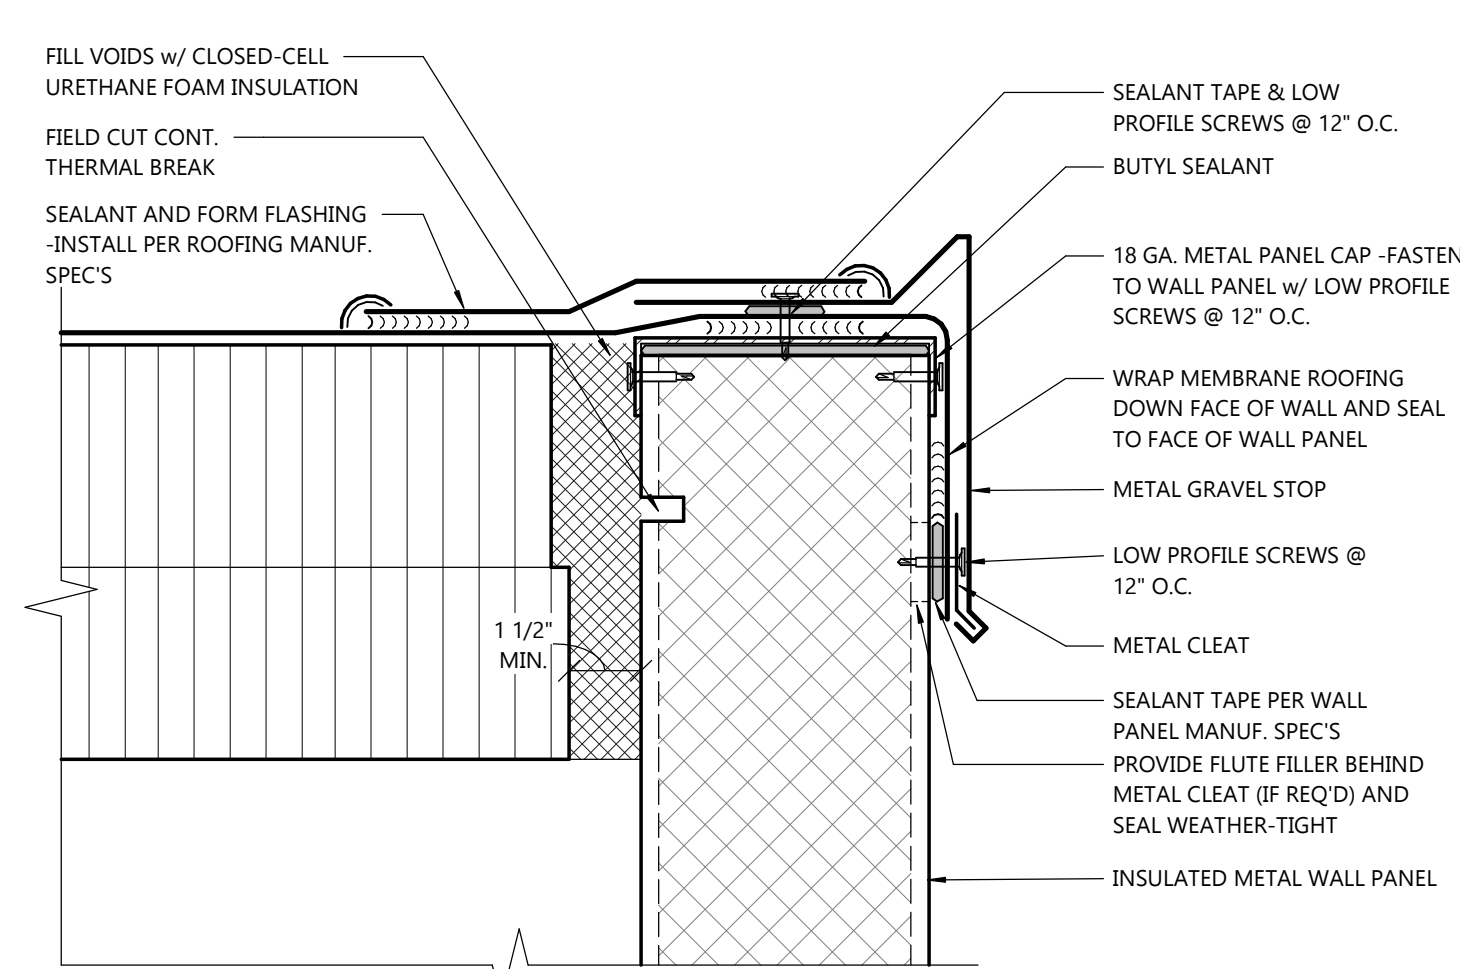

12 IMP WALL DETAIL
SCALE: 3\"/>

PROJECT INFORMATION

STORAGE WAREHOUSE EXPANSION FOR:
WEST POINT DAIRY PRODUCTS
570 NORTH 500 WEST • HYRUM, UT 84319

PROFESSIONAL SEAL

NOT FOR CONSTRUCTION

SHEET DATES

ISSUED FOR BUDGET

IFB APR. 17, 2026

JOB NUMBER

250429500


SHEET NUMBER

A4.1


NOTE:

SEE PRE-ENGINEERED METAL BUILDING
DRAWINGS FOR STEEL SIZE & LOCATIONS
OF BRACE OBSTRUCTIONS


ARCHITECTURAL DETAILS

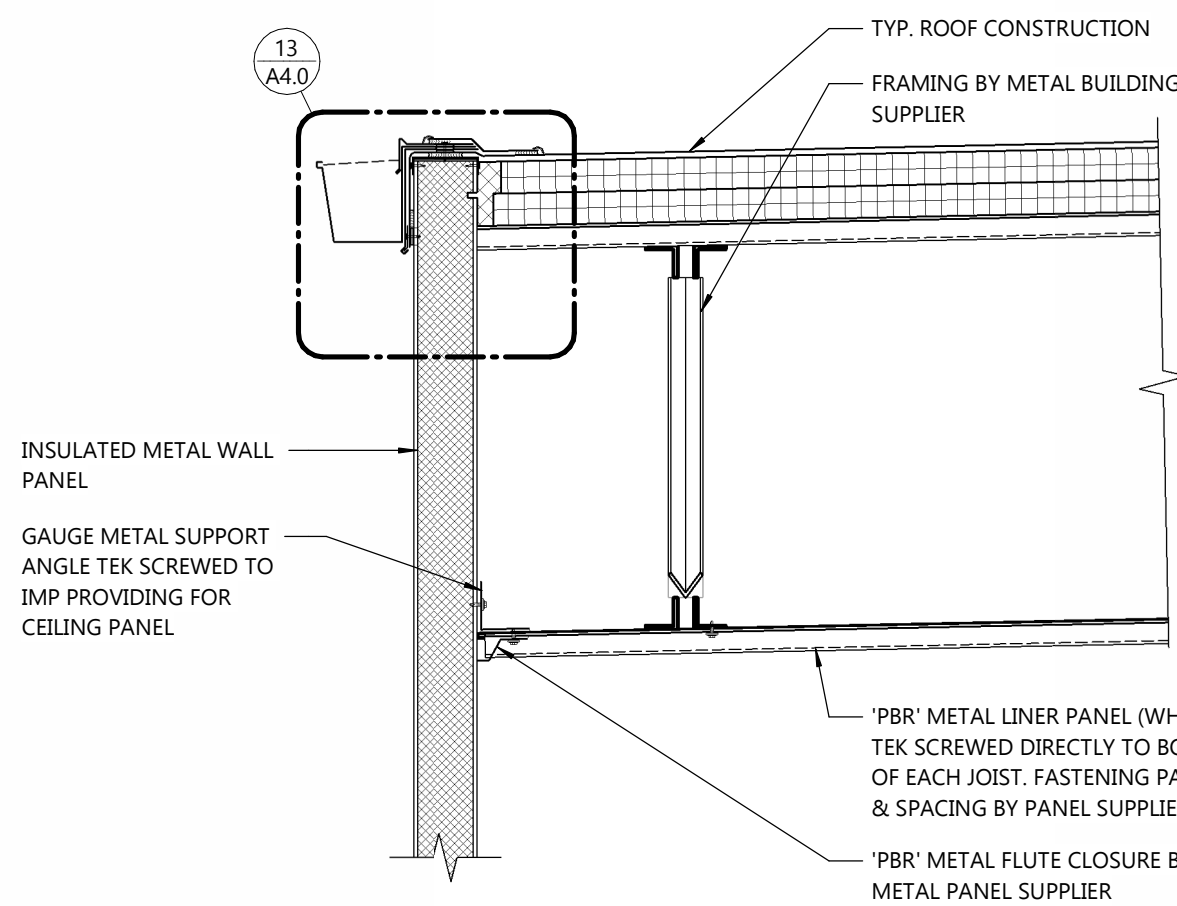


4
A4.1
DETAIL
SCALE: 1" = 1'-0"

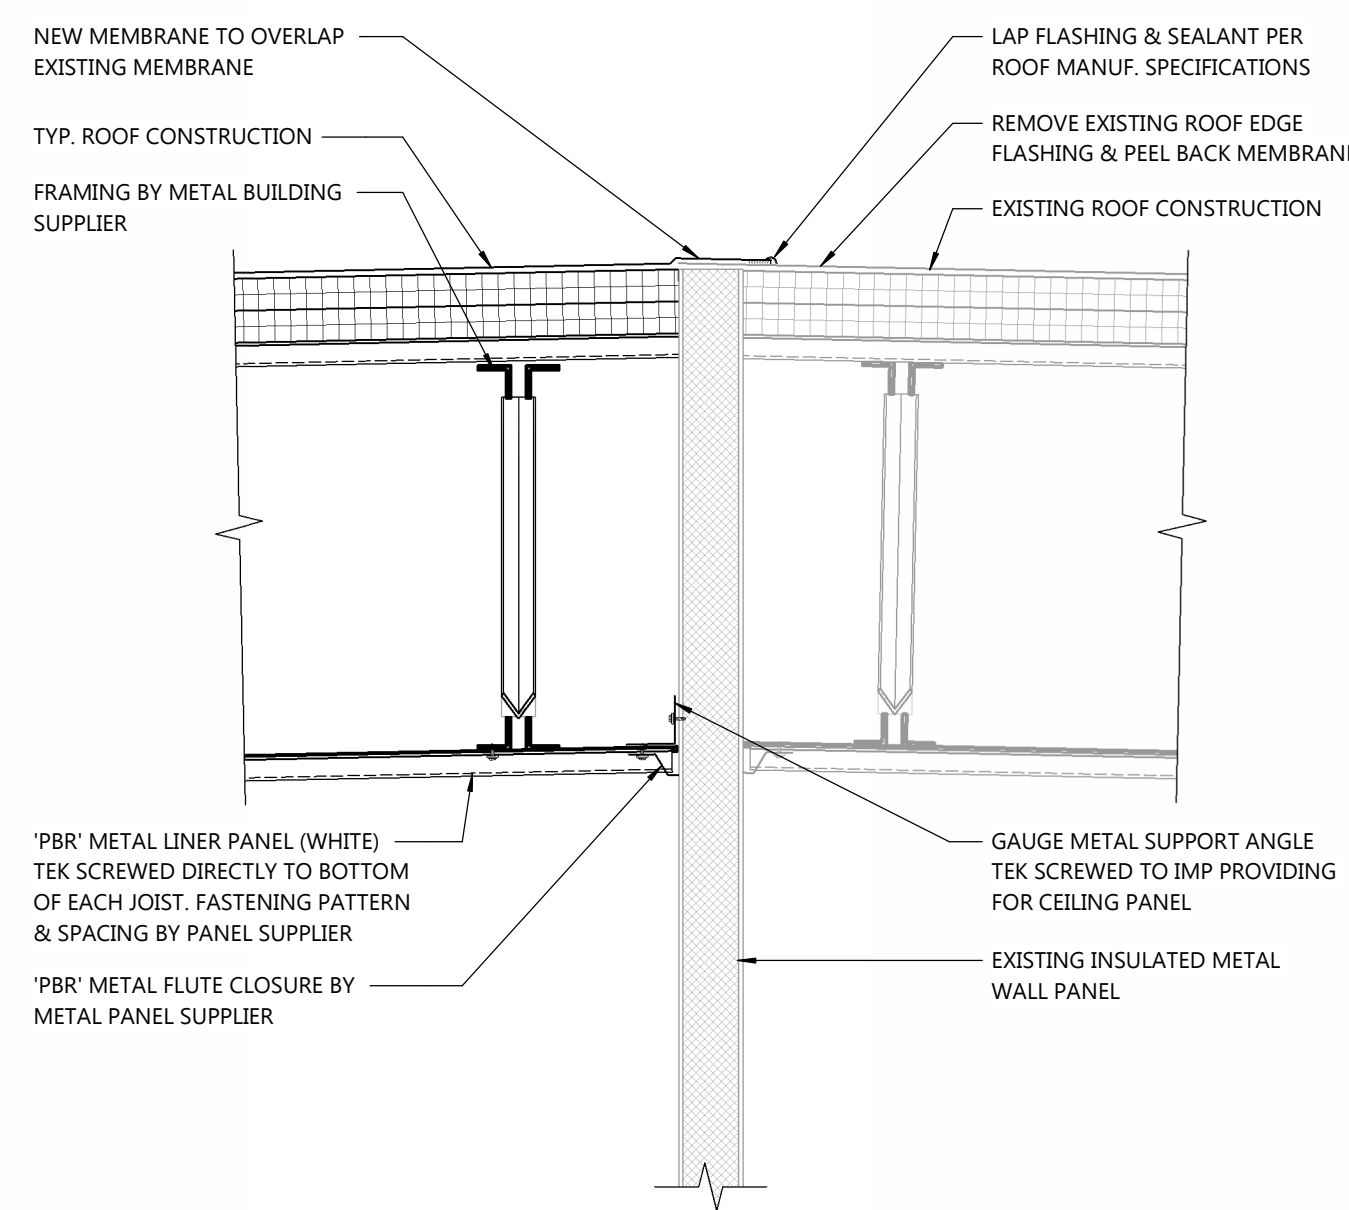


3
A4.1
DETAIL
SCALE: 1" = 1'-0"

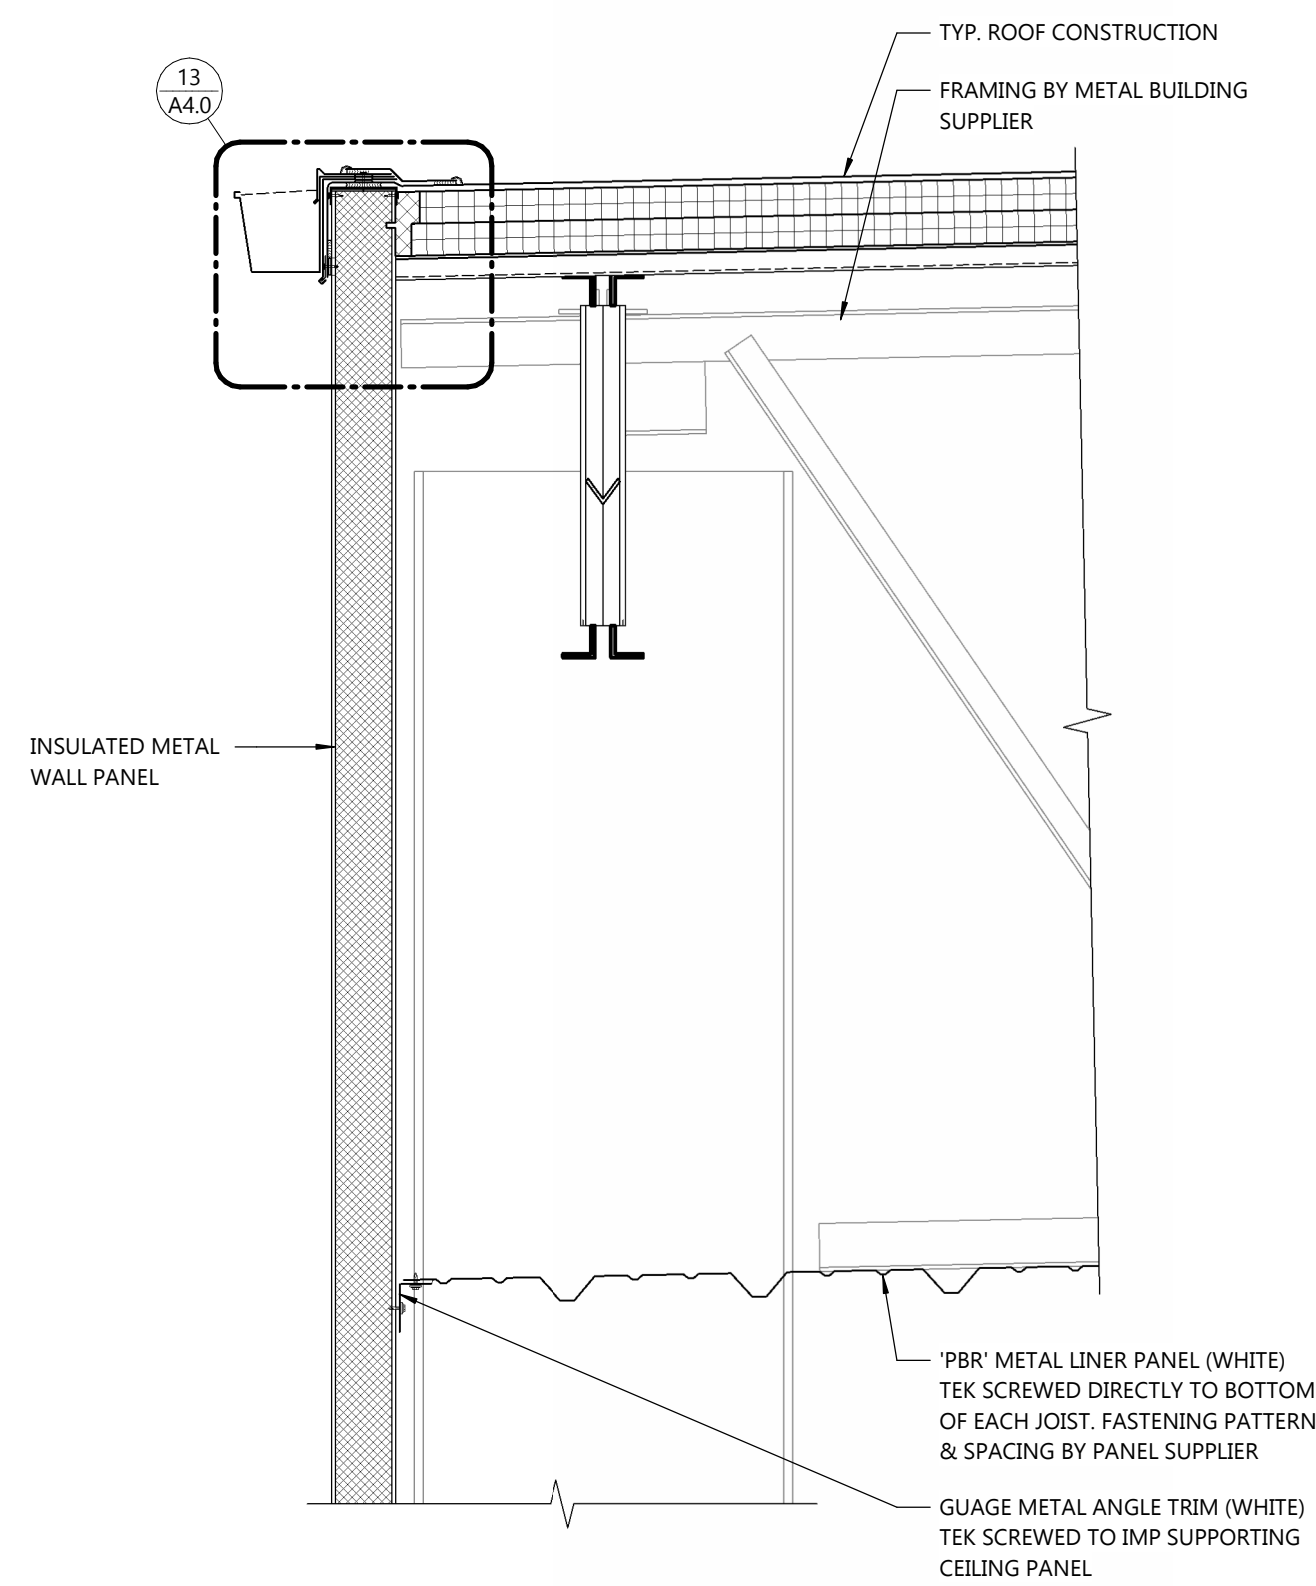


2
A4.1
DETAIL
SCALE: 1" = 1'-0"

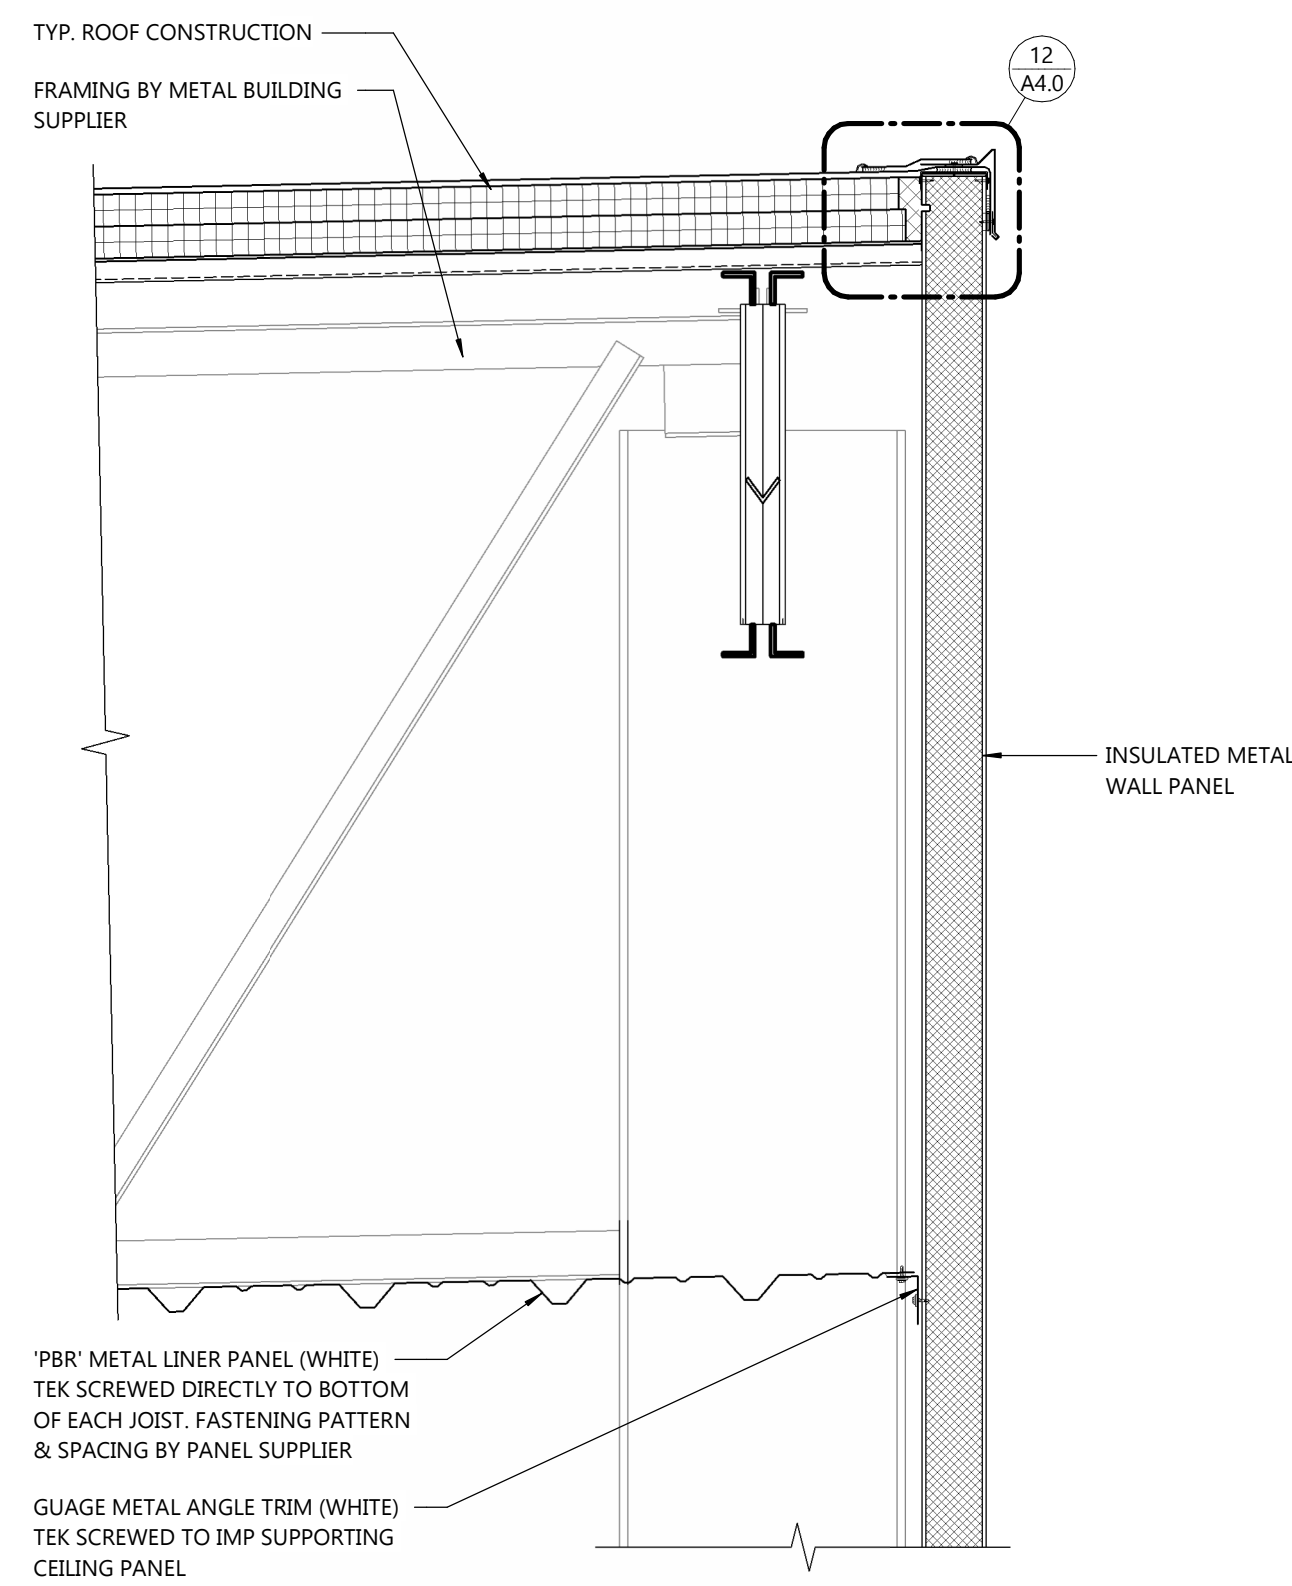


1
A4.1
DETAIL
SCALE: 1" = 1'-0"

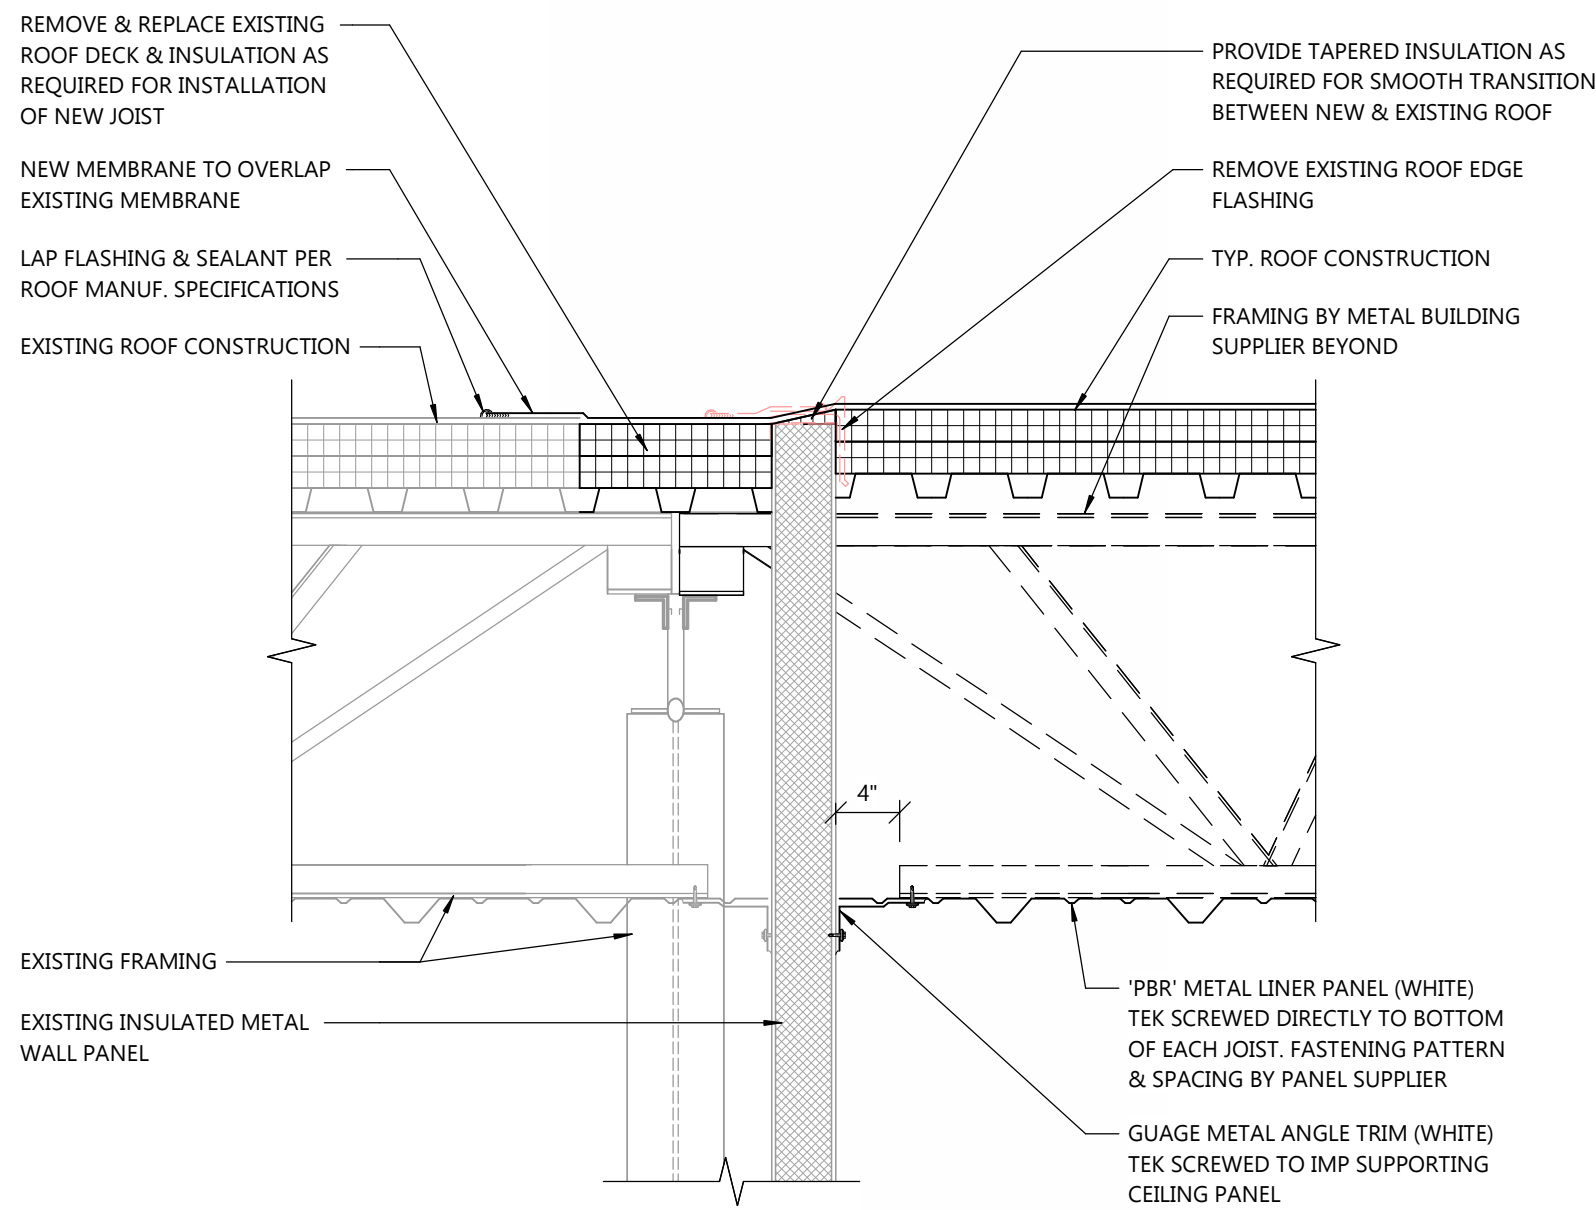


8
A4.1
DETAIL
SCALE: 1" = 1'-0"

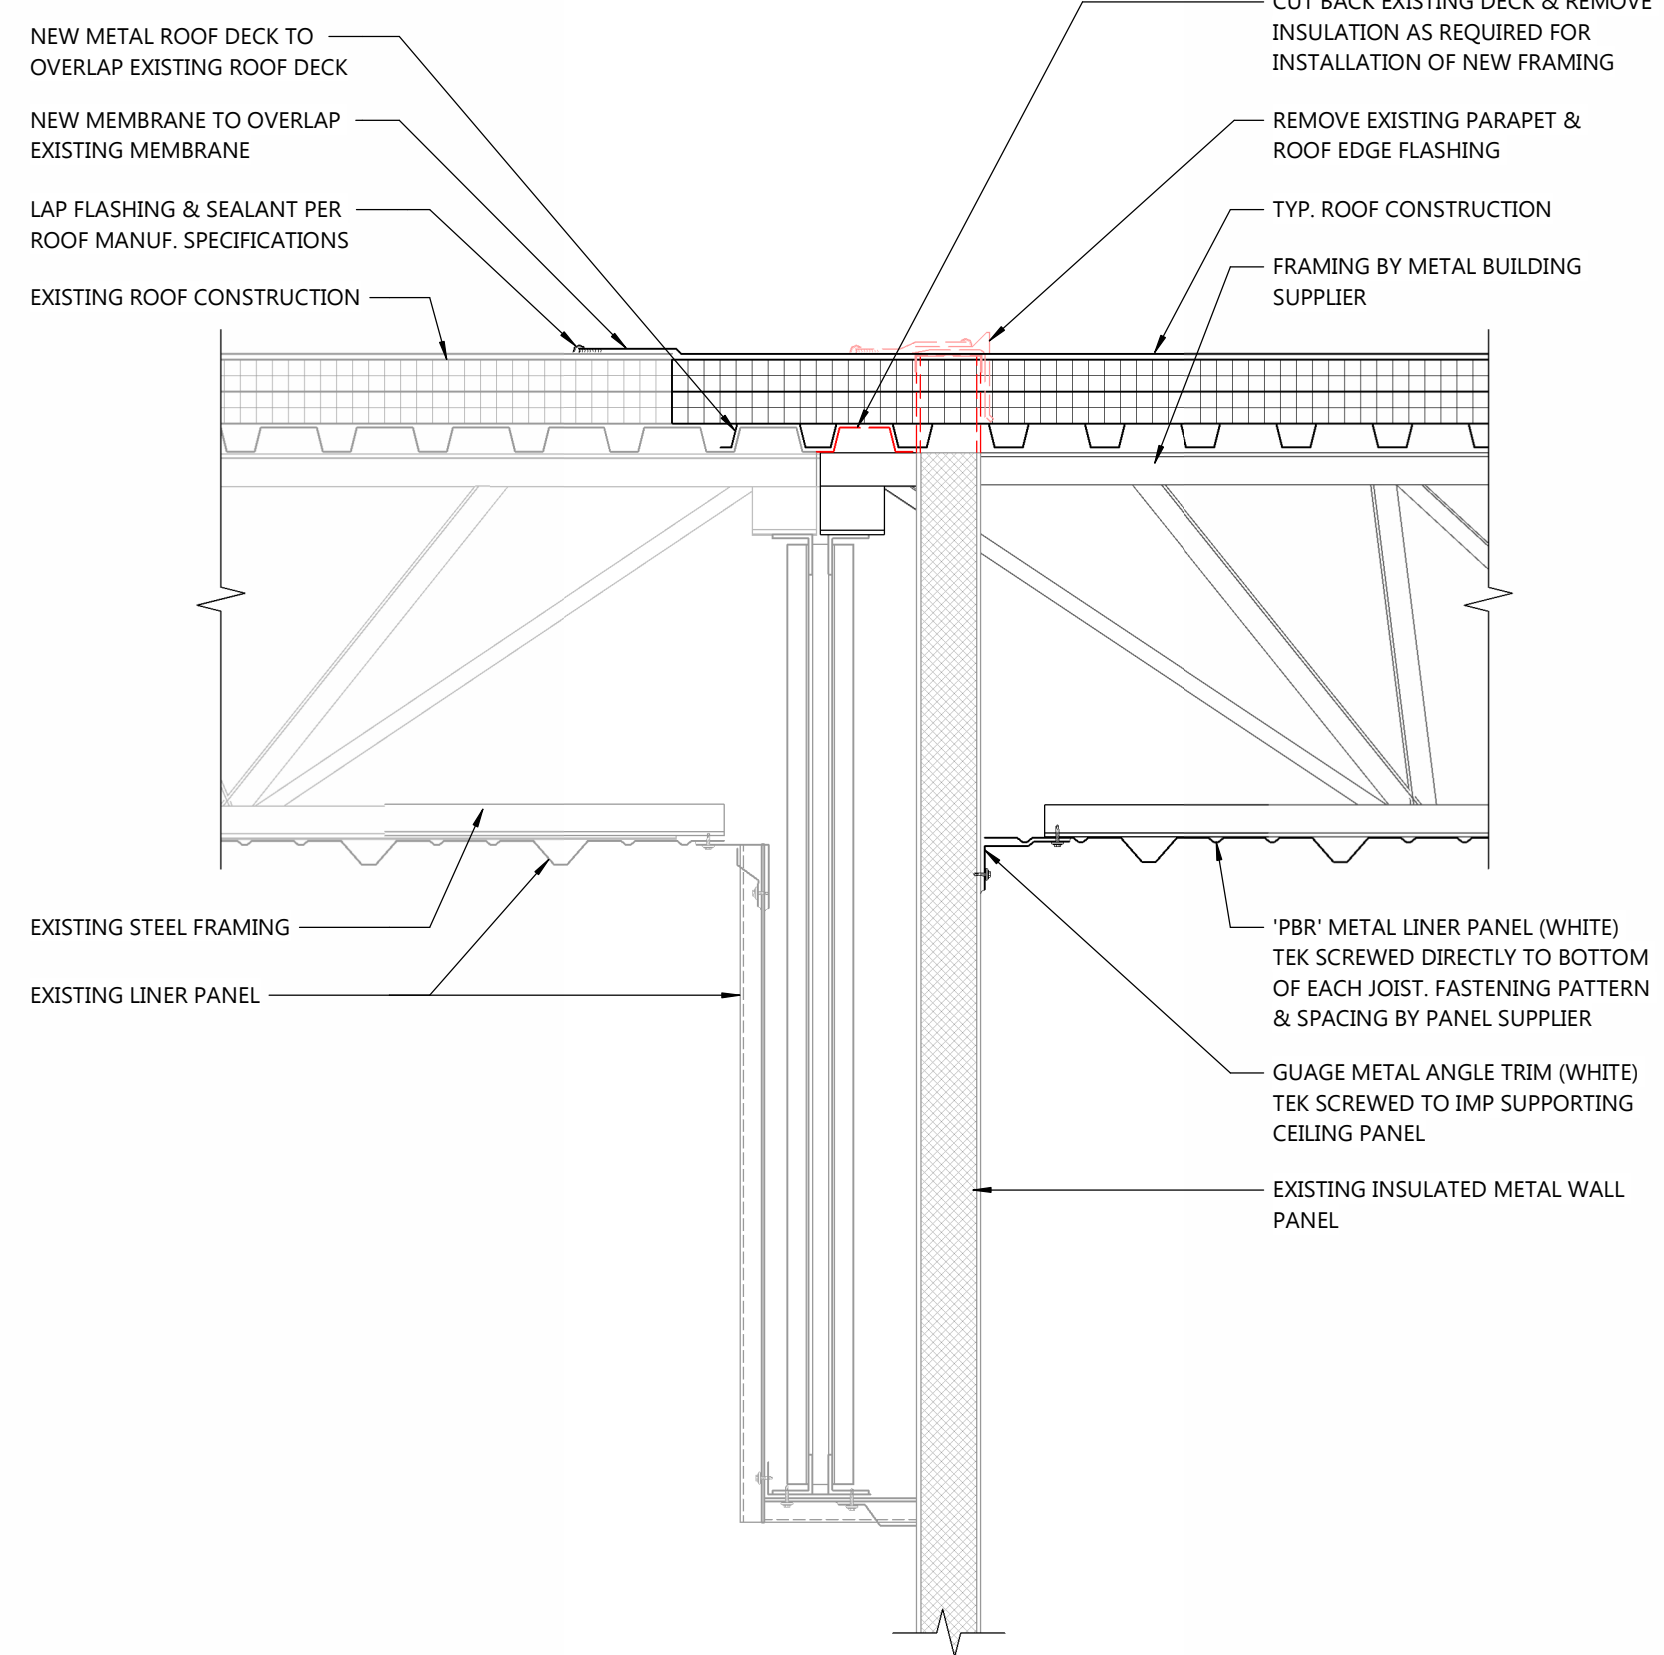






7
A4.1
DETAIL
SCALE: 1" = 1'-0"

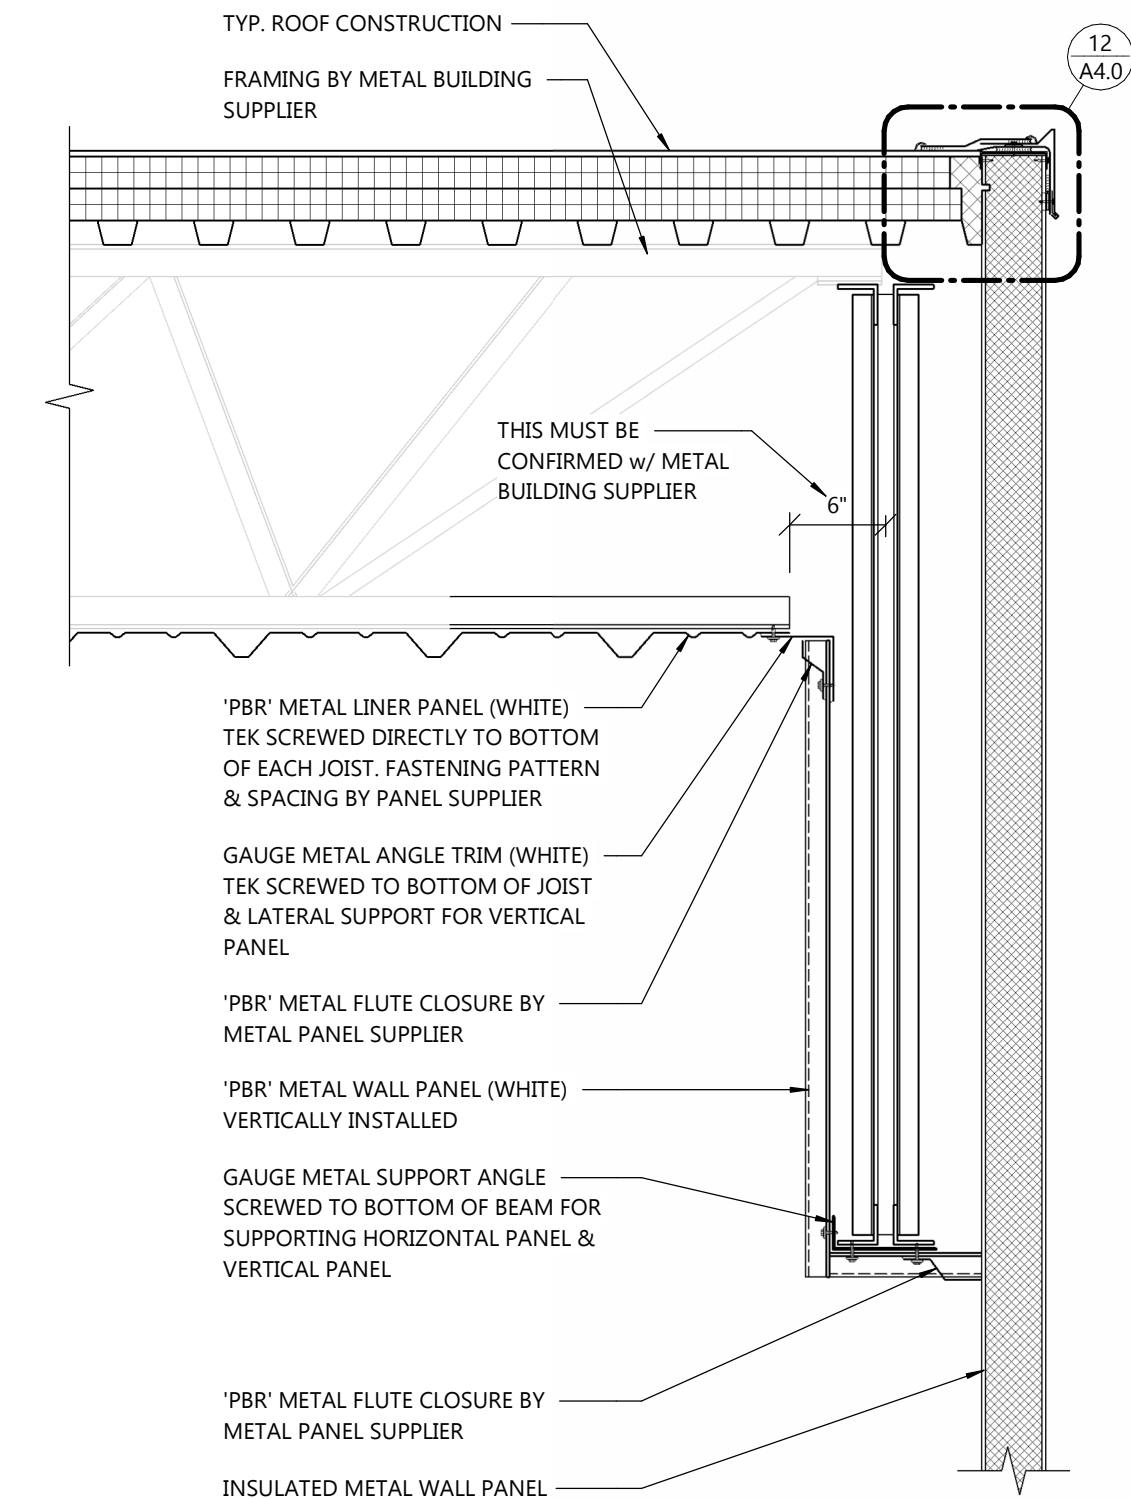

6
A4.1
DETAIL
SCALE: 1" = 1'-0"

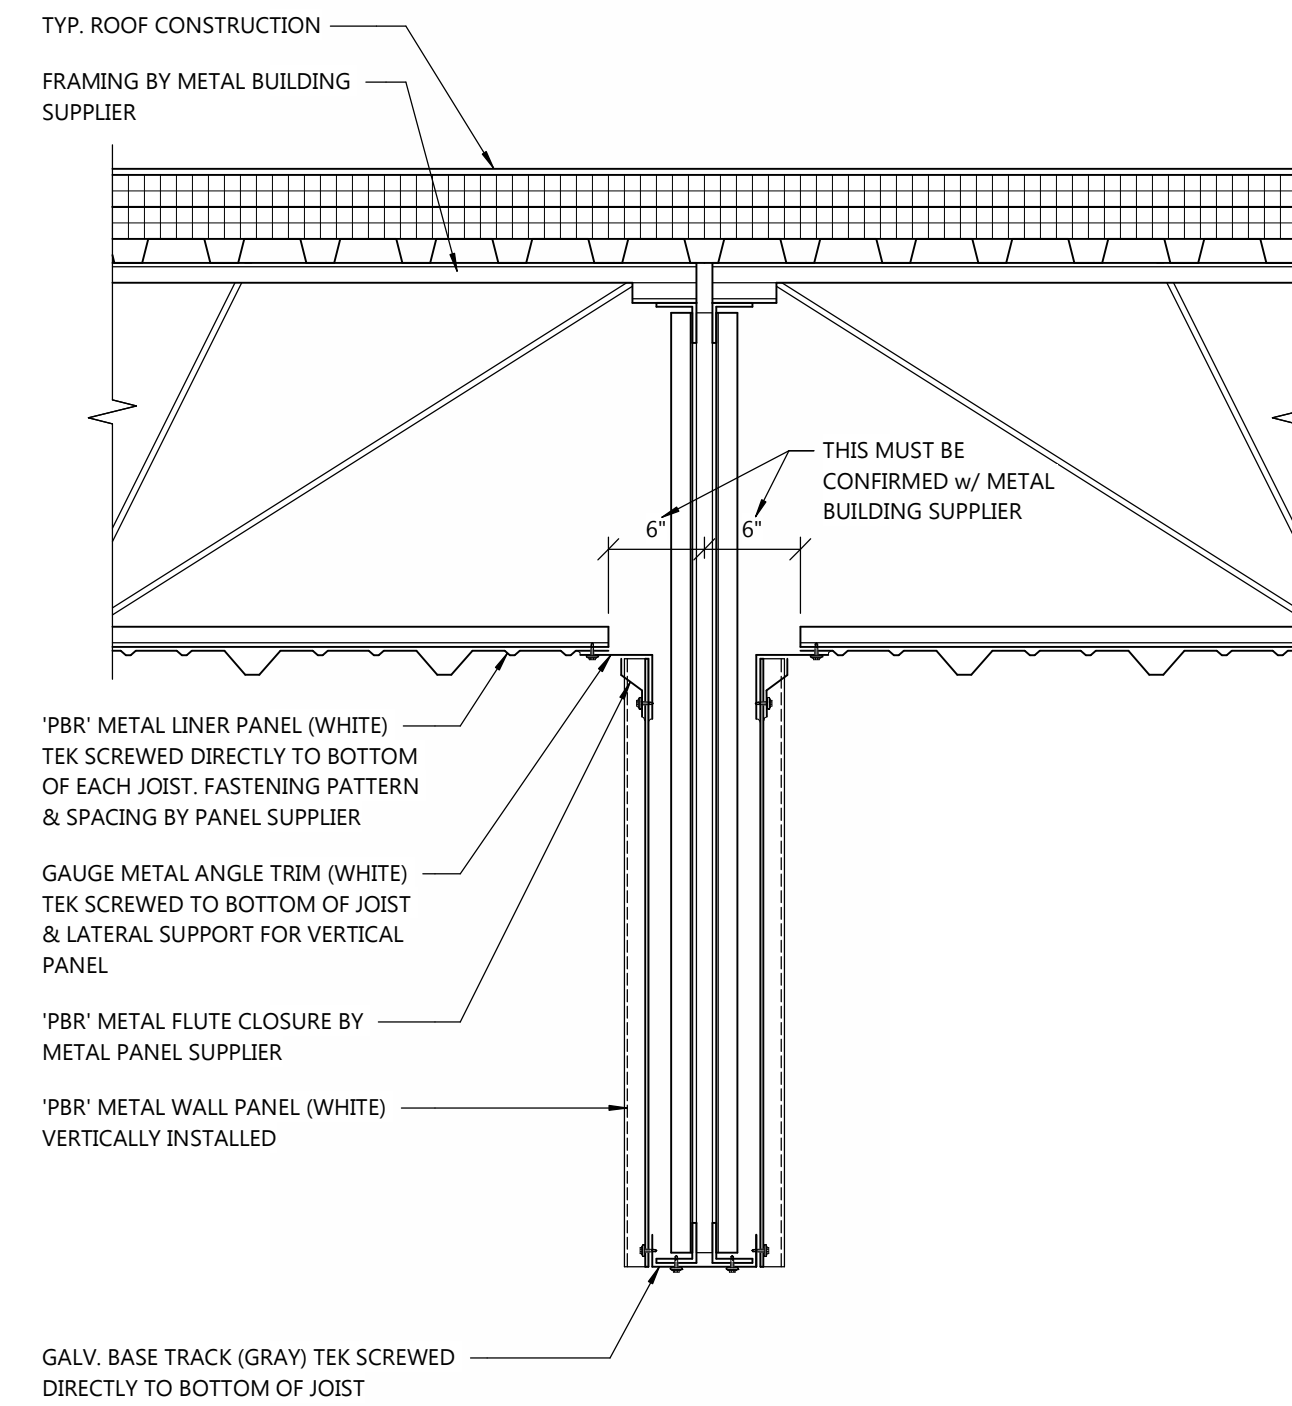

5
A4.1
DETAIL
SCALE: 1" = 1'-0"

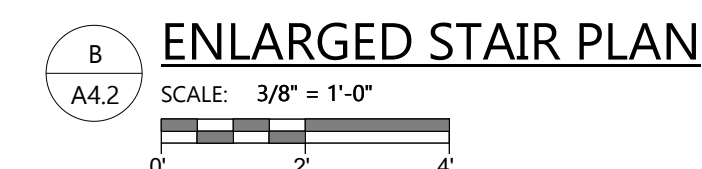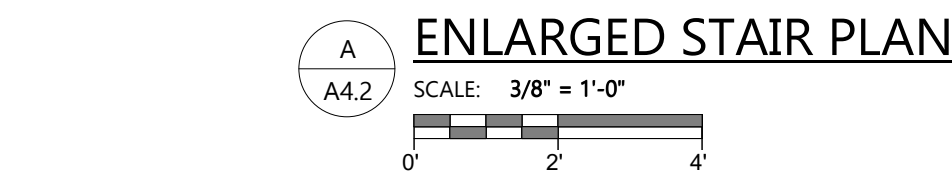   

- STAIRS AS SHOWN ARE FOR ARCHITECTURAL LAYOUT PURPOSES - FINAL DESIGN AND COMPONENTS BY STAIR SUPPLIER. SIZES SHOWN ARE MINIMUMS
- GENERAL CONTRACTOR SHALL FIELD VERIFY FINISH GRADES AT ALL EXTERIOR STAIRS PRIOR TO FABRICATING STEEL STAIRS
- SEE STRUCTURAL PLANS FOR METAL GRATE & STAIR TREAD SPECIFICATIONS

[illegible]

		HINGES			
X1	DESCRIPTION / FINISH	Ives	Hager	McKinney	Stanley
H1	STANDARD (626)	58B1	BB1279	TA2714	FB8179
H2	HEAVY (626)	58B1HW	BB1168	TA43786	FB8168
H3	STANDARD (630)	58B1 SS	BB1191	TA2314	FB8191
H4	HEAVY (630)	58B1HW SS	BB1199	TA43386	FB8199

LOCKETS				
X	DESCRIPTION / FINISH	Schlage ND Series (RHO)	Sargent 10X-Line (LL)	Best 9K (15D)
L1	ENTRANCE (626)	ND53DP	10XG05	9K AB
L2	CLASSROOM (626)	ND80DP	10XG07	9K R
L3	PRIVACY (626)	ND40S	10XU6S	9K L
L4	STOREROOM (626)	ND80DP	10XG04	9K D
L5	RIM CYLINDER (626)	20-022	34 SER05	1E-72
L6	INSTITUTION (626)	20-022	10XG17	9K N
L7	MORTISE CYLINDER (626)	20-001	40 SER05	1E-74
L8	DEADBOLT (626)	8660S	48 SER05	83T SERIES
L9	PASSAGE (626)	ND10S	10XG08	9K N
L10	EXIT ONLY-BLACK (626)	ND25S	10XG15-3	9K Y
L11	EXIT ONLY-LEVER (626)	ND12D	10XG13	9K NX
L12	MUMMY TRIM (626)	ND17U	10XU94-2	9K 1DT
Sargent 8200 (L)				
L13	DORMERY PRIVACY (626)	66 PRIVACY + 49 OC INDICATOR		

CLOSERS			
	DESCRIPTION / FINISH	LCN	
C1	PULL SIDE REG. (689)	4040 XP REG	Sargent 7501
C2	PULL SIDE HOLD-OPEN (689)	4040XP H	351 O 7501H
C3	PUSH SIDE REG. (689)	4040XP EDA	351 P10 PR7501
C4	PUSH SIDE w/ STOP (689)	4040XP CUSH	351 PS CP7501
C5	PUSH SIDE HOLD-OPEN (689)	4040XP CUSH	351 PSH UNP7501H
C6	PUSH SIDE EXT. DOORS (689)	4040XP SCUSH	351 CPS UNP7501H
C7	DROP PLATE (689)	4040XP-18PA	351-D 7788

		EXIT DEVICES		Sargeant		DTEX
DISCREPTION / FINISH		Med./Wide Size	Narrow Sille	Med./Wide Size	Narrow Sille	
1	RIM - EXIT ONLY (6226)	98,992/9240L	330Z	8813 ETL	8500 Series	
2	RIM - EXIT ONLY (6227)	98,992/9240L	331Z/360L	8813 ETL	8500 Series	
3	SURF. ROOF - LEVER (630)	98,992/9240L	332Z/360L	8813 ETL	8500 Series	
4	CON. LOCK - LEVER (626)	98,994/9240L	334Z/360L	8613 ETL	8500 Series	
5	RIM - EXIT ONLY (6330)			8813		
6	SURF. ROOF - LEVER (630)	98,992/9240L	332Z/360L	8813 ETL	8500 Series	
7	SURF. ROOF - LEVER (630)	98,992/9240L	332Z/360L	8813 ETL	8500 Series	
8	CON. LOCK - LEVER (626)	98,994/9240L	334Z/360L	8613 ETL	8500 Series	
9	RIM - EXIT ONLY - ALARM (630)	QEL-XLX-88,999L	34-55	56-8800		DTEX ECT-230X-W

When a cylinder lock is scheduled with an exit device, rim or sargeant should be provided.

WEATHERSTRIP, SWEEPS, & THRESHOLDS				
QTY	DESCRIPTION	National Guard	Reese	Pemko
T1	ALUM. THERMAL THRESHOLD	8424	5282A	252x2 FT
T2	S5 SADDLE THRESHOLD	-	2125	15455
T3	SS THERMAL THRESHOLD	-	-	252-355FG
T4	T4 THRESHOLD w/ SEAL	950N	-	-
SW1	SWEEP	200NA	772	315N
WS1	WEATHERSTRIP	160VA	D5106C	294AV
WS2	SMOKE SEAL	5050B	797B	588
ADB1	AUTO DOOR BOTTOM	335N	-	-

ACCESS CONTROL				
	DESCRIPTION	VonDupin	HES	Securiton
CS1	ELECT. STROKE AT ARM EXIT DEVICE (630)	8000-9600	9500/9600 series (24VDC)	N/A
CS2	ELECT. STROKE AT STD. LOCKSET (630)	8011 (24VDC)	1006 Series (24VDC)	UNL (24VDC)
CS3	ELECT. STROKE AT ST. LOCKSET (630)	8011 (24VDC)	1006 Series (24VDC)	UNL (24VDC)
P1	POWER TRANSFER (630)	1/2" ALUM. SPACER	8000-ASB	
P2	POWER TRANSFER (630)	1/2" ALUM. SPACER	8000-ASB	
P3	POWER TRANSFER (630)	1/2" ALUM. SPACER	8000-ASB	
CS4	MAG. HOLD IN SHEN (630)	SEMI		
CS5	CARD READER	SCN750		
DE	DOOR CONTACT	BY DOOR SECURITY CONTRACTOR - SEE ELEC. PLANS		
RE	REQUEST TO EXIT	BY DOOR SECURITY CONTRACTOR - SEE ELEC. PLANS		
MC	MAGNETIC LOCK	BY DOOR SECURITY CONTRACTOR - SEE ELEC. PLANS		
PS	POWER SUPPLY	BY DOOR SECURITY CONTRACTOR - SEE ELEC. PLANS		


- * ALL DOORS SHALL MEET AED A4 REQUIREMENTS
- * ALL DOOR THRESHOLDS SHALL NOT EXCEED 1/2" IN HEIGHT
- * ALL DOORS SHALL BE 1 1/2" MIN. FRAME AND DOOR THICKNESS. PROVIDE WRAP AROUND FRAMES AT STUD WALLS
- * PROVIDE SEALANT BOTH SIDES OF DOOR FRAMES, WHERE DIFFERENT MATERIALS MEET
- * GENERAL CONTRACTOR TO VERIFY SIZE OF ALL EQUIPMENT (ELECTRICAL, MECHANICAL, KITCHEN, LAUNDRY, ETC.) SELECTED FOR THE PROJECT TO ACCOMMODATE THE EQUIPMENT. EQUIPMENT SHALL BE OF AN ADEQUATE SIZE TO ACCOMMODATE INSTALLATION AND REPLACEMENT
- * VERIFY ALL ROUGH OPENING REQUIREMENTS WITH MANUFACTURERS DRAWINGS
- * VERIFY ALL ROUGH OPENING REQUIREMENTS WITH MANUFACTURERS DRAWINGS
- * DOOR, FRAME AND HARDWARE SCHEDULE TO BE PROVIDED BY HARDWARE SUPPLIER FOR A/E REVIEW - NUMBERING SYSTEM AND NOMENCLATURE SHALL BE AS PER A/E SCHEDULE
- * HARDWARE SUPPLIER IS RESPONSIBLE FOR COORDINATING KEYING REQUIREMENT WITH OWNER
- * ALUMINUM SUPPLIER SHALL FURNISH AND INSTALL ALL HARDWARE FOR ALUMINUM DOORS AS NOTED ON PLANS - THE SAME MANUFACTURERS AND MODELS SHALL BE USED FOR BOTH ALUMINUM AND OTHER DOOR HARDWARE
- * CONTRACTOR TO PROVIDE PRODUCTS AND SYSTEMS COMPLETELY WITH ALL SETBACKS AND FINISHES. PROVIDE FINISHES THROUGHOUT FOR COMPLETE INSTALLATION AND INTENDED USE AND EFFECT
- * DOOR UNDERCUTS, WHERE NOTED, SHALL BE 1" FROM FINISHED FLOOR, AT RATE OF 1/4" PER FOOT OF DOOR, FOR ALL OTHER LOCATIONS TRIMMED TO 1/4" AT ALL OTHER LOCATIONS; PROVIDE 1/2" DOOR UNDERCUT FROM FINISHED FLOOR
- * SEE ELECTRICAL PLANS FOR DOOR CARD READER LOCATIONS
- * SEE MECHANICAL PLANS FOR DOOR FAN COORDINATION PLANS FOR GUARD POST AND GOAL POST LOCATIONS

MANUFACTURER:

- RITE-HITE

MODEL:

- FASTRAX CLEAN HIGH PERFORMANCE DOOR

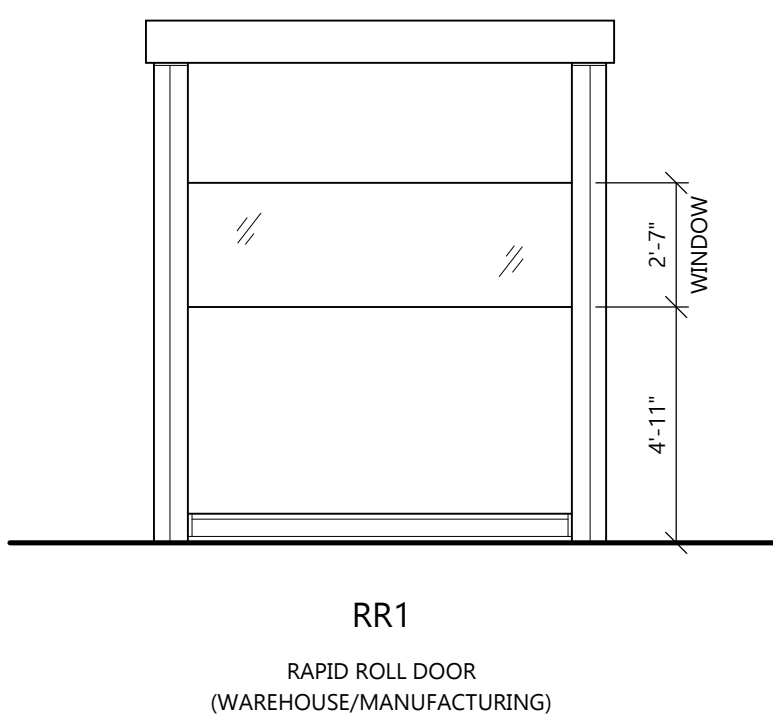


SCALE: 1/4" = 1'-0"



MANUFACTURER:



- CURRIES (APPROVED EQUIVALENT: STEELCRAFT)

- **CONSTRUCTION:**
 - **DOORS**
 - INTERIOR: 707 SERIES, MIN. 18 GA. w/ POLYSTYRENE CORE.
 - EXTERIOR: 707 SERIES, MIN. 16 GA. w/ POLYSTYRENE CORE & FLUSH TOP CAP, ASTM C1363 OPERABLE & VALUE = 2.1.
 - INTERIOR WHERE INDICATED BY AN "E" SUFFIX ON DOOR TAG, I.E., "MD1E": 747 SERIES, MIN. 16 GA. w/ 22 GA. STEENERS @ 6" CENTERS w/ FIBERGLASS INSULATION AND FLUSH TOP CAP, ASTM C1363 OPERABLE & VALUE = 1.8
 - **FRAMES**
 - "M" PROFILE w/ CONT. WELD FACE SEAMS AT FULL WIDTH OF JAMB
 - MIN. 16 ga. @ INTERIOR FRAMES
 - MIN. 14 ga. @ EXTERIOR FRAMES w/ URETHANE FOAM INSUL.
 - **GENERAL REQUIREMENTS**
 - ALL EXTERIOR DOORS AND FRAMES TO BE GALVANIZED
 - ALL DOORS & FRAMES TO HAVE BASED ON PRIMER FINISH
 - ALL DOORS & FRAMES TO BE REINFORCED AND PREPARED FOR HARDWARE
 - ALL REINFORCEMENT TO BE MIN. 12 ga.
 - PROVIDE WELDED-IN BASE ANCHORS
 - PROVIDE (1) SLICENERS PER JAMB ON ALL METAL DOOR FRAMES
 - PROVIDE BITUMINOUS COATING ON INT. FACE OF FRAMES IN MASONRY WALLS
 - PROVIDE METAL FRAME FOR LITES & GRILLES
 - PAINT LITE FRAMES TO MATCH DOOR FRAMES

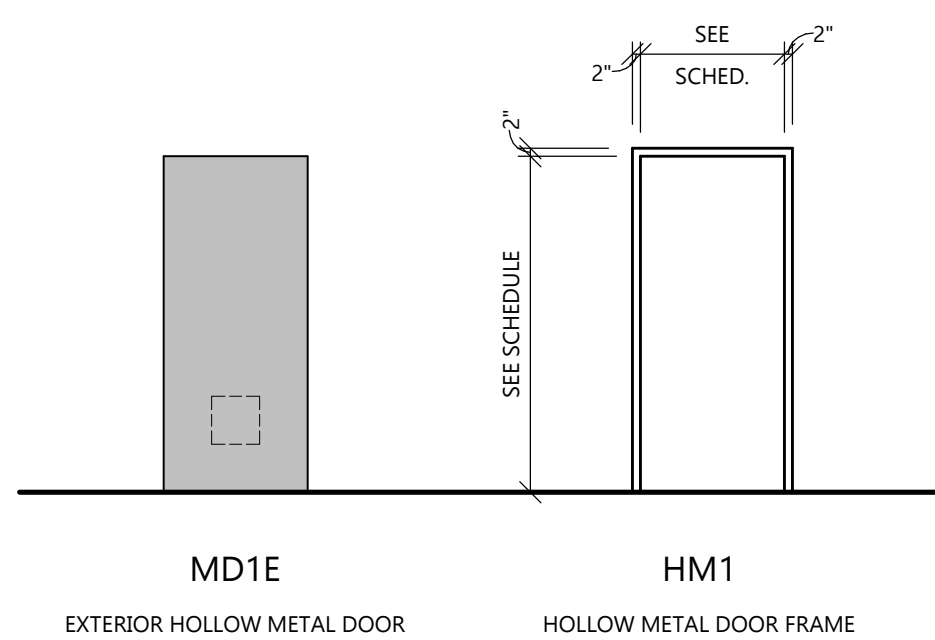

SCALE: 1/4" = 1'-0"

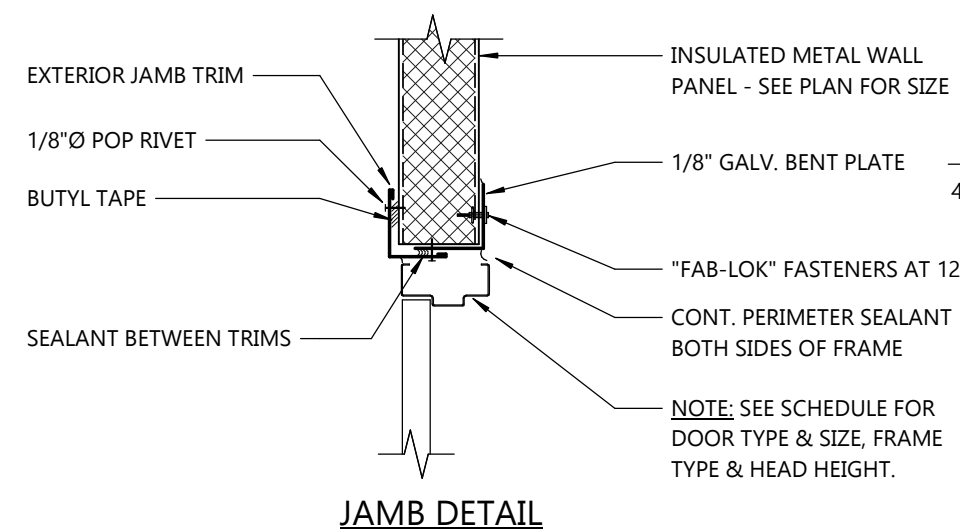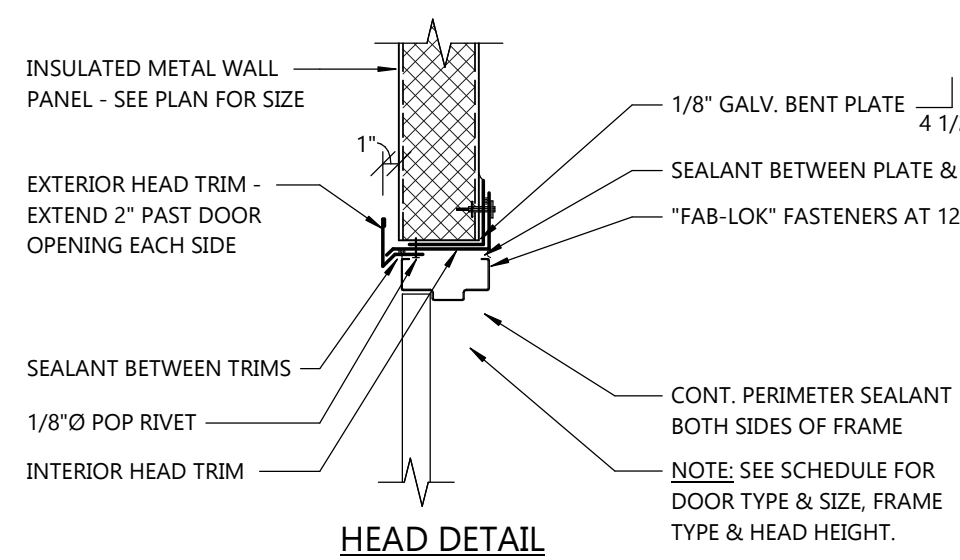

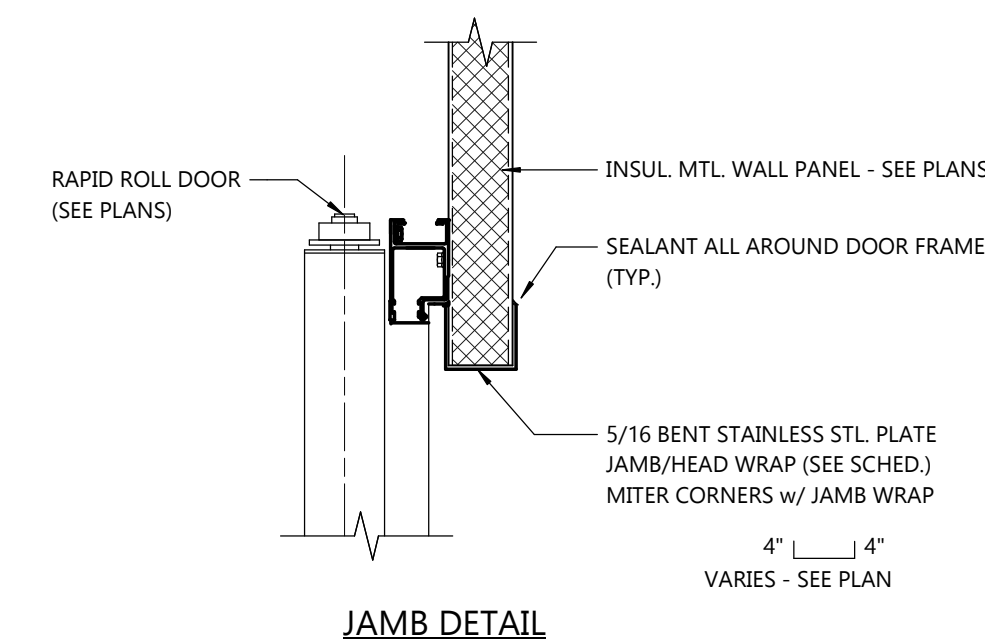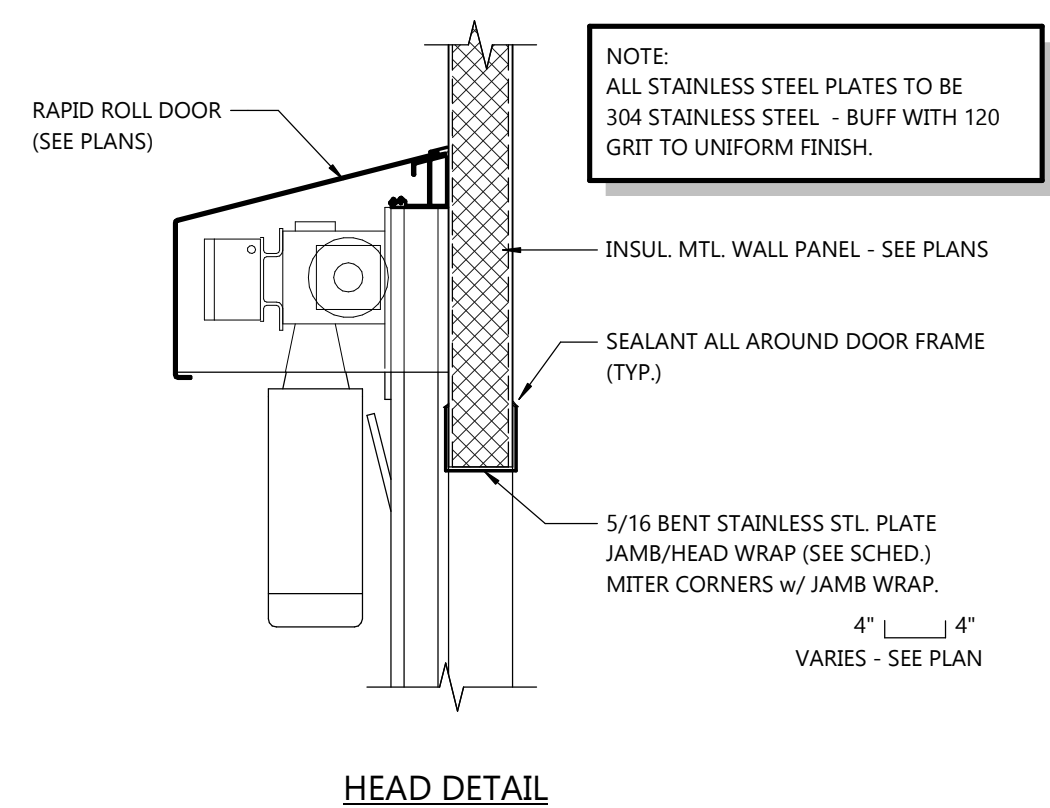


ROOM #	ROOM NAME	FLOORS			WALLS				CEILING	EXPOSED STRUCTURE		H.M.		REMARKS	
		FLOOR	BASE	CURB	NORTH	SOUTH	EAST	WEST		ROOF, FLOOR FRAMING	BELOW ROOF, FLOOR FRAMING	DOORS	FRAMES		
100	WAREHOUSE	SC-3	-	-	IMP-PL	IMP-PL/EXST.	IMP-PL	EXST.	LP	-	-	PA-1	PA-1	1	

GENERAL NOTES:

- ROOM FINISH SCHEDULE DESCRIBES FIELD APPLIED FINISHES ONLY, IT DOES NOT INCLUDE SHOP APPLIED COATINGS OR MANUFACTURER APPLIED FINISHES
- EXPOSED STRUCTURE DEFINITION FOR "ROOF, FLOOR FRAMING": INCLUDES ALL DECK, JOISTS, BEAMS & COLUMNS THAT ARE IN FRAMING DEPTH.
- EXPOSED STRUCTURE DEFINITION FOR "BELOW ROOF, FLOOR FRAMING": INCLUDES ALL EXPOSED STRUCTURE BELOW FRAMING DEPTH (COLUMNS, WALL FRAMING)
- PATCH/REPAIR SMALL BLEMISHES OR MOUNTING HOLES PRIOR TO PAINTING EXISTING WALL SURFACES.
- EXPOSED CONDUIT UNPAINTED UNLESS NOTED OTHERWISE.

FINISH GROUP		MANUF	STYLE	COLOR	SIZE	NOTES
FLOOR FINISHES						
SC-3	SEALED CONCRETE	ASHFORD	ASHFORD FORMULA	--	--	CONCRETE DENSIFIER TO REDUCE CONCRETE DUSTING AND INCREASE HARDNESS. USE AT WAREHOUSE OR ROOMS THAT WILL NOT HAVE FLOORING INSTALLED. WET CURED CONCRETE OR DISSIPATING CURING COMPOUND IS REQUIRED. INSTALLED OVER CLEAN/BARE CONCRETE.
WALL FINISHES						
EXIST.	EXISTING WALL FINISH	--	--	--	--	
IMP-PL	INSULATED METAL PANEL	METL-SPAN	CF-LIGHT MESA, STUCCO EMBOSSED	(G90) PVC PLASTISOL - IGLOO WHITE	--	
CEILING FINISHES						
LP	METAL LINER PANEL	--	--	MATCH IMP	--	METAL ROOF DECK ABOVE SHALL BE STANDARD DECK, GREY PRIME PAINT ONLY. NO FINISH PAINT
OTHER						
PA-1	METAL DOOR FRAME	SHERWIN WILLIAMS	--	MATCH EXISTING	--	

LOCATION	MFR	PRODUCT	DESCRIPTION
EXTERIOR			
WINDOW, DOOR, LOUVER OPENINGS	TREMCO	DYMONIC FC	ONE PART HIGH PERFORMANCE POLYURETHANE SEALANT
DIFFERENT MATERIALS MEET	TREMCO	DYMONIC FC	ONE PART HIGH PERFORMANCE POLYURETHANE SEALANT
ROOF OPENINGS	TREMCO	GUTTER SEAL	SYNTHETIC RUBBER AND RESIN SEALANT
THRESHOLDS TO SUBSTRATE	TREMCO	BUTYL SEALANT	MULTI-COMPONENT SEALANT
VENEER & CMU CONTROL JOINTS	TREMCO	DYMONIC FC	ONE PART HIGH PERFORMANCE POLYURETHANE SEALANT
INSULATED METAL PANEL, BASE CHANNEL TO FOUNDATION	TREMCO	BUTYL SEALANT	MULTI-COMPONENT SEALANT
	TREMCO	440 TAPE	BUTYL SEALANT TAPE
INSULATED METAL PANEL TO BASE CHANNELS	SIKA	SIKALASTOMER - 511	NON-SKINNING BUTYL SEALANT
INSULATED METAL PANEL TO PANEL JOINTS	SIKA	SIKALASTOMER - 511	NON-SKINNING BUTYL SEALANT
TRAFFIC SURFACE JOINTS (IE. CONCRETE PAVEMENT, SIDEWALKS & PADS)	TREMCO	VULKEM 45 SSL	ONE PART POURABLE SELF-LEVELING POLYURETHANE SEALANT
JOINTS IN TRAFFIC SURFACES SLOPING IN EXCESS OF 1/2" PER FOOT	TREMCO	DYMONIC FC	ONE PART HIGH PERFORMANCE POLYURETHANE SEALANT
INTERIOR			
INTERIOR DOOR AND WINDOW FRAMES	DAP	ALEX PLUS	PAINTABLE ACRYLIC LATEX - SILICONIZED SEALANT
WALL ANGLE AT SUSPENDED CEILINGS	DAP	ALEX PLUS	PAINTABLE ACRYLIC LATEX - SILICONIZED SEALANT
EXPOSED CONCRETE SAWCUT JOINTS	PPG	SL/85	TWO PART SELF-LEVELING POLYUREA SEALANT
CONCRETE CONSTRUCTION AND POUR JOINTS	PPG	SL/60	TWO PART SELF-LEVELING POLYUREA SEALANT
INSULATED METAL PANEL AND TOP OF CONCRETE CURB JOINT	TREMCO	DYMERIC 240FC	MULTI-COMPONENT CHEMICALLY CURING POLYURETHANE SEALANT
INSULATED METAL PANEL AND TRIM ELEMENTS JOINT	TREMCO	SPECTREM 2	ONE PART SILICONE SEALANT
INSULATED METAL PANEL FACE JOINTS WHERE INDICATED	TREMCO	SPECTREM 2	ONE PART SILICONE SEALANT

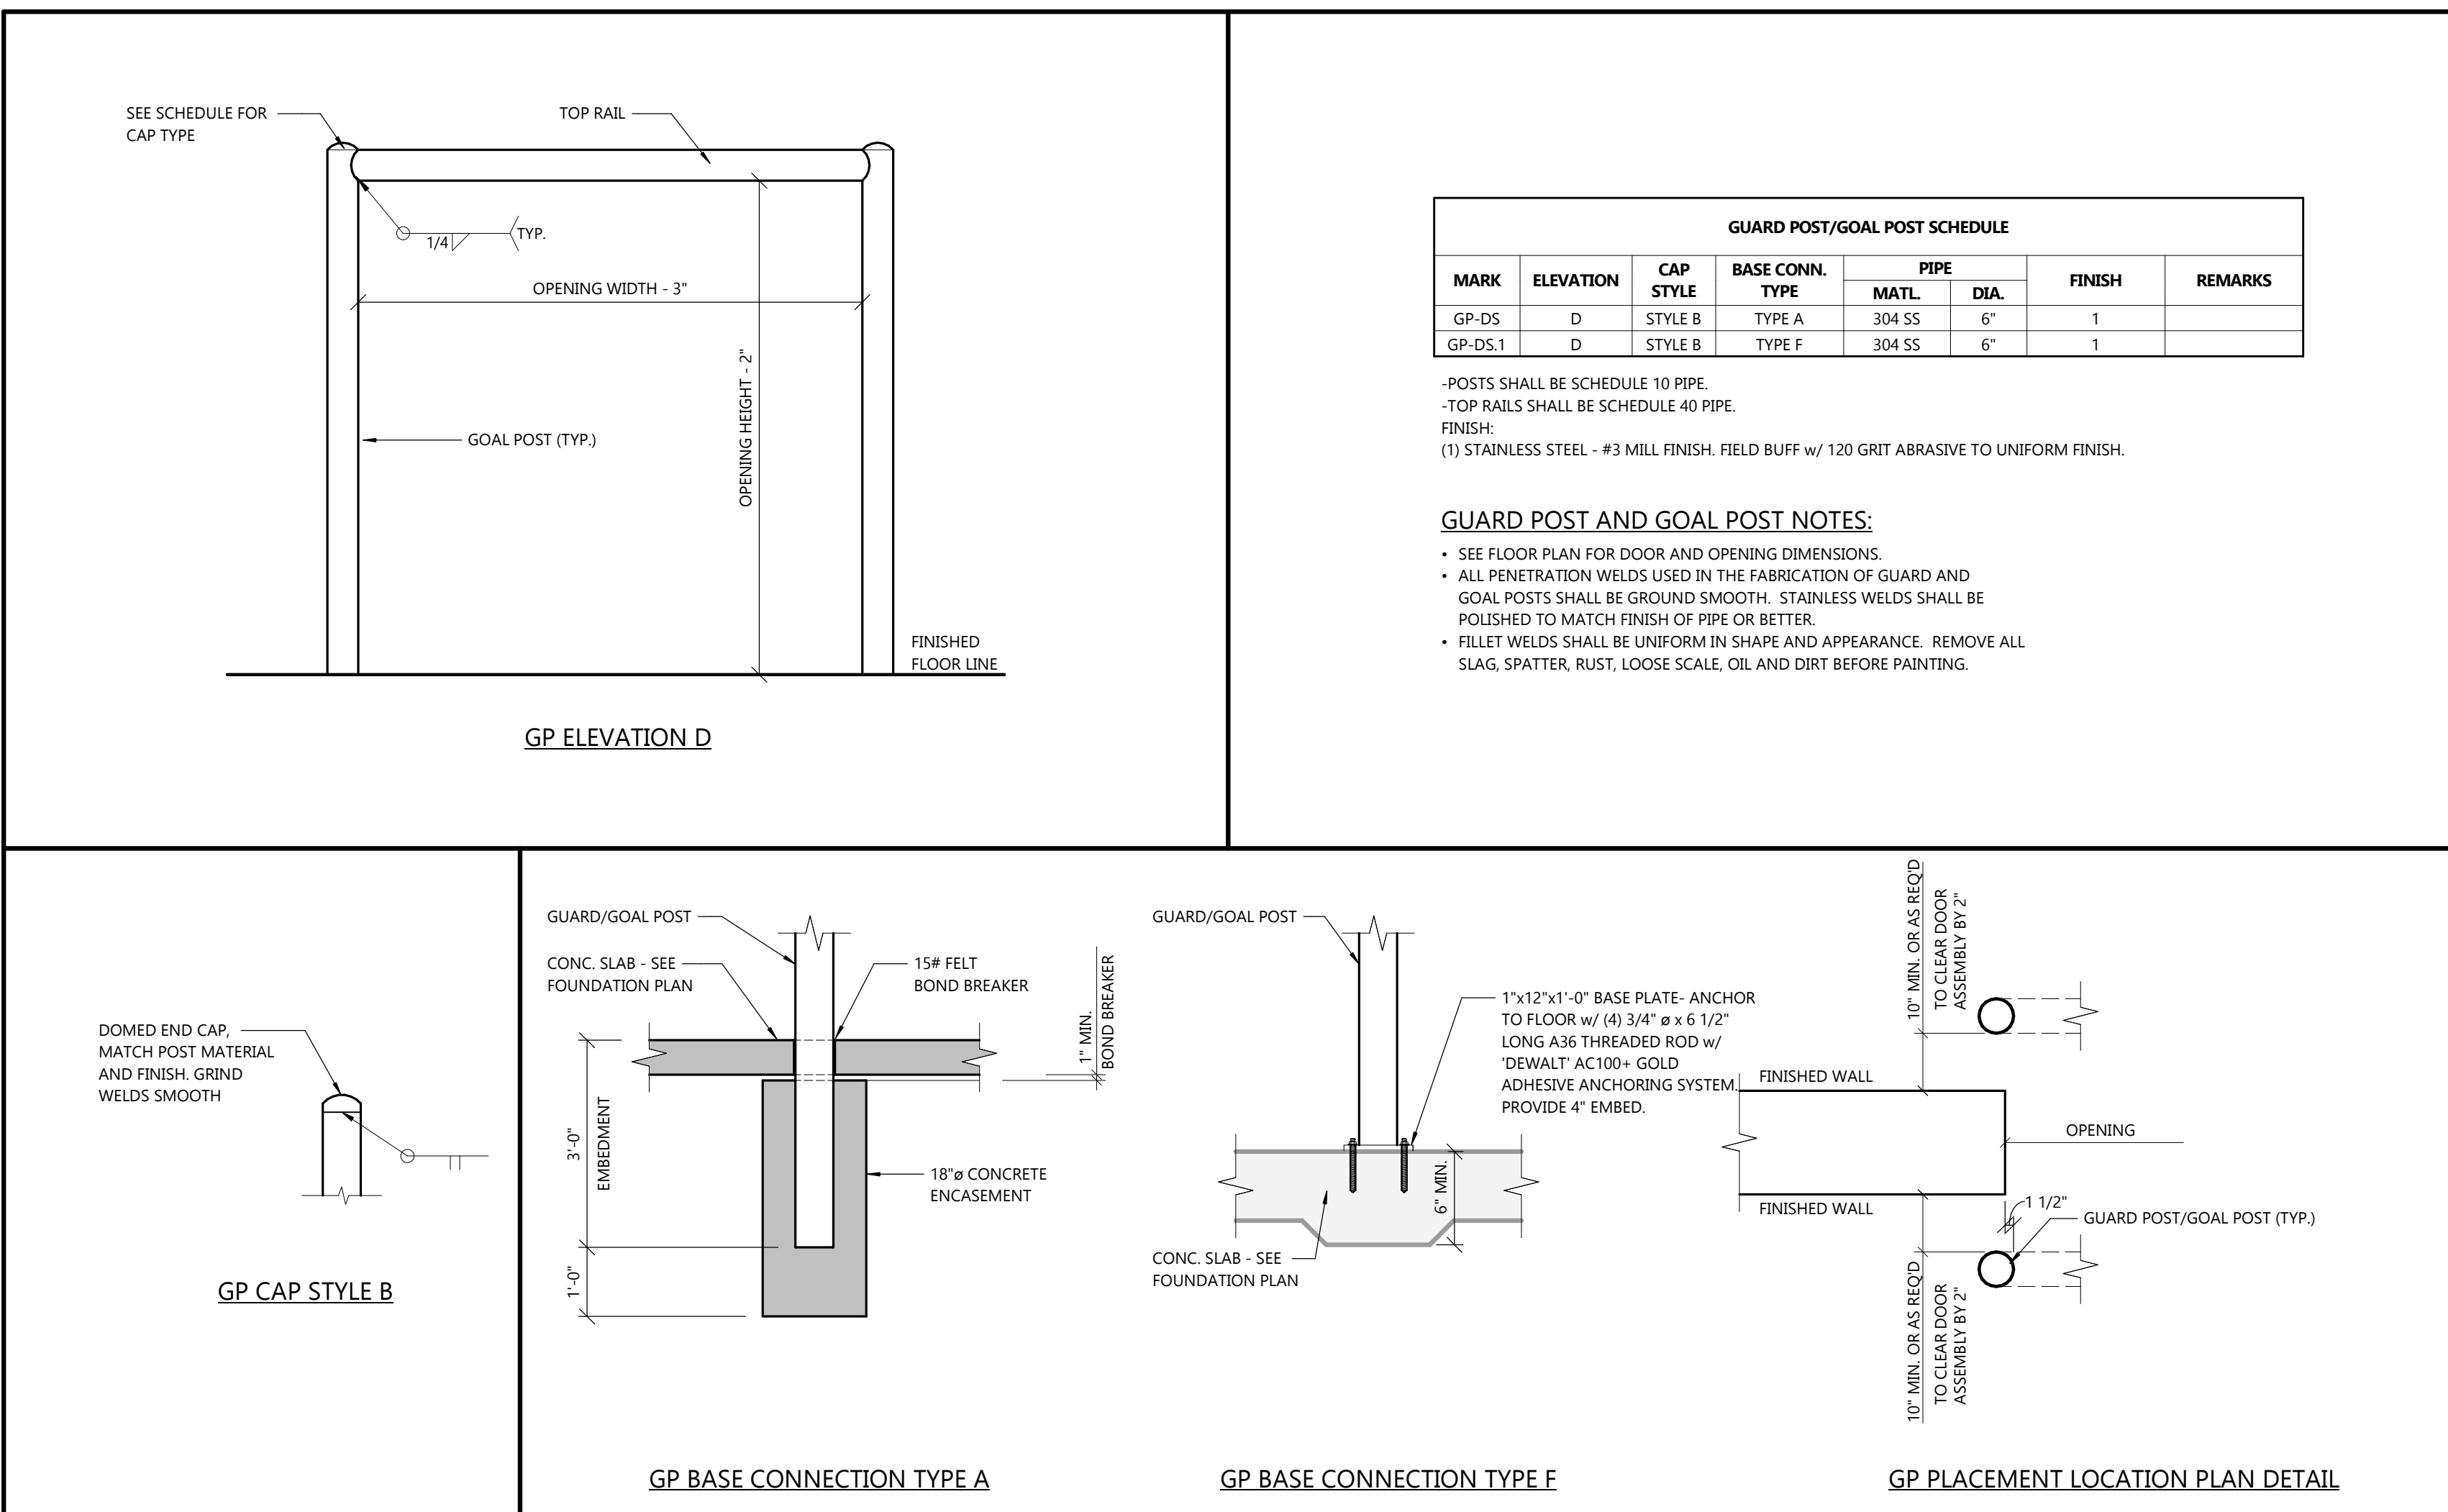

SCALE: 1/2" = 1'-0"

STORAGE WAREHOUSE EXPANSION FOR:
WEST POINT DAIRY PRODUCTS
570 NORTH 500 WEST • HYRUM, UT 84319

PROFESSIONAL SEAL

SHEET DATES

ISSUED FOR BUDGET

FB APR. 17, 2026

B NUMBER

250429500

SHEET NUMBER

A6.0

ARCHITECTURAL SCHEDULES

STRUCTURAL SPECIFICATIONS

BASIC STRUCTURAL REQUIREMENTS

- A. SEE DIVISION 00 PROCUREMENT AND CONTRACTING AND DIVISION 01 GENERAL REQUIREMENT FOR ADDITIONAL REQUIREMENTS.
- B. SUBSTITUTIONS.
1. SEE DIVISION 01 25 13 PRODUCT SUBSTITUTION PROCEDURES FOR ADDITIONAL REQUIREMENTS.
2. CONTRACTOR SHALL PROVIDE ALL SUPPORTING DATA AND ASSUME THE BURDEN OF PROOF THAT ANY SUBSTITUTE IS EQUIVALENT TO APPEARANCE, CONSTRUCTION, CAPACITY, AND PERFORMANCE. THE JUDGMENT OF EQUIVALENCY SHALL BE MADE BY THE ENGINEER AT THE TIME OF SHOP DRAWING REVIEW, NOT DURING BIDDING.
- C. SHOP DRAWINGS, PRODUCT DATA, TEST RESULTS, PROJECT CLOSEOUT DOCUMENTS.
1. SEE DIVISION 01 33 23 SHOP DRAWINGS, PRODUCT DATA, AND SAMPLES ON ARCHITECTURAL PLANS FOR ADDITIONAL REQUIREMENTS.
2. DESIGN DRAWINGS SHALL NOT BE USED AS SHOP DRAWINGS.
3. THE CONTRACTOR SHALL PREPARE A SCHEDULE OF ALL ITEMS TO BE SUBMITTED FOR A/E REVIEW. SCHEDULE SHALL SHOW ITEMS TO BE SUBMITTED AND ANTICIPATED DATE OF SUBMISSION. THIS SUBMITTAL SCHEDULE SHALL BE GIVEN TO THE A/E WITHIN 30 DAYS OF AWARD OF CONTRACT.
4. IF SHOP DRAWINGS REVISE AND/OR PROCESS, CONTACT A/E PRIOR TO SUBMITTING THE SHOP DRAWINGS TO MAKE THE APPROPRIATE ARRANGEMENT.
5. STRUCTURAL AND ARCHITECTURAL PLANS SHOW DIMENSIONS AND ELEVATIONS TO SIGNIFICANT WORKING POINTS. SHOP DRAWINGS DETAILERS AND SUPPLIERS ARE RESPONSIBLE FOR THE DETERMINATION OF ALL DIMENSIONS, PITCHES, ELEVATIONS, ETC., BEYOND THOSE NOTED ABOVE AS NECESSARY TO THOROUGHLY DETAIL/FABRICATE THEIR WORK. CONTACT A/E WITH ANY DISCREPANCIES FOUND.
6. IN NO CASE SHALL CHANGES BE MADE TO WORK SHOWN OR PROCEDURE SPECIFIED ON STRUCTURAL PLANS UNLESS FIRST APPROVED IN WRITING BY A/E. REVIEW OF SHOP DRAWINGS BY A/E DOES NOT CONSTITUTE ACCEPTANCE OF A DESIGN CHANGE. PROPOSED CHANGES BY CONTRACTOR MUST BE SUBMITTED IN RFI FORMAT AND MUST BE APPROVED IN THE SAME MANNER. CONTRACTOR REQUESTING CHANGE MAY BE BILLED ON A TIME AND EXPENSE BASIS FOR A/E FOR ALL REVISION WORK, FOR ALL NEW SKETCHES PREPARED, AND FOR ALL ADDITIONAL REVIEW TIME RELATED TO THE CHANGES.
7. CONSTRUCTION ADMINISTRATION SUBMITTAL LIST:
- a. SOILS AND SUBGRADE.
- i. GEOTECHNICAL REPORT
- ii. COMPACTION TEST REPORTS
- b. SOIL IMPROVEMENT.
- i. RAMMED AGGREGATE PIERS
- c. CONCRETE.
- i. MIX DESIGNS
- ii. TEST REPORTS FOR SLUMP, AIR ENTRAINMENT AND COMPRESSIVE STRENGTH
- iii. FOUNDATION POOR SCHEDULE, INCLUDING YARDS TO BE PLACED
- iv. SLAB ON GRADE POUR SCHEDULE, INCLUDING YARDS TO BE PLACED AND JOINT LAYOUT PLAN.
- v. REINFORCING FOR FOUNDATIONS
- vi. REINFORCING FOR SLAB ON GRADE, INCLUDING SUPPLEMENTAL REINFORCING AT REINFRANT CORNERS, OBSTRUCTIONS, AND DOORS/OPENINGS
- vii. FLOOR FLATNESS / LEVELNESS REPORTS
- viii. COLUMN ANCHOR BOLTS
- e. POST INSTALLED ANCHORS
- f. STEEL.
- i. STRUCTURAL STEEL
- ii. MISCELLANEOUS STEEL AT CURB MOUNTED ROOF TOP UNITS, AND H-FRAMED PENETRATIONS (SUBMIT ONLY AFTER QUALITIES, LOCATIONS, AND DIMENSIONS HAVE BEEN COORDINATED AND VERIFIED WITH CONTRACTOR REQUIRING PENETRATIONS)
- iii. MISCELLANEOUS STEEL FABRICATIONS
- g. STEEL STAIRS, HANDRAILS, AND GUARDRAILS AND CONNECTIONS TO STRUCTURE
- h. OPEN-WEB STEEL BAR JOISTS AND GIRDERS
- i. STEEL DECK
- j. INSULATED METAL PANEL AND CONNECTIONS
- k. PRE-ENGINEERED METAL BUILDING.
- i. PRELIMINARY REACTIONS AND BASE CONDITIONS
- ii. FINAL BUILDING REACTIONS AND DRAWINGS
- D. DELEGATED DESIGN SUBMITTALS.
1. CONTRACTOR SHALL FURNISH COMPLETE AND DETAILED SHOP DRAWINGS AND SUBMITTALS FOR REVIEW AND APPROVAL BY THE ENGINEER OF RECORD.
2. COMPONENTS AND SYSTEMS DESIGNED AS A DELEGATED DESIGN SUBMITTAL MUST INCLUDE A CALCULATION PACKAGE STAMPED AND SIGNED BY A REGISTERED PROFESSIONAL ENGINEER LICENSED IN THE STATE THE PROJECT WILL BE CONSTRUCTED PRIOR TO SUBMITTAL FOR APPROVAL TO THE ENGINEER OF RECORD.
3. THE FOLLOWING ITEMS ARE DESIGNATED AS DELEGATED DESIGN SUBMITTALS. DELEGATED DESIGN SUBMITTAL ITEMS SHALL BE SUBMITTED TO THE A/E FOR REVIEW. IN NO CASE SHALL ANY OF THE DELEGATED DESIGN SUBMITTAL ITEMS BE INSTALLED PRIOR TO REVIEW BY A/E AND APPLICABLE BUILDING OFFICIALS.
- a. SOIL IMPROVEMENT.
- ii. RAMMED AGGREGATE PIERS
- b. PRE-ENGINEERED METAL BUILDING.
- i. PRELIMINARY REACTIONS AND BASE CONDITIONS
- ii. FINAL BUILDING REACTIONS AND DRAWINGS
- E. FINISHING AND PAINTING
1. SEE DIVISION 09 91 00 FINISH AND PAINTING FOR ADDITIONAL REQUIREMENTS.
- F. GENERAL STRUCTURAL NOTES.
1. IN THE FOLLOWING NOTES, THE TERM "CONTRACTOR" REFERS TO ALL CONTRACTORS, SUBCONTRACTORS, AND SUPPLIERS ENGAGED IN THE EXECUTION OF WORK SHOWN ON THESE PLANS. THE TERM "A/E" REFERS TO EXCEL ENGINEERING, INC.
2. CONTRACTOR SHALL CROSS CHECK WITH ARCHITECTURAL, HVAC AND PLUMBING PLANS FOR ADDITIONAL DETAILS, DIMENSIONS, ELEVATIONS, OPENINGS, INSERTS, BRICK LEDGES, ETC. NOTIFY A/E OF ANY CONFLICTS BEFORE BEGINNING WORK.
3. IT IS SOLELY THE CONTRACTOR'S RESPONSIBILITY TO DETERMINE ERECTION PROCEDURE AND SEQUENCE IN ORDER TO ENSURE THE SAFETY OF THE BUILDING, WORKMEN, AND OCCUPANTS DURING CONSTRUCTION (MEANS & METHODS OF CONSTRUCTION). THIS INCLUDES, BUT IS NOT LIMITED TO, THE ADDITION OF SHORING, UNDERPINNING, AND TEMPORARY BRACING, AS NECESSARY. A/E MAY BILL CONTRACTOR ON A TIME AND EXPENSE BASIS FOR ADDITIONAL WORK, FOR ALL NEW SKETCHES, AND FOR ALL ADDITIONAL REVIEW TIME RELATED TO MEANS & METHODS.
4. WHERE DETAILS ARE CALLED FOR IN ONE AREA OF THE BUILDING THEY SHALL BE DUPLICATED AT SIMILAR CONDITIONS, UNLESS SHOWN OTHERWISE.
5. IN THE EVENT OF ANY CONFLICT BETWEEN PLANS, DETAILS, STRUCTURAL NOTES, STRUCTURAL AND ARCHITECTURAL DRAWINGS, AND SPECIFICATIONS, CONTRACTOR SHALL BRING THE CONFLICT TO THE A/E'S ATTENTION. CONTRACTOR SHALL BID THE MOST EXPENSIVE INSTALLATION CALLED OUT.
6. CONTRACTOR SHALL SURVEY THE EXISTING BUILDING FOR ALL DIMENSIONS, ELEVATIONS, AND CONDITIONS NEEDED TO PERFORM THE WORK SHOWN ON THESE PLANS. THIS INCLUDES VERIFYING DIMENSIONS, ELEVATIONS, & CONDITIONS SHOWN ON THE CONSTRUCTION DOCUMENTS. CONTRACTOR SHALL REPORT ANY NON-CONFORMANCE WITH DESIGN DRAWINGS TO THE A/E IMMEDIATELY.
7. ALL MEMBERS/WORK SHOWN ARE NEW UNLESS SPECIFICALLY NOTED "EXISTING".
8. REMOVE AND REPLACE AND/OR MODIFY ALL EXISTING CONSTRUCTION (ELECTRICAL, MECHANICAL, HVAC, STRUCTURAL, ARCHITECTURAL) AS REQUIRED IN ORDER TO PLACE NEW STRUCTURAL WORK SHOWN ON THESE DRAWINGS.
9. THESE STRUCTURAL PLANS DEPICT A STRUCTURAL FRAMING SYSTEM AND THE MAJOR COMPONENTS OF THAT SYSTEM. MINOR ITEMS SUCH AS POURSTOPS, DECK SUPPORT ANGLES AT COLUMNS, FRAMES AT FLOOR AND ROOF DECK OPENINGS, ETC, SHALL BE SUPPLIED BY THE CONTRACTOR AS NEEDED TO PROVIDE A COMPLETE SYSTEM.
10. BOTTOM OF FOOTING ELEVATION SHALL BE A MINIMUM OF 3'-0" BELOW ADJACENT EXTERIOR GRADE. NOTIFY A/E OF ANY FOOTING ELEVATION CHANGE REQUIRED IN ORDER TO PROVIDE 3'-0" FROST PROTECTION BEFORE PLACING FOOTINGS.
11. FOUNDATION SHORING AND/OR UNDERPINNING SHALL BE DESIGNED BY THE CONTRACTOR TO LIMIT HORIZONTAL AND VERTICAL MOVEMENT OF EXISTING CONSTRUCTION TO 3/16".
- G. POST-INSTALLED ANCHORS.
1. CONTRACTOR SHALL PROVIDE EXCEL ENGINEERING WITH SPECIFICATIONS AND DESIGN INFORMATION FOR ALL ALTERNATE ANCHORS. CONTRACTOR SHALL MAKE ARRANGEMENTS TO COMPENSATE EXCEL ENGINEERING FOR THE EXTRA WORK INVOLVED.
2. CLEAN SURFACES THOROUGHLY PRIOR TO INSTALLATION. PREPARE SURFACES USING THE METHODS RECOMMENDED BY THE MANUFACTURER FOR ACHIEVING THE BEST RESULTS FOR THE SUBSTRATE UNDER THE PROJECT CONDITIONS.
3. DO NOT BEGIN INSTALLATION UNTIL SUBSTRATES HAVE BEEN PROPERLY PREPARED. IF SUBSTRATE PREPARATION IS THE RESPONSIBILITY OF ANOTHER INSTALLER, NOTIFY CONTRACTOR OF UNSATISFACTORY PREPARATION BEFORE PROCEEDING.
4. INSTALL IN ACCORDANCE WITH MANUFACTURER'S INSTRUCTIONS AND RECOMMENDATIONS AND AS REQUIRED BY APPLICABLE CODE.
5. APPLY ANCHOR ITEMS NEATLY, WITH ANCHORS MOUNTED PLUMB AND LEVEL UNLESS OTHERWISE INDICATED.
6. EXCEL ENGINEERING RESERVES THE RIGHT TO REQUIRE THE ANCHOR MANUFACTURER'S REPRESENTATIVE TO DEMONSTRATE PROPER INSTALLATION PROCEDURES FOR POST-INSTALLED ANCHORS AND TO OBSERVE CONTRACTOR'S INSTALLATION PROCEDURES, AT NO EXTRA COST TO OWNER.
7. EXCEL ENGINEERING RESERVES THE RIGHT TO REQUIRE PULLOUT OR SHEAR TESTS TO DETERMINE ADEQUACY OF ANCHORS, AT NO EXTRA COST TO OWNER.

DIVISION 03 CONCRETE

03 30 00 CAST-IN-PLACE CONCRETE

- A. DESIGN AND CONSTRUCTION OF ALL CAST-IN-PLACE CONCRETE WORK SHALL CONFORM TO ACI 318 BUILDING CODE AND CRSI MANUAL OF STANDARD PRACTICE.
- B. PREPARATION OF THE SUBGRADE AND BASE COURSE/DRAINAGE LAYER FOR CONCRETE SLAB ON GRADE CONSTRUCTION TO BE PROVIDED PER MORE STRINGENT REQUIREMENTS OF GEOTECHNICAL REPORT OR CONSTRUCTION DOCUMENTS.
- C. DESIGN MIXES SHALL BE IN ACCORDANCE WITH ASTM C94.
1. SEE CONCRETE MIX DESIGN SCHEDULE ON PLANS.
2. SEE SPECIFICATIONS ON CIVIL PLANS FOR DESIGN MIXES ASSOCIATED WITH EXTERIOR CONCRETE FLATWORK SHOWN ON THE CIVIL PLANS.
- D. PLACE SLABS ON GRADE WITH POUR JOINT, CONSTRUCTION JOINT, OR SAW JOINT AS INDICATED ON THE PLANS. SAW CUT TO BE DONE WITH EARLY ENTRY SAW AND WITHIN 1 TO 4 HOURS AFTER CONCRETE IS PLACED.
- E. EXTERIOR SLABS ON GRADE SHALL BE SEPARATED FROM BUILDINGS WITH CONTINUOUS 1/2" FIBER EXPANSION JOINT AND/OR 1/4" FIBER EXPANSION JOINT AT DECORATIVE MASONRY UNITS. INTERIOR SLABS SHALL BE SEPARATED FROM FOUNDATION WALLS AND PIERS WITH FORM RELEASE AGENT, 15 LB. FELT OR AS DETAILED ON PLANS.
- F. MAINTAIN FLOOR LEVEL AT WALLS AND PITCH SURFACES UNIFORMLY TO DRAINS UNLESS INDICATED OTHERWISE ON PLANS.
- G. THE SLAB-ON-GRADE FLOOR FLATNESS/LEVELNESS SHALL MEET TO THE FOLLOWING CRITERIA:
1. TOP OF FLOOR ELEVATION SHALL BE WITHIN 3/4" OF DESIGN ELEVATION IN ACCORDANCE TO ACI
- H. CONCRETE CURING.
1. ALL CONCRETE IS TO BE CURED A MINIMUM OF 7 DAYS BY ONE OF THE FOLLOWING METHODS:
- a. CURE AND SEAL—SEE ARCHITECTURAL ROOM FINISH SCHEDULE FOR LOCATIONS
- i. SOLVENT BASED —PROVIDE EUCLID CHEMICAL SOLVENT BASED CURE AND & SEAL, DIAMOND CLEAR.
- ii. WATER BASED (VERY LOW ODOR, VOC CONTENT OF 88 g/L OR LESS) —PROVIDE EUCLID CHEMICAL WATER BASED CURE AND & SEAL, SUPER DIAMOND CLEAR VOX.
- I. CONCRETE FLOOR FINISHING: DO NOT PLACE ANY MATERIALS ON THE CONCRETE SURFACE THAT MAY CAUSE STAINING, ETCHING, OR
1. TROWEL FINISH: APPLY TO ALL INTERIOR MONOLITHIC SLAB SURFACES THAT ARE EXPOSED TO VIEW AND SLAB SURFACES TO BE COVERED WITH RESILIENT FLOORING, CARPET, PAINT, OR OTHER THIN FILM-FINISH COATING SYSTEM.
2. BROOM FINISH: APPLY TO ALL EXTERIOR STOOPS, LANDINGS, STEPS, AND RAMPS.
- J. CONCRETE WALLS SHALL HAVE JOINTS AS DETAILED ON PLANS.
- K. CONCRETE WALL FINISHING.
1. ALL EXPOSED FOUNDATION WALLS TO HAVE TIES AND FINS REMOVED AND RECEIVE THE FOLLOWING FINISHES PER ACI 301-20, 5.3.3.3 AND 5.3.3.4.
- a. AS-CAST FINISHES - USE FORM-FACING MATERIALS MEETING THE REQUIREMENTS OF 4.2.1.1. UNLESS OTHERWISE SPECIFIED, PRODUCE AS-CAST FORMED FINISHES TO COMPLY WITH THE FOLLOWING:
- i. SURFACE FINISH-3.0 (SF-3.0):
- (A) PATCH VOIDS LARGER THAN 3/4 IN. WIDE OR 1/2 IN. DEEP
- (B). REMOVE PROJECTIONS LARGER THAN 1/8 IN.

- (C). PATCH TIE HOLES
- (D). SURFACE TOLERANCE CLASS A AS SPECIFIED IN ACI 117
- L. BACKFILLING OF FOUNDATIONS.
1. BACKFILLING OF OPPOSITE SIDES OF UNBRACED FOUNDATION WALLS SHALL MAINTAIN A MAXIMUM 2 FOOT DIFFERENTIAL IN ELEVATION PRIOR TO ACHIEVING FINAL SPECIFIED GRADE.
2. TEMPORARY CONSTRUCTION BRACING DURING BACKFILLING.
- a. FOUNDATION WALLS WITH PERMANENT TOP LATERAL SUPPORTS SHALL BE TEMPORARILY BRACED UNTIL TOP SUPPORT SYSTEMS ARE INSTALLED. TEMPORARY CONSTRUCTION BRACING SHALL BE DESIGNED AND INSTALLED BY THE CONTRACTOR.
- b. THE BOTTOM OF THE BASEMENT WALLS SHALL BE TEMPORARILY BRACED UNTIL THE BASEMENT FLOOR SLAB IS IN PLACE. TEMPORARY CONSTRUCTION BRACING SHALL BE DESIGNED AND INSTALLED BY THE CONTRACTOR.
- M. ALL REINFORCING BARS SHALL BE ASTM A615 GRADE 60. THICKNESS OF CONCRETE COVER OVER REINFORCEMENT SHALL BE NOT LESS THAN THE THICKNESS OF CONCRETE IS DEPOSITED AGAINST THE GROUND WITHOUT THE USE OF FORMS AND NOT LESS THAN 1 1/2" FOR UP TO #5, 2" FOR #6 TO #10 IN ALL OTHER LOCATIONS. ALL REINFORCING SHALL BE LAPPED 48 DIAMETERS FOR UP TO #6 BARS, 62 DIAMETERS FOR #7 TO #9 BARS, 68 DIAMETERS FOR #10 BARS OR AS NOTED ON THE DRAWINGS AND EXTENDED AROUND CORNERS WITH CORNER BARS. PLACING AND DETAILING OF STEEL REINFORCING AND REINFORCING SUPPORTS SHALL BE IN ACCORDANCE WITH CRSI AND ACI MANUAL AND STANDARD PRACTICES. THE REINFORCEMENT SHALL NOT BE PAINTED AND MUST BE FREE OF GREASE/OIL, DIRT OR DEEP RUST WHEN PLACED IN THE WORK. ALL WELDED WIRE FABRIC SHALL MEET THE REQUIREMENTS OF ASTM A1064. WELDED WIRE FABRIC SHALL BE PLACED 3" FROM TOP OF SLAB UNLESS INDICATED OTHERWISE.
- N. COORDINATE INTERIOR CONCRETE HOUSEKEEPING PAD SIZES WITH RESPECTIVE CONTRACTORS. THE TOP OF PAD SHALL BE LEVEL UNLESS SPECIFIED OTHERWISE ON PLANS. THE THICKNESS INDICATED ON PLANS SHALL BE AT HIGHEST FLOOR ELEVATION FOR PADS ON TOP OF SLOPED FLOORS. PADS INSTALLED ON PRECAST DECK WITH TOPPING, TO BE PLACED AFTER PRECAST TOPPING HAS BEEN POURED.
- O. PROTECT FRESHLY PLACED CONCRETE FROM PREMATURE DRYING AND EXCESSIVE COLD OR HOT TEMPERATURES. IN HOT, DRY, AND WINDY WEATHER, APPLY AN EVAPORATION-CONTROL COMPOUND ACCORDING TO MANUFACTURER'S INSTRUCTIONS AFTER SCREEDING AND BULL FLOATING, BUT BEFORE POWER FLOATING AND TROWELING.
- P. CONTRACTOR SHALL ENGAGE A QUALIFIED INDEPENDENT TESTING AND INSPECTING AGENCY TO SAMPLE MATERIALS, PERFORM TESTS, AND SUBMIT TEST REPORTS DURING CONCRETE PLACEMENT. TESTS WILL BE PERFORMED ACCORDING TO ACI 301-20. CAST AND LABORATORY CURE ONE SET OF FOUR STANDARD CYLINDERS FOR EACH COMPOSITE SAMPLE FOR EACH DAY'S POUR OF EACH CONCRETE MIX UP TO 25 CU. YD., PLUS ONE SET FOR EACH ADDITIONAL 50 CU. YD. OR FRACTION THEREOF. PERFORM COMPRESSIVE STRENGTH TESTS ACCORDING TO ASTM C 39. TEST TWO SPECIMENS AT 7 DAYS AND TWO SPECIMENS AT 28 DAYS. PERFORM SLUMP TESTING ACCORDING TO ASTM C 143. PROVIDE ONE TEST AT POINT OF PLACEMENT FOR EACH COMPOSITE SAMPLE, BUT NOT LESS THAN ONE TEST FOR EACH DAY'S POUR OF EACH CONCRETE MIX. PERFORM ADDITIONAL TESTS WHEN CONCRETE CONSISTENCY APPEARS TO CHANGE.
- Q. TEST RESULTS WILL BE REPORTED IN WRITING TO ARCHITECT, READY-MIX PRODUCER, AND CONTRACTOR WITHIN 24 HOURS AFTER TESTS. REPORTS OF COMPRESSIVE STRENGTH TESTS SHALL CONTAIN THE PROJECT IDENTIFICATION NAME AND NUMBER, DATE OF CONCRETE PLACEMENT, NAME OF CONCRETE TESTING SERVICE, CONCRETE TYPE AND CLASS, LOCATION OF CONCRETE BATCH IN STRUCTURE, DESIGN COMPRESSIVE STRENGTH AT 28 DAYS, CONCRETE MIX PROPORTIONS AND MATERIALS, COMPRESSIVE BREAKING STRENGTH, AND TYPE OF BREAK FOR BOTH 7-DAY TESTS AND 28-DAY TESTS.

03 60 00 GROUT

- A. NONMETALLIC, SHRINKAGE-RESISTANT GROUT SHALL BE ASTM C1107/C1107M, FACTORY-PACKAGED, NONMETALLIC AGGREGATE GROUT, NONCORROSIVE AND NONSTAINING, MIXED WITH WATER TO A CONSISTENCY SUITABLE FOR APPLICATION.
- B. GROUT TO BE USED UNDER BEARING PLATES AND COLUMN BASE PLATES. PACK GROUT SOLIDLY BETWEEN BEARING PLATES AND PLATES SO NO VOIDS REMAIN. NEATLY FINISH EXPOSED SURFACES, PROTECT GROUT AND ALLOW TO CURE. COMPLY WITH MANUFACTURER'S WRITTEN INSTALLATION INSTRUCTIONS FOR GROUTING.
- C. MINIMUM COMPRESSIVE STRENGTH: 8000 PSI AT 28 DAYS.
- D. FOR GROUT USED TO FILL MASONRY CORES SEE DIVISION 04 MASONRY.

DIVISION 05 METALS

05 50 00 MISCELLANEOUS STEEL FABRICATIONS (INCLUDING STAIRS AND RAILINGS)

- A. SCOPE — THIS SECTION IS APPLICABLE ONLY TO THE FOLLOWING:
- a. STAIR STRINGERS
- b. STAIR LANDINGS, TREADS, AND RISERS (PAN, PLATE AND GRATING)
- c. FLOOR PLATES AND GRATINGS
- d. HANDRAILS AND GUARDRAILS
- e. ACCESS LADDERS
- f. GUARD POSTS AND GOAL POSTS
- g. DOOR WRAPS
- h. NON-STRUCTURAL STEEL COMPONENTS SPECIFIED BY OTHER DISCIPLINES U.N.O.
- B. MISCELLANEOUS STEEL FABRICATIONS SHALL BE OF MATERIAL AS LISTED BELOW AND SHALL BE DETAILED, FABRICATED AND DIRECTED TO COMPLY WITH AISC MANUAL, CURRENT EDITION. WELDERS SHOULD HAVE ALL LOCAL AND STATE CERTIFICATIONS WHERE APPLICABLE. ALL WELDING SHALL BE PERFORMED IN ACCORDANCE WITH AWS D1.6/D1.6M BY AN AWS CERTIFIED WELDER USING E70XX ELECTRODE. ALL BOLTS, NUTS AND WASHERS SHALL CONFORM TO REQUIREMENTS OF ASTM F1554 GRADE A325-N, INSTALLED IN SNUG-TIGHT CONDITION, U.N.O. ALL WORK PER THE AISC CODE OF STANDARD PRACTICE IN ACCORDANCE WITH LOCAL AND STATE CODES.
- C. MISCELLANEOUS STEEL
1. STEEL GRADES SHALL BE AS LISTED BELOW UNLESS INDICATED OTHERWISE:
- a. STEEL W-SHAPES: ASTM A992, Fy = 50 KSI MIN.
- b. STEEL M-SHAPES, S-SHAPES, MC-SHAPES, AND L-SHAPES: ASTM A36, Fy = 36 KSI MIN.
- c. STEEL HSS-RECTANGULAR: ASTM A500 Gr. C, Fy = 50 KSI MIN.
- d. STEEL PLATES AND BARS: ASTM A572 Gr. 50, Fy = 50 KSI MIN.
2. SHOP APPLIED COATINGS (SEE SHOP APPLIED COATING AND AESS REQUIREMENT SCHEDULE ON PLANS):
- a. STANDARD: ONE COAT OF MANUFACTURER'S STANDARD GRAY PRIMER, ALL FIELD WELDS TO BE CLEANED AND PRIMED TO MATCH.
- b. GALVANIZED: MINIMUM G60 HOT-DIP GALVANIZED COATING MEETING THE REQUIREMENTS OF ASTM A123 FOR SHAPES, PLATES, AND BARS; ASTM A153 FOR BOLTS, NUTS, AND WASHERS. ALL LOCATIONS WHERE THE SHOP APPLIED COATING HAS BEEN REMOVED/DAMAGED IN THE FIELD TO BE REPAIRED WITH ZRC GALVILITE GALVANIZING REPAIR COMPOUND PER THE MANUFACTURER'S APPLICATION INSTRUCTIONS. ALL FIELD WELDS TO BE GROUND TO BARE METAL PRIOR TO APPLYING REPAIR COMPOUND.
3. STAINLESS STEEL GRADES SHALL ADHERE TO SPECIFICATIONS IN TABLE A3.1 OF AISC 370 AND BE OF S30400 ALLOY UNLESS NOTED OTHERWISE. WELDERS SHOULD HAVE ALL LOCAL AND STATE CERTIFICATIONS WHERE APPLICABLE. ALL WELDING SHALL BE PERFORMED IN ACCORDANCE WITH AWS D1.6/D1.6M BY AN AWS CERTIFIED WELDER. ALL BOLTS, NUTS AND WASHERS SHALL CONFORM TO REQUIREMENTS OF ASTM F593 & ASTM F594 MATCHING ALLOY LISTED ABOVE, INSTALLED IN SNUG-TIGHT CONDITION, UNLESS NOTED OTHERWISE.
4. STAINLESS STEEL SHAPES SHALL MATCH THE AISC STANDARDS AS LISTED BELOW AND HAVE STANDARD MILL FINISH UNLESS NOTED OTHERWISE.
- a. STAINLESS STEEL HSS-RECTANGULAR AND PIPE: ASTM A554, Fy = 30 KSI MIN.
- b. STAINLESS STEEL PLATES: ASTM A240, Fy = 30 KSI MIN.
- c. STAINLESS STEEL RODS: ASTM A193, Fy = 30 KSI MIN.
- D. STEEL BAR GRATING AND STAIR TREADS.
1. STEEL BAR GRATING AND STAIR TREADS TO BE MONOLITHIC WELDED RECTANGULAR BAR GRATING WITH SMOOTH SURFACE. SEE PLANS FOR BAR DEPTH AND THICKNESS.
- a. TYPICAL UNLESS NOTED OTHERWISE: CARBON STEEL GW SERIES 19-W-4 SPACING.
- b. ADA ACCESSIBLE ROUTES AS SHOWN ON ARCHITECTURAL PLANS: CARBON STEEL CMW-4 SERIES 11-W-4 SPACING.
2. ALL GRATING ENDS TO BE BANNED.
3. GRATING TO BE FASTENED TO EACH SUPPORTING ELEMENT BY MONOLITHIC C8 SADDLE TYPE CLIPS PER MANUFACTURER RECOMMENDATIONS.
4. STAIR TREADS TO BE PREFABRICATED COMPLETE WITH END CARRIER PLATES AND CHECKER PLATE NOSING. FASTER TO STRINGERS PER MANUFACTURER RECOMMENDATIONS.
5. SHOP APPLIED COATINGS (SEE SHOP APPLIED COATING AND AESS REQUIREMENT SCHEDULE ON PLANS):
- a. GALVANIZED: MINIMUM G60 HOT-DIP GALVANIZED COATING MEETING THE REQUIREMENTS OF ASTM A653. ALL LOCATIONS WHERE THE SHOP APPLIED COATING HAS BEEN REMOVED/DAMAGED IN THE FIELD TO BE REPAIRED WITH ZRC GALVILITE GALVANIZING REPAIR COMPOUND PER THE MANUFACTURER'S APPLICATION INSTRUCTIONS. ALL FIELD WELDS TO BE GROUND TO BARE METAL PRIOR TO APPLYING REPAIR COMPOUND.

DIVISION 07 THERMAL AND MOISTURE PROTECTION

07 41 13 INSULATED METAL PANELS:

- A. SEE ARCHITECTURAL SPECIFICATIONS.

DIVISION 13 SPECIAL CONSTRUCTION

13 34 19 PRE-ENGINEERED METAL BUILDING (DESIGN BUILD)

- B. SEE ARCHITECTURAL SPECIFICATIONS.

13 34 19 PRE-ENGINEERED METAL BUILDING (BID SPEC)

- A. SEE ARCHITECTURAL SPECIFICATIONS.

DIVISION 05 - SHOP APPLIED COATING AND AESS REQUIREMENT SCHEDULE				
05 12 00 STRUCTURAL STEEL FRAMING				
ITEM	SHOP APPLIED COATING			SEE SHOP APPLIED COATING PLANS
	PRIME TO MATCH EXISTING	GALVANIZED	EPOXY	
INTERIOR				
COLUMNS	X			
BEAMS/GIRDERS	X			
BRACES/STRUTS	X			
GIRTS/PURLINS	X			
EDGE ANGLES	X			
WALL LINTELS	X			
05 21 00 STEEL JOIST FRAMING				
ITEM	SHOP APPLIED COATING			SEE SHOP APPLIED COATING PLANS
	PRIME TO MATCH EXISTING	GALVANIZED	EPOXY	
INTERIOR				
JOISTS/GIRDERS/BRIDGING	X			
05 31 00 STEEL DECKING				
ITEM	SHOP APPLIED COATING			SEE SHOP APPLIED COATING PLANS
	PRIME TO MATCH EXISTING	GALVANIZED	EPOXY	
INTERIOR ROOF DECKING				
TOP SURFACE	X			
BOTTOM SURFACE	X			
05 50 00 MISCELLANEOUS METAL FABRICATIONS				
ITEM	SHOP APPLIED COATING			SEE SHOP APPLIED COATING PLANS
	PRIME TO MATCH EXISTING	GALVANIZED	EPOXY	
INTERIOR MISCELLANEOUS METALS				
GUARD POST/GOAL POST	SEE GUARD POST/ GOAL POST SCHEDULE			
DOOR WRAPS	SEE DOOR SCHEDULE			
EXPOSED EXTERIOR MISCELLANEOUS METALS				
ALL EXTERIOR MISCELLANEOUS...		X		
GRATINGS		X		
HANDRAILS		X		
GUARDRAILS		X		
GUARD POST/GOAL POST	SEE GUARD POST/ GOAL POST SCHEDULE			
DOOR WRAPS	SEE DOOR SCHEDULE			
EXPOSED EXTERIOR STAIRS AND LANDINGS				
POSTS		X		
STRINGERS/BEAMS		X		
FLOOR PLATE		X		
GRATINGS - LANDING/TREAD		X		
HANDRAILS		X		
GUARDRAILS		X		
ALL STAINLESS STEEL				
PROVIDE STANDARD MILL FINISH WITH NO SHOP APPLIED COATING (U.N.O.)				

CONCRETE MIX DESIGN SCHEDULE

GENERAL NOTES:

- DESIGN MIXES SHALL BE IN ACCORDANCE WITH ASTM C94.
- SPECIFIED MINIMUM COMPRESSIVE STRENGTH IS MEASURED AT 28 DAYS.
- LIMIT PERCENTAGE BY MASS, OF CEMENTITIOUS MATERIALS OTHER THAN PORTLAND CEMENT IN CONCRETE WITH EXPOSURE CLASS F50 AS FOLLOWS:
 - FLY ASH OR OTHER POZZOLANS: 25%
 - SLAG CEMENT: 50%
 - TOTAL OF FLY ASH OR OTHER POZZOLANS: 35% WITH FLY ASH OR POZZOLANS NOT EXCEEDING 25%
 - TOTAL OF FLY ASH OR OTHER POZZOLANS: 35% WITH FLY ASH OR POZZOLANS NOT EXCEEDING 25%
- ADMITTURE REQUIREMENTS
 - ALL CONCRETE EXPOSED TO WEATHER SHALL BE AIR-ENTRAINED. SPECIFIED VALUE SHALL BE MET AT POINT OF DELIVERY.
 - HIGH-RANGE WATER-REDUCING OR PLASTICIZING ADMIXTURE PER SCHEDULE NOTES.
 - CALCIUM CHLORIDE SHALL NOT BE USED.
 - NO OTHER ADMIXTURES SHALL BE USED WITHOUT APPROVAL OF EXCEL ENGINEERING, INC.

SCHEDULE NOTES:

(1) SLUMP LIMIT SHALL BE 8" ± 1" FOR CONCRETE WITH VERIFIED SLUMP OF 2" TO 4" BEFORE ADDING HIGH-RANGE WATER-REDUCING ADMIXTURE OR PLASTICIZING ADMIXTURE.

MIX ID	APPLICABLE ELEMENTS	CONCRETE		ADMIXTURES		EXP. CLASS. PER ACI 318	REMARKS
		MIN. COMP. STRENGTH (F'c)	MAX. W/C RATIO	MAX. AGG. SIZE (1)	AIR CONTENT	ADDITIONAL REQUIRED	
A	• CONT. FOOTINGS • SPREAD FOOTINGS • GRADE BEAMS	3,000 PSI	-	1-1/2"	4" ± 1"	-	F0
A0	• SLURRY/FLOWABLE FILL BELOW FOUNDATIONS	250 PSI	-	-	-	-	F0 **comp. strength shall be greater of this spec. or geotech report**
B	• INTERIOR SLABS ON GRADE ≤ 6" THICK • HOUSEKEEPING PADS ≤ 6" THICK	3,500 PSI	-	3/4"	4" ± 1"	-	F0
B1	• INTERIOR CURBS	3,500 PSI	-	3/4"	4" ± 1"	-	F0 SHRINKAGE REDUCING ADMIXTURE (SRA) WITH A DOSSAGE RATE OF 2% BY WEIGHT OF CEMENTITIOUS MATERIAL
C	• INTERIOR SLABS ON GRADE > 6" THICK • HOUSEKEEPING PADS > 6" THICK	4,000 PSI	-	1-1/2"	4" ± 1"	-	F0
G	• EXTERIOR WALLS • EXTERIOR PIERS • EXTERIOR COLUMNS • EXTERIOR BEAMS • EXTERIOR ELEVATED CIP SLABS	4,500 PSI	0.45	3/4"	4" ± 1"	6.0% ± 1.5%	F2
H	ALL CONCRETE EXPOSED TO FREEZING/THAWING, DEICING SALTS OR ABUTTED TO PAVED SURFACES WHERE DEICING SALTS MAY BE USED, SUCH AS: • EXTERIOR WALLS, PIERS, COLUMNS, BEAMS • EXTERIOR ELEVATED CIP SLABS	5,000 PSI	0.40	3/4"	4" ± 1"	6.0% ± 1.5%	F3



Always a Better Plan

100 Camelot Drive
Fond du Lac, WI 54935
920-926-9800
excelengineer.com

PROJECT INFORMATION

STORAGE WAREHOUSE EXPANSION FOR:
WEST POINT DAIRY PRODUCTS
570 NORTH 500 WEST • HYRUM, UT 84319

PROFESSIONAL SEAL

SHEET DATES

ISSUED FOR BUDGET

IFB APR. 17, 2026

JOB NUMBER

250429500

SHEET NUMBER

S0.1

SHEET INDEX


SHEETS BELOW INTENDED TO BE PRINTED IN COLOR. REFER TO DIGITAL FORMAT DRAWINGS IF PRINTED GRAYSCALE TO ENSURE SCOPE CLARITY.

NUMBER	SHEET NAME / DESCRIPTION
STRUCTURAL	
S0.1	SPECIFICATIONS
S0.2	DESIGN CRITERIA
S1.1	FOUNDATION PLAN
S1.15	CONCRETE FLOOR SLAB PLAN
S2.0	FOUNDATION SCHEDULES
S2.1	PEMB ANCHOR BOLT SETTING PLAN
S2.2	SLAB ON GRADE SCHEDULES AND DETAILS
S2.3	FOUNDATION DETAILS

NOT FOR CONSTRUCTION

STRUCTURAL DESIGN CRITERIA


GOVERNING CODES: 2021 INTERNATIONAL BUILDING CODE (IBC) ALL LOADS SHOWN ON PLANS ARE UNFACTORED LOAD COMBINATION UTILIZED IN DESIGN ARE FROM ASCE 7-16			
ROOF SNOW LOAD (PER SECTION 1608 AND ASCE 7-16 SECTION 7)			
GROUND SNOW LOAD (Pg) (PER FIGURE 1608.2)			50 PSF
FLAT ROOF SNOW LOAD (Pf)			35 PSF
MINIMUM SNOW LOAD (Pm)			20 PSF
SLOPED ROOF SNOW LOAD (Ps)			35 PSF
SNOW EXPOSURE FACTOR (Ce)			1.0
SNOW IMPORTANCE FACTOR (Is)			1.0 (RISK CATEGORY II)
THERMAL FACTOR (Ct)			1.0
UNBALANCED ROOF SNOW LOADS PER ASCE 7-16 (SECTION 7.6)			
SNOW DRIFT PER ASCE 7-16 (SECTIONS 7.7 AND 7.8)			
SLIDING SNOW PER ASCE 7-16 (SECTION 7.9)			
RAIN-ON-SNOW SURCHARGE LOAD PER ASCE 7-16 (SECTION 7.10)			
ROOF RAIN LOAD (PER SECTION 1611 AND ASCE 7-16 SECTION 8)			
DESIGN RAINFALL INTENSITY FOR 100YR - 1 HR STORM (I)			3.58 IN/HR
ROOF LIVE LOAD			
MINIMUM ROOF LIVE LOAD PER SECTION 1607.14			20 PSF
ROOF DEAD LOADS AND DEFLECTION REQUIREMENTS			
PRE-ENGINEERED METAL BUILDING	DEAD LOAD PER MANUFACTURER REQUIREMENTS		
	COLLATERAL - PRIMARY		10 PSF
	COLLATERAL - SECONDARY		10 PSF
	ROOF DEFLECTION REQUIREMENTS		L/240 LL L/180 TL
FLOORS AND MEZZANINES			
		UNIFORM	CONCENTRATED
		(See Note 1 for LL > 50 PSF)	
SLAB ON GRADE	LIVE LOAD		
	STORAGE	SEE FOUNDATION PLAN	
	OFFICE - LIVE LOAD + 20 PSF PARTITION	70 PSF	2,000 LBS
	EQUIPMENT	75 PSF	40 PSF + ACT. EQUIP. WT.
	WALKWAYS AND ELEVATED PLATFORMS	60 PSF	
	LOBBIES AND FIRST FLOOR CORRIDORS	100 PSF	2,000 LBS
	ASSEMBLY AREAS WITH FIXED SEATS	60 PSF	
STAIRS AND EXITS			
LIVE LOAD		100 PSF	300 LBS AT TREAD
DEAD LOAD		25-50 PSF	
DEFLECTION REQUIREMENTS (MIN.)		L/360 LL L/240 TL	
RAILINGS AND LADDERS			
LIVE LOAD ON GUARD RAILINGS PER ASCE 7-16 SECTION 4.5.1 (PUBLIC AREAS)		50 PLF (ANY DIRECTION)	200 LBS (ANY DIRECTION)
LIVE LOAD ON HAND RAILINGS PER ASCE 7-16 SECTION 4.5.1 (PUBLIC AREAS)		50 PLF (ANY DIRECTION)	200 LBS (ANY DIRECTION)
LIVE LOAD ON BALUSTERS, PANEL FILLERS, AND GUARDRAIL INFILL			50 LBS (ANY DIRECTION)
LIVE LOAD ON GRAB BAR SYSTEMS PER ASCE 7-16 SECTION 4.5.2			250 LBS (ANY DIRECTION)
NOTE: UNIFORM AND CONCENTRATED LOADS/HANDRAIL AND GUARDRAIL LOADS ARE NOT REQUIRED TO ACT CONCURRENTLY.			
LIVE LOAD ON LADDERS PER ASCE 7-16 SECTION 4.5.4			300 LBS FOR EVERY 10 FT. OF LADDER 100 LBS AT EXTENSIONS (ANY DIRECTION)
LATERAL			
WIND LOADS AND DESIGN DATA	ULTIMATE WIND SPEED = 103 MPH (RISK CATEGORY II) WIND EXPOSURE = 'C' ANALYSIS PROCEDURE: DIRECTIONAL PROCEDURE PER ASCE 7-16 CHAPTER 27 INTERNAL PRESSURE COEFFICIENT = ± 0.18 COMPONENT AND CLADDING PRESSURES/SUCTIONS FOR EFFECTIVE AREAS ≤ 10 S.F. AS FOLLOWS: EDGE STRIPS - ROOF: (0.20) = 8.1 FT. (0.6H) = 24.3 FT. WALL: (a) = 5.7 FT. ROOF ZONE 1 PRESSURE = 16.0 PSF. SUCTION = -22.1 PSF ROOF ZONE 2 PRESSURE = 16.0 PSF. SUCTION = -38.5 PSF ROOF ZONE 3 PRESSURE = 16.0 PSF. SUCTION = -50.8 PSF ROOF ZONE 4 PRESSURE = 16.0 PSF. SUCTION = -49.2 PSF WALL ZONE 1 PRESSURE = 22.1 PSF. SUCTION = -23.9 PSF WALL ZONE 3 PRESSURE = 22.1 PSF. SUCTION = -23.9 PSF PRESSURES/SUCTIONS MAY BE REDUCED FOR AREAS > 10 S.F. PER ASCE 7-16 MINIMUM WIND LOADS PER ASCE 7-16 MEMBERS: 16.0 PSF ON HORIZONTAL AND VERTICAL PROJECTION COMPONENT AND CLADDING: ± 16.0 PSF NORMAL TO SURFACE		
SEISMIC LOADS AND DESIGN DATA	SEISMIC IMPORTANCE FACTOR, I _e = 1.0 (RISK CATEGORY = II) MAPIED RESPONSE COEFFICIENTS = SPECTRAL RESPONSE COEFFICIENTS = SITE CLASS = E (ASSUMED) SEISMIC DESIGN CATEGORY = D ANALYSIS PROCEDURE: EQUIVALENT LATERAL FORCE PER ASCE 7-16 SECTION 12.8 RECOMMENDED SEISMIC FORCE RESISTING SYSTEM AND SEISMIC DESIGN COEFFICIENTS (PER ASCE 7-16 TABLE 12.2-1) AS FOLLOWS: SEISMIC FORCE RESISTING SYSTEM = B3 STEEL ORDINARY CONCENTRICALLY BRACED FRAMES EAST-WEST DIRECTION OVERSTRENGTH FACTOR R = 3.25 DEFLECTION AMPLIFICATION FACTOR C _d = 3.25 NORTH-SOUTH DIRECTION SEISMIC FORCE RESISTING SYSTEM = C4 STEEL ORDINARY MOMENT FRAMES OVERSTRENGTH FACTOR R = 3.5 DEFLECTION AMPLIFICATION FACTOR C _d = 3.5 OVERSTRENGTH FACTOR R = 3 (REDUCTION OF 0.5 ALLOWED WITH FLEXIBLE DIAPHRAGM) DEFLECTION AMPLIFICATION FACTOR C _d = 3		
STABILITY LOADS	INTERIOR PARTITIONS 5 PSF INTERIOR FREESTANDING MEZZ / STRUCTURE 2%, 5% OF TOTAL DL + LL		
ALLOWABLE SOIL BEARING PRESSURE			
THE VERIFIED SOIL BEARING CAPACITY IS 5,000 PSF AS DETERMINED BY THE GEOTECHNICAL REPORT PREPARED BY TERRACON CONSULTANTS, INC (REPORT #6119507). RAMMED AGGREGATE PIERS ARE REQUIRED TO IMPROVE SOILS TO DESIRED BEARING CAPACITY.			
NOTE 1 - REQUIREMENT FOR POSTED LIVE LOADS EXCEEDING 50 PSF			
IBC SECTION 1601.1 REQUIRES SIGNS TO BE POSTED BY THE OWNER IN AREAS DESIGNED TO SUPPORT UNIFORM LIVE LOADS EXCEEDING 50 PSF. SEE DETAILS ON S0 SHEETS FOR SIGN. SIGNAGE NOT REQUIRED FOR SLAB-ON-GRADE AREAS.			

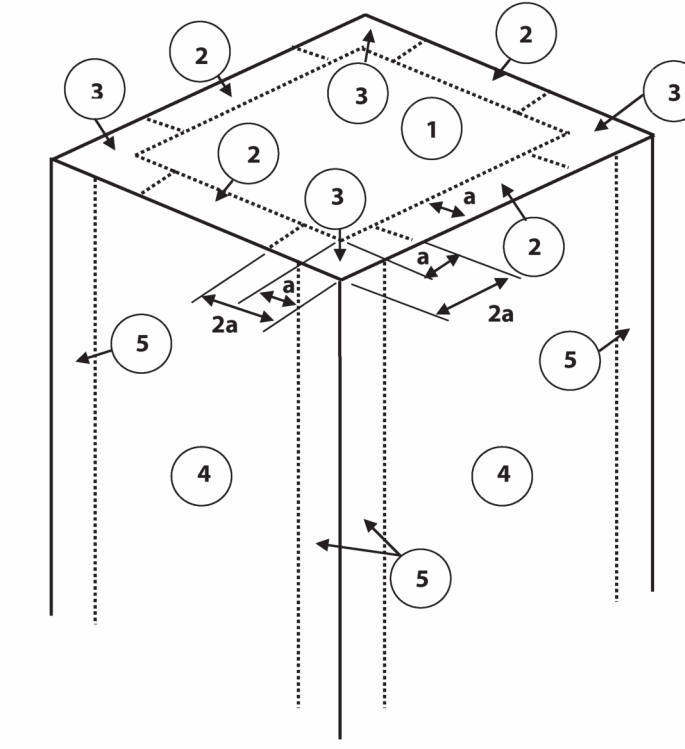

FLAT/HIP/GABLE/MANSARD ROOF <7°


COMPONENTS AND CLADDING WIND ZONES

NOT TO SCALE

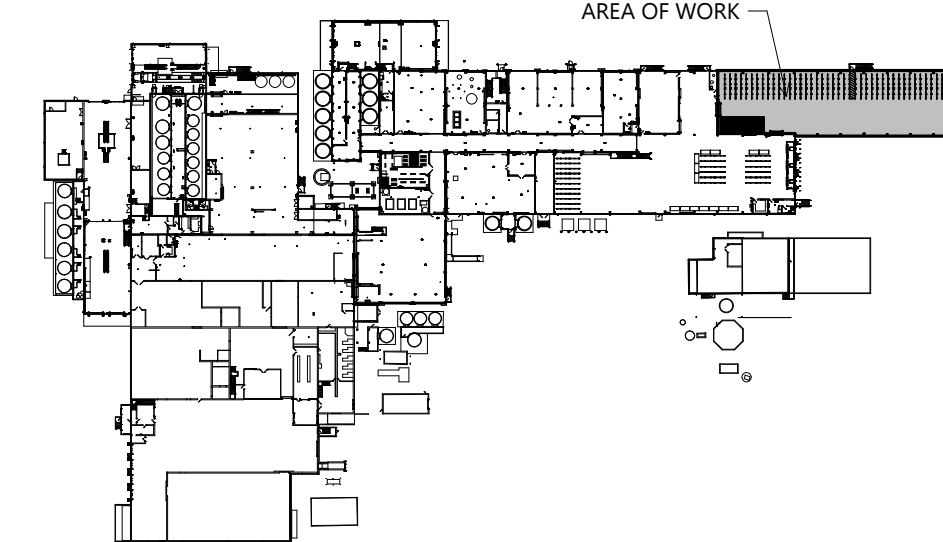


KEY PLAN

STRUCTURAL DESIGN CRITERIA

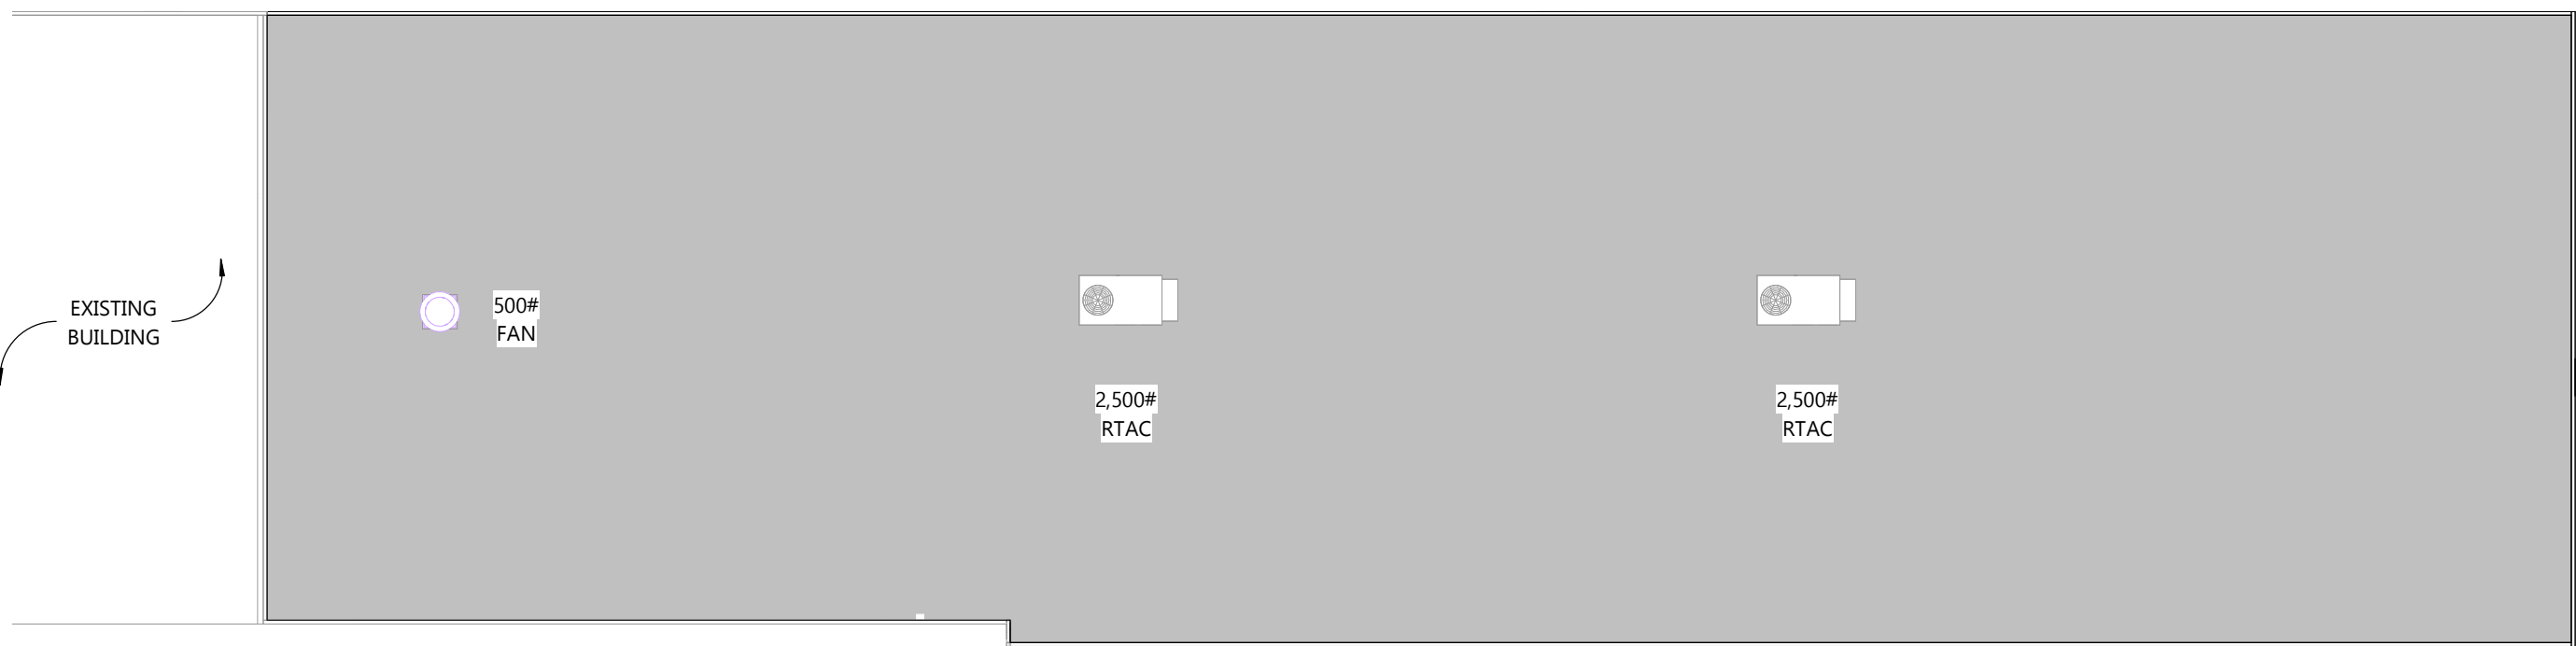


ROOF RTU LOAD PLAN

SCALE: 1/16" = 1'-0"

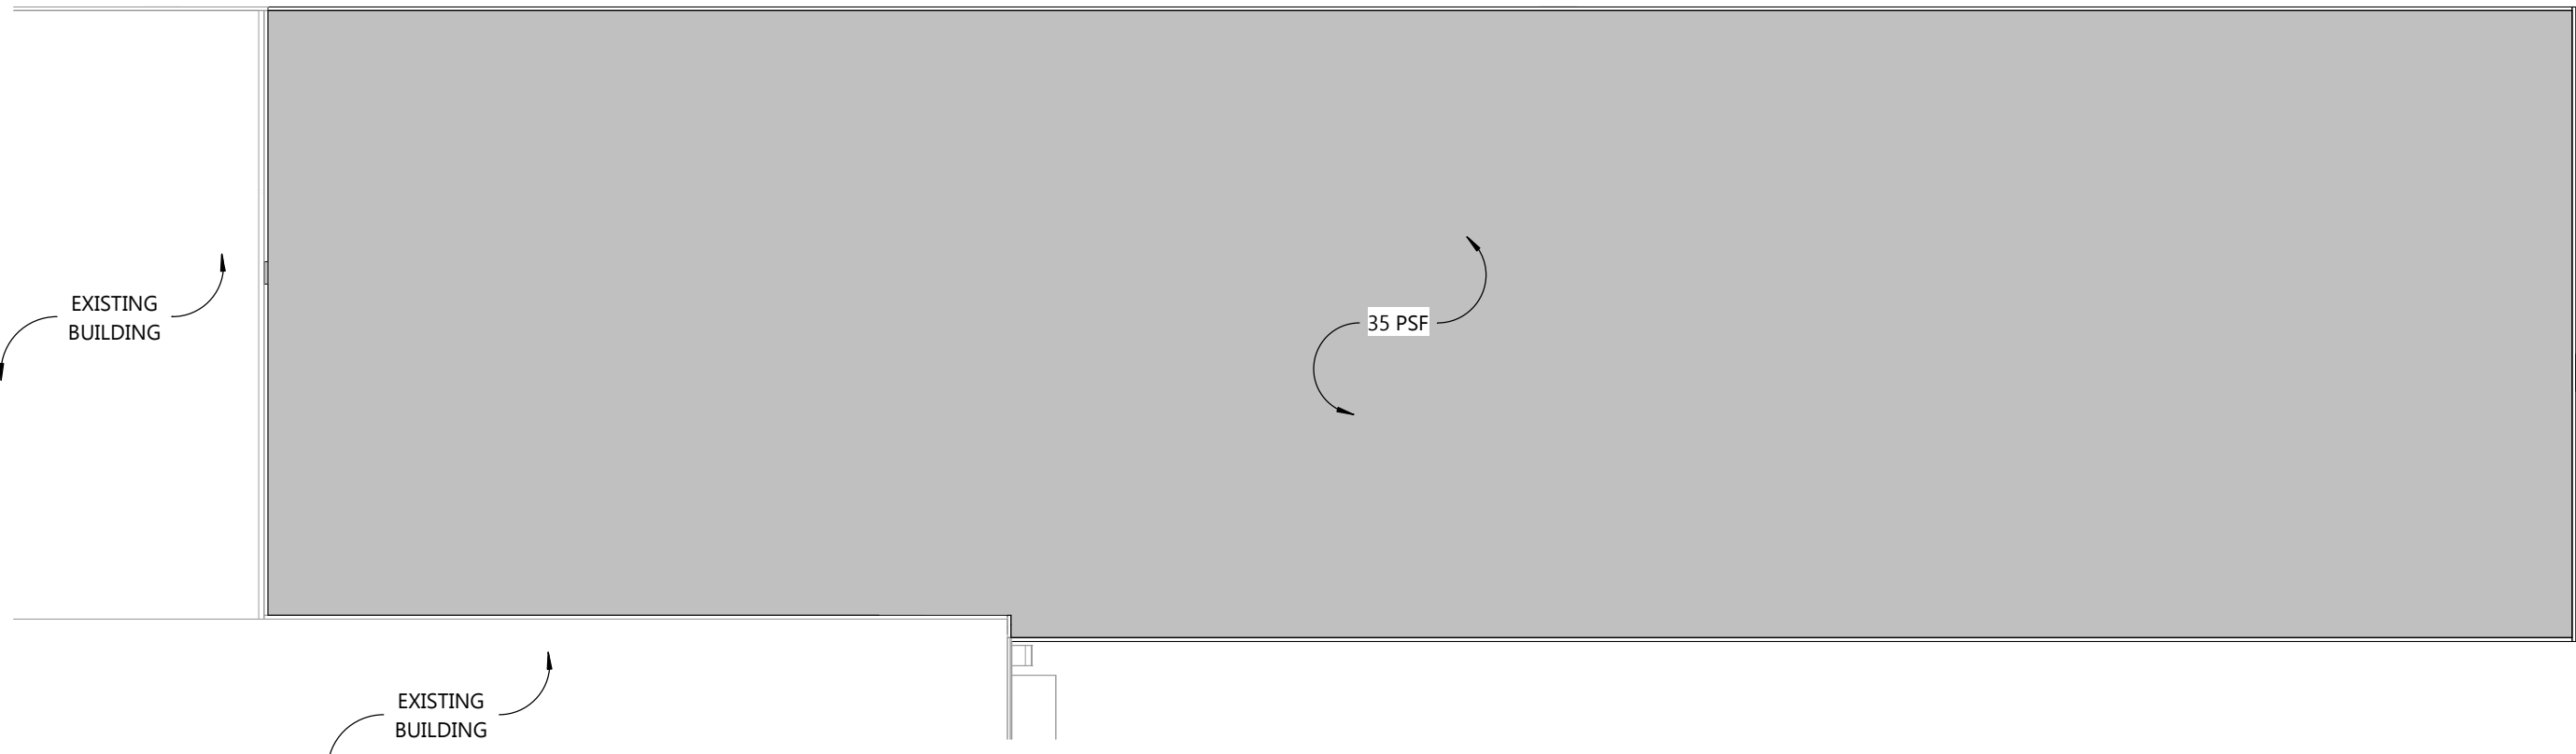


SNOW DRIFT LOAD PLAN

SCALE: 1/16" = 1'-0"

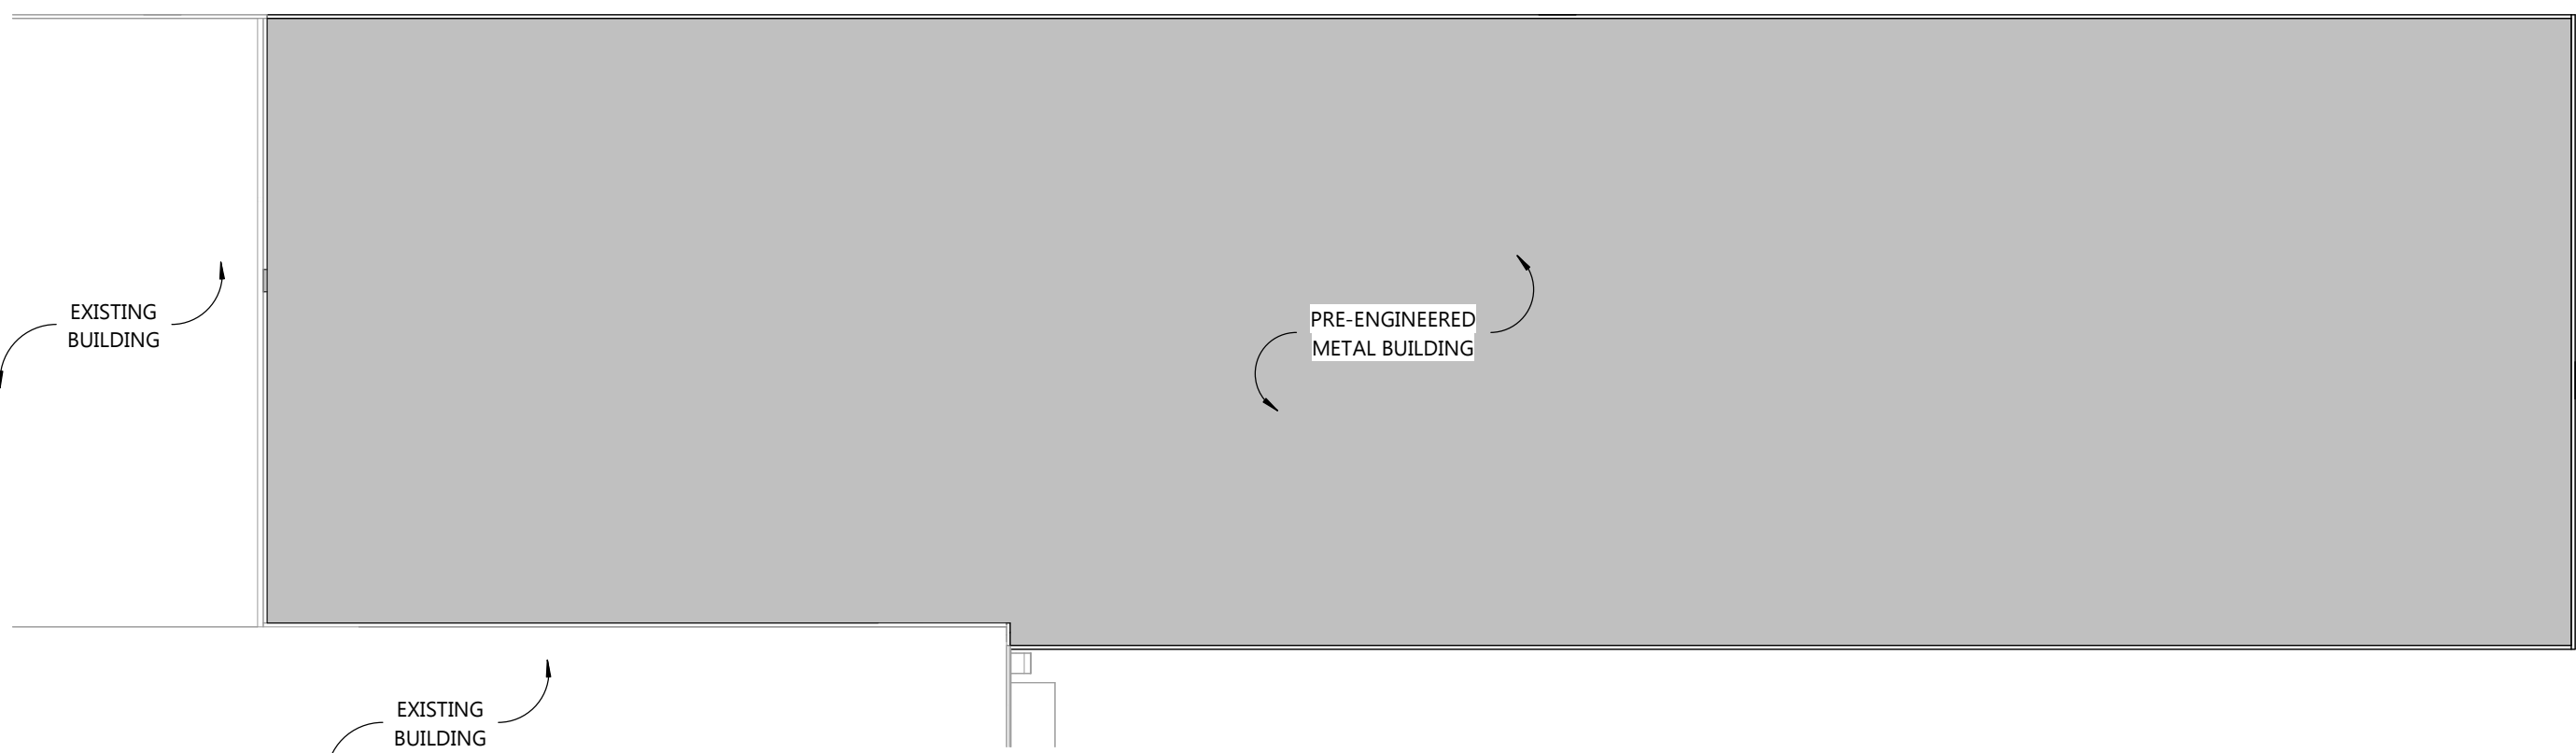

ROOF DEAD LOAD PLAN

SCALE: 1/16" = 1'-0"

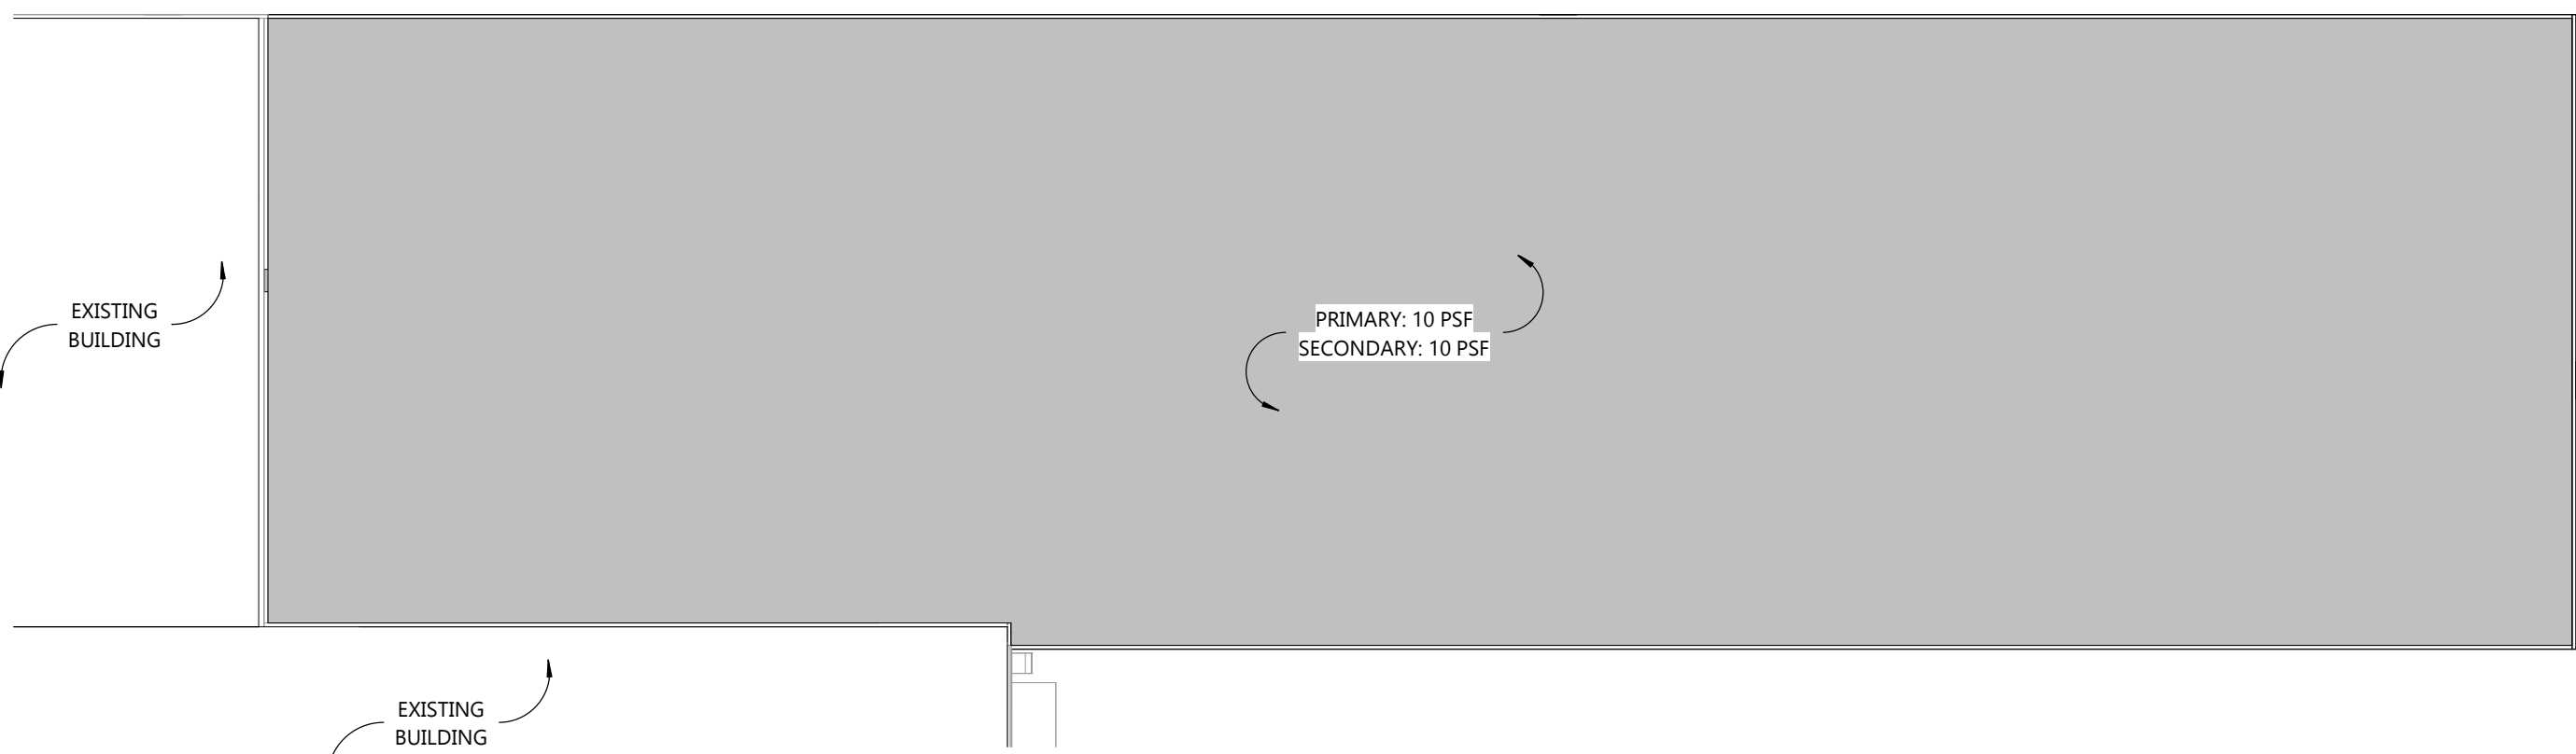

ROOF COLLATERAL LOAD PLAN

SCALE: 1/16" = 1'-0"


PEMB BUILDING NOTES

- ALL BRACING SHOWN REPRESENTS ACCEPTABLE LOCATIONS FOR BRACING PLACEMENT. ACTUAL QUANTITY OF BRACING REQUIRED NEED NOT INCLUDE BRACING AT EACH LOCATION SHOWN ON THIS PLAN.
- FOR REQUIRED GIRT ELEVATIONS AND FRAMING AROUND OPENINGS. SEE ARCHITECTURAL EXTERIOR ELEVATIONS FOR ALL MAIN DOORS, OVERHEAD DOORS, AND KNOCK OUT PANELS.
- ALL GIRTS TO BE INBOARD OF COLUMNS AT SIDEWALLS (PERPENDICULAR TO MF) AND OUTBOARD AT ENDWALLS (PARALLEL TO MF).
- T/PIER = 99'-4"
- FOR MECHANICAL UNITS SUSPENDED FROM ROOF, SEE ARCHITECTURAL REFLECTED CEILING PLANS.


PRE-ENGINEERED METAL BUILDING ALLOWABLE BRACE LOCATIONS AND DESIGN INFORMATION

SCALE: 1/16" = 1'-0"


C:\Users\jason\OneDrive\Documents\Excel\Projects\2025\250429500\250429500.sxd
4/7/2025 9:15:52 AM

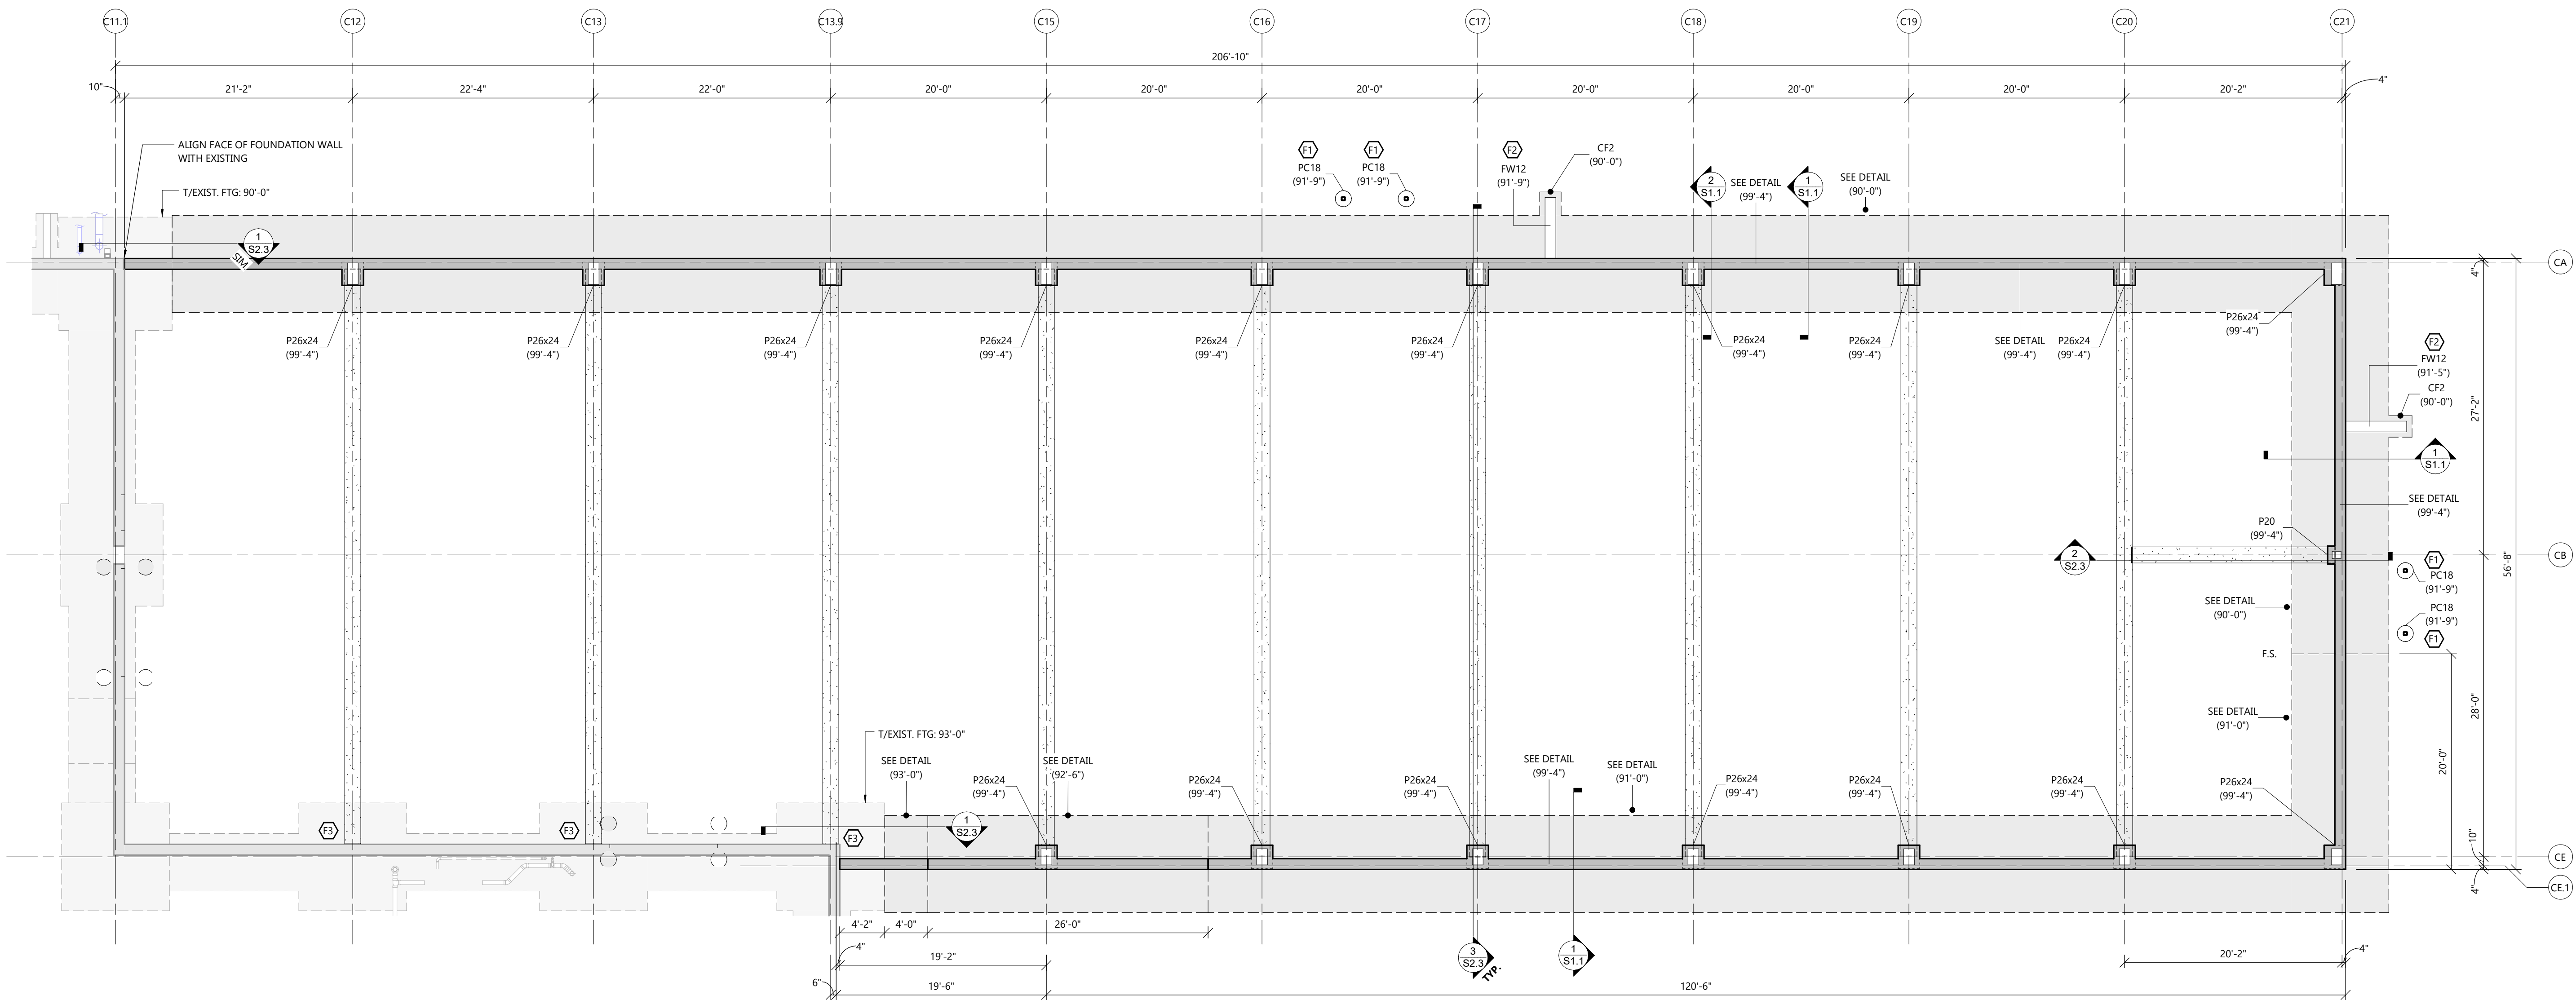

FOUNDATION PLAN
SCALE: 1/8" = 1'-0"

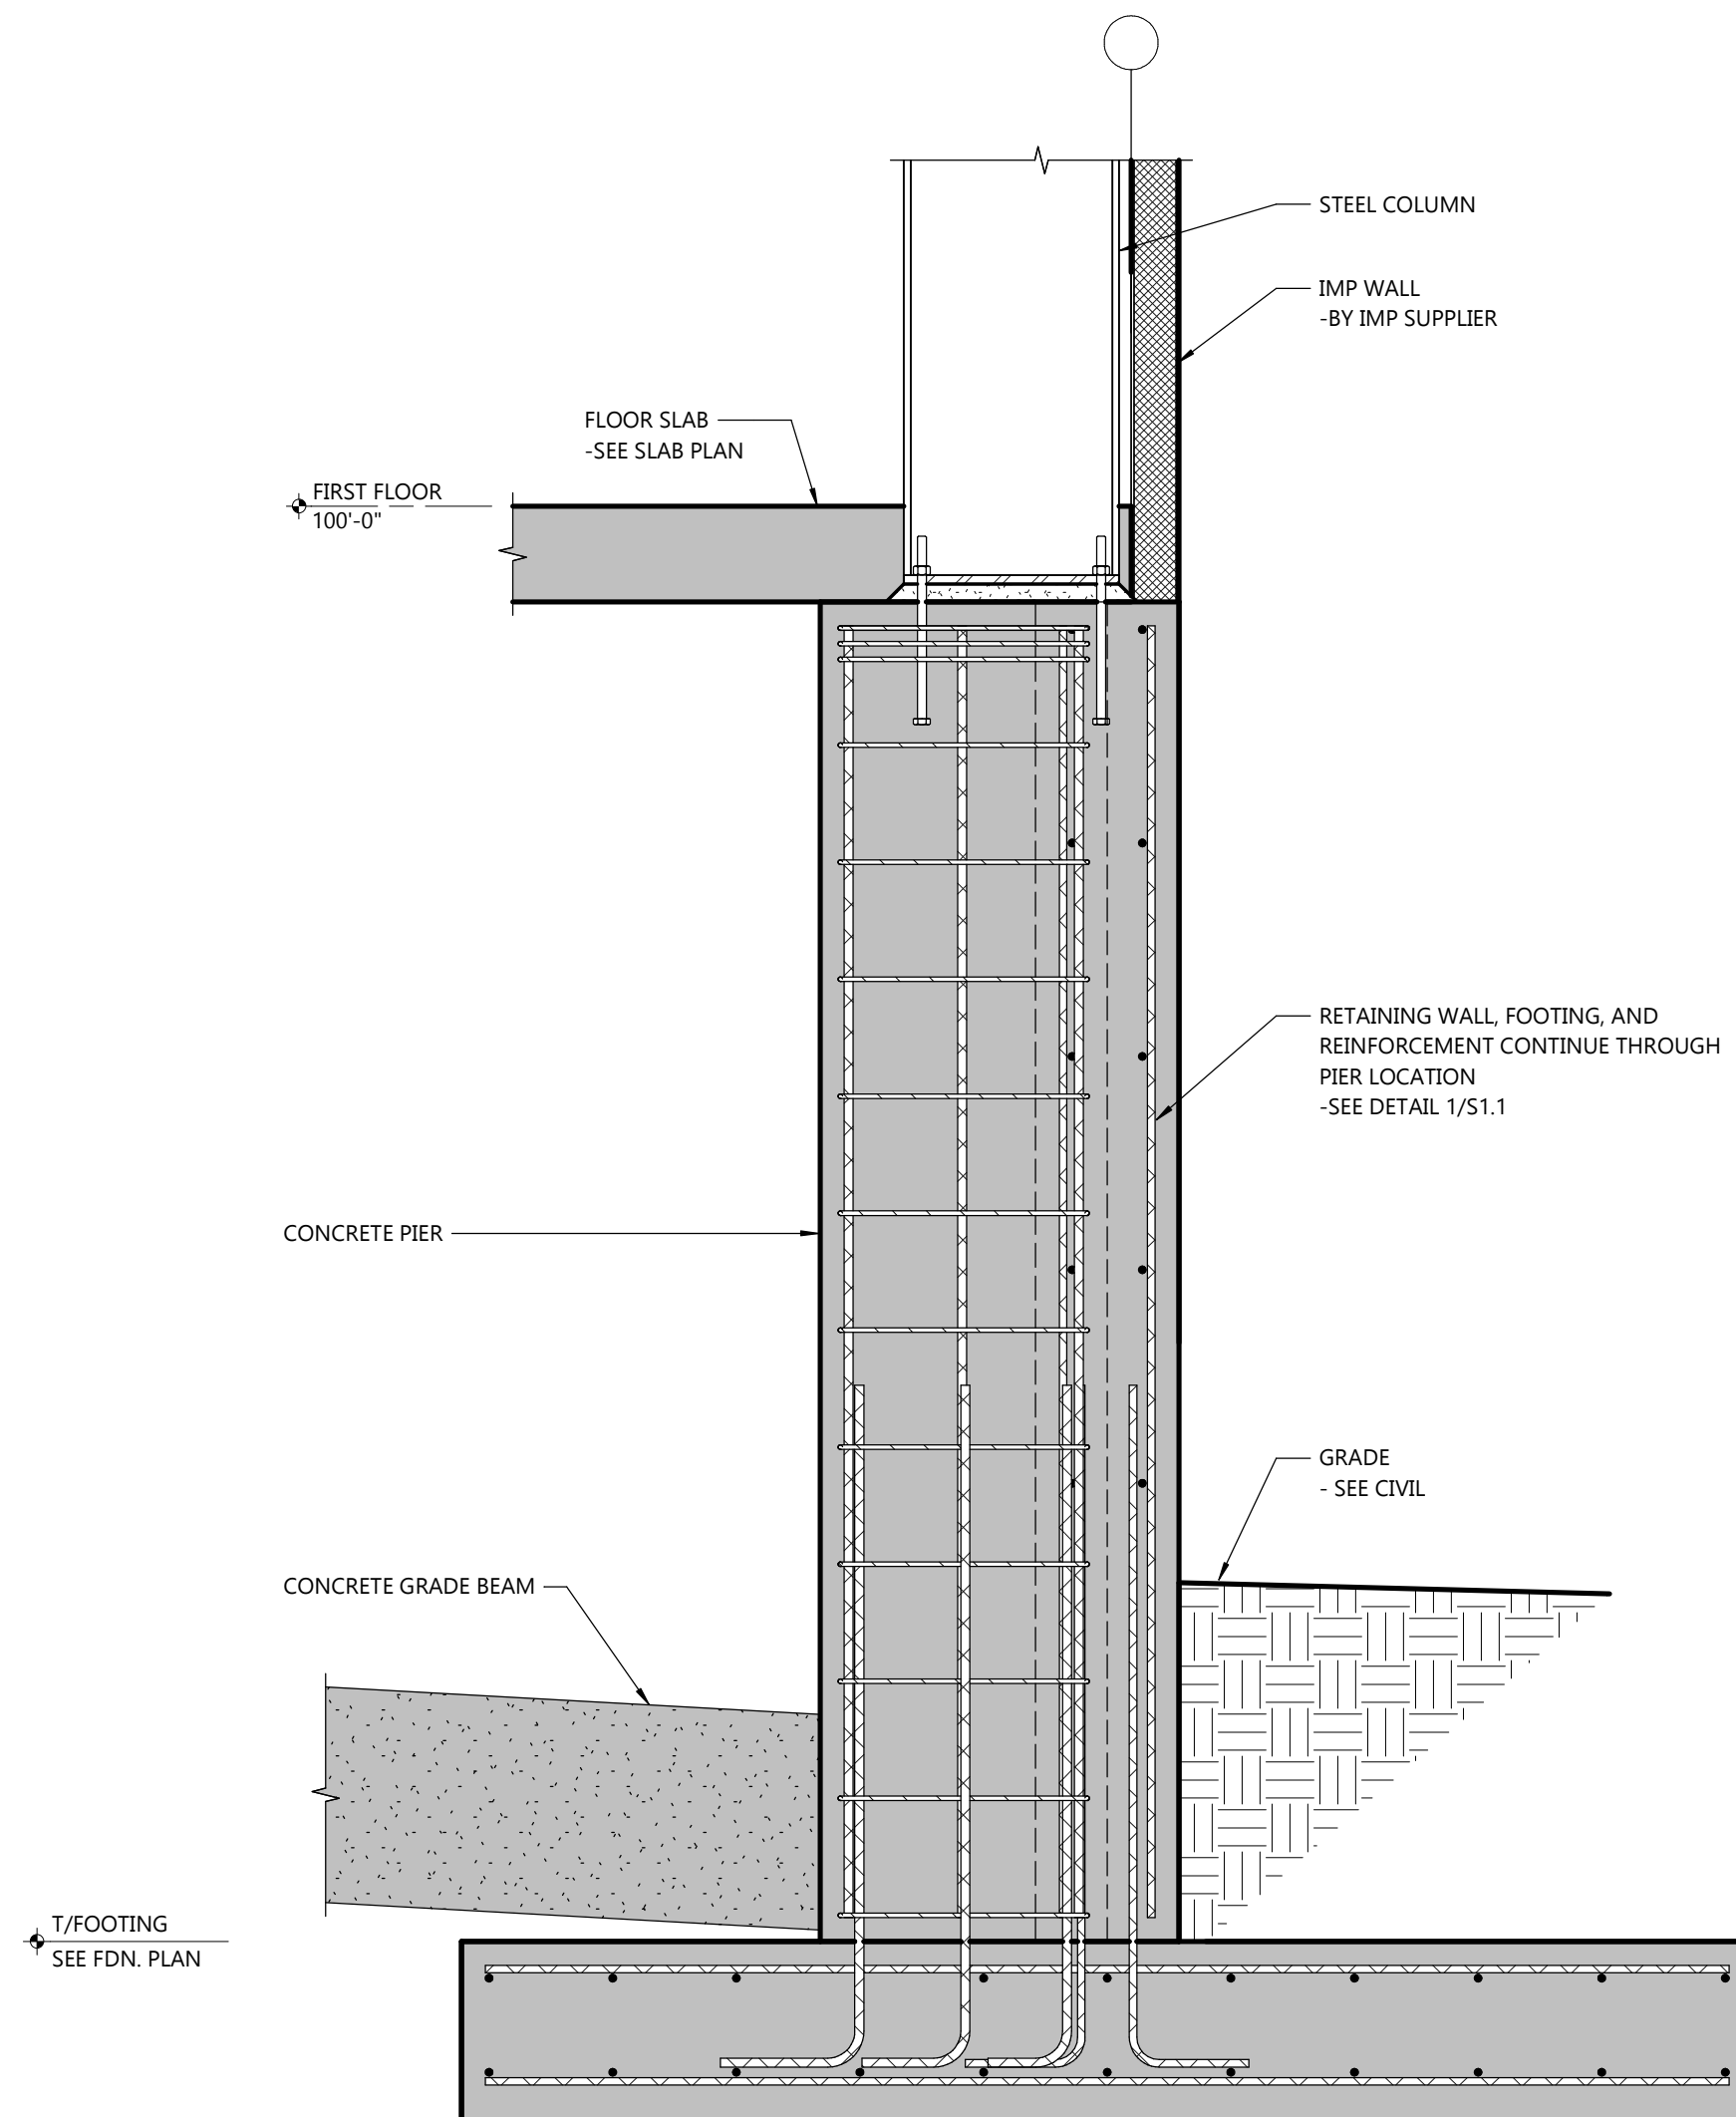


FOUNDATION SECTION
SCALE: 3/4" = 1'-0"

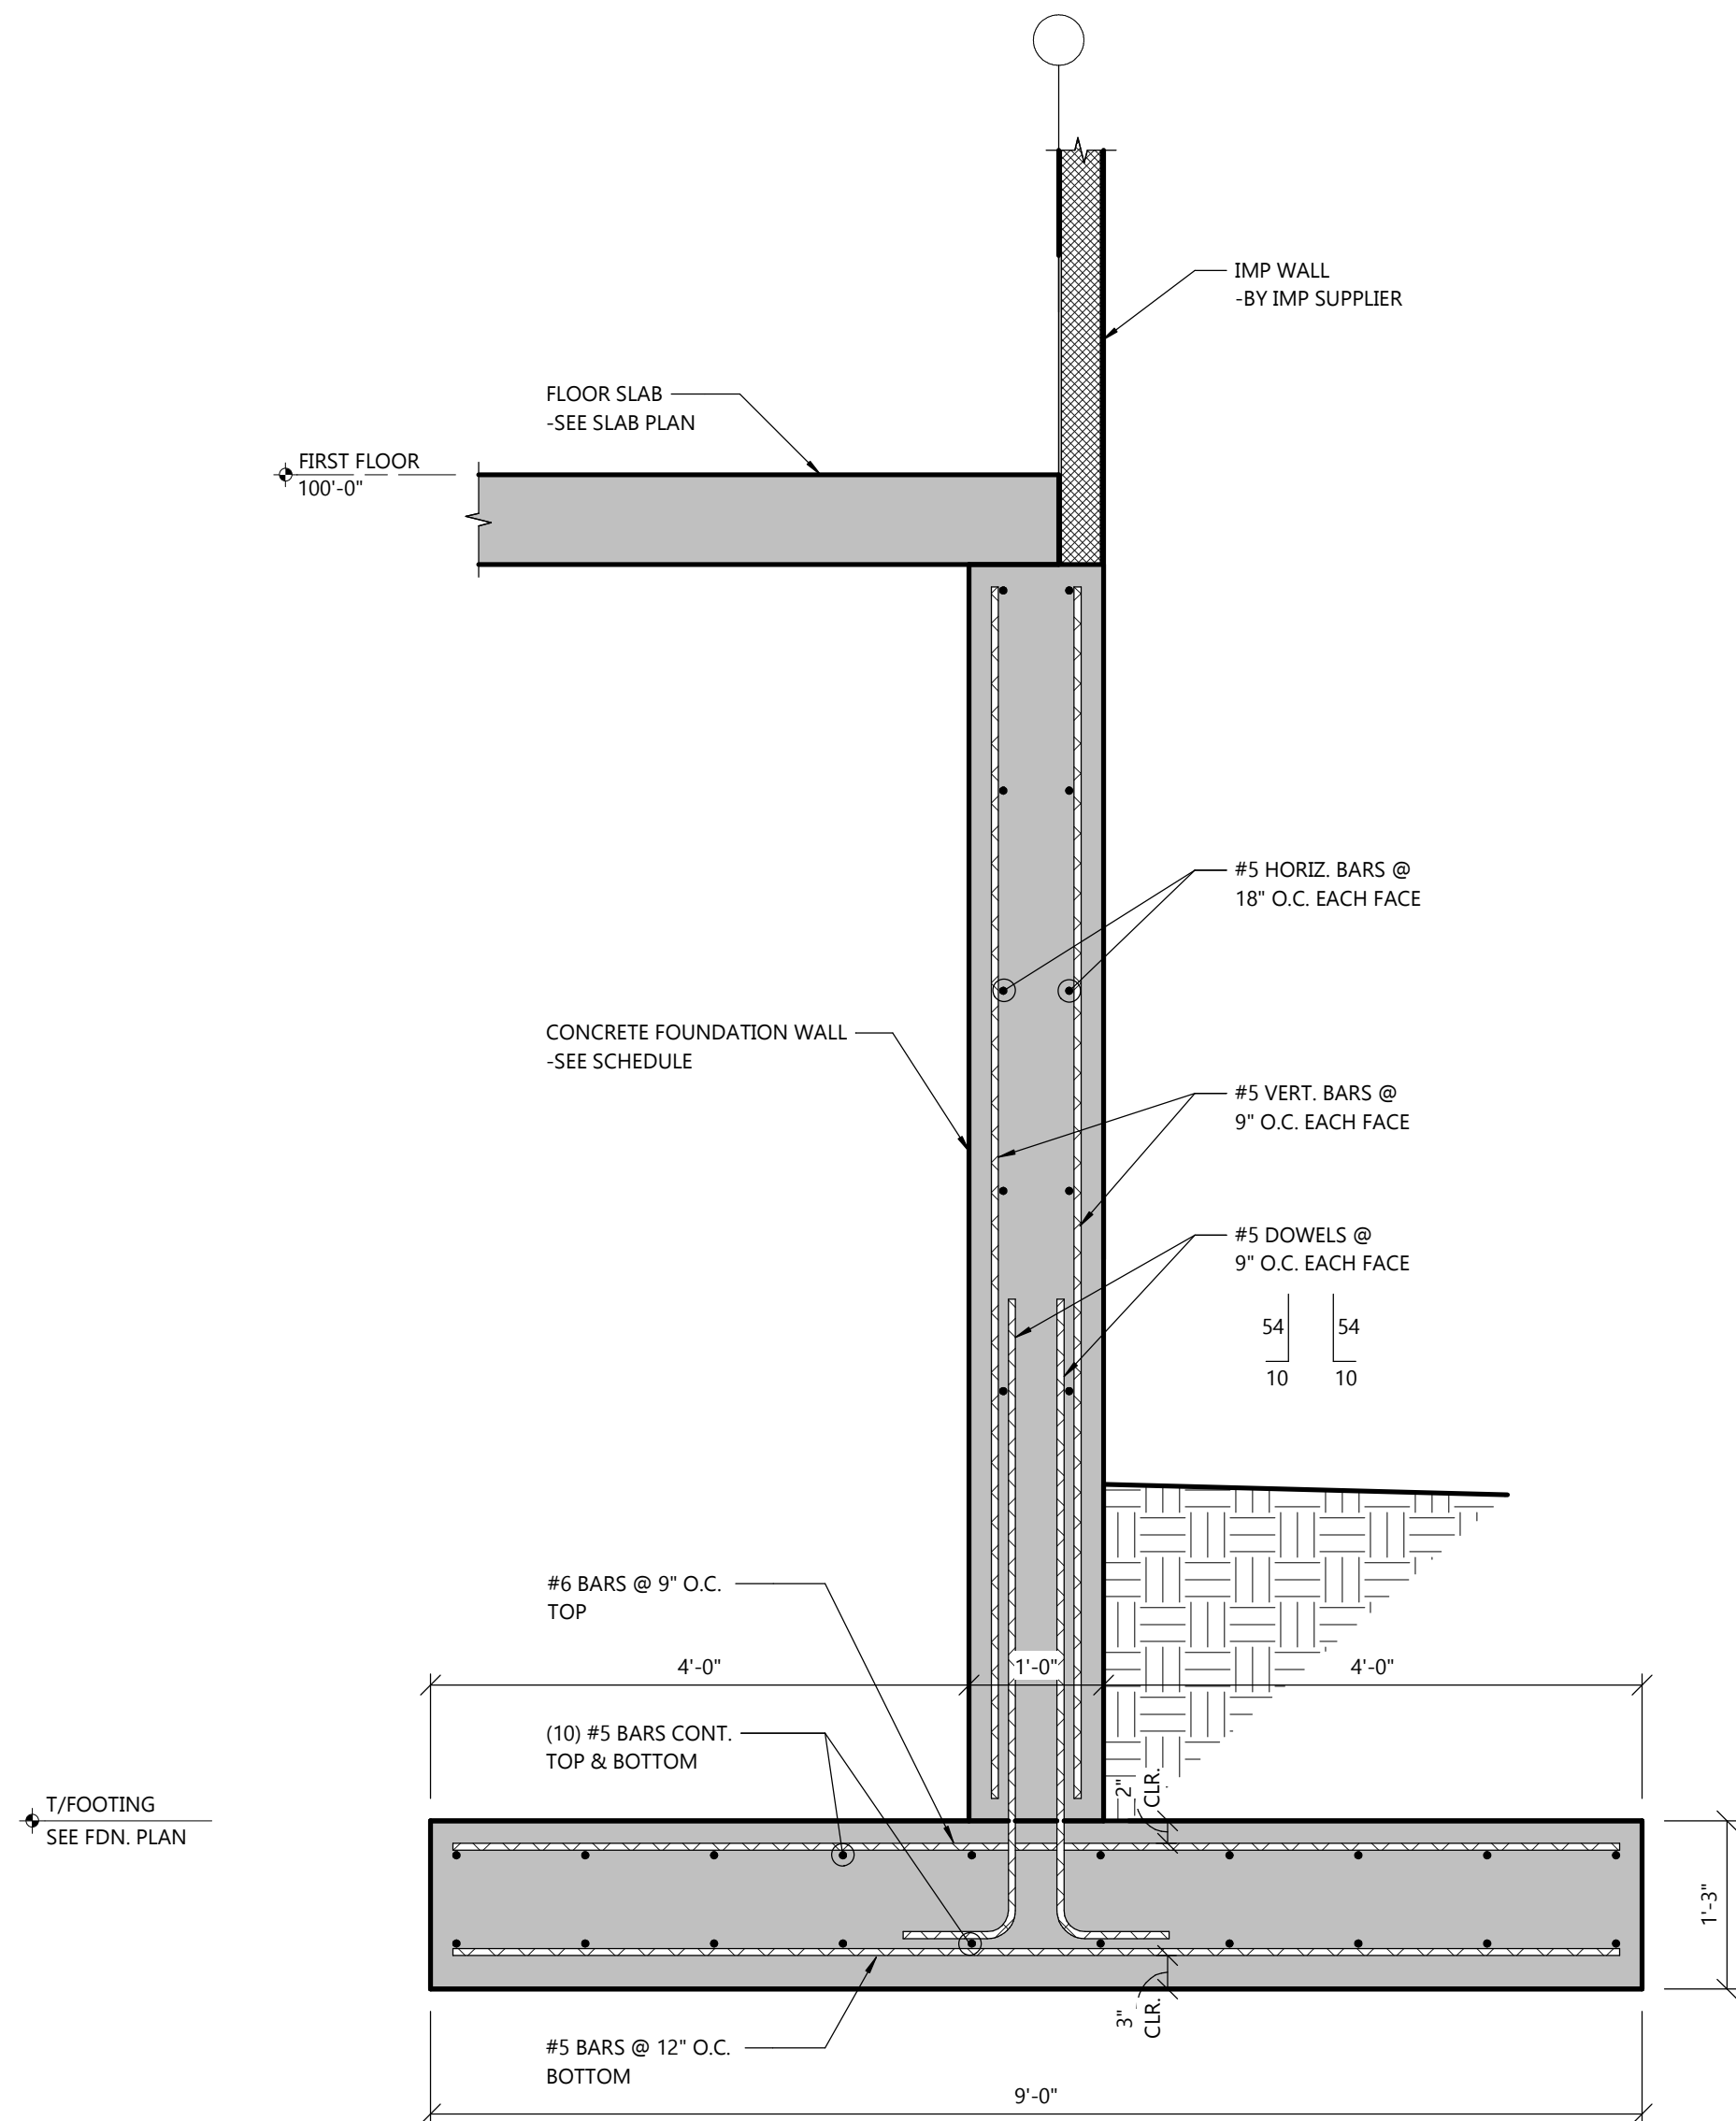

FOUNDATION SECTION
SCALE: 3/4" = 1'-0"

FOUNDATION PLAN LEGEND

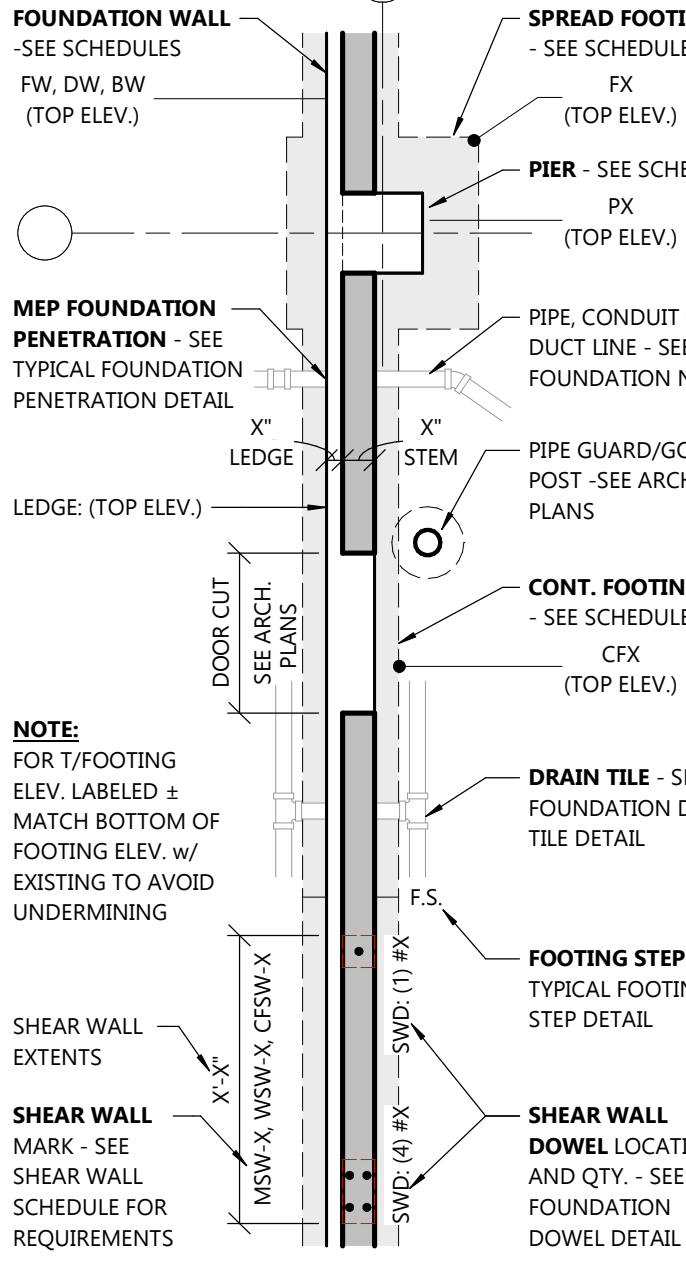

FOUNDATION NOTES


- SEE DESIGN LOADS ON S0 SHEETS FOR ALL DESIGN LOADS NOT SHOWN ON PLANS.
- SEE GENERAL BUILDING SPECIFICATIONS ON A0 SHEETS AND STRUCTURAL SPECIFICATIONS ON S0 SHEETS FOR MATERIAL SPECIFICATIONS NOT SHOWN ON PLANS.
- **GEOTECHNICAL REPORT REQUIREMENTS:**
 - CONTRACTOR TO READ, REVIEW AND FOLLOW ALL RECOMMENDATIONS LISTED IN GEOTECHNICAL REPORT (U.N.O.). SEE STRUCTURAL DESIGN CRITERIA FOR GEOTECHNICAL REPORT REFERENCE.
 - FOUNDATION/SLAB SUBGRADE MATERIALS AND PREPARATION SHALL BE PER RECOMMENDATIONS OF GEOTECHNICAL REPORT (U.N.O.). RANMED-AGGREGATE PIERS, OR SIMILAR PRODUCT, ARE REQUIRED TO IMPROVE EXISTING SOILS FOR SUPPORT OF NEW STRUCTURE. SEE GEOTECH REPORT FOR ADDITIONAL INFORMATION.
 - FOUNDATION BACKFILL AND PREPARATION SHALL BE COMPACTED GRANULAR MATERIAL PER RECOMMENDATIONS OF GEOTECHNICAL REPORT (U.N.O.).
 - CONTRACTOR SHALL ENGAGE A QUALIFIED INDEPENDENT TESTING AND INSPECTING AGENCY TO PERFORM FIELD TESTS AND INSPECTIONS BELOW FOOTINGS/FOUNDATIONS TO VERIFY THE NET ALLOWABLE SOIL BEARING CAPACITY MEETS OR EXCEEDS THE SPECIFIED VALUE IN THE STRUCTURAL DESIGN CRITERIA. CONTRACTOR SHALL PROVIDE DOCUMENTATION OF PASSING SOIL BEARING TESTING TO ENGINEER UPON COMPLETION. IT IS RECOMMENDED THAT THE GEOTECHNICAL FIRM USED TO PERFORM THE SUBSURFACE SOIL INVESTIGATION BE ENGAGED FOR THE FIELD QUALITY CONTROL TESTS.
- FOUNDATION WALL CONTRACTION AND CONSTRUCTION JOINTS ARE NOT SHOWN ON PLAN. SEE S2 SHEETS FOR JOINT REQUIREMENTS.
- SEE S2 SHEETS FOR ADDITIONAL FOUNDATION DETAILS NOT REFERENCED ON FOUNDATION PLANS.
- SEE SPECIFICATIONS FOR PERIMETER FOUNDATION INSULATION AND FOUNDATION DRAINAGE PANEL THICKNESS.
- COORDINATE AND VERIFY ALL UNDERGROUND WORK PRIOR TO POURING CONCRETE FLOOR SLAB.
- SEE CIVIL PLANS AND SPECIFICATIONS ON CIVIL PLANS FOR ALL EXTERIOR CONCRETE FLATWORK NOT SPECIFICALLY SHOWN/DETAILED ON THE STRUCTURAL PLANS.
- SEE S2 SHEETS FOR TOP OF PIER/FOOTING AND CONTROL JOINT AT COLUMN LOCATIONS.
- VERIFY EXISTING FOUNDATIONS AND INFORM EXCEL ENGINEERING IF DIFFERENT THAN SHOWN.
- PROVIDE DOWELS WHERE NEW FOOTING/FOUNDATION INTERSECTS EXISTING FOOTING/FOUNDATION. SEE STANDARD DETAILS ON S2 SHEETS.
- SEE ARCHITECTURAL FLOOR PLANS FOR TAGS OF ALL GUARDPOSTS & GOALPOSTS. GUARDPOST & GOALPOST SCHEDULE & DETAILS LOCATED ON A6 SHEETS.
- PIPE, CONDUIT AND DUCT LINES SHOWN ON THIS PLAN ARE FOR GENERAL LAYOUT INTENT PURPOSES ONLY. REFER TO THE CIVIL/MEP PLANS FOR SPECIFIC INFORMATION.

PRE-ENGINEERED METAL BUILDING NOTES

- ARCHITECT/ENGINEER TO APPROVE FOUNDATION DETAILS w/ FINAL METAL BUILDING REACTIONS AND BASE PLATE LAYOUTS PRIOR TO POURING BUILDING FOUNDATIONS.
- METAL BUILDING ANCHOR BOLTS TO BE LOCATED PER METAL BUILDING ANCHOR BOLT PLAN IN CONJUNCTION w/ STRUCTURAL FOUNDATION. SEE S2 SHEETS.

FOUNDATION KEYNOTES

- F1 SONOTUBE PIER STAIR FOUNDATION. COORDINATE LOCATION & TOP OF WALL ELEVATION w/ DETAILS ON ARCHITECTURAL PLANS & FINAL STAIR SHOP DRAWINGS PRIOR TO INSTALLING. COORDINATE w/ CIVIL PLANS & FINAL GRADE ELEVATION TO PROVIDE MINIMUM 3'-0" FROST PROTECTION.
- F2 STAIR FOUNDATION. COORDINATE LOCATION & TOP OF WALL ELEVATION w/ DETAILS ON ARCHITECTURAL PLANS & FINAL STAIR SHOP DRAWINGS PRIOR TO INSTALLING. COORDINATE w/ CIVIL PLANS & FINAL GRADE ELEVATION TO PROVIDE MINIMUM 3'-0" FROST PROTECTION.
- F3 DOWEL GRADE BEAM INTO EXISTING PIER. SEE DETAIL 1/S2.3.

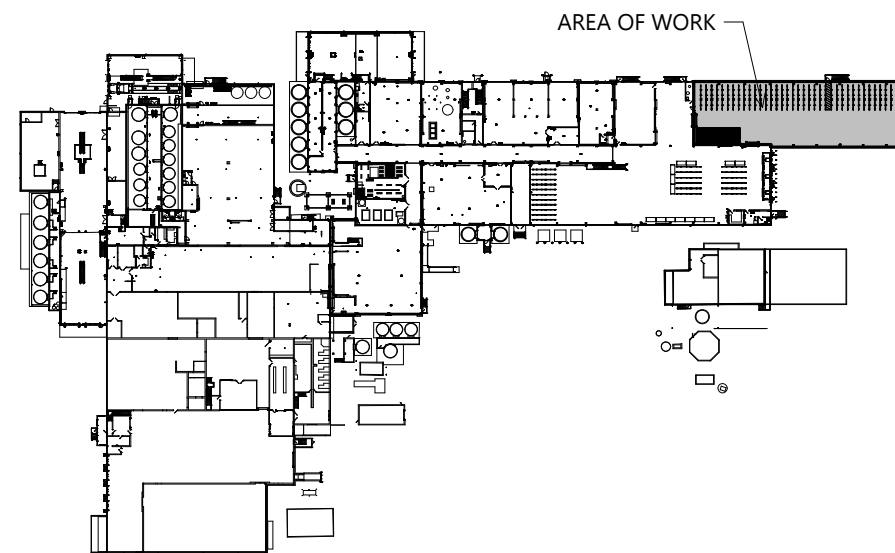

KEY PLAN

STRUCTURAL FOUNDATION PLAN

PROJECT INFORMATION

STORAGE WAREHOUSE EXPANSION FOR: WEST POINT DAIRY PRODUCTS 570 NORTH 500 WEST • HYRUM, UT 84319

PROFESSIONAL SEAL

SHEET DATES

ISSUED FOR BUDGET
IFB APR. 17, 2026

JOB NUMBER
250429500

SHEET NUMBER

S1.1

NOT FOR CONSTRUCTION

PROJECT INFORMATION

STORAGE WAREHOUSE EXPANSION FOR:
WEST POINT DAIRY PRODUCTS
570 NORTH 500 WEST • HYRUM, UT 84319

PROFESSIONAL SEAL

NOT FOR CONSTRUCTION

SHEET DATES

ISSUED FOR BUDGET

IFB APR. 17, 2026

JOB NUMBER

250429500

SHEET NUMBER

S1.1S

GENERAL NOTES


- SEE DESIGN LOADS ON S2 SHEETS FOR ALL DESIGN LOADS NOT SHOWN ON PLANS.
- SEE GENERAL BUILDING SPECIFICATIONS ON A0 SHEETS AND STRUCTURAL SPECIFICATIONS ON S2 SHEETS FOR MATERIAL SPECIFICATIONS NOT SHOWN ON PLANS.
- G.C. TO HOLD PRECONSTRUCTION MEETING PRIOR TO POURING ALL SLOPED FLOOR AREAS TO DISCUSS WITH OWNER/ARCHITECT.
- SEE CIVIL PLANS AND SPECIFICATIONS FOR ALL EXTERIOR CONCRETE FLATWORK NOT SPECIFICALLY SHOWN/DETAILED ON THE STRUCTURAL PLANS.
- SEE CONCRETE SLAB ON GRADE SCHEDULE ON S2 SHEETS FOR SLAB REQUIREMENTS.
- SEE SLAB ON GRADE REINFORCING AT DOORS/OPENINGS DETAIL ON S2 SHEETS FOR ADDITIONAL SLAB REINFORCING.
- SEE SUPPLEMENTAL REINFORCING DETAIL ON S2 SHEETS FOR ADDITIONAL SLAB REINFORCING.
- SEE CONCRETE SLAB ON GRADE SCHEDULE AND DETAILS FOR SLAB JOINT REQUIREMENTS.
- CONSTRUCTION JOINTS (C.J.) SHOWN ON PLAN MAY BE CHANGED TO POUR JOINTS (P.J.) AT CONTRACTORS DISCRETION.
- TOP OF FLOOR SLAB IS TOP OF FINISHED SURFACE. OFFSET THE TOP OF CONCRETE AS REQUIRED TO SUIT FLOOR FINISH MATERIAL.
- COORDINATE PLAN WITH ARCHITECTURAL FLOOR PLANS FOR WALL AND DOOR LOCATIONS.
- AT ALL HIGH POINTS IN FLOOR, PROVIDE EASED EDGE. SEE FLOOR SCREED DETAIL ON S2 SHEETS.
- DO NOT TERMINATE A SAWCUT JOINT INTO ANOTHER SAWCUT JOINT (CREATING A "T" CONDITION). SAWCUT JOINTS MUST CONTINUE THRU OTHER SAWCUT JOINTS UNTIL THEY TERMINATE INTO A POUR JOINT OR SLAB EDGE.

SLAB-ON-GRADE KEYNOTES

- ① PROVIDE ARMOR JOINT AT DOOR/OPENING FLOOR JOINT - SEE S2 SHEETS ARMOR JOINT DETAIL.



SLAB-ON-GRADE JOINT LEGEND

SAWCUT JOINT (S.J.)	----
CONSTRUCTION JOINT (C.J.)	----
POUR JOINT (P.J.)	----

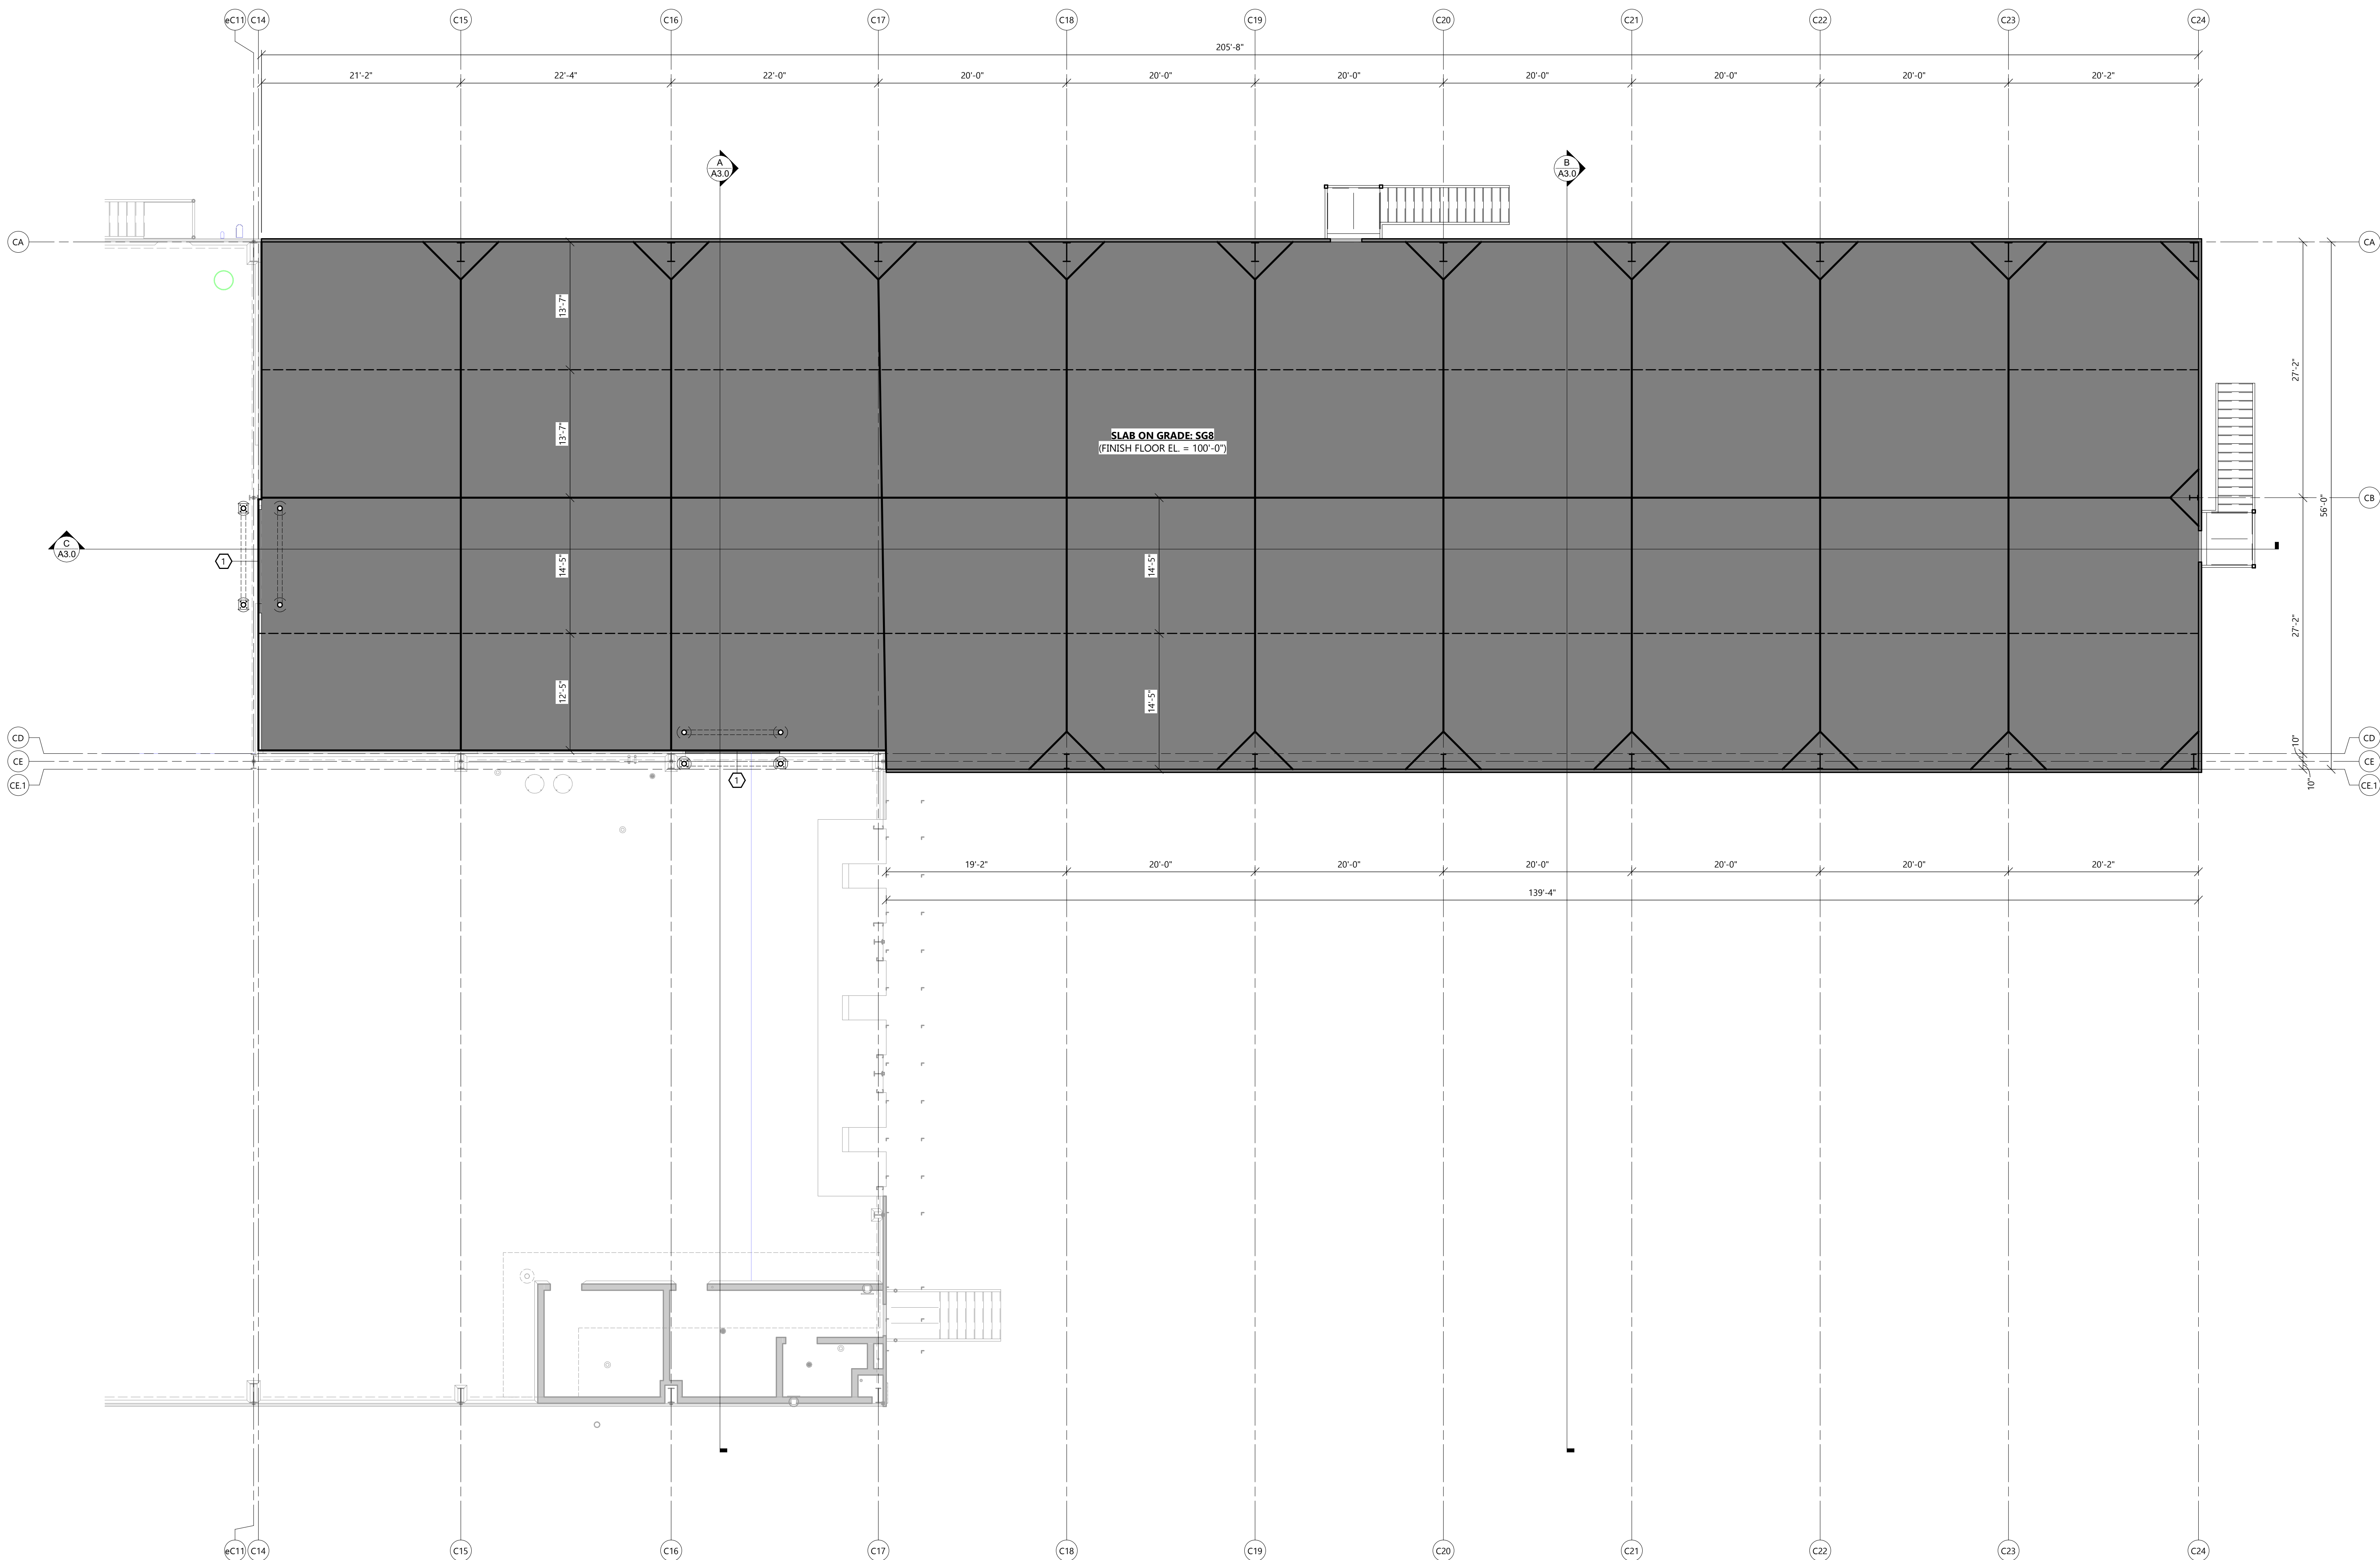

FIRST FLOOR SLAB PLAN - AREA "A"

 SCALE: 1/8" = 1'-0"

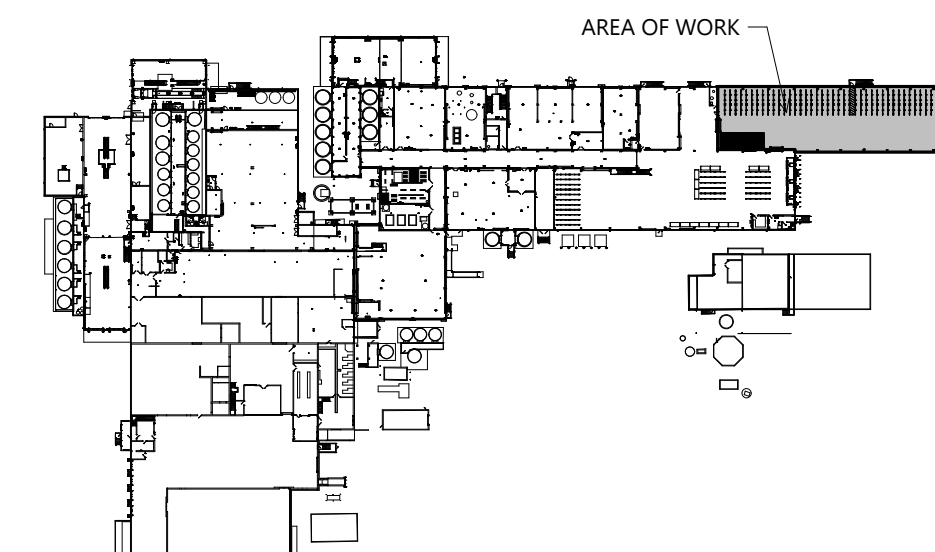

KEY PLAN

STRUCTURAL CONCRETE FLOOR SLAB PLAN

PROJECT INFORMATION

STORAGE WAREHOUSE EXPANSION FOR:
WEST POINT DAIRY PRODUCTS
570 NORTH 500 WEST • HYRUM, UT 84319

PROFESSIONAL SEAL

NOT FOR CONSTRUCTION

SHEET DATES

ISSUED FOR BUDGET

IFB APR. 17, 2026

JOB NUMBER

250429500

SHEET NUMBER


S2.0

FROST WALL SCHEDULE

NOTES:

- SEE TYPICAL FROST WALL DETAIL FOR TYPICAL CONSTRUCTION & NOTES.
- SEE FOUNDATION PLAN FOR TOP OF WALL & LEDGE (IF APPLICABLE) ELEVATIONS.
- SEE STRUCTURAL SPECIFICATIONS FOR CONSTRUCTION MATERIAL REQUIREMENTS.

MARK	WIDTH	HORIZONTAL REINFORCING	BOTTOM DOWEL	REMARKS
FW12	12"	(2) #5 TOP & BOT.	#4 x 21" + HOOK @ 18" O.C.	

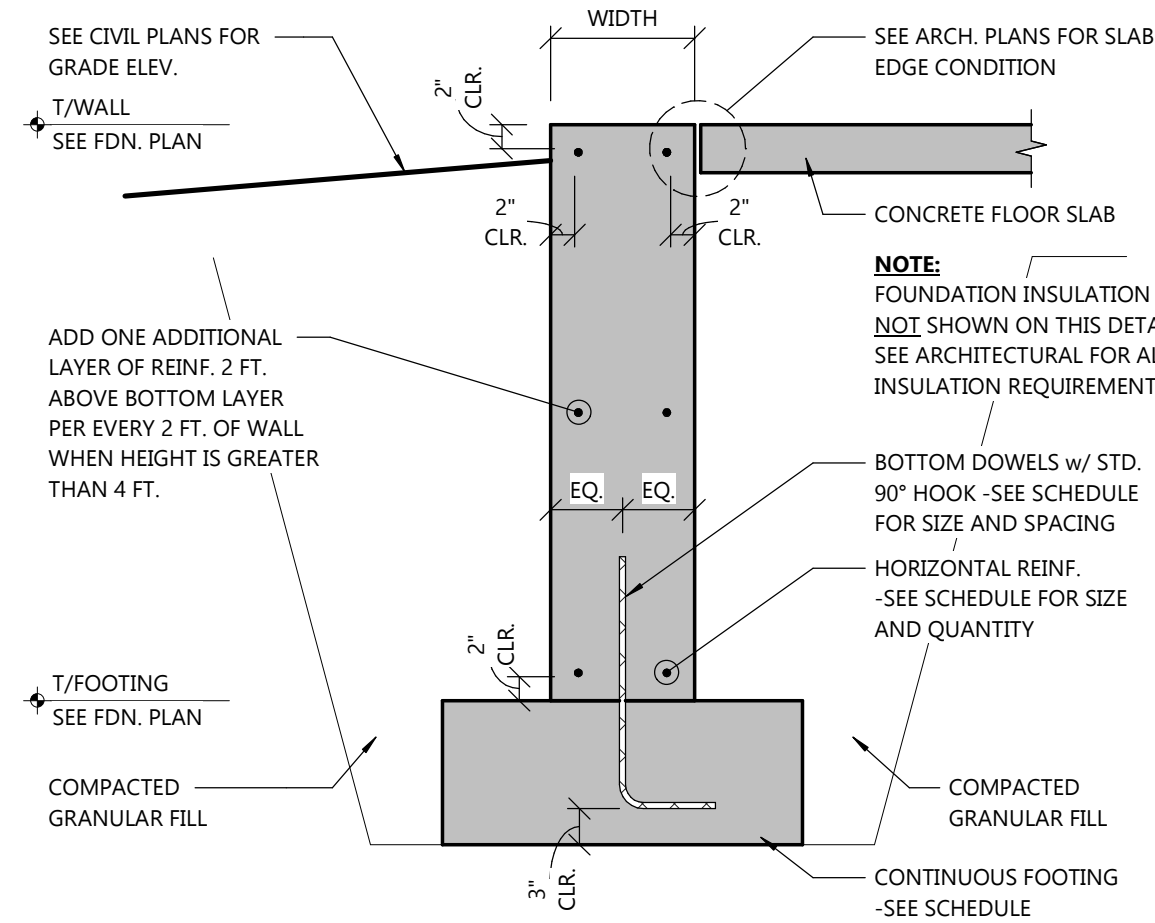

TYPICAL FROST WALL DETAIL


NOT TO SCALE

PIER SCHEDULE (PRELIMINARY)

NOTES:


- ALL PIERS ARE CENTERED ON COLUMN GRID LINE INTERSECTIONS UNLESS DIMENSIONED OTHERWISE.
- SEE TYPICAL PIER DETAIL FOR TYPICAL CONSTRUCTION & NOTES.
- SEE FOUNDATION PLAN FOR TOP OF PIER ELEVATIONS.
- SEE FOUNDATION PLAN FOR PIER ORIENTATION.
- SEE COLUMN SCHEDULE FOR COLUMN ANCHOR BOLT INFORMATION.
- VERTICAL REINFORCING BARS SHALL BE EQUALLY SPACED, UNO.
- SEE REINFORCING TOP VIEW DETAILS FOR ORIENTATION OF VERTICAL REINFORCING.
- HORIZONTAL TIES SHALL MEET REQ'S OF ACI 318-7.10.5.3 FOR LATERAL SUPPORT OF VERTICAL REINFORCING.
- SEE STRUCTURAL SPECIFICATIONS FOR CONSTRUCTION MATERIAL REQUIREMENTS.

MARK	SIZE			REMARKS
	LENGTH	WIDTH	DIAMETER	
RECTANGULAR				
P20	20"	20"		
P26x24	26"	24"		
CIRCULAR				
PC18			1'-6"	

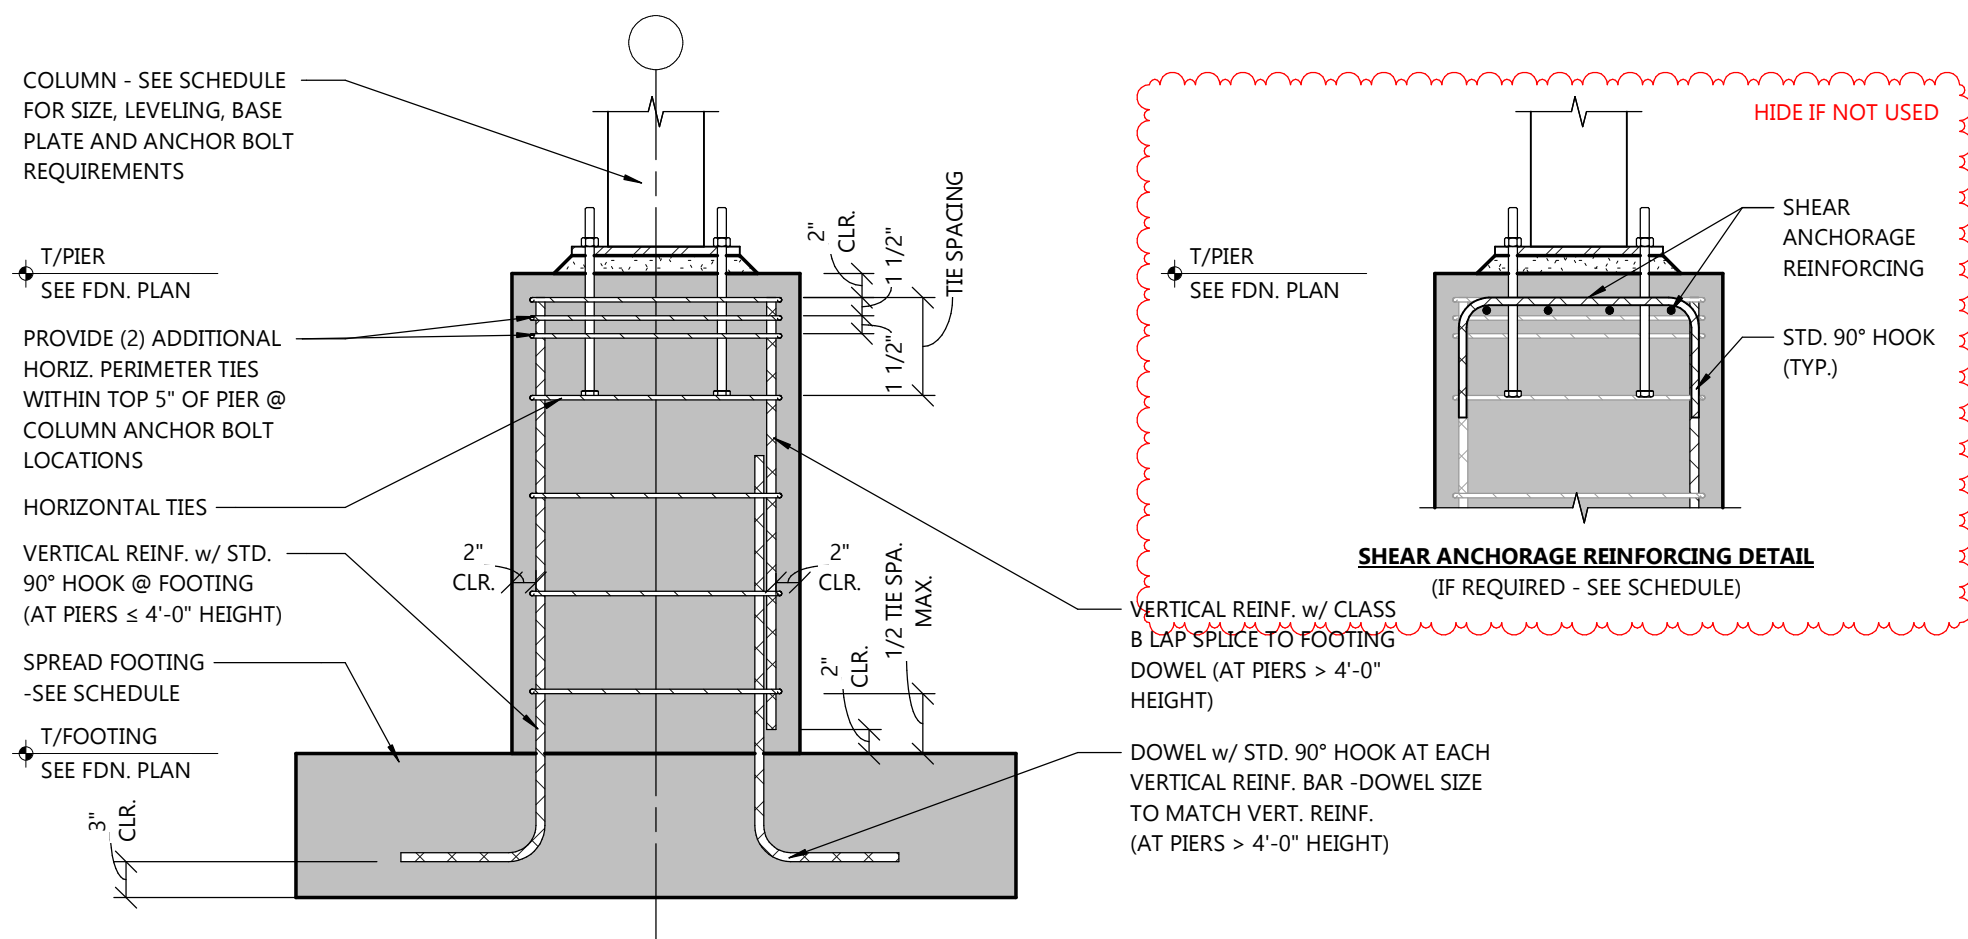


TYPICAL PIER DETAIL

NOT TO SCALE

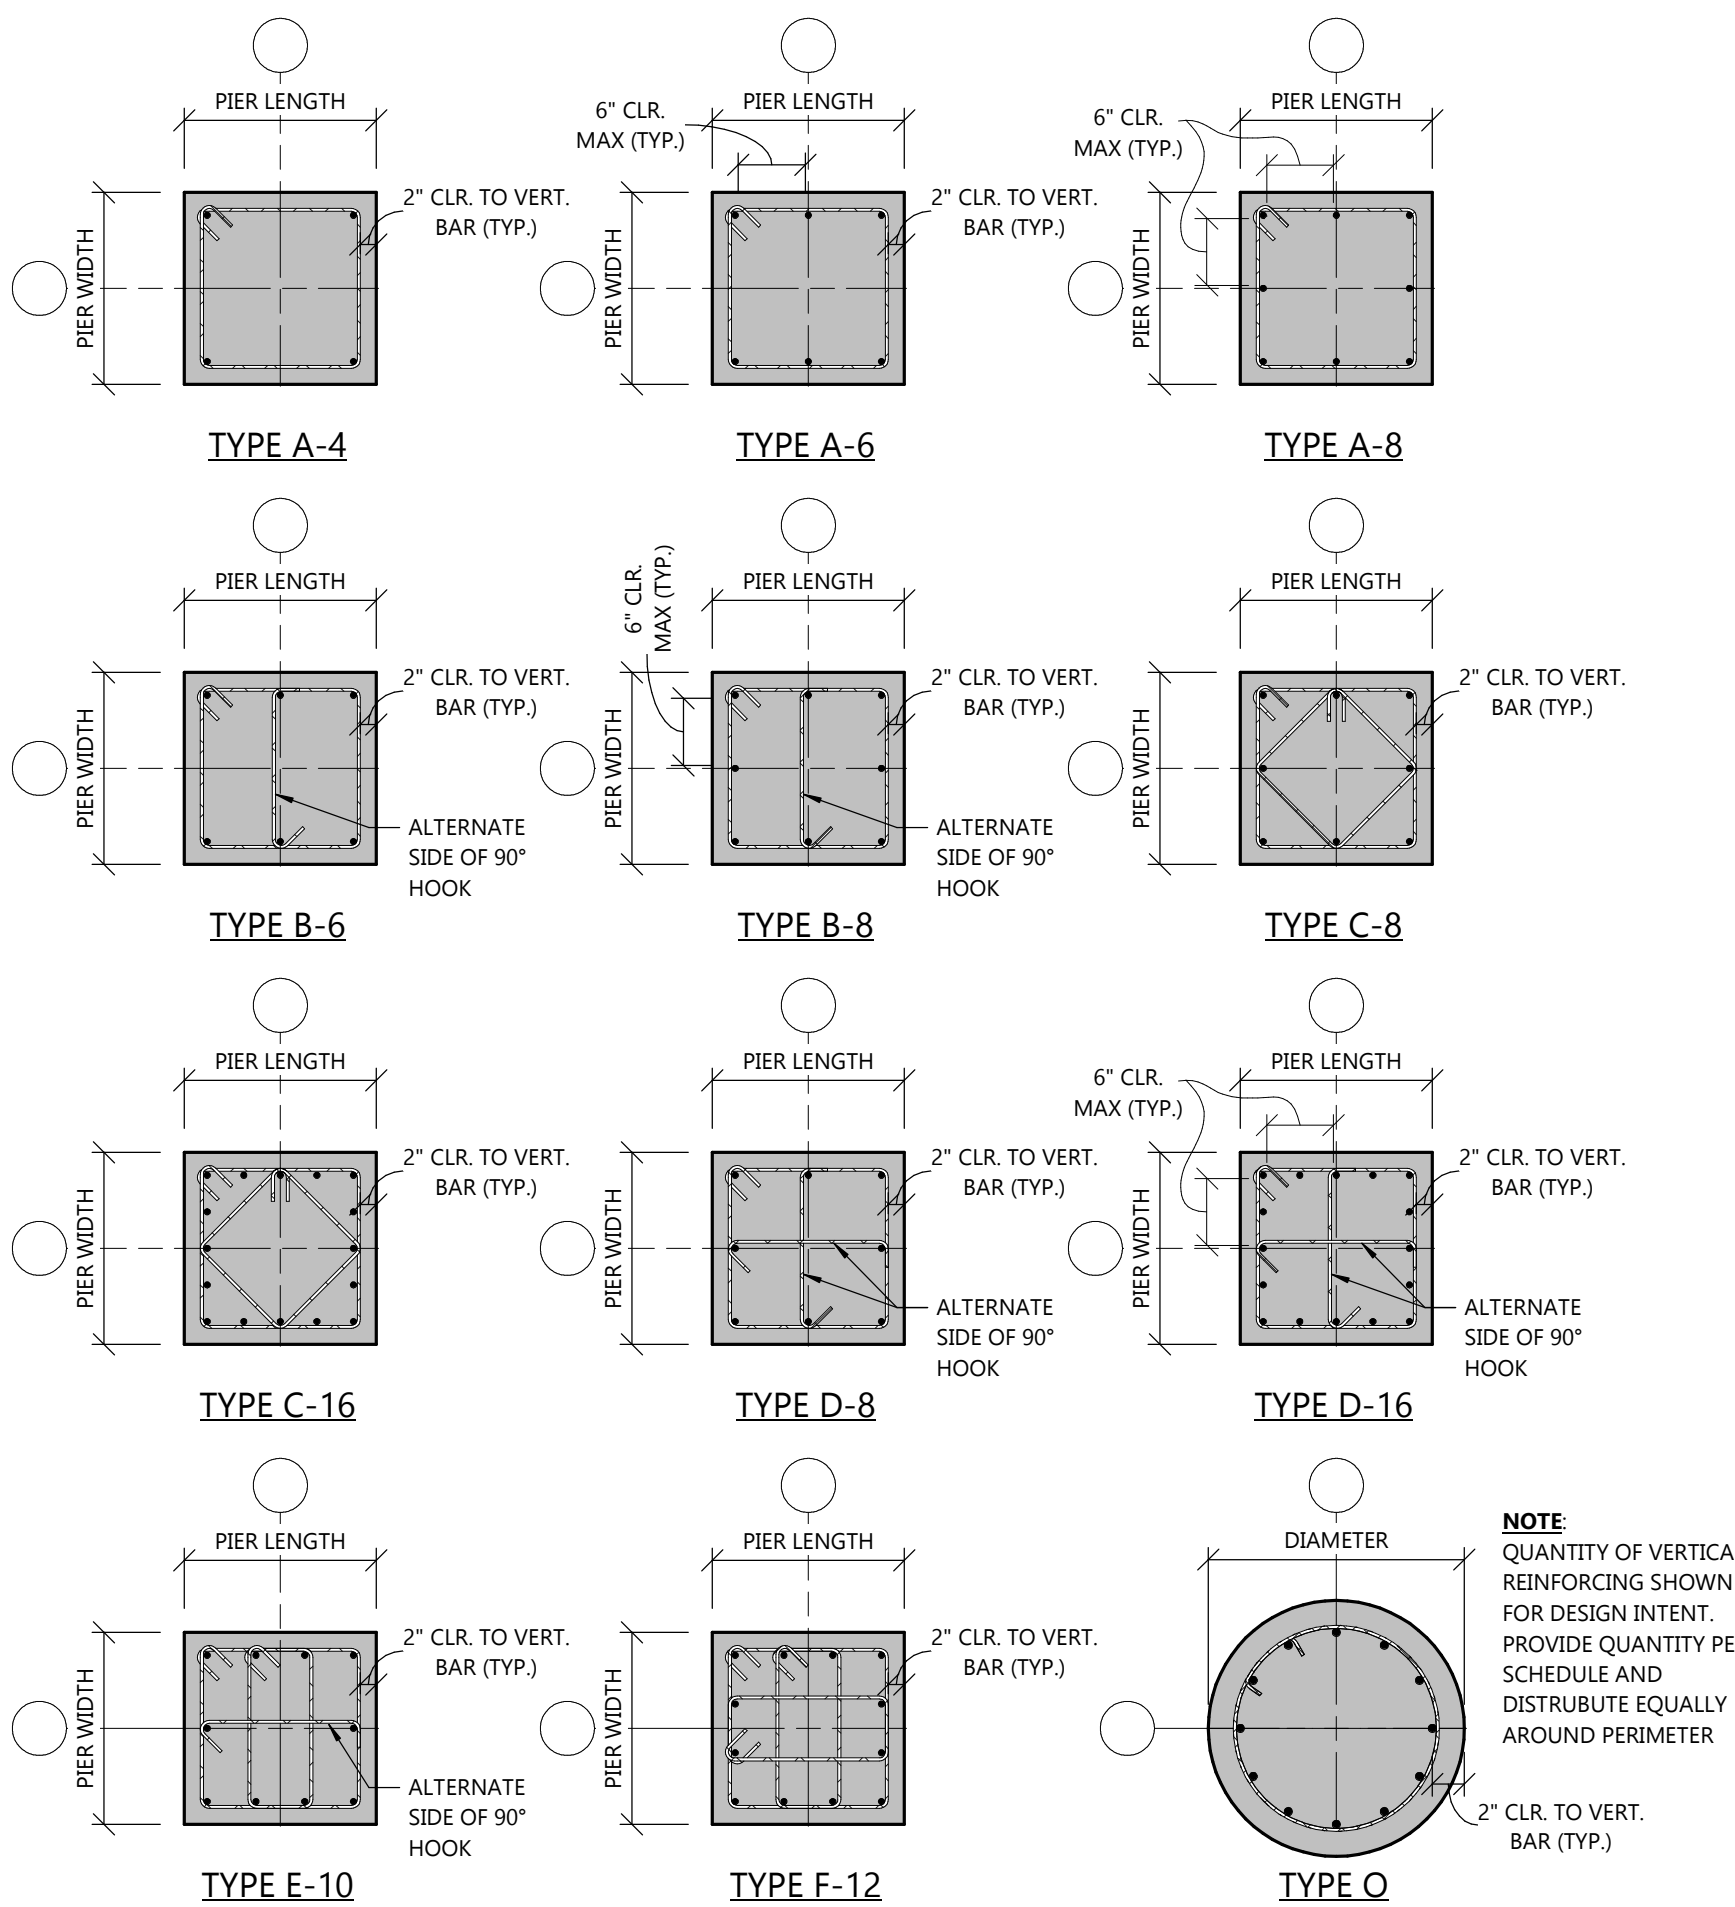


PIER REINFORCING TYPES

NOT TO SCALE

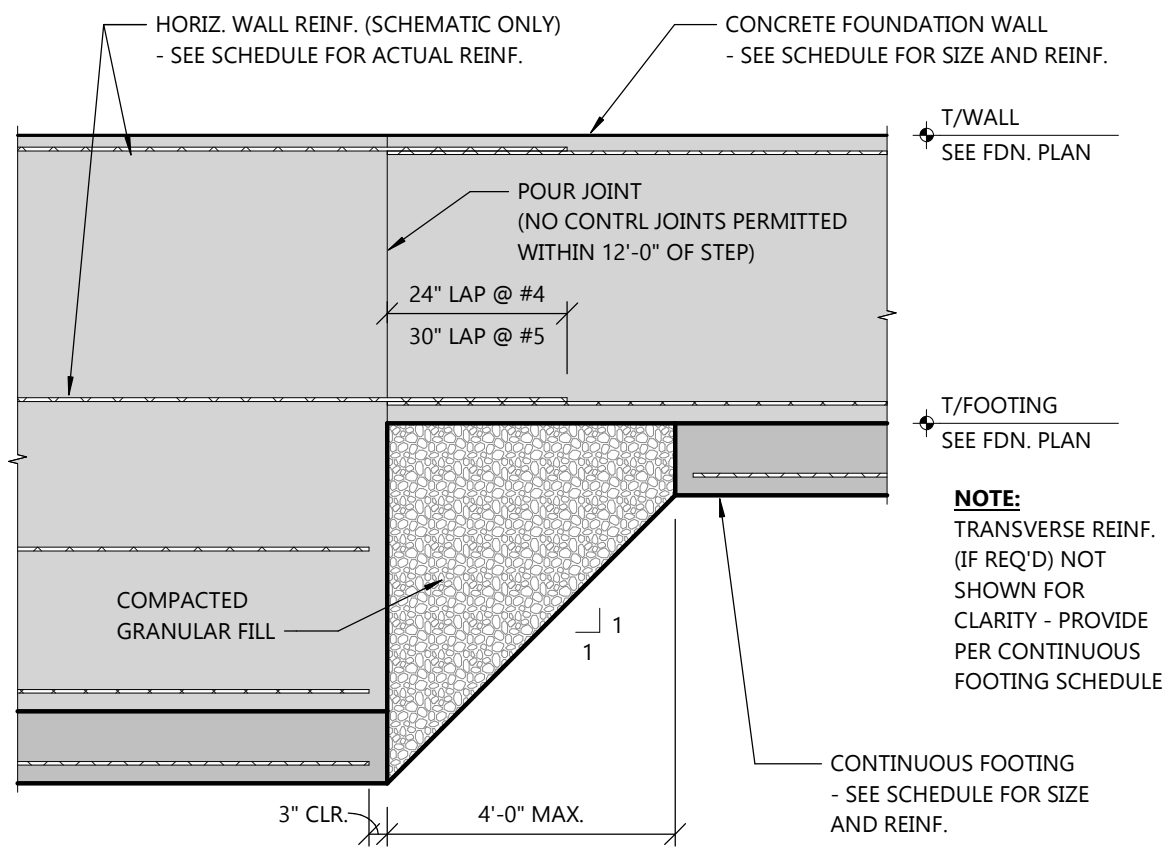

STEPPED FOOTING DETAIL

NOT TO SCALE

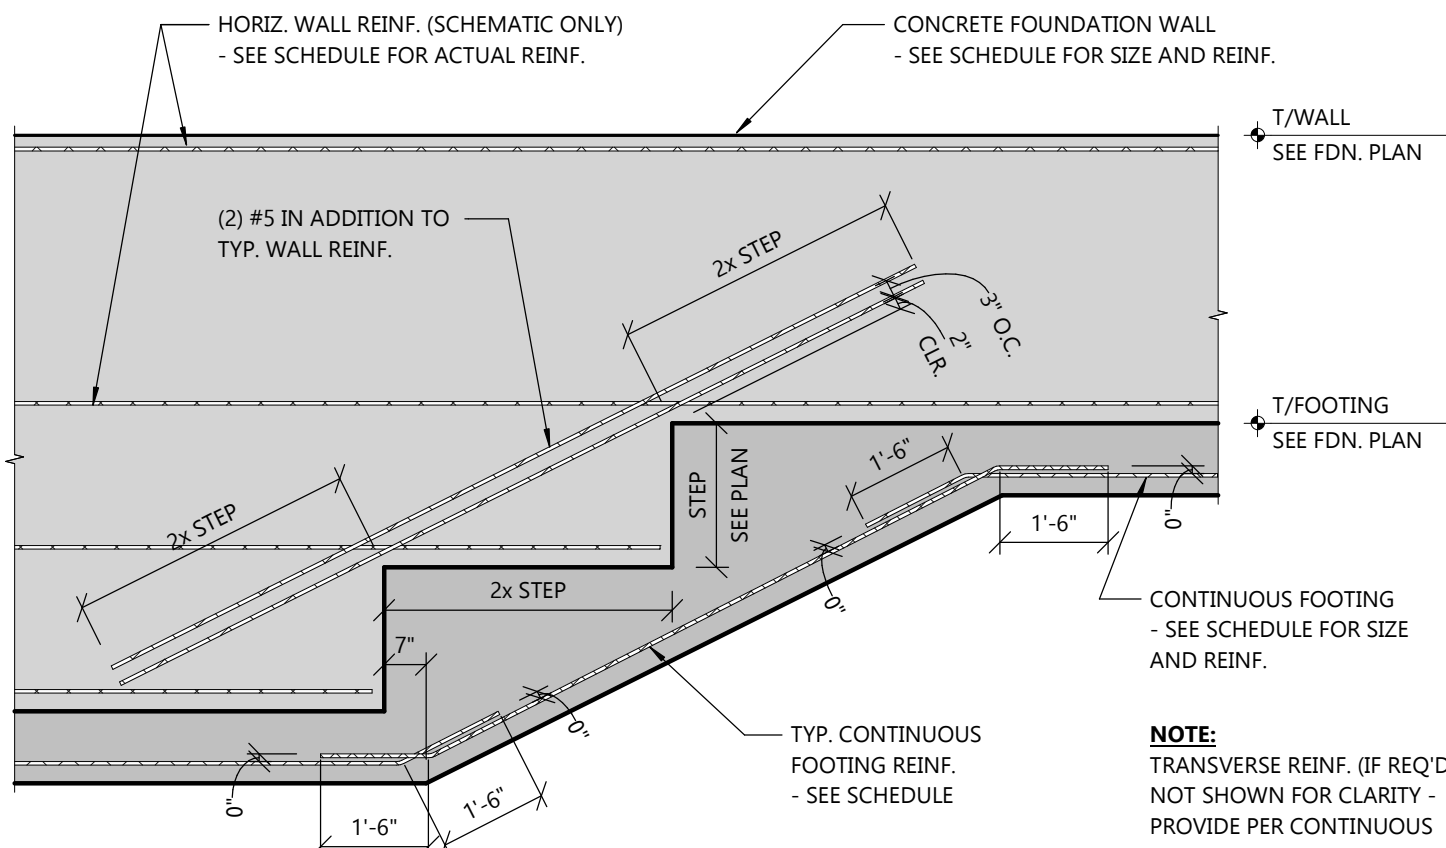

TYPICAL SONOTUBE DETAIL

NOT TO SCALE

NOTES:

- BASE PLATE CONFIGURATION PER PEMB SUPPLIER.
- ALL ANCHOR BOLTS SHALL BE INSTALLED FREE OF DIRT, OIL, OR ANY OTHER CONTAMINANTS WHICH MAY DESTROY OR REDUCE BOND TO CONCRETE PER SSPC-SP1.
- ANCHOR BOLTS SHALL BE PLACED IN FORMS PRIOR TO POURING CONCRETE TO ENSURE PROPER CONSOLIDATION OF CONCRETE AROUND ANCHOR BOLTS. ANCHOR BOLT MUST NOT BE PUSHED INTO ALREADY POURED CONCRETE.

MARK	BASE CONDITION			BASE PLATE (PER PEMB DWG.)			BASE ANCHOR			REMARKS
	TYPE	GROUT		TYPE (SEE PEMB)	SIZE		TYPE	SIZE		
		REQ'D	THICK.		W	L		DIA.	EMBED.	
B1	1	No		1	8"	10"	1	1"	24"	
B2	1	No		1	12"	18"	1	1"	24"	
B3	1	No		1	12"	24"	1	1"	24"	


- PRE-ENGINEERED METAL BUILDING (PEMB) ANCHOR BOLTS TO BE LOCATED PER METAL BUILDING ANCHOR BOLT PLAN IN CONJUNCTION w/ STRUCTURAL FOUNDATION PLAN.

- HAIRPIN REINFORCING AT COLUMNS NOTED ON PLANS IS REQUIRED TO MAINTAIN THE STRUCTURAL STABILITY OF THE BUILDING. THESE HAIRPINS SHALL NOT BE CUT OR REMOVED.
- CROSS TIE REINFORCING BETWEEN COLUMNS NOTED ON PLANS IS REQUIRED TO MAINTAIN THE STRUCTURAL STABILITY OF THE BUILDING. THESE CROSS TIES SHALL NOT BE CUT OR REMOVED.
- ARCHITECT/ENGINEER TO APPROVE FOUNDATION DETAILS w/ FINAL METAL BUILDING REACTIONS AND BASE PLATE LAYOUTS PRIOR TO POURING BUILDING FOUNDATIONS.

- FOUNDATION DESIGN IS ON HOLD PENDING FINAL PEMB SHOP DRAWINGS AND BASE REACTIONS, DO NOT PRODUCE SHOP DRAWINGS, FABRICATE REBAR, OR INSTALL FOUNDATIONS UNTIL FINAL DESIGN IS COMPLETE.

- ANCHOR BOLT LAYOUT AND SCHEDULE IS BASED ON DRAWINGS/REACTIONS PROVIDED TO EXCEL BY PEMB SUPPLIER DATED FEB. XX, 202X. ANY UPDATES AFTER THIS DATE HAVE NOT BEEN ACCOUNTED FOR IN ANCHOR BOLT/FOUNDATION DESIGN AND MUST BE VERIFIED BY EXCEL PRIOR TO ANY WORK.

- PEMB SUPPLIER TO DESIGN PEMB STRUCTURE FOR LATERAL AND GRAVITY LOADS PROVIDED:
 - **NOTE:** DESIGN FOR ALL LOADS SHOWN ON FRAMING PLANS AND 30 SHEETS. SEE SPECIFICATIONS FOR REQUIREMENTS OF DELEGATED DESIGN SUBMITTALS. STAMPED PLANS AND CALCULATIONS TO BE SUBMITTED TO EXCEL ENGINEERING FOR REVIEW PRIOR TO FABRICATION.
- ALL PEMB ANCHOR BOLTS MUST BE CAST-IN-PLACE. POST INSTALLED ANCHORS WILL NOT BE ACCEPTED.
- PEMB BASE PLATE DETAIL REFERS TO BUILDING SUPPLIER ANCHOR BOLT PLANS & DETAILS.
- VERIFY BOLT PROJECTION WITH PEMB SUPPLIER.
- PIER OUTLINES & ANCHOR BOLT LOCATIONS ARE FOR GENERAL REFERENCE. SEE FOUNDATION PLAN & PEMB DRAWINGS FOR FINAL DIMENSIONAL INFORMATION.

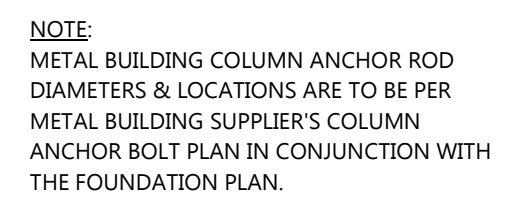

NORTH SCALE: $1/8" = 1'-0"$



A horizontal scale bar with alternating black and white segments. It is marked with '0'', '8'', and '16'' at the bottom.



PEMB COLUMN BASE CONDITION TYPES



PEMB COLUMN ANCHOR TYPES

STRUCTURAL PEMB ANCHOR BOLT SETTING PLAN



100 Camelot Drive
Fond du Lac, WI 54935
920-926-9800
excelengineer.com

STORAGE WAREHOUSE EXPANSION FOR:

STORAGE WAREHOUSE EXPANSION FOR:
WEST POINT DAIRY PRODUCTS
570 NORTH 500 WEST • HYRUM, UT 84319

PROFESSIONAL SEAL

ALLOTTED FOR BUDGET

APR. 17, 2026

3 NUMBER

50429500

SHEET NUMBER

S2.1

NOT FOR CONSTRUCTION

PROJECT INFORMATION

STORAGE WAREHOUSE EXPANSION FOR:
WEST POINT DAIRY PRODUCTS
570 NORTH 500 WEST • HYRUM, UT 84319

PROFESSIONAL SEAL

NOT FOR CONSTRUCTION

SHEET DATES

ISSUED FOR BUDGET

IFB APR. 17, 2026

JOB NUMBER

250429500

SHEET NUMBER


S2.2

CONCRETE SLAB ON GRADE SCHEDULE

NOTES:


- SEE STRUCTURAL SPECIFICATIONS FOR MATERIAL REQUIREMENTS.
- "EARLY-ENTRY" SAWCUT JOINTS ARE DEFINED AS SAWCUTTING 1 TO 4 HOURS AFTER PLACEMENT USING A DRY-CUT SAW WITH A SKID PLATE (1 HOUR IN HOT WEATHER & 4 HOURS IN COLD WEATHER).
- "WET-CUT" SAWCUT JOINTS ARE NOT PERMITTED.
- MICRO FIBER REINFORCING = FRC - BI BLEND 300 FIBRILATED MICRO FIBERS (ASTM C116 TYPE III).
- MACRO FIBER REINFORCING = FORTA FERRO MACRO FIBERS (ASTM 116 TYPE III). FINAL FIBER DOSAGE MUST BE VERIFIED w/ FIBER REINFORCING & CONSULTING, LLC AND INCLUDED IN CONCRETE MIX SUBMITTAL - CONTACT: DAN LARGE AT 262-685-7749 OR DAN.LARGE@FRCLLC.US

MARK	DESCRIPTION	CONCRETE							SLAB JOINTING						BELOW SLAB INSULATION		REQUIRED FINISH FLOOR ELEVATION COORDINATION	REMARKS
		THICKNESS	STEEL REINFORCING		LOCATION	TYPE	FIBER	SAWCUT JOINT (SJ)		CONSTRUCTION JOINT (CJ)		POUR JOINT (PJ)		TOTAL THICKNESS	MIN. COMP. STRENGTH			
			REINFORCING					MAX. JOINT SPACING	TYPE	MAX. JOINT SPACING	TYPE	MAX. JOINT SPACING	TYPE					
SG8	8" HEAVY DUTY	8"	#5 @ 16" O.C. EA WAY	CENTERED	AND	MICRO	1.5 LBS/CU YD	SJ-B	16'-0"	CJ-A	60'-0"	PJ-A	60'-0"					

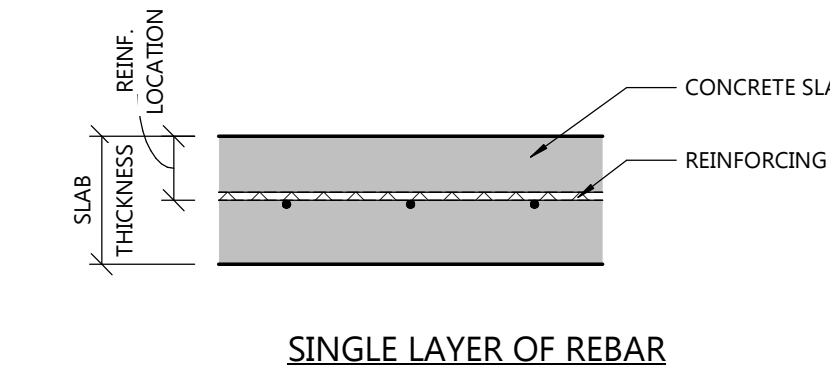


REINFORCING DETAIL

NOT TO SCALE

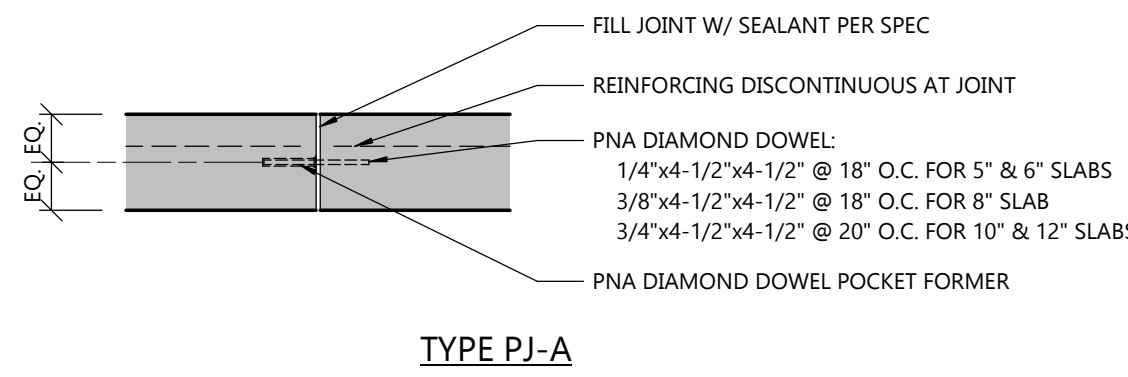


POUR JOINT TYPES

NOT TO SCALE

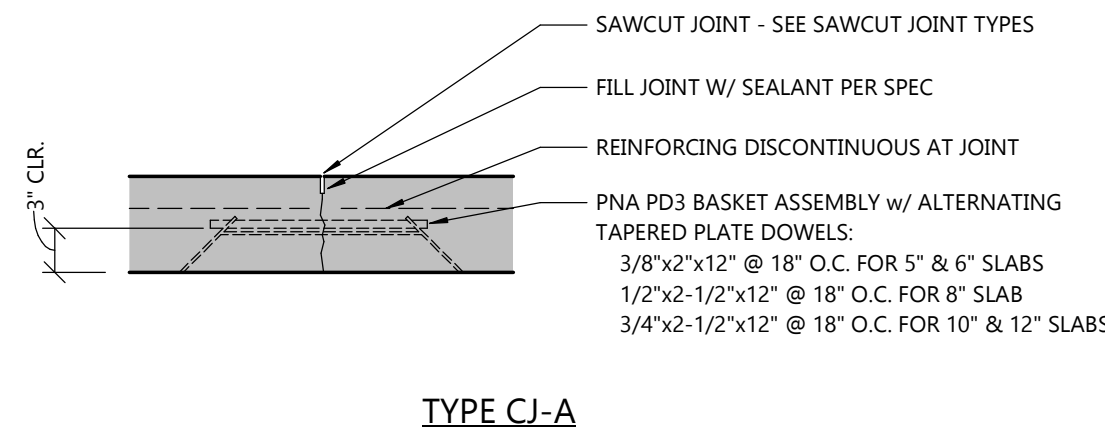


CONSTRUCTION JOINT TYPES

NOT TO SCALE

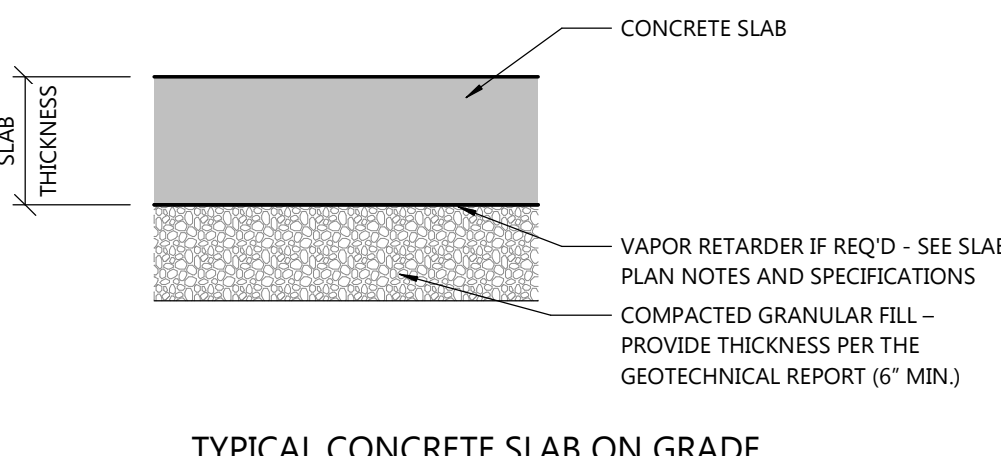


CONCRETE SLAB ON GRADE DETAIL

NOT TO SCALE

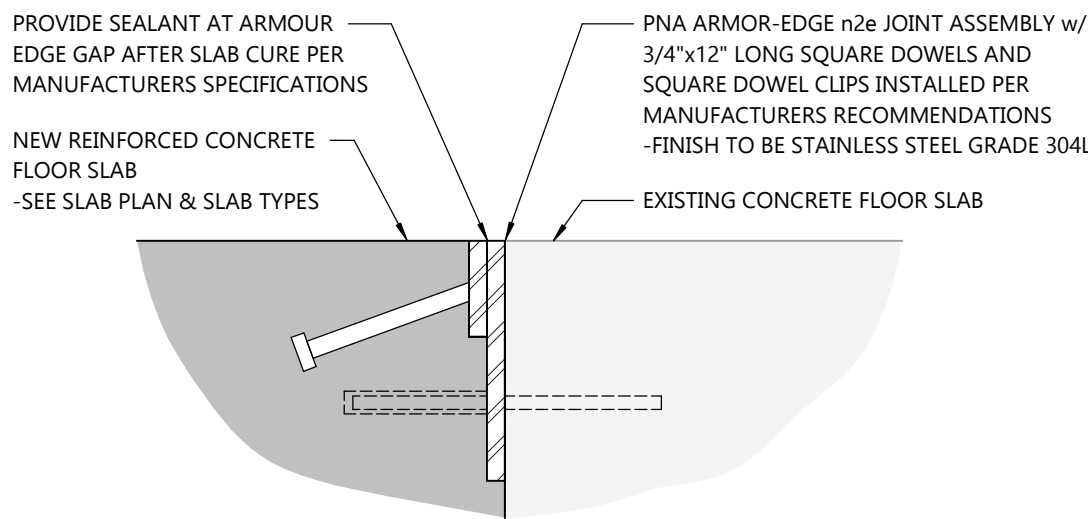

ARMOR JOINT AT EXISTING SLAB DETAIL

NOT TO SCALE

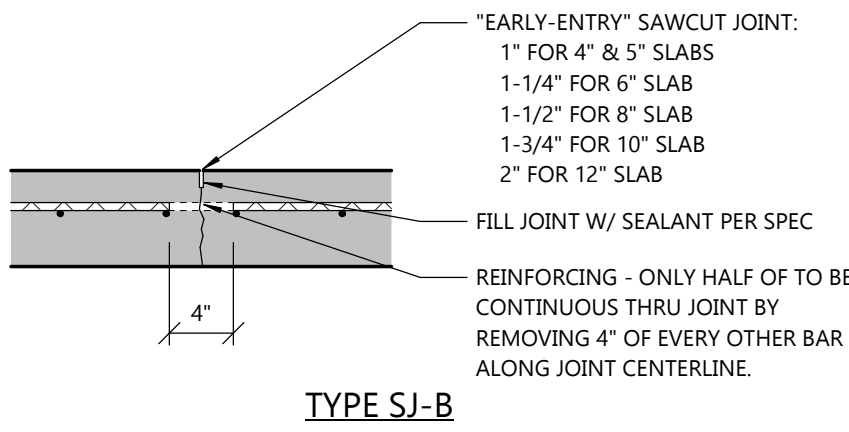

SAWCUT JOINT TYPES

NOT TO SCALE

CONCRETE S.O.G. DESIGN CAPACITY SCHEDULE

NOTES:

- AXLE LOAD CAPACITY BASED ON WHEEL SPACING OF 3 FT AND TIRE INFLATION PRESSURE OF 110 PSI.
- RACKING LEG LOAD CAPACITIES BASED ON LEG SPACING OF 4 FT x 4 FT AND MIN. PLATE SIZE OF 3 IN x 5 IN.
- RACKING LEG LOAD PLATE DIMENSIONS PROVIDED FOR GENERAL USE. CONTACT EXCEL ENGINEERING FOR ALTERNATE PLATE CONDITIONS PRIOR TO APPLICATION OF LOAD.
- TABLE LOADS ARE GIVEN AS ALLOWABLE LOADS (ASD) FOR MAXIMUM COMBINED LOADING.

MARK	SLAB DESIGN CAPACITIES			REMARKS
	MAX. UNIFORM LOAD	MAX. AXLE LOAD	MAX. RACKING LEG LOAD	
SG8	1,200 PSF	20,000#	12,000#	

PROFESSIONAL SEAL

SHEET DATES

ISSUED FOR BUDGET

 
 
 
 
IFB APR. 17, 2026

JOB NUMBER

250429500

SHEET NUMBER

S2.3



FIRE PROTECTION SPECIFICATIONS

DIVISION 21 FIRE PROTECTION

21 05 00 BASIC FIRE PROTECTION REQUIREMENTS

- A. SEE DIVISION 00 PROCUREMENT AND CONTRACTING AND DIVISION 01 GENERAL REQUIREMENT FOR ADDITIONAL REQUIREMENTS AND DIVISION OF WORK DESCRIPTION.
- B. SHOP DRAWINGS, PRODUCT DATA, TEST RESULTS AND SAMPLE SUBMITTALS.
1. SEE DIVISION 01 31 22 SHOP DRAWINGS, PRODUCT DATA, AND SAMPLES FOR ADDITIONAL REQUIREMENTS.
2. FIRE PROTECTION CONSTRUCTION ADMINISTRATION SUBMITTAL LIST.
- a. ALL SCHEDULED EQUIPMENT
- b. SPRINKLER SYSTEM/FIRE PROTECTION PLANS
- c. HANGERS
- d. PIPE IDENTIFICATION
3. AS-BUILT DRAWINGS SHALL BE MARKED ON A FINAL SET OF DRAWINGS WHICH INCLUDES ALL REVISIONS.
- C. FINISHING AND PAINTING
1. IF FINISH BECOMES RUSTED, CORRODED, OR FLAKED DURING STORAGE OR INSTALLATION, REFINISH THE PIPING OR EQUIPMENT TO THE SATISFACTION OF THE OWNER.
- D. INSTALL ALL EQUIPMENT PER MANUFACTURER'S INSTALLATION INSTRUCTIONS AND REQUIREMENTS. PROVIDE ADDITIONAL WORK AND MATERIALS AS REQUIRED.
- E. DETAILS AND SCHEDULES ARE SHOWN TO AID THE CONTRACTOR AND ARE NOT MEANT TO BE INCLUSIVE OF ALL DEVICES. PROVIDE REQUIRED EQUIPMENT AND ACCESSORIES FOR A COMPLETE INSTALLATION.
- F. FULLY COOPERATE WITH OTHER TRADES AND FURNISH ANY INFORMATION NECESSARY TO PERMIT THE WORK OF OTHER TRADES TO BE INSTALLED WITH LEAST POSSIBLE INTERFERENCE OR DELAY.
- G. COORDINATE WORK WITH OTHER CONTRACTORS AND MAKE ADJUSTMENTS TO THE FIRE PROTECTION SYSTEM INSTALLATION WHERE IT WILL BE INSTALLED IN CLOSE PROXIMITY TO THE WORK OF OTHER TRADES.
- H. IF THE FPC INSTALLS WORK BEFORE COORDINATING IT WITH OTHER TRADES SO AS TO CAUSE INTERFERENCE WITH WORK OF OTHER TRADES, THE FPC SHALL MAKE NECESSARY CHANGES IN THE WORK TO CORRECT THE CONDITION WITHOUT EXTRA CHARGES.
- I. PROVIDE ALL CUTTING AND PATCHING NECESSARY FOR FIRE PROTECTION WORK INSTALLATION UNLESS THIS WORK IS IDENTIFIED TO BE THE WORK OF OTHER CONTRACTORS. PATCHING SHALL MATCH ADJACENT SURFACES.
- J. FIRE RATED INTERIOR WALL AND FLOOR PENETRATIONS
1. SLEEVE REQUIRED FOR PENETRATION OF CONCRETE AND MASONRY WALLS AND FLOORS.
2. SEAL OPENING AROUND PIPE WITH A UL APPROVED FIRE STOP SYSTEM HAVING AN F-RATING NOT LESS THAN THE HOURLY RATING OF THE ASSEMBLY BEING PENETRATED.
3. FIRE-RESISTIVE JOINT SYSTEM PRODUCTS BY THE SAME MANUFACTURER AS BEING USED ON THE REMAINDER OF THE PROJECT.
- K. PROVIDE UL ASSEMBLY PENETRATION NUMBER TO AHJ COMPLIANT WITH BUILDING UL ASSEMBLY 30 DAYS PRIOR TO INSTALLATION IF REQUIRED BY AHJ.
- L. SEE PLANS FOR ADDITIONAL WALL AND FLOOR PENETRATION DETAILS.
- M. ESCUTCHEONS
1. INSTALL ONE-PIECE (TWO PIECE FOR EXISTING PIPING) POLISHED CHROME PLATED STEEL ESCUTCHEONS AT PENETRATIONS EXPOSED IN FINISHED ROOMS (ROOMS WHICH DON'T HAVE UNFINISHED CONCRETE FLOORS).
2. ESCUTCHEONS WITH SPRINGS FOR WALL AND CEILING LOCATIONS.
3. ID TO CLOSELY FIT AROUND PIPE/INSULATION, CO THAT COMPLETELY COVERS THE OPENING.
- N. PROVIDE A COMPLETE DESIGN/BUILD FIRE PROTECTION SYSTEM FOR THE PROPOSED PROJECT.
- O. THE REQUIREMENTS OF MUNICIPAL AND STATE CODES, LAWS, ORDINANCES AND REGULATIONS, AND NFPA ARE MADE PART OF THESE SPECIFICATIONS AND SHALL BE COMPLIED WITH AS FAR AS THEY APPLY TO THE WORK.
- P. CONTRACTOR SHALL BE RESPONSIBLE FOR DESIGNING AND SIZING THE DISTRIBUTION SYSTEMS BY HYDRAULIC CALCULATION, AND SHALL PROVIDE THE NECESSARY ENGINEERING DRAWINGS AND CALCULATIONS TO OBTAIN ACCEPTANCE OF ALL AUTHORITIES HAVING JURISDICTION.
- Q. DESIGN COORDINATION
1. REVIEW DESIGN AND PROJECT SCOPE AND INFORM EXCEL ENGINEERING INC. OF ANY SPRINKLER SYSTEM IMPACTS ON BUILDING DESIGN WITHIN 7 DAYS OF CONTRACTOR SELECTION.
2. IF FIRE PROTECTION DESIGN REQUIRES ANY MODIFICATIONS OR ADDITIONS TO THE BUILDING AFTER CONSTRUCTION BEGINS, IN ORDER TO MEET THE SPRINKLER SYSTEM REQUIREMENTS, THE CONTRACTOR SHALL BE RESPONSIBLE FOR THE COST OF MODIFICATIONS OR ADDITIONS OR SHALL SPECIFICALLY NOTE IN THE BID THE WORK REQUIRED.
- R. RACK STORAGE
1. INCLUDE WITH BID THE FOLLOWING INFORMATION:
- a. LIST OF ITEMS REQUIRING ELECTRICAL CONNECTION, AND THE ASSOCIATED LOAD.
- b. DESCRIPTION OF SPRINKLER SYSTEM PROPOSED FOR RACK STORAGE AREAS INCLUDING:
- 1). ASSUMED FUEL SPACE
- 2). NUMBER OF HORIZONTAL BARRIERS REQUIRED, IF ANY, AND LEVELS.
- 3). NUMBER OF ROWS OF IN-RACK SPRINKLERS, AND LEVELS.
- 4). SPRINKLER LOCATIONS.
- 5). MEANS OF ACHIEVING SPRINKLER/PIPE PROTECTION IN RACKS.
- c. AREA REQUIRED FOR SPRINKLER RISER AND EQUIPMENT.
2. PARTICIPATE IN ANY PRE-BID MEETINGS OR WALK-THROUGHS WITH GC AND OWNER TO VERIFY STORAGE REQUIREMENTS.
3. DOCUMENT IN BID ALL ASSUMPTIONS RELATED TO STORAGE OCCUPANCIES.
4. INFORMATION PROVIDED IS INTENDED TO PROVIDE A BASIS OF DESIGN WITH INFORMATION AVAILABLE AT TIME OF SCOPE DRAWING ISSUE.
- a. CONTRACTOR SHALL VERIFY DESIGN CRITERIA PRIOR TO BEGINNING OF DESIGN.
- b. FAILURE TO DO SO IS CONTRACTOR'S RESPONSIBILITY AS THE LICENSED DESIGN PROFESSIONAL, NOT OWNER'S OR EXCEL'S.
5. IN-RACK SPRINKLERS
- a. COORDINATE PIPE ROUTING, SPRINKLER PLACEMENT, REQUIRED FUEL SPACES, REQUIRED HORIZONTAL BARRIERS AND RACK HEIGHTS TO ACHIEVE REQUIRED CLEARANCES WITH RACK SUPPLIER. CONTRACTOR SHALL OBTAIN WRITTEN APPROVAL FROM RACK SUPPLIER THAT PIPES AND SPRINKLERS DO NOT INTERFERE WITH PALLET PLACEMENT AND THAT PIPE ROUTING DOES NOT CAUSE ANY CONFLICTS WITH THE RACKS.
- b. REVIEW PIPE ROUTING AND SPRINKLER PLACEMENT WITH OWNER PRIOR TO INSTALLATION FOR ACCEPTABILITY OF PIPE AND SPRINKLER PLACEMENT. PROVIDE MEETING MINUTES OF THE MEETING.
- c. VERIFY AND DOCUMENT TOP OF PRODUCT HEIGHTS AND REQUIRED CLEARANCES NEEDED FOR PALLET PLACEMENT AT EACH RACK LEVEL WITH OWNER AND RACK SUPPLIER. CONTRACTOR TO OBTAIN OWNER SIGNOFF BEFORE INSTALLING ANY PIPING.
- d. IN-RACK SPRINKLER PIPING AND SPRINKLERS SHALL NOT BE INSTALLED ABOVE PALLET LOAD AREA UNLESS SPECIFICALLY IDENTIFIED BY CONTRACTOR AND SIGNED OFF BY OWNER. ALL PIPING AND SPRINKLERS SHALL BE LOCATED OUT OF HARMS WAY. PROVIDE PROTECTION WHEN NEEDED TO PREVENT ACCIDENTAL DAMAGE.
- R. COMPLETE DESIGN AND SUBMIT FOR APPROVAL TO AUTHORITIES HAVING JURISDICTION WITHIN 60 DAYS OF CONTRACT AWARD. CONSTRUCTION REWORK COSTS INCURRED BY OTHER CONTRACTORS DUE TO FAILURE BY FPC TO OBTAIN APPROVAL IN A TIMELY MANNER SHALL BE BORNE BY THE FIRE PROTECTION CONTRACTOR.
- S. DRAWINGS INDICATING NEW FIRE PROTECTION SYSTEMS TO BE INSTALLED WITH PIPE SIZES, ETC., AND COPY OF SYSTEMS HYDRAULIC CALCULATIONS SHALL BE SUBMITTED TO THE FOLLOWING FOR REVIEW.
1. EXCEL ENGINEERING
2. NUMBER OF PRINTS AS REQUIRED TO LOCAL FIRE DEPARTMENT AUTHORITY.
3. NUMBER OF PRINTS AS REQUIRED TO OWNER'S INSURING AUTHORITY.
4. PROVIDE A COPY OF ALL REVIEW COMMENTS FROM LOCAL FIRE DEPARTMENT AUTHORITY AND OWNER'S INSURING AUTHORITY, ALONG WITH ANY RESPONSE TO SAID COMMENTS TO EXCEL ENGINEERING FOR THEIR RECORDS.
- T. FIRE PROTECTION CONTRACTOR SHALL BE RESPONSIBLE FOR STATE OF UTAH AND/OR LOCAL SUBMITTAL AND PLAN REVIEW FEES.
- U. FIRE PROTECTION CONTRACTOR SHALL BE LICENSED BY THE STATE OF UTAH TO FURNISH AND INSTALL FIRE PROTECTION SYSTEMS.
- V. LEAVE SYSTEM IN PROPER WORKING CONDITION AT THE TIME OF FINAL CLEAN-UP.
1. FURNISH THE NECESSARY SKILLED, QUALIFIED PERSONNEL FOR OPERATING THE SYSTEM FOR A TOTAL OF ONE HALF HOUR (65) UPON COMPLETION OF ALL WORK AND TESTS.
2. INSTRUCT THE OWNER'S REPRESENTATIVE FULLY IN THE OPERATION, ADJUSTMENT AND MAINTENANCE OF EQUIPMENT FURNISHED.
3. MAINTAIN A RECORD OF OPERATING INSTRUCTION PERIODS, DOCUMENTING THE DATE, TIME INVOLVED, PEOPLE IN ATTENDANCE AND HAVE THE OWNER'S REPRESENTATIVE ATTEST IN WRITING FOR EACH SESSION HELD.
- W. AVAILABLE WATER FLOW DATA
1. FIRE FLOW TEST
- a. TEST TAKEN BY: CITY OF HYRUM.
- b. DATE TAKEN: SEPTEMBER, 25, 2025.
- c. STATIC PRESSURE: 110 PSIG.
- d. RESIDUAL PRESSURE: 65 PSIG.
- e. GPM FLOWING: 1,300 GPM.
2. WATER TEST DATA IS PRELIMINARY FOR BIDDING PURPOSES. FPC IS RESPONSIBLE TO VERIFY AND OBTAIN ANY ADDITIONAL TEST DATA REQUIRED FOR DESIGN. TESTS TO BE REPRESENTATIVE OF HIGH WATER FLOW PERIODS.
- X. TESTS AND INSPECTIONS
1. CONTRACTOR SHALL BE RESPONSIBLE FOR TESTING AND CERTIFICATION OF SYSTEMS AND ORDERING INSPECTIONS AS REQUIRED BY AUTHORITIES HAVING JURISDICTION.
2. ALL TESTS SHALL BE CONDUCTED IN THE PRESENCE OF AND TO THE SATISFACTION OF THE OWNER OR AN AUTHORIZED REPRESENTATIVE.
3. INSPECTIONS SHALL BE MADE BY THE OWNER'S AUTHORIZED REPRESENTATIVE AND INSPECTORS HAVING JURISDICTION.

21 13 17 AUTOMATIC SPRINKLER SYSTEMS

- A. SYSTEM DESCRIPTION
1. PROVIDE AUTOMATIC SPRINKLER SYSTEM TO PROTECT BUILDING AREA INDICATED.
2. SYSTEM DESIGN SHALL CONFORM TO SYSTEM SCHEDULE ON THE DRAWINGS, AND COMPLY WITH NFPA 13 AND REQUIREMENTS OF LOCAL AUTHORITIES HAVING JURISDICTION.
- a. DEVIATIONS FROM THESE DOCUMENTS SHALL BE COMMUNICATED IN WRITING AT TIME OF BID SUBMITTAL.
3. UL LISTED AND LABELED SYSTEM COMPONENTS RATED FOR 175 PSIG MINIMUM OPERATING PRESSURE.
4. INCLUDE INSIDE AND OUTSIDE HOSE STREAMS IN THE DESIGN OF THE HYDRAULICALLY CALCULATED SPRINKLER SYSTEMS.
5. SIMILAR COMPONENT ITEMS SHALL BE BY THE SAME MANUFACTURER.
6. VALVE CLOSURE TIME SHALL NOT EXCEED LIMITATIONS SET BY NFPA 13.
- B. SPRINKLERS
1. MANUFACTURERS: VIKING, CENTRAL, TYCO.
2. SEE SCHEDULE ON PLANS.
3. MAY USE FLEXIBLE PENDENT SYSTEM AS LISTED FOR THE OCCUPANCY HAZARD OF THE SPACE BEING PROTECTED.
- C. EX. FIRE RISERS
1. COVERAGE THIS AREA TO BE ADDED UNDER EXCEL JOB # 250231400
2. EX. FIRE RISER
3. COVERAGE THIS AREA TO BE ADDED UNDER EXCEL JOB # 250290700
4. EX. FIRE SERVICE
5. NEW ZONE 6 (WET) (11,500 S.F.)
6. EX. SYSTEM #4 ZONE 5 (WET) (9,500 S.F.)
7. EX. SYSTEM #2 ZONE 2 (WET) (3,280 S.F.)
8. EX. SYSTEM #3 ZONE 3 (WET) (24,000 S.F.)
9. EXISTING DRY ZONE (5,700 S.F.)
10. EXISTING ZONE 1 (WET) (24,100 S.F.)
11. EX. FIRE RISER
12. COVERAGE THIS AREA TO BE ADDED UNDER EXCEL JOB # 250290700
13. EX. FIRE RISER
14. COVERAGE THIS AREA TO BE ADDED UNDER EXCEL JOB # 250231400
15. EX. FIRE RISER
16. COVERAGE THIS AREA TO BE ADDED UNDER EXCEL JOB # 250231400
17. EX. FIRE RISER
18. COVERAGE THIS AREA TO BE ADDED UNDER EXCEL JOB # 250231400
19. EX. FIRE RISER
20. COVERAGE THIS AREA TO BE ADDED UNDER EXCEL JOB # 250231400
21. EX. FIRE RISER
22. COVERAGE THIS AREA TO BE ADDED UNDER EXCEL JOB # 250231400
23. EX. FIRE RISER
24. COVERAGE THIS AREA TO BE ADDED UNDER EXCEL JOB # 250231400
25. EX. FIRE RISER
26. COVERAGE THIS AREA TO BE ADDED UNDER EXCEL JOB # 250231400
27. EX. FIRE RISER
28. COVERAGE THIS AREA TO BE ADDED UNDER EXCEL JOB # 250231400
29. EX. FIRE RISER
30. COVERAGE THIS AREA TO BE ADDED UNDER EXCEL JOB # 250231400
31. EX. FIRE RISER
32. COVERAGE THIS AREA TO BE ADDED UNDER EXCEL JOB # 250231400
33. EX. FIRE RISER
34. COVERAGE THIS AREA TO BE ADDED UNDER EXCEL JOB # 250231400
35. EX. FIRE RISER
36. COVERAGE THIS AREA TO BE ADDED UNDER EXCEL JOB # 250231400
37. EX. FIRE RISER
38. COVERAGE THIS AREA TO BE ADDED UNDER EXCEL JOB # 250231400
39. EX. FIRE RISER
40. COVERAGE THIS AREA TO BE ADDED UNDER EXCEL JOB # 250231400
41. EX. FIRE RISER
42. COVERAGE THIS AREA TO BE ADDED UNDER EXCEL JOB # 250231400
43. EX. FIRE RISER
44. COVERAGE THIS AREA TO BE ADDED UNDER EXCEL JOB # 250231400
45. EX. FIRE RISER
46. COVERAGE THIS AREA TO BE ADDED UNDER EXCEL JOB # 250231400
47. EX. FIRE RISER
48. COVERAGE THIS AREA TO BE ADDED UNDER EXCEL JOB # 250231400
49. EX. FIRE RISER
50. COVERAGE THIS AREA TO BE ADDED UNDER EXCEL JOB # 250231400
51. EX. FIRE RISER
52. COVERAGE THIS AREA TO BE ADDED UNDER EXCEL JOB # 250231400
53. EX. FIRE RISER
54. COVERAGE THIS AREA TO BE ADDED UNDER EXCEL JOB # 250231400
55. EX. FIRE RISER
56. COVERAGE THIS AREA TO BE ADDED UNDER EXCEL JOB # 250231400
57. EX. FIRE RISER
58. COVERAGE THIS AREA TO BE ADDED UNDER EXCEL JOB # 250231400
59. EX. FIRE RISER
60. COVERAGE THIS AREA TO BE ADDED UNDER EXCEL JOB # 250231400
61. EX. FIRE RISER
62. COVERAGE THIS AREA TO BE ADDED UNDER EXCEL JOB # 250231400
63. EX. FIRE RISER
64. COVERAGE THIS AREA TO BE ADDED UNDER EXCEL JOB # 250231400
65. EX. FIRE RISER
66. COVERAGE THIS AREA TO BE ADDED UNDER EXCEL JOB # 250231400
67. EX. FIRE RISER
68. COVERAGE THIS AREA TO BE ADDED UNDER EXCEL JOB # 250231400
69. EX. FIRE RISER
70. COVERAGE THIS AREA TO BE ADDED UNDER EXCEL JOB # 250231400
71. EX. FIRE RISER
72. COVERAGE THIS AREA TO BE ADDED UNDER EXCEL JOB # 250231400
73. EX. FIRE RISER
74. COVERAGE THIS AREA TO BE ADDED UNDER EXCEL JOB # 250231400
75. EX. FIRE RISER
76. COVERAGE THIS AREA TO BE ADDED UNDER EXCEL JOB # 250231400
77. EX. FIRE RISER
78. COVERAGE THIS AREA TO BE ADDED UNDER EXCEL JOB # 250231400
79. EX. FIRE RISER
80. COVERAGE THIS AREA TO BE ADDED UNDER EXCEL JOB # 250231400
81. EX. FIRE RISER
82. COVERAGE THIS AREA TO BE ADDED UNDER EXCEL JOB # 250231400
83. EX. FIRE RISER
84. COVERAGE THIS AREA TO BE ADDED UNDER EXCEL JOB # 250231400
85. EX. FIRE RISER
86. COVERAGE THIS AREA TO BE ADDED UNDER EXCEL JOB # 250231400
87. EX. FIRE RISER
88. COVERAGE THIS AREA TO BE ADDED UNDER EXCEL JOB # 250231400
89. EX. FIRE RISER
90. COVERAGE THIS AREA TO BE ADDED UNDER EXCEL JOB # 250231400
91. EX. FIRE RISER
92. COVERAGE THIS AREA TO BE ADDED UNDER EXCEL JOB # 250231400
93. EX. FIRE RISER
94. COVERAGE THIS AREA TO BE ADDED UNDER EXCEL JOB # 250231400
95. EX. FIRE RISER
96. COVERAGE THIS AREA TO BE ADDED UNDER EXCEL JOB # 250231400
97. EX. FIRE RISER
98. COVERAGE THIS AREA TO BE ADDED UNDER EXCEL JOB # 250231400
99. EX. FIRE RISER
100. COVERAGE THIS AREA TO BE ADDED UNDER EXCEL JOB # 250231400

21 05 13 ELECTRICAL WORK

- A. FURNISH AND INSTALL ALL ALARM, FLOW AND TAMPER SWITCHES, AND THE INTERFACE WIRING BETWEEN THEM. ALL DEVICES SHALL BE 110 VAC. PROVIDE TRANSFORMERS AS REQUIRED IF VOLTAGE REQUIREMENT IS LOWER THAN 110 VAC.
- B. ELECTRICAL CONTRACTOR IS RESPONSIBLE TO WIRE FROM THE AUTOMATIC SPRINKLER SYSTEM COMPONENTS TO THE BUILDING FIRE ALARM SYSTEM.

21 05 29 SUPPORTS AND HANGERS

- A. PROVIDE PIPE HANGERS AND SUPPORTS IN COMPLIANCE WITH NFPA 13.
- B. ALL HANGERS AND COMPONENTS SHALL BE GALVANIZED UNLESS NOTED OTHERWISE.
- C. PROVIDE SEISMIC RESTRAINT HANGERS AND SUPPORTS FOR PIPING AND EQUIPMENT AND OBTAIN APPROVAL FROM AUTHORITIES HAVING JURISDICTION.
1. SEISMIC DESIGN RESPONSIBILITIES FOR EQUIPMENT SUPPLIER.
2. THE EQUIPMENT SUPPLIER IS RESPONSIBLE FOR THE STRUCTURAL DESIGN OF THE PROVIDED EQUIPMENT INCLUDING ALL SUPPORTING ELEMENTS SUCH AS LEGS, SIZES, CURBS, AND ANCHORAGE.
3. DESIGN MUST INCORPORATE THE SEISMIC LOADS SPECIFIED IN THESE CONSTRUCTION DOCUMENTS AND ALL APPLICABLE BUILDING CODES AS WELL AS ALL RELATED SEISMIC DETAILING REQUIREMENTS.
4. SEE STRUCTURAL SPECIFICATIONS AND DESIGN CRITERIA ON THE 50 SHEETS FOR LIST OF SUBMITTALS AND DESIGN VALUES.
- D. HANGERS SHALL NOT BE ATTACHED TO JOIST BRIDGING.
- E. ATTACHMENT TO METAL DECK: HANGERS MAY BE ANCHORED TO METAL FLOOR/ROOF DECK IF ALL THE FOLLOWING CONDITIONS ARE MET:
1. MAXIMUM HANGER LOAD OF 50 LBS.
2. ANCHORED TO BOTTOM OF DECK FLUTES, NOT UPPER FLUTE.
3. ANCHOR LENGTH SHALL EXCEED DECK DEPTH.

21 05 53 IDENTIFICATION

- A. PROVIDE IDENTIFICATION PER NFPA 13

21 13 13 PIPING

- A. DESIGN REQUIREMENTS: ALL SYSTEM COMPONENTS SHALL BE RATED FOR THE MAXIMUM WORKING PRESSURE TO WHICH THEY ARE EXPOSED BUT NOT LESS THAN 175 PSIG.
- B. PIPE AND FITTINGS: PROVIDE PER NFPA 13
- C. RUBBER GASKETED OUTLET FITTINGS ONLY PERMITTED WHERE CONNECTING TO EXISTING PIPE SYSTEM.
- D. COORDINATION
1. COORDINATE LOCATIONS OF PIPING WITH PIPING, DUCTWORK, CONDUIT AND EQUIPMENT OF OTHER CONTRACTORS.
2. REVIEW DRAWINGS FOR EXACT LOCATION OF PIPE SPACES, CEILING HEIGHTS, CEILING GRID, LIGHT FIXTURES AND GRILLES BEFORE INSTALLING PIPING.
3. INSTALL WITH SUFFICIENT CLEARANCES FOR INSTALLATION OF OTHER CONTRACTOR'S WORK.
4. PIPING SHALL NOT OBSTRUCT SERVICE CLEARANCES REQUIRED FOR EQUIPMENT AND VALVES.
5. PIPING SHALL NOT BE INSTALLED BELOW OR WITHIN 45 DEGS OF LIGHT EDGE.
6. DO NOT ROUTE PIPING ABOVE TRANSFORMERS, PANELBOARDS, MOTOR CONTROL CENTERS, SWITCHBOARDS OR OTHER ELECTRICAL DISTRIBUTION EQUIPMENT.
- E. PREPARE EXPOSED PIPE, FITTINGS, SUPPORTS, AND ACCESSORIES NOT PREFINISHED, READY FOR FINISH PAINTING.
- F. INSTALLATION
1. INSTALL PIPE AND FITTINGS IN ACCORDANCE WITH NFPA 13, MANUFACTURER'S INSTALLATION INSTRUCTIONS AND RECOGNIZED INDUSTRY PRACTICES.
2. INSTALL PIPING TO CONSERVE BUILDING SPACE AND NOT INTERFERE WITH USE OF SPACE. CONCEAL PIPING WITHIN WALLS AND CHASES OR ABOVE CEILINGS.
3. INSTALL PIPING PARALLEL TO WALLS AND CEILINGS AND AT HEIGHTS WHICH DO NOT OBSTRUCT WINDOWS, DOORWAYS, STAIRWAYS, OR PASSAGEWAYS. OFFSET OR REROUTE PIPING TO CLEAR INTERFERENCE WHICH DEVELOP IN THE FIELD.

FIRE PROTECTION ZONE MAP

ELECTRICAL / FIRE ALARM COORDINATION SCHEDULE													
EQUIPMENT/DEVICE	LOCATION	IP	VOLT	PH	TYPE	STARTER		DISCONNECT	FIRE ALARM		REMARKS		
						LOCATION	MIN. SCCR RATING	FURN. BY	DIS-CONNECT	FURN. BY			
FLOW SWITCH	106	-	-	-	-	-	-	-	-	2	-	-	-
TAMPER SWITCH	106	-	-	-	-	-	-	-	-	2	(1)	-	-

- (1) FIRE PROTECTION CONTRACTOR TO DETERMINE IF TAMPER SWITCHES ARE REQUIRED.
- (2) QUANTITY IS ESTIMATED. FPC TO PROVIDE QUANTITY AS REQUIRED BY SYSTEM. PROVIDE ANY ADDITIONAL DEVICES RELATED TO THE WORK NOT SHOWN ON THE DRAWINGS. FPC SHALL PROVIDE POWER AND CONTROL WIRING INSTALLED PER ELECTRICAL SPECIFICATIONS FOR ANY DEVICES NOT LISTED.

DESIGN CRITERIA




DESIGNATION	SYSTEM TYPE	HAZARD/COMMODITY	MINIMUM DENSITY (3)	REMOTE AREA	HOSE ALLOWANCE	aisle WIDTH	ENCAP-SULATED	STORAGE HEIGHT	STORAGE IN RACKS	CARTONED	PLASTIC	TOTES
R1	WET	(1)	-	-	500 GPM	SEE PLAN	NO	21'-2"	(8)	NO	NA	NA
S1	WET	(1)	-	-	500 GPM	SEE PLAN	NO	21'-2"	(8)	NO	NA	NA

- CONTRACTOR SHALL VERIFY DESIGN CRITERIA.
- (3) INCREASE AREA OF OPERATION BY 30% FOR AREAS WITH SLOPED CEILING GREATER THAN 1 IN 6.
- (5) IDLE PALLET STORAGE.
- (8) IN-RACK SPRINKLER SYSTEM, PER CHAPTER 25 OF NFPA 13-2019

SPRINKLER REQUIREMENTS

TAG	APPLICATION	SYSTEM TYPE	MOUNTING	BODY MAT'L	ELEMENT	SPRINKLER FINISH	ESCUTCHEON		TEMPERATURE CLASSIFICATION	CENTER OF TILE
							TYPE	MAT'L/COLOR		
A	WAREHOUSE WITH CEILING	WET	PENDANT	BRASS	FUSIBLE LINK	NONE	FULL PENDANT	WHITE	ORDINARY	N/A
B	IN RACK SPRINKLERS	WET		BRASS	FUSIBLE LINK	NONE	N/A	N/A	ORDINARY	N/A

- ALL TEMPERATURES AS LISTED UNLESS OTHERWISE REQUIRED BY NFPA.
- (1) AS REQUIRED BY RACKING DESIGN.

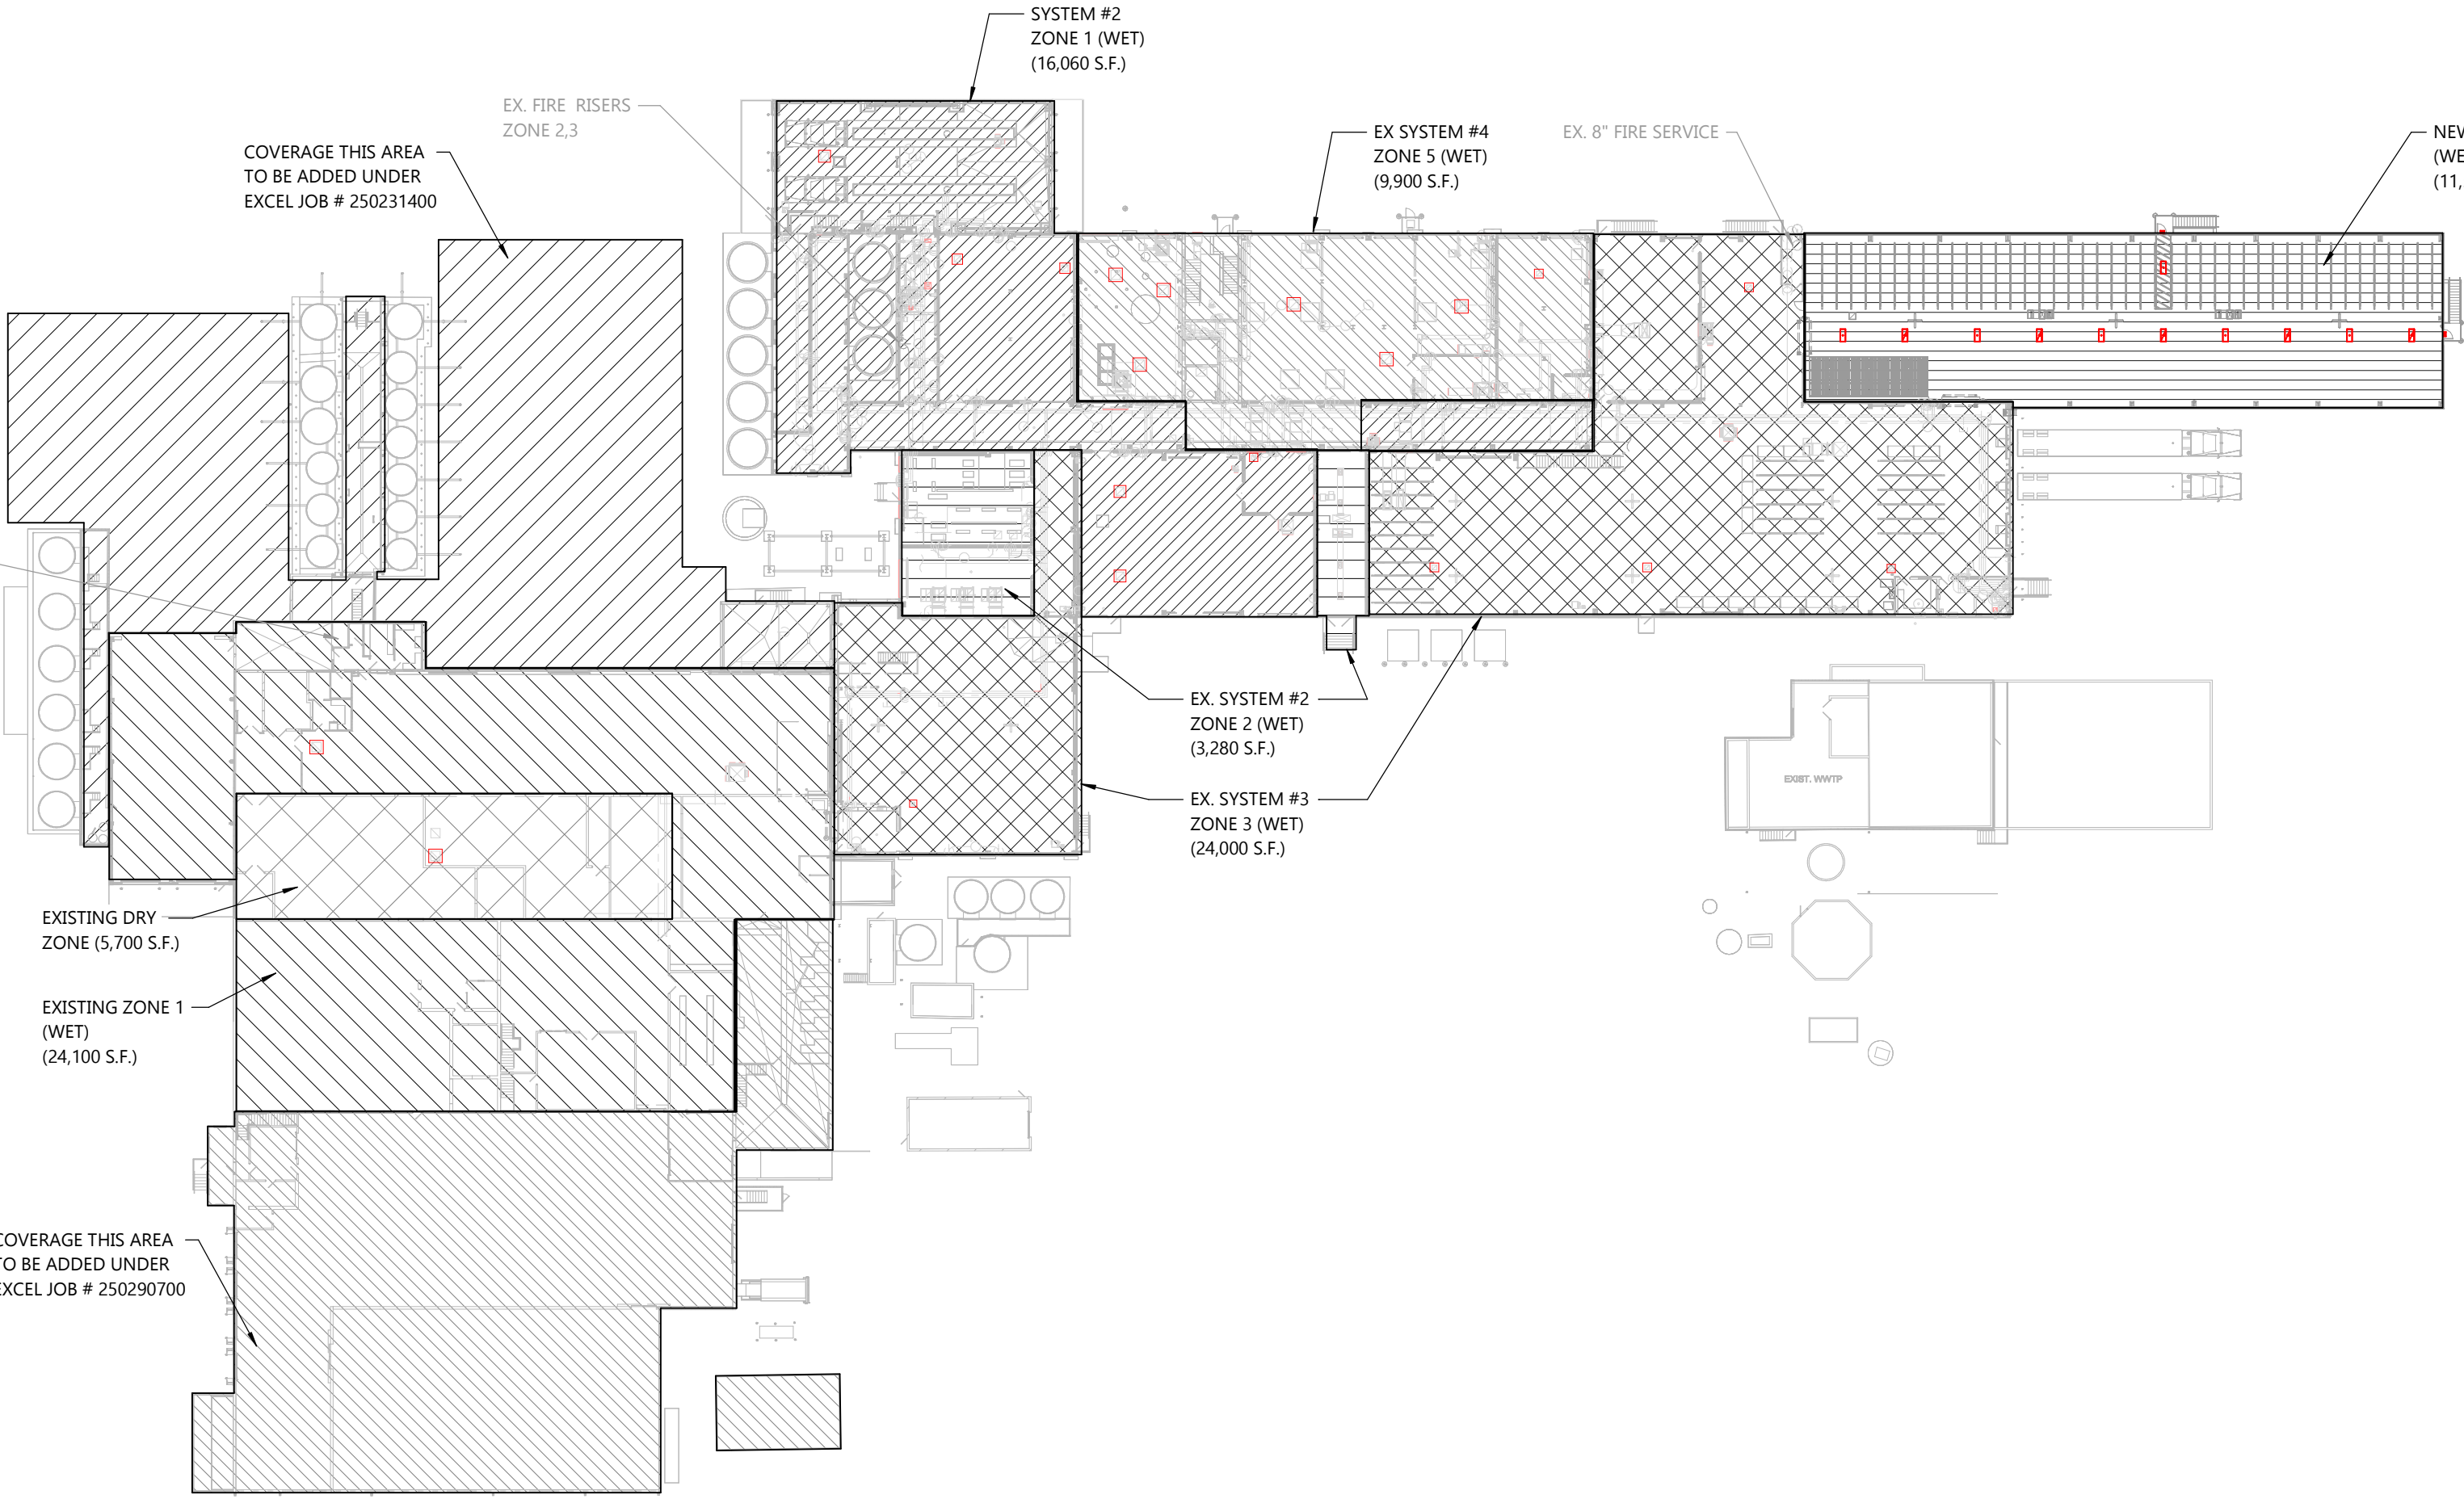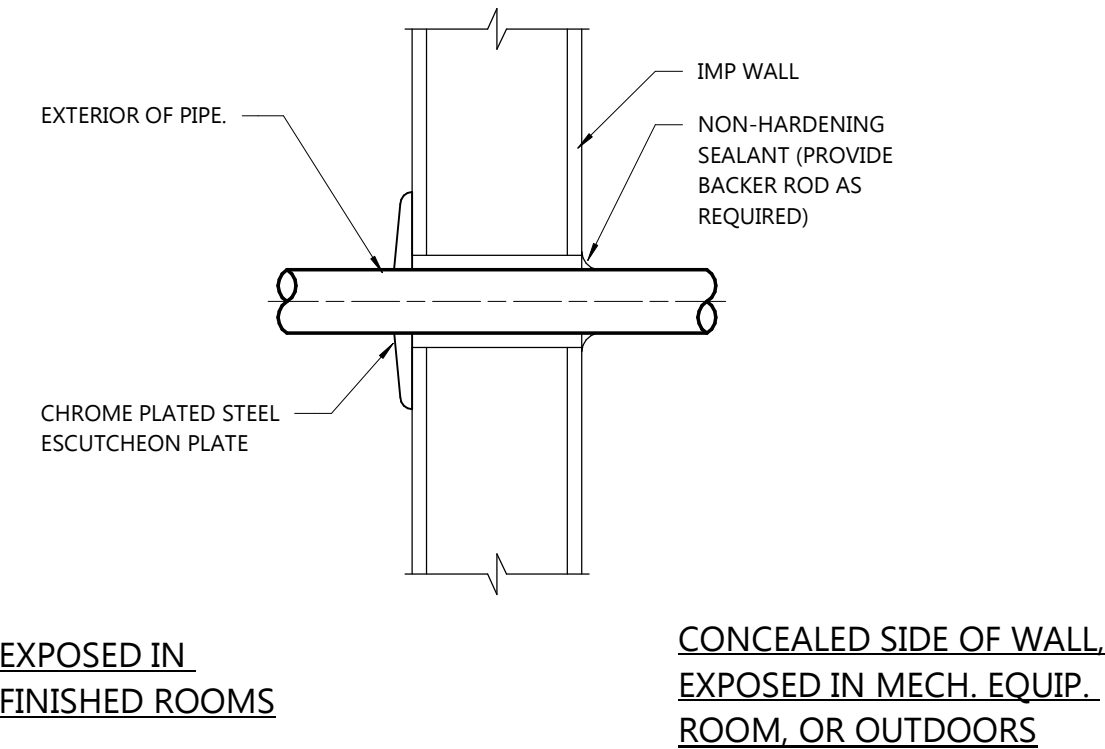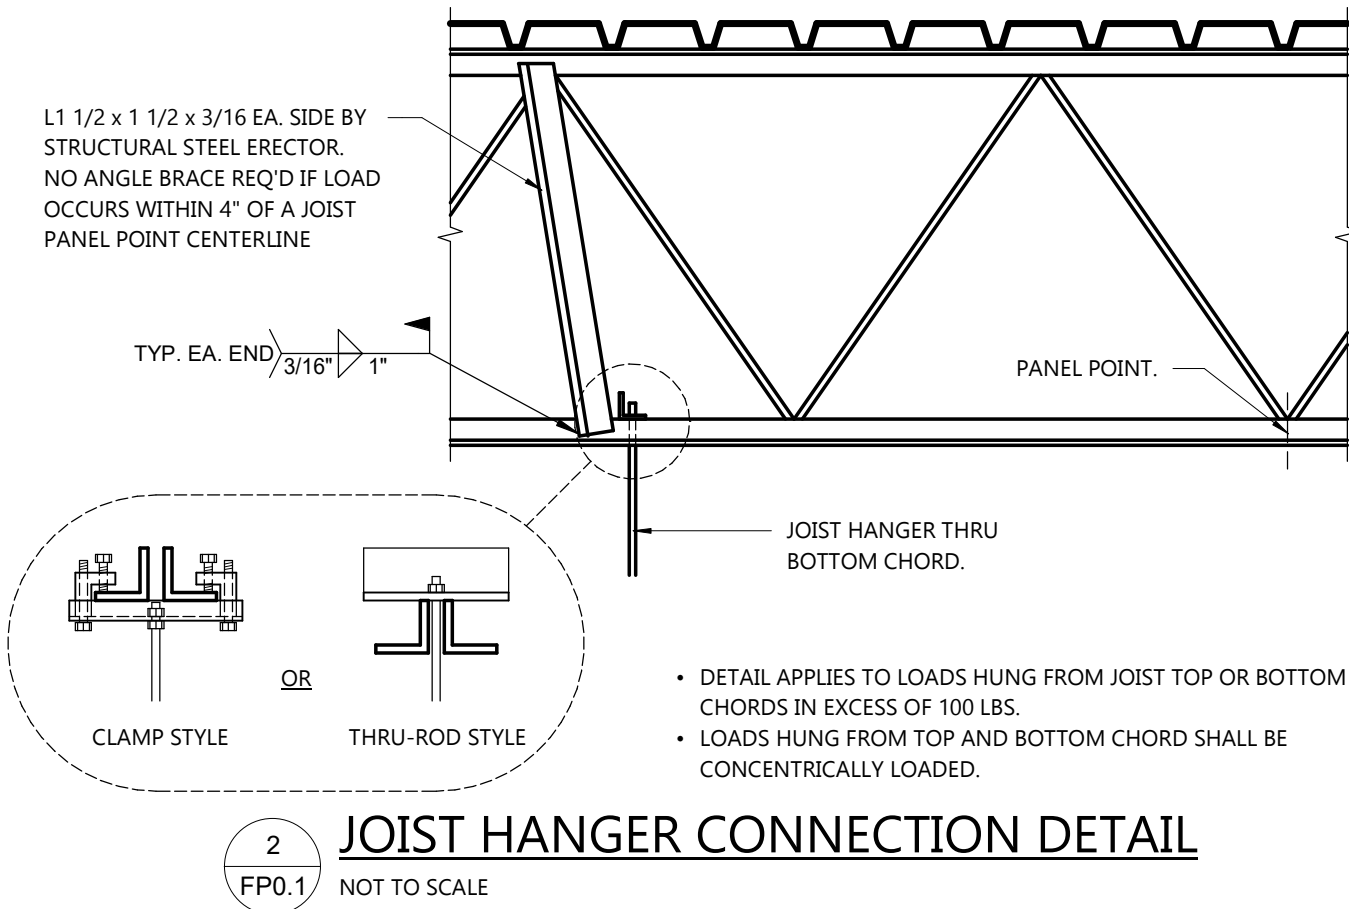

SHEET INDEX

SHEETS BELOW INTENDED TO BE PRINTED IN COLOR. REFER TO DIGITAL FORMAT DRAWINGS IF PRINTED GRAYS/SCALE TO ENSURE SCOPE CLARITY.

NUMBER	SHEET NAME / DESCRIPTION	SHEET STATUS
FIRE PROTECTION		
FP0.1	LEGEND AND SPECIFICATIONS	IFB
FP1.1	FIRST FLOOR PLAN - AREA OF WORK	IFB

FIRE PROTECTION LEGEND AND SPECIFICATIONS

Excel

Always a Better Plan

100 Camelot Drive
Fond du Lac, WI 54935
920-926-9800
excelengineer.com

PROJECT INFORMATION

STORAGE WAREHOUSE EXPANSION FOR:
WEST POINT DAIRY PRODUCTS
570 NORTH 500 WEST • HYRUM, UT 84319

PROFESSIONAL SEAL

FIRE PROTECTION DRAWINGS ARE SCOPE IN NATURE. FIRE PROTECTION CONTRACTOR SHALL SUBMIT AND STAMP FINAL DESIGN DRAWINGS AS REQUIRED BY AUTHORITIES HAVING JURISDICTION.

SHEET DATES	
ISSUED FOR BUDGET	
IFB	APR. 17, 2026

JOB NUMBER

250429500

SHEET NUMBER

FP0.1

NOT FOR CONSTRUCTION

- GENERAL NOTES:**
- SEE ARCHITECTURAL PLANS FOR ADDITIONAL INFORMATION.
 - FPC SHALL REVIEW CONSTRUCTION SEQUENCING AND TEMPORARY WALLS WITH GENERAL CONTRACTOR AND MAINTAIN SPRINKLER COVERAGE IN EXISTING AREAS THROUGHOUT CONSTRUCTION.
 - PIPING SHALL BE CONCEALED WHEREVER POSSIBLE. WHERE NOT POSSIBLE, LOCATIONS AND ROUTING SHALL BE APPROVED BY ARCHITECT/OWNER PRIOR TO INSTALLATION.
 - VERIFY EQUIPMENT/DUCTWORK LOCATIONS WITH ARCHITECTURAL AND HVAC PLANS. PROVIDE SPRINKLERS AT THESE LOCATIONS PER NFPA 13.
 - PENETRATE MASONRY WALLS PER STRUCTURAL DRAWINGS. PENETRATIONS NOT PERMITTED THROUGH MARKED GROUTED/REINFORCED MASONRY.
 - OPENINGS THROUGH BEAMS OR COLUMNS OR ANY OTHER STRUCTURAL MEMBER ARE NOT PERMITTED UNLESS APPROVED BY STRUCTURAL ENGINEER.
 - EXISTING FIRE PROTECTION PLANS MAY BE OBTAINED FROM EXCEL ENGINEERING. CONTACT FOODGROUP@EXCELENGINEER.COM TO RECEIVE A PDF COPY OF THE PLANS.
- INDICATES DESIGN CRITERIA DESIGNATION (SEE SCHEDULE)
INDICATES SPRINKLER DESIGNATION (SEE SCHEDULE)

PROJECT INFORMATION

STORAGE WAREHOUSE EXPANSION FOR:
WEST POINT DAIRY PRODUCTS
570 NORTH 500 WEST • HYRUM, UT 84319

PROFESSIONAL SEAL

FIRE PROTECTION
DRAWINGS ARE SCOPE IN
NATURE. FIRE PROTECTION
CONTRACTOR SHALL
SUBMIT AND STAMP FINAL
DESIGN DRAWINGS AS
REQUIRED BY AUTHORITIES
HAVING JURISDICTION.

SHEET DATES

ISSUED FOR BUDGET

IFB APR. 17, 2026


JOB NUMBER

250429500

SHEET NUMBER



FP1.1

NOT FOR CONSTRUCTION

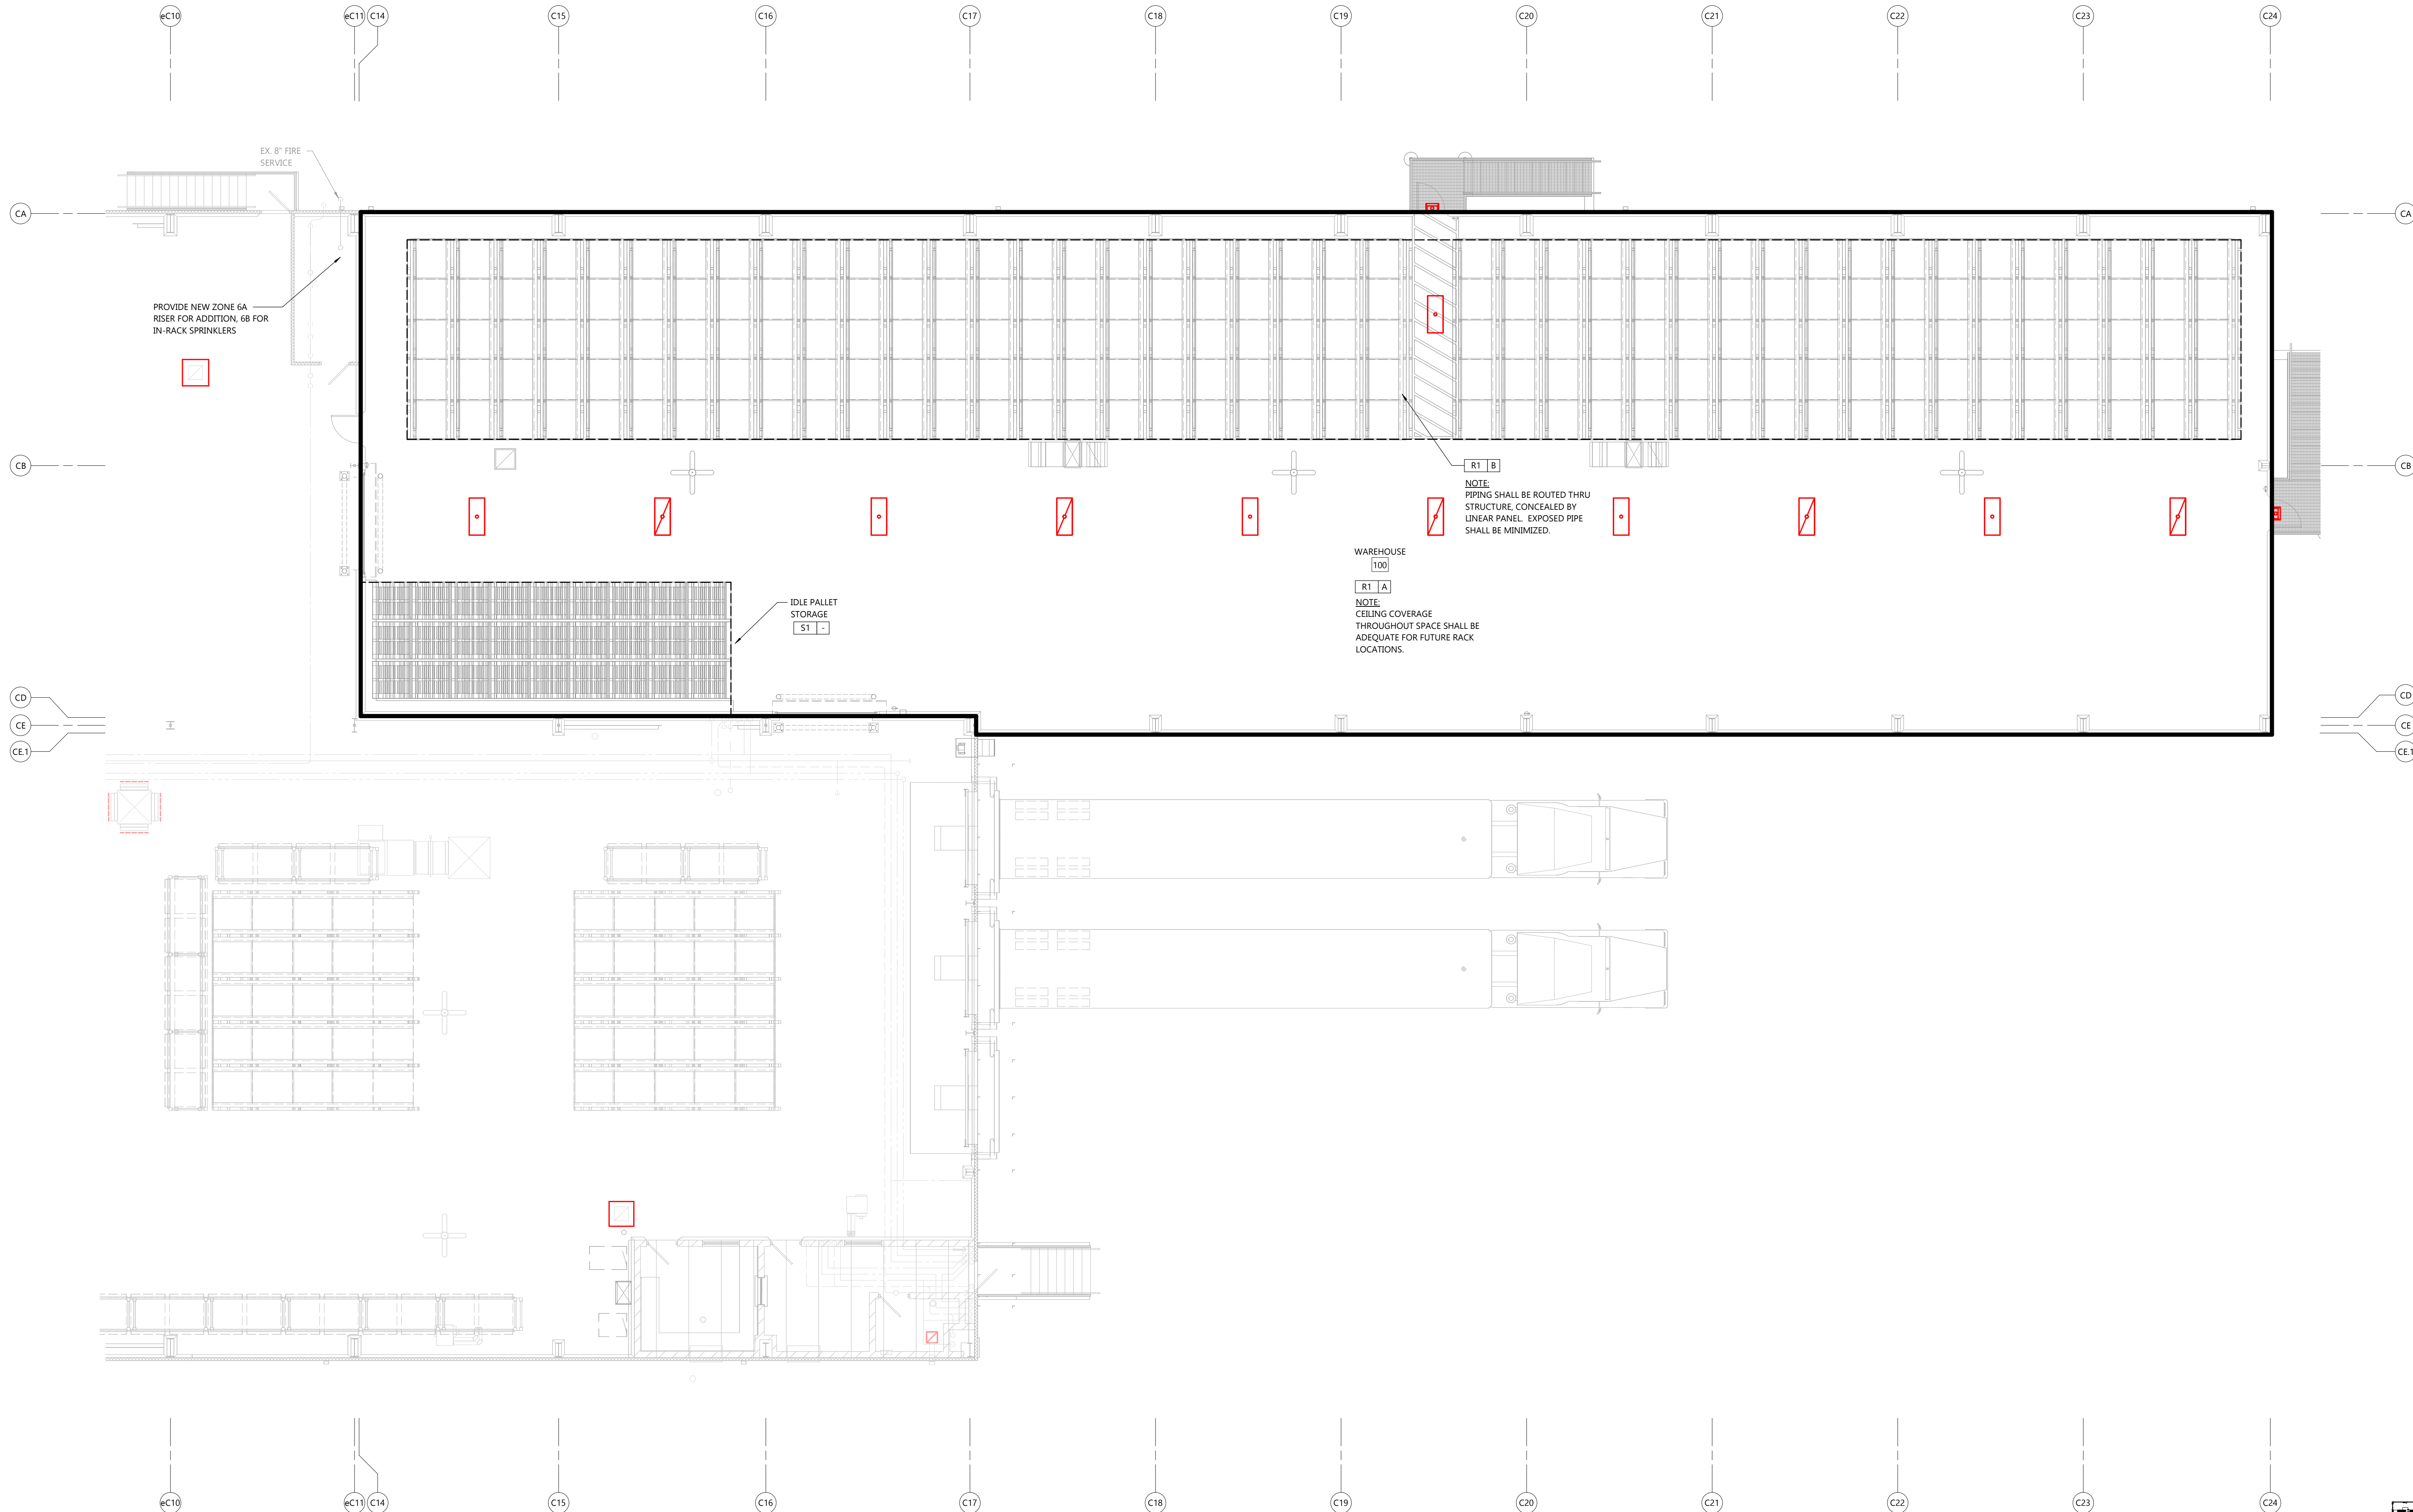

FIRST FLOOR PLAN - AREA OF WORK

 SCALE: 1/8" = 1'-0"

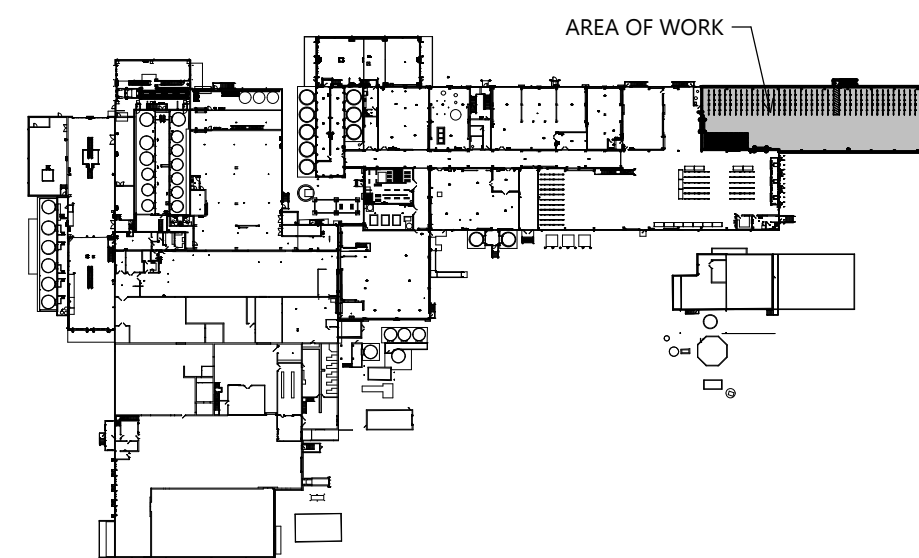

KEY PLAN

FIRE PROTECTION FIRST FLOOR PLAN - AREA OF WORK

HVAC SPECIFICATIONS

DIVISION 23 HVAC

23 05 00 BASIC HVAC REQUIREMENTS

- A. SEE DIVISION 00 PROCUREMENT AND CONTRACTING AND DIVISION 01 GENERAL REQUIREMENT FOR ADDITIONAL REQUIREMENTS.
- B. SUBSTITUTIONS.
1. SEE DIVISION 01 25 13 PRODUCT SUBSTITUTION PROCEDURES FOR ADDITIONAL REQUIREMENTS.
2. CONTRACTOR SHALL PROVIDE ALL SUPPORTING EVIDENCE AND ASSUME THE BURDEN OF PROOF THAT ANY SUBSTITUTE IS EQUIVALENT AS TO APPEARANCE, CONSTRUCTION, CAPACITY, AND PERFORMANCE. THE JUDGMENT OF EQUIVALENCY SHALL BE MADE BY THE ENGINEER AT THE TIME OF SHOP DRAWING REVIEW, NOT DURING BIDDING.
3. WHERE SUBSTITUTE EQUIPMENT REQUIRES REDESIGN OF ANY PART OF THE PROJECT, THE COST OF REDESIGN AND ADDITIONAL COSTS OF THE WORK SHALL BE PAID BY THE CONTRACTOR. REDESIGN SHALL BE SUBJECT TO THE APPROVAL OF ALL AUTHORITIES HAVING JURISDICTION OVER THE WORK INCLUDING THE ARCHITECT/ENGINEER.
4. CONTRACTOR SHALL ASSUME ALL COORDINATION RESPONSIBILITIES FOR SUBSTITUTE EQUIPMENT INCLUDING COORDINATION ACROSS TRADES AND COORDINATION OF PREVIOUSLY REVIEWED AND APPROVED SHOP DRAWING SUBMITTALS. SHOULD THESE SHOP DRAWINGS BE AFFECTED BY THE SUBSTITUTE EQUIPMENT.
- C. SHOP DRAWINGS, PRODUCT DATA, TEST RESULTS, PROJECT CLOSOUT DOCUMENTS.
1. SEE DIVISION 01 33 23 SHOP DRAWINGS, PRODUCT DATA AND SAMPLES FOR ADDITIONAL REQUIREMENTS
2. CONSTRUCTION ADMINISTRATION SUBMITTAL LIST:
- a. DUCTWORK
- b. DUCTWORK ACCESSORIES
- c. INSULATION
- d. PIPING
- e. VALVES AND STRAINERS
- f. ROOF EXHAUSTERS
- g. GAS PRESSURE REGULATORS
- h. ROOFTOP AIR CONDITIONING UNITS
- i. DESTRATIFICATION FANS
- j. TEMPERATURE CONTROLS
- k. TEST AND BALANCE REPORT
3. PROJECT CLOSOUT
- a. DOCUMENTATION: PROVIDE VENTILATION SYSTEM DOCUMENTATION PER ASHRAE 62.1-2007, SECTION 7.2.6
- b. AS-BUILT DRAWINGS SHALL BE MARKED ON A FINAL SET OF DRAWINGS WHICH INCLUDES ALL REVISIONS.
- c. PROVIDE HVAC EQUIPMENT OPERATING AND MAINTENANCE MANUALS TO THE OWNER PER RECC 408.1.1 AND CARB 2.2.2.

- D. FINISHING AND PAINTING
1. IF FINISH BECOMES RUSTED, CORRODED, SCRATCHED, OR FLAKED DURING STORAGE OR INSTALLATION, REFINISH THE EQUIPMENT TO THE SATISFACTION OF THE ARCHITECT/ENGINEER.
- E. DETAILS AND SCHEDULES ARE SHOWN TO AID THE CONTRACTOR AND ARE NOT MEANT TO BE INCLUSIVE OF ALL DEVICES. PROVIDE REQUIRED EQUIPMENT AND ACCESSORIES FOR A COMPLETE INSTALLATION.
- F. INSTALL ALL EQUIPMENT PER MANUFACTURER'S INSTALLATION INSTRUCTIONS AND REQUIREMENTS. PROVIDE ADDITIONAL WORK AND MATERIALS AS REQUIRED.
- G. COORDINATE INSTALLATION OF HVAC WORK WITH THE OTHER CONTRACTORS TO AVOID CONFLICTS WITH OTHER WORK.
- H. VERIFY CONNECTION REQUIREMENTS FOR EQUIPMENT FURNISHED BY OTHERS WITH FINAL SHOP DRAWINGS.
- I. STRUCTURAL PENETRATIONS
1. OPENINGS THRU BEAMS OR COLUMNS OR ANY OTHER STRUCTURAL MEMBER ARE NOT PERMITTED UNLESS APPROVED BY STRUCTURAL ENGINEER.
- J. PROJECT COMPLETION
1. INSTALL CLEAN SET OF FILTERS IN ALL UNITS AT TIME OF TESTING AND BALANCING.
2. CLEAN EQUIPMENT AND LEAVE IN PROPER WORKING CONDITION AT THE TIME OF FINAL CLEAN-UP.
3. PROVIDE OPERATING INSTRUCTIONS FOR A TOTAL OF TWO (2) HOURS. MAINTAIN A RECORD OF OPERATING INSTALLATION PERIODS AND OBTAIN OWNER SIGNOFF THAT INSTRUCTIONS HAVE BEEN COMPLETED.

23 05 13 MOTORS AND ELECTRICAL WORK

- A. MOTORS
1. MANUFACTURERS: GENERAL ELECTRIC, LOUIS ALLEN, MARATHON, AND BALDOR.
2. MOTORS LESS THAN 250 WATTS: MANUFACTURER'S STANDARD AND NEED NOT CONFORM TO THESE SPECIFICATIONS.
3. OPEN DRIP PROOF TYPE EXCEPT TOTALLY ENCLOSED FAN COOLED FOR THE FOLLOWING MOTORS:
- a. EXTERIOR LOCATIONS
- b. WHERE NOTED ON EQUIPMENT SCHEDULES
4. DESIGN FOR CONTINUOUS OPERATION IN 40 DEGREES C ENVIRONMENT AND FOR TEMPERATURE RISE IN ACCORDANCE WITH NEMA MG 1 LIMITS.
5. SINGLE PHASE POWER (PERMANENT-SPLIT CAPACITOR MOTORS) WITH STARTING TORQUE EXCEEDING ONE FOURTH OF FULL LOAD TORQUE AND STARTING CURRENTS EXCEEDING 50 TIMES FULL LOAD CURRENT, CLASS A, 50 DEGREES C TEMPERATURE RISE INSULATION, MINIMUM 1.0 SERVICE FACTOR, REBUILT/REBUILT SLEEVE OR BALL BEARINGS, AUTOMATIC RESTART OVERLOAD PROTECTOR.
6. THREE PHASE POWER (SQUARE, CAGE MOTORS) WITH STARTING TORQUE BETWEEN 1 AND 1-1/2 TIMES FULL LOAD TORQUE AND STARTING CURRENT 50 TIMES FULL LOAD CURRENT. NEMA DESIGN B MOTOR AND INSULATION SYSTEM, MINIMUM 1.15 SERVICE FACTOR FOR OPEN DRIP-PROOF MOTORS, 1.0 (MINIMUM) FOR OTHER TYPES. MINIMUM 65% NOMINAL POWER FACTOR UNDER RATED LOAD CONDITIONS. GREASE LUBRICATED ANTI-FRICTION BALL BEARINGS, RATED FOR MINIMUM AFMA 9, 1-10 LIFE OF 20,000 HOURS.
7. MINIMUM NOMINAL EFFICIENCY: COMPLY WITH 2021 RECC 408.8. MOTORS THAT ARE PART OF EQUIPMENT NOT REQUIRED TO COMPLY.
- B. STARTERS
1. SEE ELECTRICAL STARTER DISCONNECT SCHEDULE ON PLANS.

23 05 29 PIPE AND EQUIPMENT HANGERS AND SUPPORTS

- A. MANUFACTURERS: B-LINE, EMPIRE INDUSTRIES, GLOBAL PIPE HANGER PRODUCTS, GRINNELL, NATIONAL PIPE HANGER, UNISTRUT.
- B. HOT DIP GALVANIZED HANGERS, RODS, AND ACCESSORIES AFTER FABRICATION WHICH ARE EXPOSED TO WEATHER. PROVIDE RESISTANT HANGERS AND SUPPORTS FOR PIPING AND EQUIPMENT AND OBTAIN APPROVAL FROM AUTHORITIES HAVING JURISDICTION.
- C. PROVIDE ATTACHMENT OF ROOFTOP EQUIPMENT IN COMPLIANCE WITH APPLICABLE ASSET FOR WIND LOADING AND OBTAIN APPROVAL FROM AUTHORITIES HAVING JURISDICTION.
- D. ANGLES, CHANNELS, AND BEAMS: ASTM A36 AND A572 AS REQUIRED.
- E. HANGERS SHALL NOT BE ATTACHED TO JOIST BRIDGING.
- F. ATTACHMENT TO METAL DECK: HANGERS MAY BE ANCHORED TO METAL FLOOR/ROOF DECK IF ALL THE FOLLOWING CONDITIONS ARE MET:
- a. MAXIMUM HANGER LOAD OF 50 LBS.
- b. ANCHORED TO BOTTOM OF DECK FULL FLATS, NOT UPPER FLUTE.
- c. ANCHOR LENGTH SHALL NOT EXCEED DECK DEPTH.
- H. FASTENER SYSTEM
1. PULL-OUT TENSION AND SHEAR CAPACITIES APPROPRIATE FOR SUPPORTED LOADS AND BUILDING MATERIALS.
2. POWDER-ACTUATED FASTENERS: THREADED-STEEL STUD, FOR USE IN CONCRETE.
3. MECHANICAL EXPANSION ANCHORS: INSERT WEDGE TYPE, ZINC-COATED STEEL (STAINLESS IN PROCESS ROOMS), FOR USE IN CONCRETE. MINIMUM 1 1/2" EMBEDMENT.
4. INSTALL SUPPORTS SO PIPING LINE AND DEAD LOADS AND STRESSES FROM MOVEMENT WILL NOT BE TRANSMITTED TO CONNECTED EQUIPMENT.
- I. STRUT SYSTEM
1. COMPLY WITH THE LATEST REVISION OF NFMA STANDARDS PUBLICATION NUMBER NFMA-3, "METAL FRAMING STANDARDS PUBLICATION".
2. INSTALL STRUT IN ACCORDANCE WITH NFMA-102 "GUIDELINES FOR THE USE OF METAL FRAMING" IN ACCORDANCE WITH EQUIPMENT MANUFACTURER'S RECOMMENDATIONS, AND WITH RECOGNIZED INDUSTRY PRACTICES.
3. COLD FORMED LOW CARBON STEEL METAL FRAMING CHANNEL STRUT, B-LINE TYPE B CHANNEL.
4. MANUFACTURER'S STANDARD FINISH OR PLAIN FINISH UNLESS INSTALLED OUTDOORS, OR IN WET LOCATIONS.
5. FRAMING INSTALLED OUTDOORS OR WET LOCATIONS SHALL BE ONE OF THE FOLLOWING:
- a. EXTRUDED ALUMINUM ALLOY 6063 T5, ALL FITTINGS AND HARDWARE SHALL BE TYPE 304 STAINLESS STEEL.
- b. PRE-GALVANIZED STEEL, ALL FITTINGS AND HARDWARE SHALL BE ZINC PLATED TO ASTM B633.
- c. EPOXY PAINTED STEEL, WATER BORN EPOXY, APPLIED BY A CATHODIC ELECTRO DEPOSITION PROCESS. FITTINGS AND HARDWARE SHALL BE ZINC PLATED STEEL.
- d. TYPE 304 STAINLESS STEEL STRUT, FITTINGS AND HARDWARE.
6. 1-5/8 INCHES WIDE IN VARYING HEIGHTS AND WELDED COMBINATIONS AS REQUIRED TO MEET LOAD CAPACITIES.
- J. EQUIPMENT PIPE STANDS, CONTAINER SUPPORTS, STANDS CONSISTING OF STRUCTURAL STEEL MEMBERS SUPPORTED BY PIPE SUPPORTS. NOT HOT GALVANIZED AFTER FABRICATION WHERE EXPOSED TO WEATHER.

23 05 53 MECHANICAL IDENTIFICATION

- A. NAMEPLATES
1. MANUFACTURERS: MARKING SERVICES, BRADY B-1 AND SETON SETONTEK.
2. 3/4" HIG, 1 1/4" THICK PLASTIC WITH ENGRAVED WHITE LETTERS ON BLACK BACKGROUND COLOR, SCREW OR ADHESIVE MOUNTING.
3. PROVIDE AT CONTROL PANELS, STARTERS, AND MAJOR CONTROL COMPONENTS OUTSIDE PANELS.

23 07 00 INSULATION

- A. GENERAL
1. SEE INSULATION SCHEDULES ON PLANS FOR ADDITIONAL INFORMATION.
2. INSULATION, INSULATION SYSTEM AND JACKETS SHALL MEET UL-723/ASTM E84 REQUIREMENTS OF MAX. FIRE HAZARD CLASSIFICATION OF 25, AND MAX. FLAME SPREAD, FUE CONTRIBUTION, AND SMOKE DEVELOPED OF 50 WHEN INSTALLED IN A RETURN AIR PLENUM.
3. INSTALL MATERIALS IN ACCORDANCE WITH MANUFACTURER'S INSTRUCTIONS AND MICA PUBLICATION "NATIONAL COMMERCIAL AND INDUSTRIAL STANDARDS" LATEST EDITION.
4. CONTINUE INSULATION WITHOUT INTERRUPTIONS THROUGH WALLS AND FLOOR PENETRATIONS AND HANGERS.
- B. FIBERGLASS (F-G) INSULATION
1. RIGID F-G
- a. GLASS FIBER INSULATION WITH FACTORY APPLIED FRK VAPOR RETARDER.
- b. R-3.7 / NOMINAL RICH AT 75 DEG F
- c. MAX 450 DEG F, JACKET MAX 150 DEG F, 0.02 PERMA.
- d. INDOOR DUCTWORK:
- 1). O.C. TYPE T03, CERTAINTED CERTAPRO CB 300, JOHNS MANVILLE B14
- 2). 3 LB/CU FT, COMPRESSIVE STRENGTH AT 10% DEFORMATION 25 LB/5.F.
- C. DUCT INSULATION REQUIREMENTS
1. INSULATE FITTINGS, JOINTS, FLANGES, FLEXIBLE CONNECTIONS, DAMPERS, AND IN-LINE ACCESSORIES WITHOUT INTERNAL LINING/INSULATION AND THICKNESS AS SPECIFIED FOR THE DUCT SYSTEM. STOP AND POINT INSULATION AROUND ACCESS DOORS AND DAMPER OPERATORS TO ALLOW OPERATION WITHOUT DISTURBING WRAPPING.

23 11 23 NATURAL GAS PIPING AND ACCESSORIES

- A. PIPING
1. INSTALL, INSPECT, TEST, AND PURGE GAS PIPING IN CONFORMANCE WITH NFPA 54, UTILITY COMPANY AND ALL OTHER GOVERNING CODES.
2. MAKE BRANCH CONNECTIONS TO THE MAIN FROM THE TOP OR SIDE.
3. PAINTING PER SPECIFICATION 09 91 00 PAINTING.
- B. GAS VALVES
1. UL LISTED FOR USE AS NATURAL GAS SHUTOFF.
2. BALL VALVES (MANUFACTURERS: NIBCO 585/580-700L, WATTS B6000UL), BRONZE BODY, THREADED ENDS, CHROME PLATED BRONZE BALL, FULL-PORT CONVENTIONAL PORT, TEFLON SEAT, BLOW-OUT PROOF STEM, TWO-PIECE CONSTRUCTION, 150 PSIG WORKING PRESSURE.
3. PLUG VALVES (MANUFACTURERS: DEURUP REC, HOMESTEAD SERIES 612), CAST IRON BODY, FLANGED ENDS, BRONZE BEARINGS, ELECTROLESS NICKEL PLATED CAST IRON PLUG WITH HYDRA-RESISTANT PLUG SEAL, BUNA-N STEM SEAL, PACKING, LEVER ACTUATOR, 15 PSIG WOG.
- C. GAS PRESSURE REGULATORS
1. CAST IRON BODY, ALUMINUM SPRING CASE, ALUMINUM ORFICE, BUNA-N DIAPHRAGM, INTERNAL RELIEF VALVE SET TO RELIEVE AT 7-10" W.C. ABOVE NORMAL, OUTLET PRESSURE SETTING OF 7" W.C., TOP-COAT ENAMEL.
2. SENSUS MODELS 496, 6182, 181, 80, 243
3. FOR REGULATORS INSTALLED OUTDOORS, POSITION THE REGULATOR SO THE RELIEF VALVE VENT IS FACING DOWN OR INSTALLED ELBOW FACING DOWN A MINIMUM 10 FEET FROM AN OUTSIDE AIR INTAKE AND 5 FEET FROM A GAS FUEL DISCHARGE.
4. IF GAS PRESSURE IS GREATER THAN 2PSI, PROVIDE OVERPRESSURE PROTECTION DEVICES PER 604.416.

23 31 13 DUCTWORK

- A. PERFORM WORK IN ACCORDANCE WITH THE LATEST EDITIONS OF SMACNA - HVAC DUCT CONSTRUCTION STANDARDS, NFPA 90A.
- B. GENERAL
1. CERTAIN VERTICAL AND HORIZONTAL OFFSETS ARE INDICATED IN DUCTS TO INDICATE THE GENERAL POSITION RELATIONSHIP OF THE DUCTWORK SYSTEMS; PROVIDE ADDITIONAL OFFSETS AS REQUIRED TO COORDINATE WITH THE INSTALLATION OF OTHER SYSTEMS, CEMENTS, OR TAPED POLYETHYLENE OR OPEN DUCTWORK TO PREVENT CONSTRUCTION DUCT FROM ENTERING DUCTWORK SYSTEM.
2. INCREASE DUCT SIZES GRADUALLY, NOT EXCEEDING 15 DEGREES WHENEVER POSSIBLE. 30 DEGREE MAXIMUM.
- C. DUCTWORK SEALANTS
1. MANUFACTURERS: HARDCAST GPR-40K SOLVENT BASED DUCT SEALANT OR EQUIVALENT.
- a. SYNTHETIC RUBBER RESIN BASE.
- b. -20 TO 200 DEG F.
- c. PRESSURE CLASSES UP TO 10" W.C., MEETING SEAL CLASS A.
- d. MAXIMUM FLAME SPREAD OF 25, SMOKE DEVELOPED OF 50.
- e. APPLY MINIMUM 20 MILS THICK WET FILM AT TEMPERATURES BETWEEN 35-100 DEG F.
- f. HARDCAST ALUMA GPR 701 OR EQUIVALENT PRESSURE SENSITIVE DUCT JOINT ROLLED SEALANT MAY BE USED IN PLACE OF MASTIC. SEALANT SHALL COMPLY WITH THE FOLLOWING:
- a. MILL FINISH ALUMINUM SUBSTRATE WITH GRAY ADHESIVE.
- b. MINIMUM 30 MIL THICK.
- c. MIN. 17 LB PER LINEAR INCH PULL STRENGTH.
- d. MAX FLAME SPREAD OF 25, MAX SMOKE DEVELOPED OF 50 WHEN TESTED IN ACCORDANCE WITH ASTM G-53.
- e. VOC: 0 G/L, COMPLIANT WITH LEED SCAQMD RULE 1168.
- f. PRESSURE CLASSES UP TO 10" W.C.
- D. DUCT CLEANING
1. PROTECT DUCTWORK AGAINST ENTRY OF FOREIGN MATERIAL DURING CONSTRUCTION. PROVIDE TEMPORARY END CAPS AND SEALS. PROVIDE TEMPORARY FILTERS OVER RETURN OR EXHAUST AIR INLETS IF DUCTWORK IS USED DURING CONSTRUCTION.
2. REMOVE ALL DIRT AND FOREIGN MATERIAL AND CLEAN DIFFUSERS, REGISTERS, AND GRILLES BEFORE OPERATING FANS.

23 30 00 DUCTWORK ACCESSORIES

- A. GENERAL - ALL DUCT ACCESSORIES SHALL BE CONSTRUCTED OF SAME MATERIAL AS DUCTWORK BEING INSTALLED IN.
- B. TURNING VANES
1. MANUFACTURERS: AERODYNE/CO. H.E. HART & COOLEY, UNITED MCGILL, SEMCO.
2. RECTANGULAR DUCTWORK: TURNING VANES IN ACCORDANCE WITH SMACNA FIG. 2-3 AND 2-4. VANE RADIUS 4 INCHES WITH A 3-1/4 INCH SPACING.
3. ROUND DUCTWORK: TWO-PIECE MITERED, MINIMUM 20 GAUGE.
- C. FLEXIBLE CONNECTIONS
1. MANUFACTURERS: VENTAIRBAC, DURO-DINE.
2. MATERIAL BOLTED SECURELY TO THE EQUIPMENT AND CONNECTING DUCTWORK WITH #16 GAUGE GALVANIZED IRON BAND (LOOP) CLAMPS BOLTED TIGHT TO MAKE AN AIRTIGHT CONNECTION. MINIMUM 6" WIDE.
3. PROVIDE AT INLET AND OUTLET OF ALL HAND LINGING UNITS AND FANS IN ACCORDANCE WITH SMACNA FIGURE 2-17.
4. CONVENTIONAL INTERIOR: VENTGLAS, -20 TO 200 DEG F, 30 OZ. PER SQUARE YARD GLASS FABRIC DOUBLY COATED WITH NEOPRENE, UL 214 APPROVED.

23 90 00 TEMPERATURE CONTROLS

- A. THE CONTROL SYSTEM SHALL BE AN EXTENSION OF THE EXISTING TRANE CONTROL SYSTEM.
- B. INSTALLER QUALIFICATIONS: AUTOMATIC CONTROL SYSTEM MANUFACTURER'S AUTHORIZED REPRESENTATIVE WHO IS TRAINED AND APPROVED FOR INSTALLATION OF SYSTEM COMPONENTS REQUIRED FOR THIS PROJECT.
- C. THE CONTROL SYSTEM SHALL CONSIST OF A HIGH-SPEED, REPLY-TO-PEER NETWORK OF DDC CONTROLLERS RESIDING AND COMMUNICATING ON A BACNET INTRANEWORK.
- D. ALL PRODUCTS USED IN THIS INSTALLATION SHALL BE NEW, CURRENTLY UNDER MANUFACTURE, AND SHALL BE APPLIED IN STANDARD OFF THE SHELF PRODUCTS. THIS INSTALLATION SHALL NOT BE USED AS A TEST SITE FOR ANY NEW PRODUCTS UNLESS EXPRESSLY APPROVED BY THE ENGINEER IN WRITING. SPARE PARTS SHALL BE AVAILABLE FOR AT LEAST 5 YEARS AFTER COMPLETION OF THIS CONTRACT.
- E. ELECTRICAL COMPONENTS, DEVICES, AND ACCESSORIES: LISTED AND LABELED AS DEFINED IN NFPA 70, ARTICLE 100, BY A TESTING AGENCY ACCEPTABLE TO AUTHORITIES HAVING JURISDICTION AND MARKED FOR INTENDED USE.
- F. LABOR AND MATERIALS FOR THE CONTROL SYSTEM SPECIFIC SCHEDULING AND MARKED FOR INTENDED USE.
- G. CONTROLLER HARDWARE USED OUTDOORS AND/OR IN WET AMBIENT CONDITIONS SHALL BE MOUNTED WITHIN NEMA 3R ENCLOSURES, AND RATED FOR OPERATION AT -40 DEG F TO 130 DEG F AND 10 TO 90% RH. HARDWARE USED IN CONDITIONED SPACE SHALL BE MOUNTED IN AN ENCLOSURE AND BE RATED FOR OPERATION AT 32 DEG F TO 120 DEG F.
- H. CONTROLLERS (APPLIES TO ALL CONTROLLERS)
1. PROVIDE A SEPARATE CONTROLLER FOR EACH HVAC SYSTEM. A DDC CONTROLLER MAY CONTROL MORE THAN ONE SYSTEM PROVIDED THAT ALL POINTS/OBJECTS ASSOCIATED WITH THE SYSTEM ARE ASSIGNED TO THE SAME DDC CONTROLLER. POINTS/OBJECTS USED FOR CONTROL LOOP RESET SUCH AS OUTSIDE AIR OR SPACE TEMPERATURE ARE EXEMPT FROM THIS REQUIREMENT.
2. SELECT BUILDING CONTROLLERS AND CUSTOM APPLICATION CONTROLLERS TO PROVIDE A MINIMUM OF 15% SPARE I/O POINT/OBJECT CAPACITY FOR EACH POINT/OBJECT TYPE FOUND AT EACH LOCATION. IF INPUT/OBJECTS ARE NOT UNIVERSAL, 15% OF EACH TYPE IS REQUIRED. IF OUTPUTS ARE NOT UNIVERSAL, 15% OF EACH TYPE IS REQUIRED. A MINIMUM OF ONE SPARE IS REQUIRED FOR EACH TYPE OF POINT/OBJECT USED.
- K. BUILDING CONTROLLERS
1. PROVIDE AN ADEQUATE NUMBER OF INDEPENDENT, STANDALONE, MICROPROCESSOR-BASED BUILDING CONTROLLERS TO ACHIEVE THE PERFORMANCE SPECIFIED. PANELS SHALL HAVE SUFFICIENT MEMORY TO SUPPORT ITS OPERATING SYSTEM, DATABASE, AND PROGRAMMING REQUIREMENTS. THE BUILDING CONTROLLER SHALL SHARE REAL AND VIRTUAL OBJECT INFORMATION AND ALLOW CENTRAL MONITORING AND ALARMS.
2. CONTROLLERS THAT PERFORM SCHEDULING SHALL HAVE A REAL-TIME CLOCK.
3. EACH BUILDING CONTROLLER SHALL FULLY SUPPORT DIRECT ETHERNET OR A COMMUNICATIONS CARD, AND PROVIDE A SERIES COMMUNICATION PORT TO A HARDWARE WORKSTATION AND/OR MODEM.
4. PROVIDE DIAGNOSTIC LEDS FOR POWER, COMMUNICATION, AND PROCESSOR. ALL WIRING CONNECTIONS SHALL BE MADE TO FIELD-REMOVABLE, MODULAR TERMINAL STRIPS - OR TO A TERMINATION CARD CONNECTED BY A RIBBON CABLE.
5. OPERATE AT 90% TO 110% OF NOMINAL VOLTAGE RATING AND PERFORM AN ORDERLY SHUTDOWN BELOW 80% NOMINAL VOLTAGE. MAINTAIN ALL DATABASE INFORMATION INCLUDING BIOS AND PROGRAMMING INFORMATION IN THE EVENT OF A POWER LOSS FOR AT LEAST 72 HOURS. OPERATION SHALL BE PROTECTED AGAINST ELECTRICAL NOISE OF 5 TO 120 HZ AND FROM KEVED RADIOS UP TO 5 W AT 3 FT.
- L. APPLICATION SPECIFIC CONTROLLERS (ASC)
1. MICROPROCESSOR-BASED REPLY-TO-PEER FULLY USER PROGRAMMABLE DDC CONTROLLERS.
2. EACH ASC SHALL BE CAPABLE OF STANDALONE OPERATION AND SHALL CONTINUE TO PROVIDE CONTROL FUNCTIONS WITHOUT BEING CONNECTED TO THE NETWORK. FIRMWARE AND CONTROLLER DATABASE SHALL BE LOADABLE OVER THE NETWORK.
3. THE CONTROLLER SHALL RESIDE ON A BACNET NETWORK USING THE MS/TP DATA LINK/ PHYSICAL LAYER PROTOCOL. EACH CONTROLLER SHALL HAVE A BACNET DATA LINK/ PHYSICAL LAYER COMPATIBLE CONNECTION FOR A LAPTOP COMPUTER OR A PORTABLE OPERATOR'S TOOL.
4. PROVIDE DIAGNOSTIC LEDS FOR POWER, COMMUNICATION, AND PROCESSOR. ALL WIRING CONNECTIONS SHALL BE TO FIELD-REMOVABLE, MODULAR TERMINAL STRIPS.
5. USE NON-VOLATILE MEMORY AND MAINTAIN ALL BIOS AND PROGRAMMING INFORMATION IN THE EVENT OF A POWER LOSS.
6. OPERATE AT 90% TO 110% OF NOMINAL VOLTAGE RATING AND SHALL PERFORM AN ORDERLY SHUTDOWN BELOW 80%. OPERATION SHALL BE PROTECTED AGAINST ELECTRICAL NOISE OF 5-120 HZ AND FROM KEVED RADIOS UP TO 5 W AT 3 FT.
7. POWER SUPPLY FOR THE ASC SHALL BE RATED AT MINIMUM OF 125% OF ASC POWER CONSUMPTION, AND SHALL BE FUSED OR CURRENT LIMITING TYPE.
8. THE SYSTEM SIZE SHALL BE EXPANDABLE TO AT LEAST 100% THE NUMBER OF INPUT/OUTPUT OBJECTS REQUIRED FOR THIS PROJECT. ADDITIONAL CONTROLLERS SHALL BE ALL THAT IS NECESSARY TO ACHIEVE THIS CAPACITY REQUIREMENT. THE OPERATOR INTERFACES INSTALLED FOR THIS PROJECT SHALL NOT REQUIRE ANY HARDWARE ADDITIONS OR SOFTWARE REVISIONS IN THE EVENT OF A SYSTEM EXPANSION.
- M. UNITARY CONTROLLERS: UNITIZED, CAPABLE OF STAND-ALONE OPERATION WITH SUFFICIENT MEMORY TO SUPPORT ITS OPERATING SYSTEM, DATABASE, AND PROGRAMMING REQUIREMENTS, AND WITH SUFFICIENT I/O CAPACITY FOR THE APPLICATION.
1. DIAGNOSTIC LEDS FOR POWER, COMMUNICATION, AND PROCESSOR. WIRING TERMINATION TO TERMINAL STRIP OR CARD CONNECTED WITH RIBBON CABLE. MEMORY WITH BIOS, AND 72 HOUR BATTERY BACKUP.
2. OPERATING SYSTEM: MANAGE I/O CAPACITY TO ALLOW DISTRIBUTED CONTROLLERS TO SHARE REAL AND VIRTUAL OBJECT INFORMATION AND ALLOW CENTRAL MONITORING AND ALARMS.
- a. ASHRAE 133 COMPLIANCE: COMMUNICATE USING READ, EXECUTE AND INITIATE AND WRITE (EXECUTE AND INITIATE) PROPERTY SERVICES DEFINED IN ASHRAE 133. RESIDE ON NETWORK USING MS/TP DATA/PHYSICAL LAYER PROTOCOL AND HAVE SERVICE COMMUNICATION PORT FOR CONNECTION TO DIAGNOSTIC TERMINAL UNIT.
- N. I/O INTERFACE: HARDWIRED INPUTS/OUTPUTS TO THE BTO SYSTEM THROUGH CONTROLLERS.
1. BINARY INPUTS: MONITORING ON OR OFF SIGNALS WITHOUT EXTERNAL POWER.
2. PULSE ACCUMULATION INPUTS: ACCEPT UP TO 10 PULSES PER SECOND.
3. ANALOG INPUTS: MONITORING OF 0 TO 10 V.D.C. TO 4 TO 20 MA OR RESISTANCE SIGNALS.
4. BINARY OUTPUTS: ON-OFF OR PULSED LOW-VOLTAGE SIGNAL, SELECTABLE FOR NORMALLY OPEN OR CLOSED.
5. ANALOG OUTPUTS: MODULATING SIGNAL, EITHER 0 TO 10 V.D.C. OR 4 TO 20 MA.
6. TWO-STATE OUTPUTS: TWO COORDINATED BINARY OUTPUTS FOR CONTROL OF THREE-POINT FLOATING-TYPE ELECTRONIC ACTUATORS. USE OF THREE-POINT FLOATING-TYPE OUTPUTS LIMITED TO ZONE AND TERMINAL UNIT CONTROL APPLICATIONS (NAV TERMINAL UNITS, DUCT MOUNTED HEATING COILS, ZONE DAMPERS, RADIATION, ETC.).
7. UNIVERSAL I/O'S: SOFTWARE SELECTABLE BINARY OR ANALOG INPUTS AND OUTPUTS.
- O. POWER SUPPLIES: UL LISTED TRANSFORMERS WITH CLASS 2 CURRENT-LIMITING TYPE OR OVERCURRENT PROTECTION; LIMIT CONNECTED LOADS TO 80 PERCENT OF RATED CAPACITY. DC POWER SUPPLY SHALL MATCH OUTPUT CURRENT AND VOLTAGE REQUIREMENTS AND BE FULL-WAVE RECTIFIER TYPE.
- P. POWER LINE FILTERING: INTERNAL OR EXTERNAL TRANSIENT VOLTAGE AND SURGE SUPPRESSION.
- Q. COMMUNICATION
1. PROVIDE ALL COMMUNICATION MEDIA, CONNECTORS, REPEATERS, BRIDGES, HUBS, AND ROUTERS NECESSARY FOR THE INTRANETWORK.
2. CONNECTION OF AN OPERATOR INTERFACE DEVICE TO ANY OTHER CONTROLLER AS THE INTRANETWORK WILL ALLOW THE OPERATOR TO INTERFACE WITH ALL OTHER CONTROLLERS AS IF THAT INTERFACE WERE DIRECTLY CONNECTED TO THE OTHER CONTROLLERS.
- R. ELECTRONIC SENSORS/TRANSMITTERS
1. INSTALLATION
- a. INSTALL ALL SENSORS IN ACCORDANCE WITH THE MANUFACTURER'S RECOMMENDATIONS.
- b. ROOM TEMPERATURE SENSORS SHALL BE INSTALLED ON CONCEALED JUNCTION BOXES PROPERLY SUPPORTED BY THE WALL FRAMING WITH CONDUIT TUB TO ABOVE THE CEILING.
- c. INSTALL DEVICES WHICH HAVE ADJUSTMENT 48 INCHES ABOVE THE FLOOR OR COMPLY WITH CURRENT DATA REQUIREMENTS. INSTALL NON-ADJUSTABLE CONTROL SENSORS AT 60 INCHES ABOVE THE FLOOR.
- d. COORDINATE LOCATION OF THERMOSTATS AND OTHER EXPOSED CONTROL SENSORS WITH PLANS AND ROOM DETAILS BEFORE INSTALLATION.
- e. ALL WIRES ATTACHED TO SENSORS SHALL BE AIR SEALED IN THEIR RACEWAYS OR IN THE WALL TO STOP AIR TRANSMISSION FROM OTHER AREAS AFFECTING SENSOR READINGS.
2. ROOM TEMPERATURE SENSOR:
- a. MANUFACTURER'S STANDARD COVER.
- b. SEE SEQUENCE OF OPERATION FOR ADDITIONAL TEMPERATURE SENSOR FEATURES.
3. HUMIDITY SENSORS: BULK POLYMER SENSOR ELEMENT.
- a. ACCURACY: 3 PERCENT FULL RANGE WITH LINEAR OUTPUT.
- b. ROOM SENSOR RANGE: 20 TO 100 PERCENT RELATIVE HUMIDITY.
- c. ROOM SENSOR: MANUFACTURER'S STANDARD LOCKING COVER.
- d. DRIFT SHALL NOT EXCEED 3% OF FULL SCALE PER YEAR.
- e. SEE SEQUENCE OF OPERATION FOR ADDITIONAL HUMIDITY SENSOR FEATURES.
4. PRESSURE TRANSMITTER
- a. HONEYWELL P7640 SERIES, VERES PX SERIES, PANEL, DUCT OR UNIVERSAL, MODEL AS REQUIRED.
- b. 32 TO 140 DEG F OPERATING TEMPERATURE RANGE.
- c. 4-20 MA, 0-5 V.D.C. OR 0-10 V.D.C. SELECTABLE.
- d. PLUS OR MINUS 1% FULL SCALE ACCURACY.
- e. RANGES
- 1). RE-1 OFF AND CLOSE ASSOCIATED MOTOR OPERATED DAMPERS
- 2). RE-1 OFF AND CLOSE ASSOCIATED MOTOR OPERATED DAMPERS
- 3). RE-1 OFF AND CLOSE ASSOCIATED MOTOR OPERATED DAMPERS

23 90 10 SEQUENCE OF OPERATION

- A. ALL LISTED SEQUENTS ADJUSTABLE.
- B. CONTRACTOR IS RESPONSIBLE FOR:
1. ALL POWER AND CONTROL WIRING TO ACTUATORS AND PANELS NOT SPECIFICALLY CALLED OUT ON THE PLANS.
2. ALL DATA CABLEING AND WIRING FROM PANELS TO PANEL, PANELS TO OWNERS DATA CLOSET/IT SYSTEM, AND OTHER COMMUNICATION WIRING REQUIRED FOR A COMPLETE AND OPERATIONAL SYSTEM.
3. ALL INTERLOCK POWER AND CONTROL WIRING BETWEEN COMPONENTS OF SYSTEMS FURNISHED OR INSTALLED BY THIS CONTRACTOR TO MAKE FULLY FUNCTIONAL.
- C. PROVIDE ALL SENSORS NECESSARY TO ACHIEVE SPECIFIED SEQUENCES AND ADDITIONAL SENSORS WHERE SPECIFIED. PROVIDE READOUT OF ALL SENSORS AT OPERATOR WORKSTATION.
- D. WHERE TEMPERATURE SENSORS HAVE ADJUSTABLE SETPOINT TEMPERATURE PROVIDE WITH LOWEST COOLING AND HIGHEST HEATING ROOM SETPOINTS TO LIMIT ROOM SETPOINT ADJUSTMENT AT SENSOR.
- E. PROVIDE OUTSIDE AIR TEMPERATURE SENSOR FOR BUILDING TO BE USED FOR ALL SEQUENCES AND PROVIDE GLOBAL READOUT AT EACH SCREEN.
- F. PROVIDE WIRING TO ALL HVAC ACTUATORS AT MOTOR OPERATED DAMPERS PROVIDED BY ROOF EXHAUSTER MANUFACTURERS. PROVIDE SIGNAL TO OPER DAMPER WHEN ROOF EXHAUSTER IS TURNED ON.
- G. MONITOR VFD BYPASS SWITCH. INDEX UNIT TO OCCUPIED CYCLE PER AN ACTIVATION.
- H. AT-12 AND RE-1
1. PROVIDE TEMPERATURE/HUMIDITY SENSOR FOR:
- a. WAREHOUSE (100) WITH SETPOINT ADJUSTMENT, TEMPERATURE/HUMIDITY READOUT
2. PROVIDE DIFFERENTIAL PRESSURE SENSOR FOR:
- a. ROOM COMPARED TO OUTDOOR
3. ROOM HEATING AND COOLING SETPOINTS CAN BE SET NO CLOSER THAN 3 DEG F.
4. PROVIDE OCCUPIED / UNOCCUPIED SCHEDULE FOR UNIT.
5. PROVIDE SEPARATE UNOCCUPIED / OCCUPIED SETPOINTS FOR HEATING AND COOLING.
6. PROVIDE HEATING AND COOLING SETPOINTS, ROOM TEMPERATURE, HUMIDITY SETPOINTS AND SCHEDULE TO RTAC CONTROLS FOR ALL CYCLES.
7. UNOCCUPIED CYCLE
- a. BMS CONTROLS
- 1). RE-1 OFF AND CLOSE ASSOCIATED MOTOR OPERATED DAMPERS
- 2). RE-1 OFF AND CLOSE ASSOCIATED MOTOR OPERATED DAMPERS
- 3). RE-1 OFF AND CLOSE ASSOCIATED MOTOR OPERATED DAMPERS

LEGEND

NOTE: ALL SYMBOLS SHOWN MAY NOT APPEAR ON DRAWINGS.

SYM.	ABBR.	IDENTIFICATION	SYM.	ABBR.	IDENTIFICATION
DUCTWORK					
	DUCT	(RISE/DROP)		SA	DUCT DOWN OR AWAY
	RADIUS	ELBOW		OA	DUCT DOWN OR AWAY
	SQUARE	ELBOW WITH TURNING VANES		EA	DUCT DOWN OR AWAY
	SQUARE	ELBOW WITHOUT TURNING VANES		RA	DUCT DOWN OR AWAY
	SQUARE OR RECTANGULAR	BRANCH TAKEOFF		VD	VOLUME DAMPER
	RECTANGULAR TO ROUND	TAKEOFF		BDD	BACKDRAFT DAMPER
	TEE WITH TURNING VANES			MOD	MOTOR OPERATED DAMPER
	ROUND TO ROUND CONICAL	TAKEOFF		DSD	DUCT SMOKE DETECTOR
	ECCENTRIC	TRANSITION		FD	FIRE DAMPER
	CONCENTRIC	TRANSITION		SD	SMOKE DAMPER
	SQUARE TO ROUND TRANS			FRS	FIRE/SMOKE DAMPER
	DUCT	CAP		SG	SUPPLY GRILLE
	ALD	ACOUSTICALLY LINED DUCT		EGGR	(EXHAUST / RETURN / TRANSFER) GRILLE
	SA	SUPPLY AIR DUCT UP		DTG	DOOR TRANSFER GRILLE
	OA	OUTSIDE AIR DUCT UP		UCD	UNDERCUT DOOR (BY GC)
	RA	RETURN AIR DUCT UP		FC	FLEXIBLE CONNECTION
	EA	EXHAUST AIR DUCT UP		AD	ACCESS DOOR
MISCELLANEOUS AND CONTROLS					
	STATIC PRESS. SENSOR			SLAB TEMP. SENSOR	
	HUMIDISTAT / HUMID. SENSOR			COMBINATION STARTER	
	THERMOSTAT / TEMP. SENSOR			MANUAL STARTER	
	VFD	VARIABLE FREQUENCY DRIVE		OED	OPEN END DUCT
	AFD	ABOVE FINISHED FLOOR		PC	PLUMBING CONTRACTOR
	AFG	ABOVE FINISHED GRADE		RAO	RETURN AIR OPENING
	AP	ACCESS PANEL		TAO	TRANSFER AIR OPENING
	BJ	BOTTOM JOISTS		EAO	EXHAUST AIR OPENING
	BD	BOTTOM OF DUCT		TCC	TEMPERATURE CONTROL CONTRACTOR
	BOG	BOTTOM OF GRILLE		TCP	TEMPERATURE CONTROL PANEL
	EC	ELECTRICAL CONTRACTOR		TJ	THRU JOISTS
	GC	GENERAL CONTRACTOR / CONSTRUCTION MANAGER		TYP.	TYPICAL
	HVC	HVAC CONTRACTOR		TTS	TIGHT TO STRUCTURE
	IMP	INSULATED METAL PANEL		TV	TURNING VANES
	NTC	NOT IN CONTRACT		WWM	WELDED WIRE MESH
	NTS	NOT TO SCALE			
PIPING					
	SHUT-OFF VALVE			PRV	PRESS. REDUCING VALVE
	BALANCE VALVE			SRV	SAFETY RELIEF VALVE
	CHECK VALVE			STEAM TRAP	
	COMBINATION VALVE			ANCHOR	
	STRAINER			GUIDE	
	DRAIN VALVE			PIPPING BOTTOM TAKE-OFF	
	GLOBE VALVE			PIPPING TOP TAKE-OFF	
	THERMOMETER			PIPE DOWN OR AWAY	
	PG	PRESSURE GAUGE		PIPE UP	
	GAUGE COCK			PIPPING CAP	
	TCV	TEMP. CONTROL VALVE		UNION/FLANGE	
	TEST CONNECTION			PIPE PITCH DOWN	
	MAV	MANUAL AIR VENT		CONCENTRIC REDUCER	
	FM	FLOW METER		ECCENTRIC REDUCER	
	FLOW CONTROL / SHUTOFF VALVE			FC	FLEXIBLE CONNECTION
	GEO-5	GEOTHERMAL SUPPLY		BF	BLIND FLANGE
	GTS-8	GEOTHERMAL RETURN		HWS	HOT WATER SUPPLY
	CTS-9	COOLING TOWER WATER SUPPLY		HWR	HOT

DEMOLITION PLAN NOTES

- ALL EQUIPMENT, DUCTWORK AND PIPING SHOWN "RED AND DASHED" SHALL BE REMOVED.
- ALL EQUIPMENT, DUCTWORK AND PIPING SHOWN "LIGHTER" ARE EXISTING TO REMAIN.



Always a Better Plan
100 Camelot Drive
Fond du Lac, WI 54935
920-926-9800
excelengineer.com

PROJECT INFORMATION

STORAGE WAREHOUSE EXPANSION FOR:
WEST POINT DAIRY PRODUCTS
570 NORTH 500 WEST • HYRUM, UT 84319

PROFESSIONAL SEAL

NOT FOR CONSTRUCTION

SHEET DATES

ISSUED FOR BUDGET


IFB APR. 17, 2026

JOB NUMBER

250429500



SHEET NUMBER

HD1.1

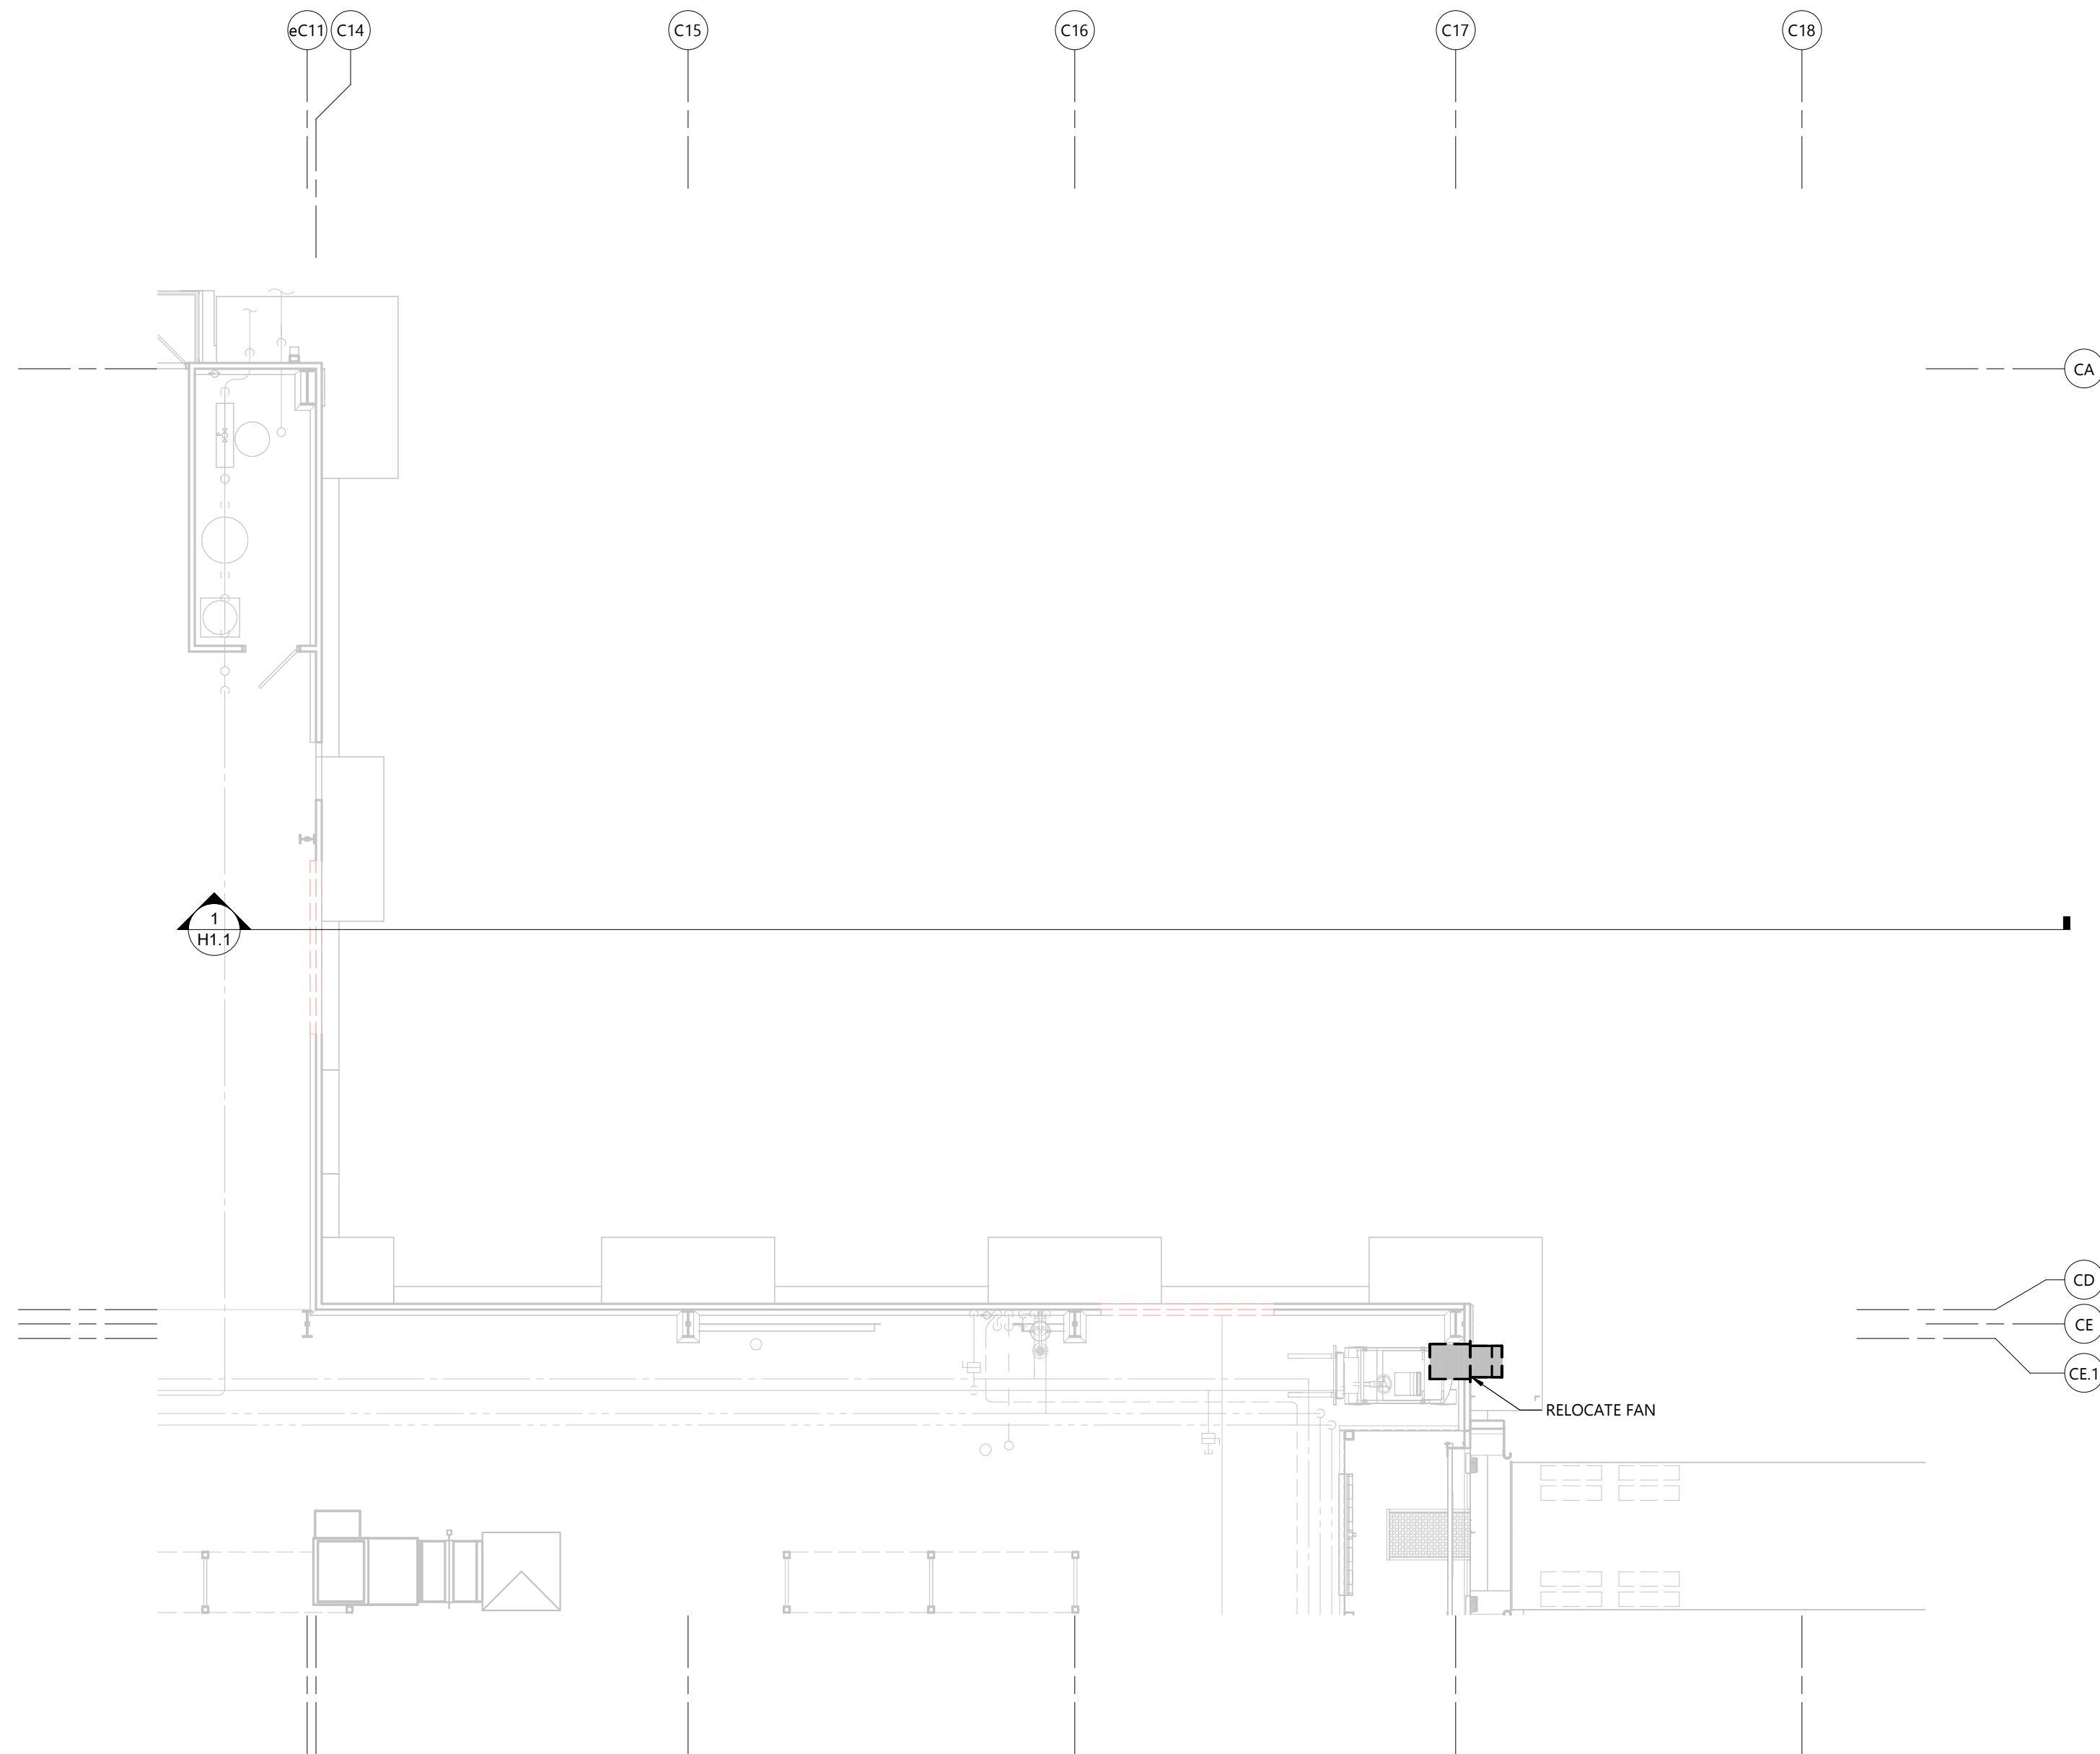

FIRST FLOOR DEMOLITION PLAN

 SCALE: 1/8" = 1'-0"

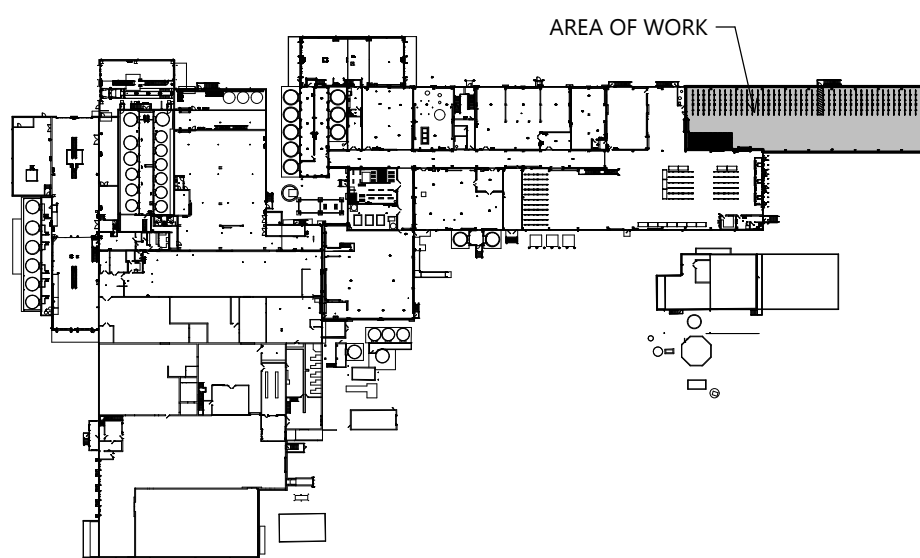

KEY PLAN

HVAC FIRST FLOOR DEMOLITION PLAN

- GENERAL NOTES**
- DUCT FITTINGS SHALL BE TYPE SHOWN ON PLAN OR CALLED OUT BY KEYNOTE. SEE DETAIL 1/H3.0 FOR ADDITIONAL FITTING DETAIL.
 - VERIFY BUILDING OPENING AND CURB SIZES LISTED ON PLANS WITH ACTUAL EQUIPMENT SCHEDULED AND SUPPLIED. COORDINATE REQUIRED OPENING SIZES AND LOCATIONS WITH CONTRACTORS PROVIDING OPENING SCHEDULES AND ACTUAL EQUIPMENT SIZES SHALL TAKE PRECEDENCE OVER SIZES SHOWN ON PLANS.
 - DETAIL REFERENCES ON PLANS ARE TO AID THE CONTRACTOR IN IDENTIFYING THE APPLICABLE DETAIL. NOT ALL DETAILS, OR INSTANCES OF DETAILS, ARE REFERENCED ON PLANS. CONTRACTOR IS RESPONSIBLE TO REVIEW AND COMPLY WITH ALL APPLICABLE DETAILS WHETHER OR NOT REFERENCED ON PLANS.
 - COORDINATE LOCATION OF ALL EXPOSED PIPING AND DUCTWORK WITH OWNER PRIOR TO INSTALLATION.
 - IF DUCT SYSTEMS ARE USED FOR TEMPORARY HEAT, PROVIDE TEMPORARY FILTERS AT RETURN AIR OPENINGS AND INSTALL FILTERS IN THE UNITS. EQUIVALENT TO THE EFFICIENCY OF THE SPECIFIED FILTERS FOR THE UNIT. IF PROPER EFFICIENCY FILTERS ARE NOT INSTALLED IN UNIT, UNIT AND ALL DUCTWORK DOWNSTREAM OF UNIT SHALL BE CLEANED BEFORE TEST AND BALANCE.

EXCEL

Always a Better Plan

100 Camelot Drive
Fond du Lac, WI 54935
920-926-9800
excelengineer.com

PROJECT INFORMATION

STORAGE WAREHOUSE EXPANSION FOR:
WEST POINT DAIRY PRODUCTS
570 NORTH 500 WEST • HYRUM, UT 84319

PROFESSIONAL SEAL


SHEET DATES

ISSUED FOR BUDGET
IFB APR. 17, 2026


JOB NUMBER
250429500

SHEET NUMBER


H1.1

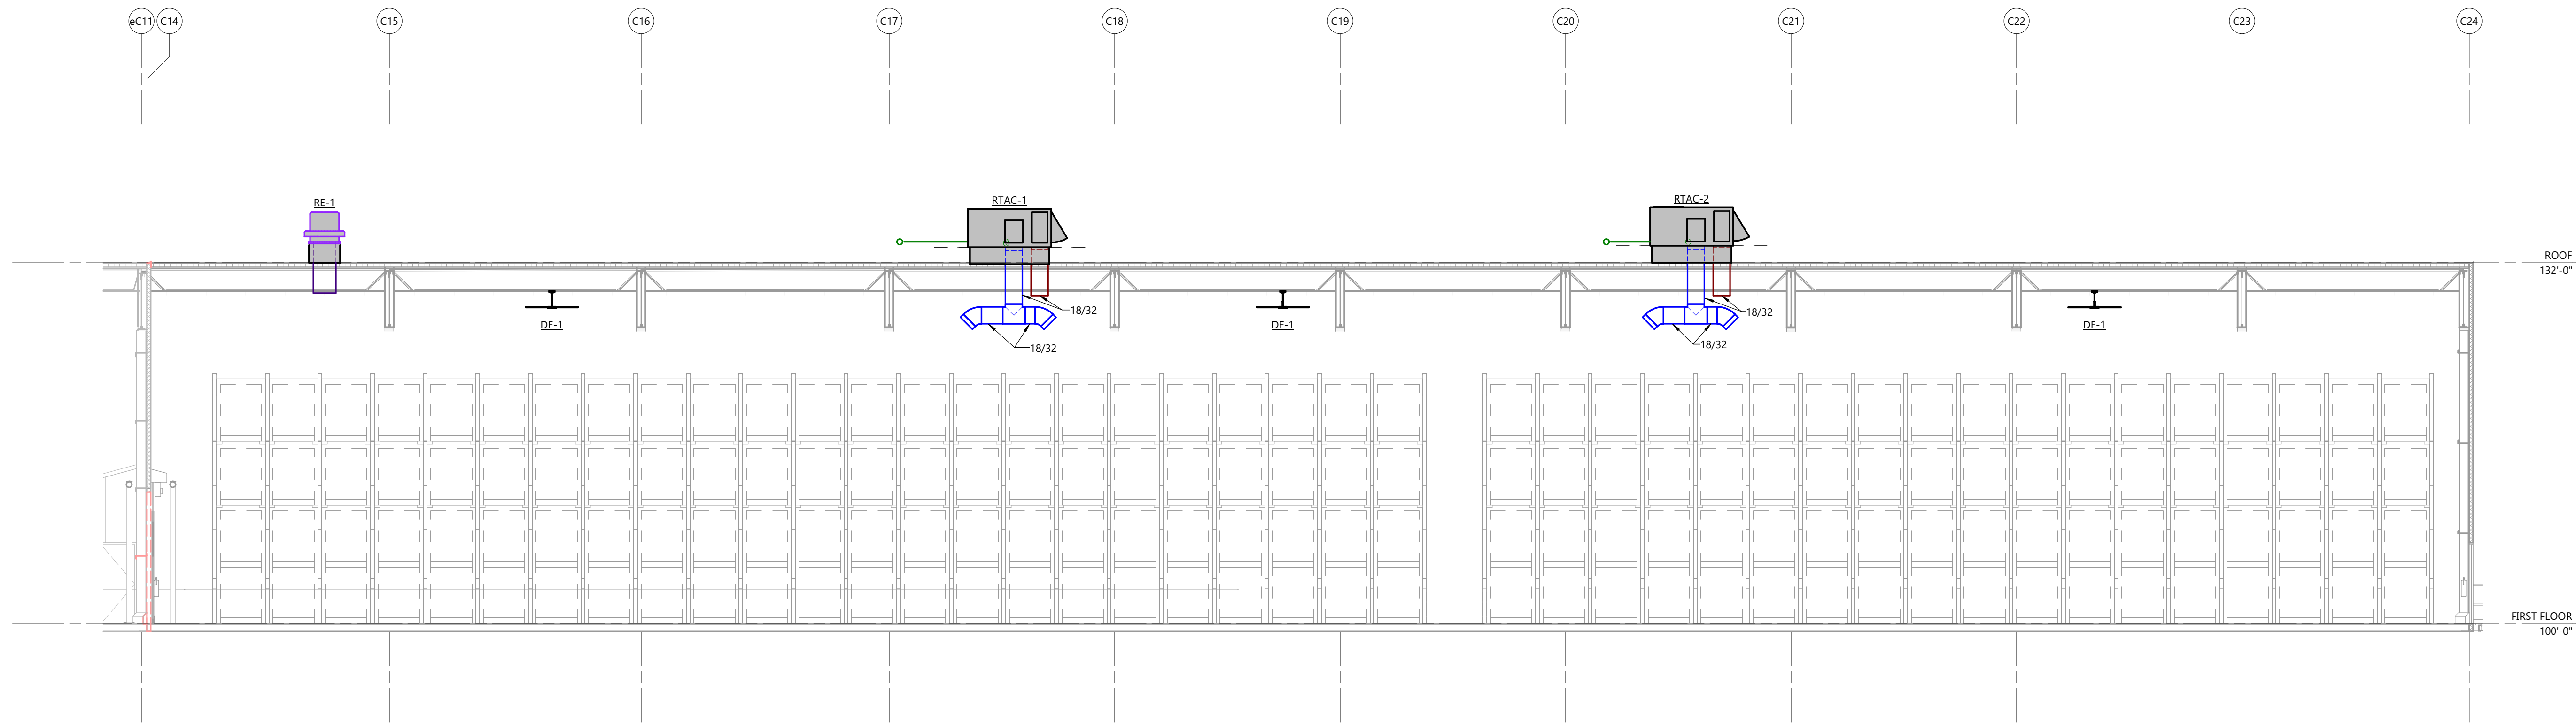

1 EQUIPMENT SECTION
SCALE: 1/8" = 1'-0"
8' 0' 8' 16'

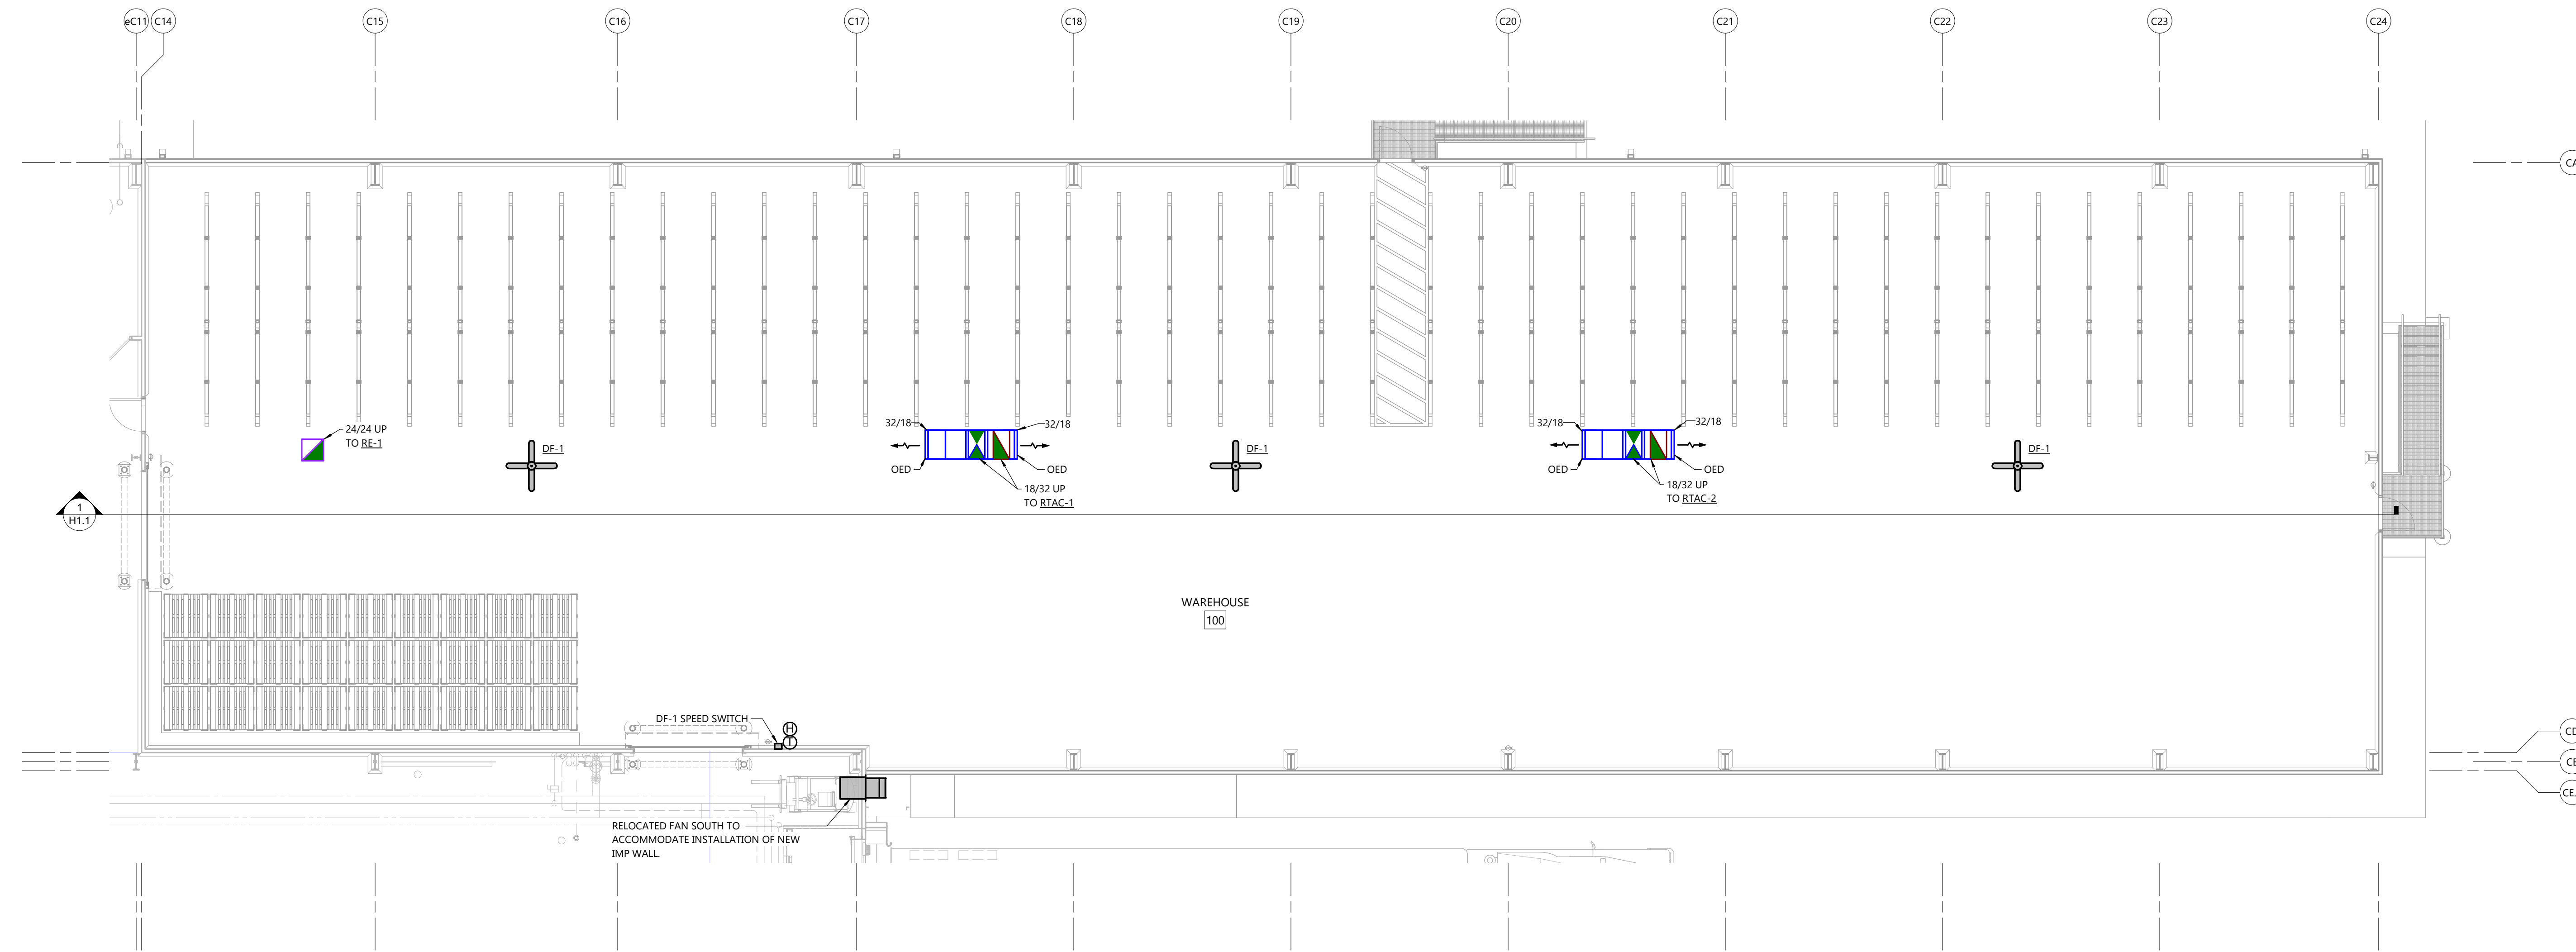


NORTH
FIRST FLOOR PLAN
SCALE: 1/8" = 1'-0"
0' 8' 16'

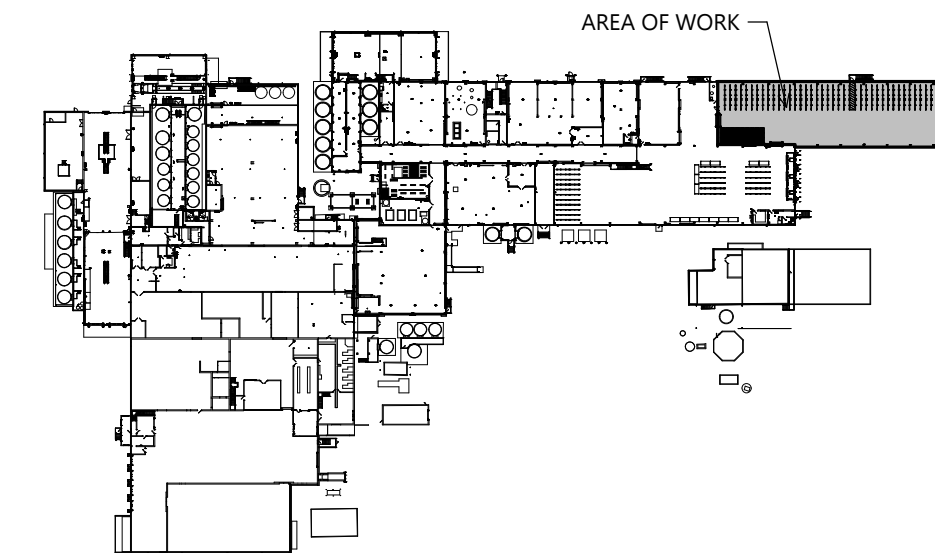


KEY PLAN
HVAC FIRST FLOOR PLAN

NOT FOR CONSTRUCTION

C:\Users\kshen\OneDrive\Documents\250429500 - HVAC - 07mm\0205 - Hvac\Roof Plan.dwg
4/15/2025 2:38:59 PM

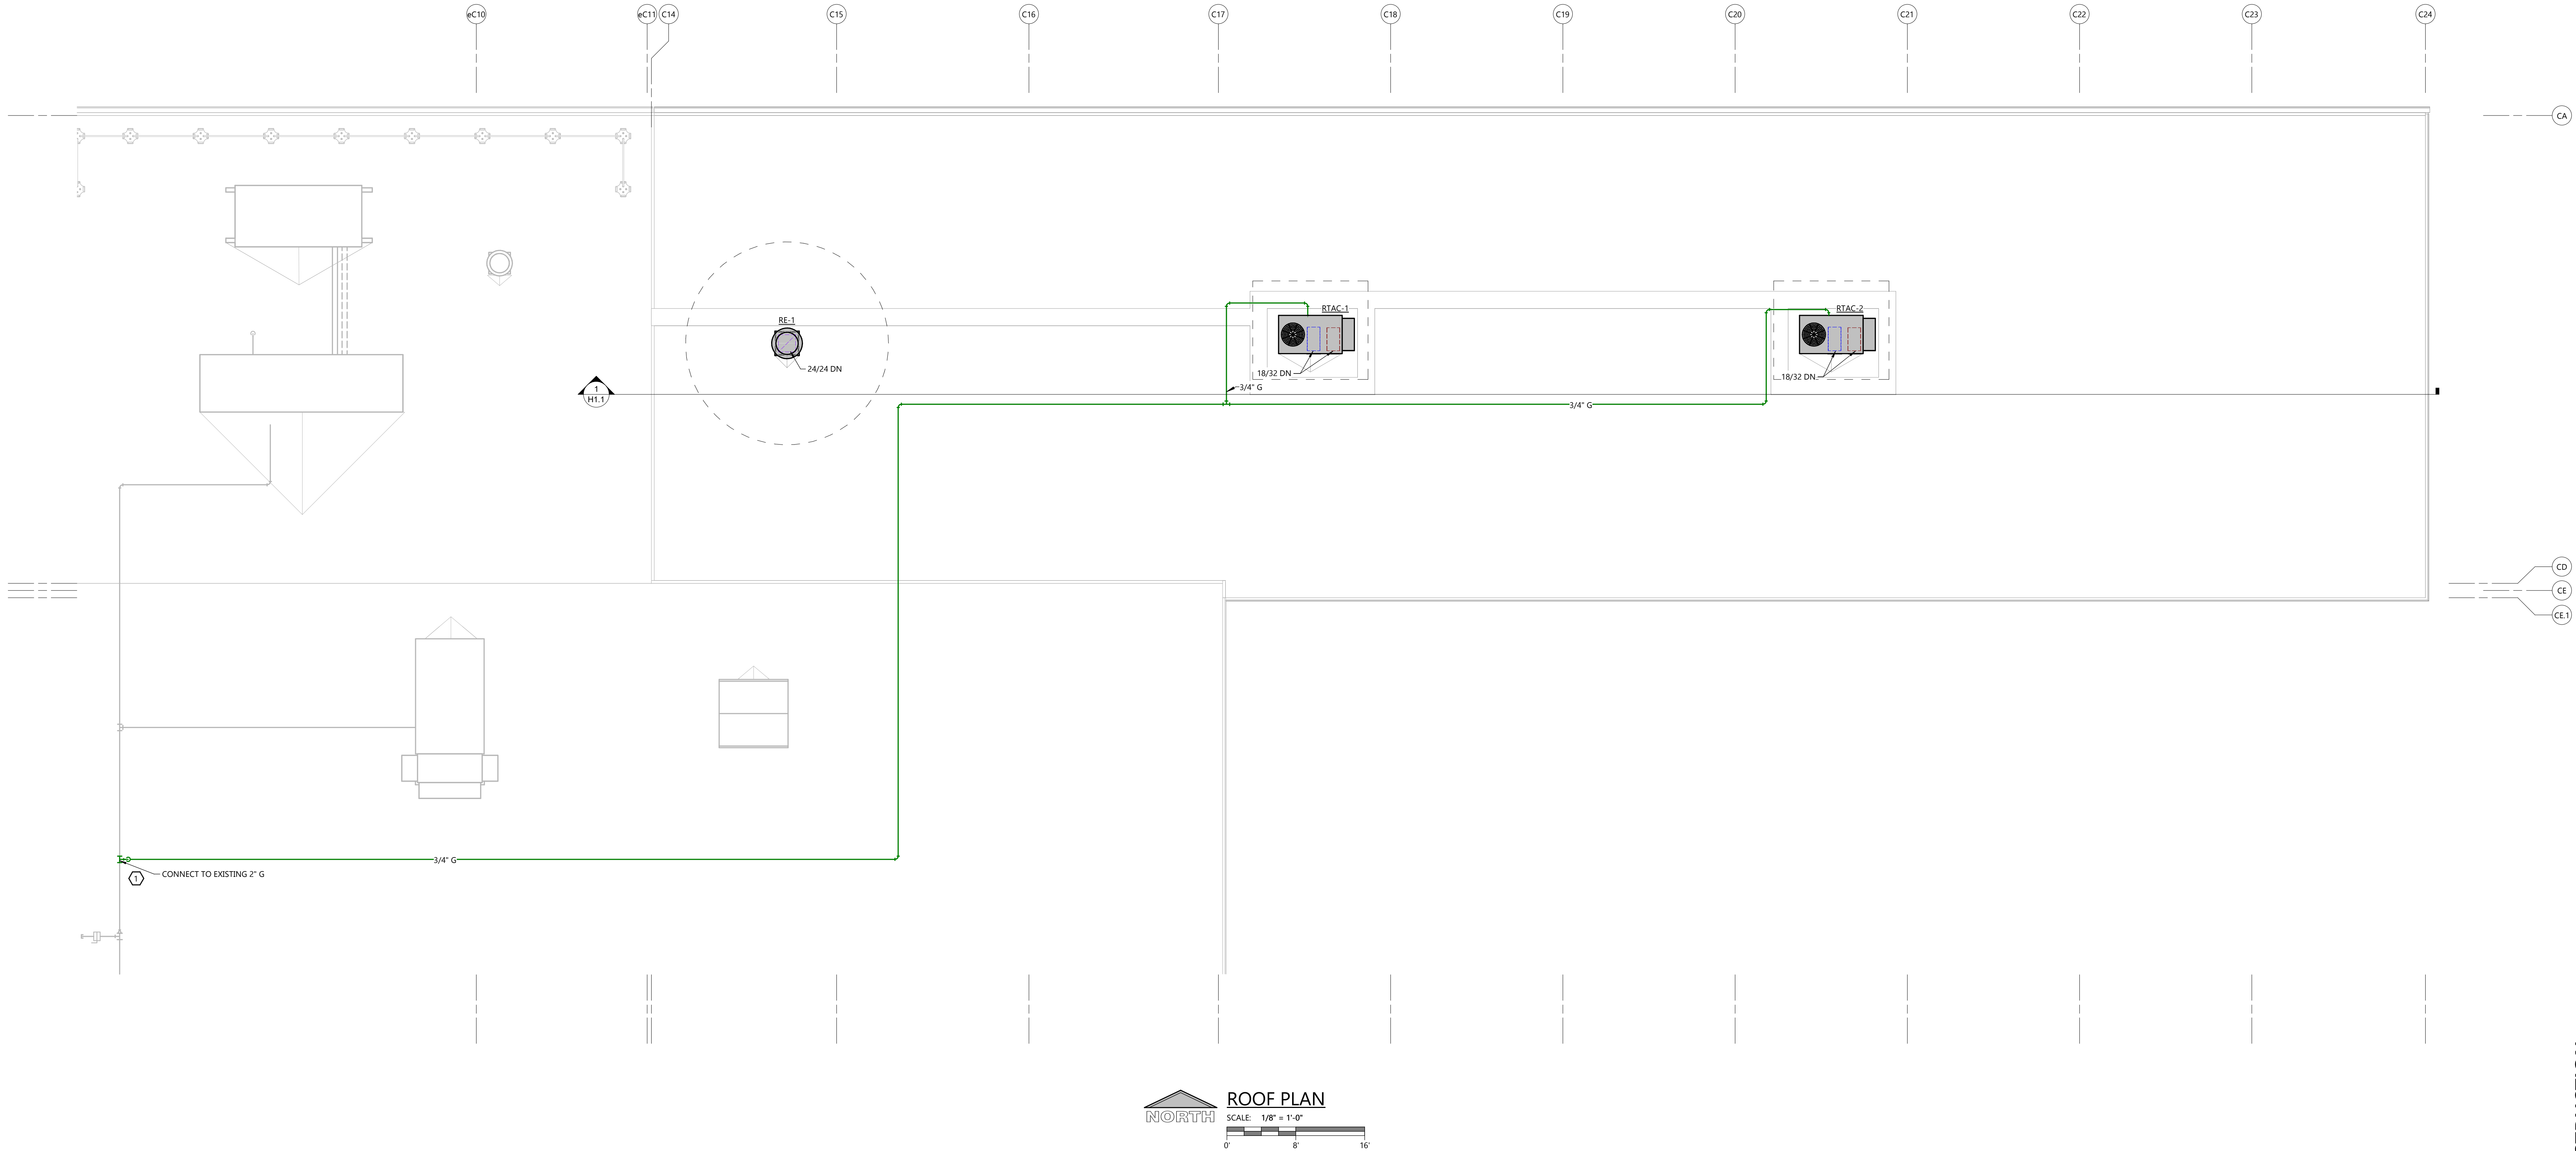

ROOF PLAN
SCALE: 1/8" = 1'-0"
0' 8' 16'

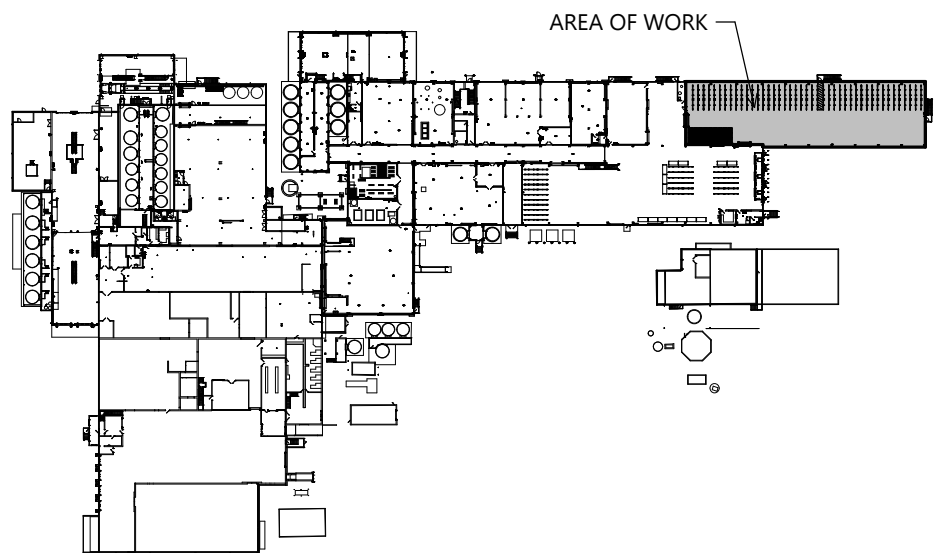

KEY PLAN
HVAC ROOF PLAN

EXISTING GAS LOAD SUMMARY		
ITEM	MBH INPUT	REQUIRED PRESSURE
BOILER-1	33,000	3 PSIG
BOILER-2	33,000	3 PSIG
RTAC-1	124	7" W.C.
RTAC-3	82	7" W.C.
RTAC-5	205	7" W.C.
GUH-1	400	5" W.C.
GUH-2	400	5" W.C.
GUH-3	200	5" W.C.
GUH-4	200	5" W.C.
GUH-5	200	5" W.C.
GUH-6	200	5" W.C.
GUH-7	200	5" W.C.
GUH-8	200	5" W.C.
GUH-9	200	5" W.C.
MAU-1	933	1 PSIG
MAU-2	1,696	1 PSIG
MAU-3	2,290	1 PSIG
MAU-4	3,000	1 PSIG
AHU-1	2,255	1 PSIG
AHU-2	690	1 PSIG
DRYER	22,976	12 PSIG
BOILER-3	199	7" WC
EXISTING TOTAL	102,650	

GAS LOAD SUMMARY		
ITEM	MBH INPUT	REQUIRED PRESSURE (1)
250429500 STORAGE WAREHOUSE		
RTAC-1	99	7" W.C.
RTAC-2	99	7" W.C.
PROJECT TOTAL	197	7" W.C.
250231400 CREAM RECEIVING (FUTURE)		
FAHU-1	3,963	8"-14" W.C.
GUH-1	150	5" W.C.
GUH-2	200	1 PSIG
GUH-3	200	1 PSIG
MAU-1	3,211	7.5" W.C.
MAU-2	2,625	15" W.C.
MAU-3	636	8.5" W.C.
MAU-4	158	6" W.C.
MAU-5	5,716	10.5" W.C.
FUTURE TOTAL	9,859	
GRAND TOTAL	112,706	
- GAS PRESSURE AT METER = 15 PSIG		
- PROVIDE GAS PRESSURE REGULATOR AT EACH PIECE OF EQUIPMENT LISTED ABOVE		
- CONNECT TO EACH PIECE OF EQUIPMENT LISTED ABOVE.		
(1) VERIFY PRESSURE REQUIRED WITH ACTUAL EQUIPMENT INSTALLED ON PROJECT BEFORE SIZING REGULATOR.		

- GENERAL NOTES**
- VERIFY BUILDING OPENING AND CURB SIZES LISTED ON PLANS WITH ACTUAL EQUIPMENT SCHEDULED AND SUPPLIED. COORDINATE REQUIRED OPENING SIZES AND LOCATIONS WITH CONTRACTORS PROVIDING OPENING SCHEDULES AND ACTUAL EQUIPMENT SIZES SHALL TAKE PRECEDENCE OVER SIZES SHOWN ON PLANS.
 - DETAIL REFERENCES ON PLANS ARE TO AID THE CONTRACTOR IN IDENTIFYING THE APPLICABLE DETAIL. NOT ALL DETAILS OR INSTANCES OF DETAILS ARE REFERENCED ON PLANS. CONTRACTOR IS RESPONSIBLE TO REVIEW AND COMPLY WITH ALL APPLICABLE DETAILS WHETHER OR NOT REFERENCED ON PLANS.
 - TERMINATE ALL GAS REGULATOR VENTS MINIMUM 10'-0" FROM EDGE OF ROOF. VENTS SHALL NOT BE TERMINATED OUT EXTERIOR WALLS
 - DASHED LINES AROUND EXHAUST TERMINATIONS INDICATE 10'-0" REQUIRED CLEARANCE TO OUTSIDE AIR INTAKES.

- KEYNOTES**
- ① CONNECT TO EXISTING

PROJECT INFORMATION

STORAGE WAREHOUSE EXPANSION FOR:
WEST POINT DAIRY PRODUCTS
570 NORTH 500 WEST • HYRUM, UT 84319

PROFESSIONAL SEAL

NOT FOR CONSTRUCTION


SHEET DATES	
ISSUED FOR BUDGET	
IFB	APR. 17, 2026

JOB NUMBER
250429500

SHEET NUMBER


H1.3

C:\Users\kshen\OneDrive\Documents\250429500 - HVAC Details\0205 - Labels\labeler not
4/15/2025 2:38:59 PM

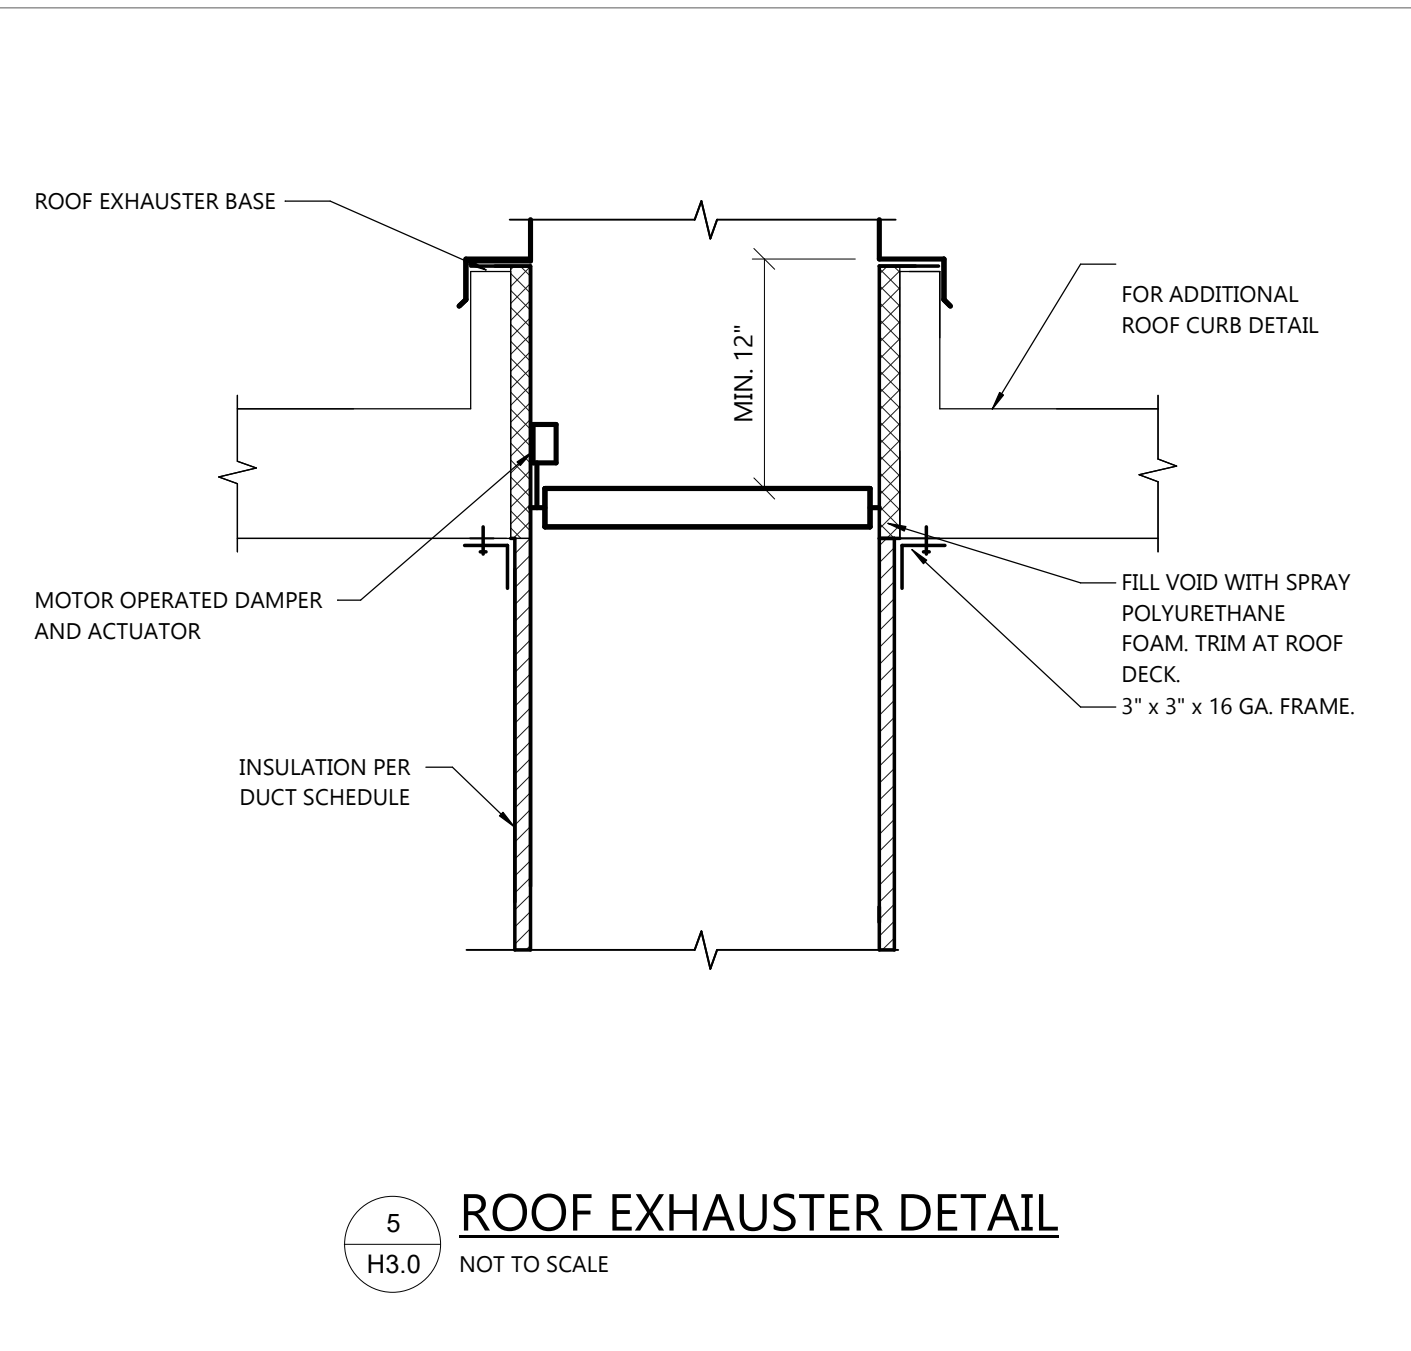


5
H3.0
NOT TO SCALE

ROOF EXHAUSTER DETAIL

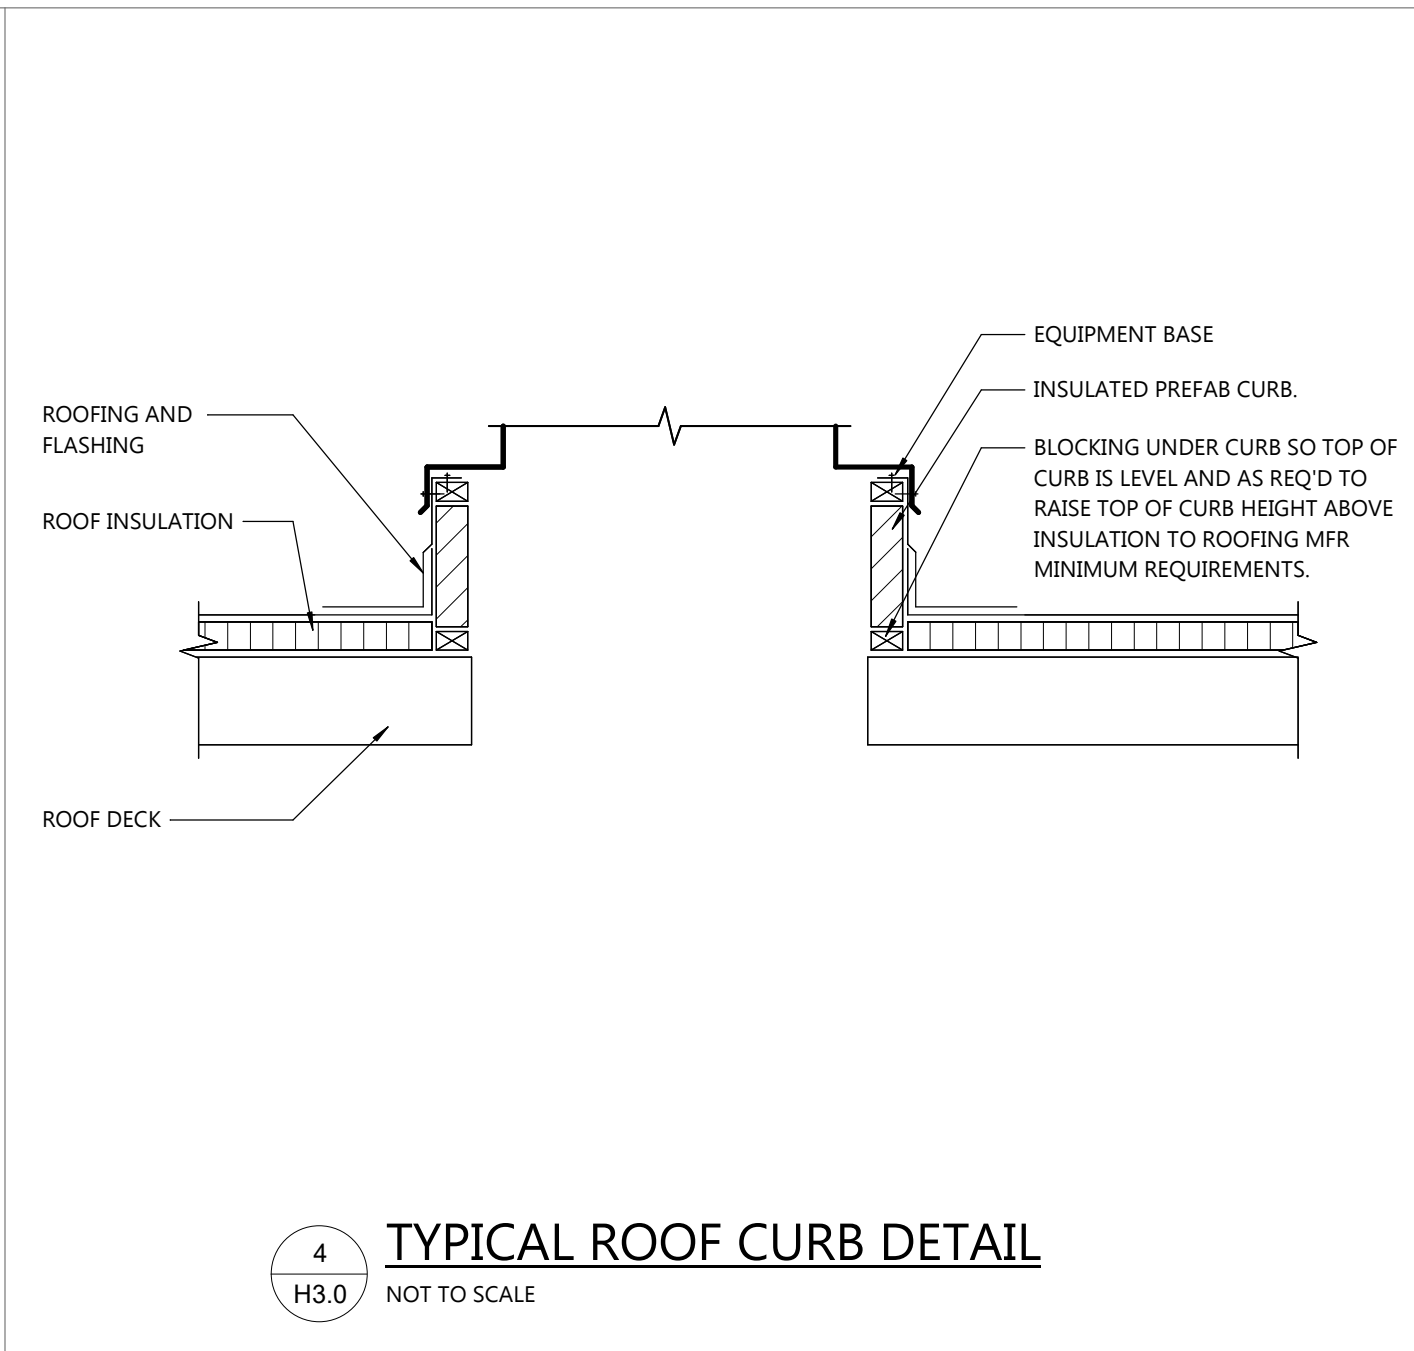


4
H3.0
NOT TO SCALE

TYPICAL ROOF CURB DETAIL

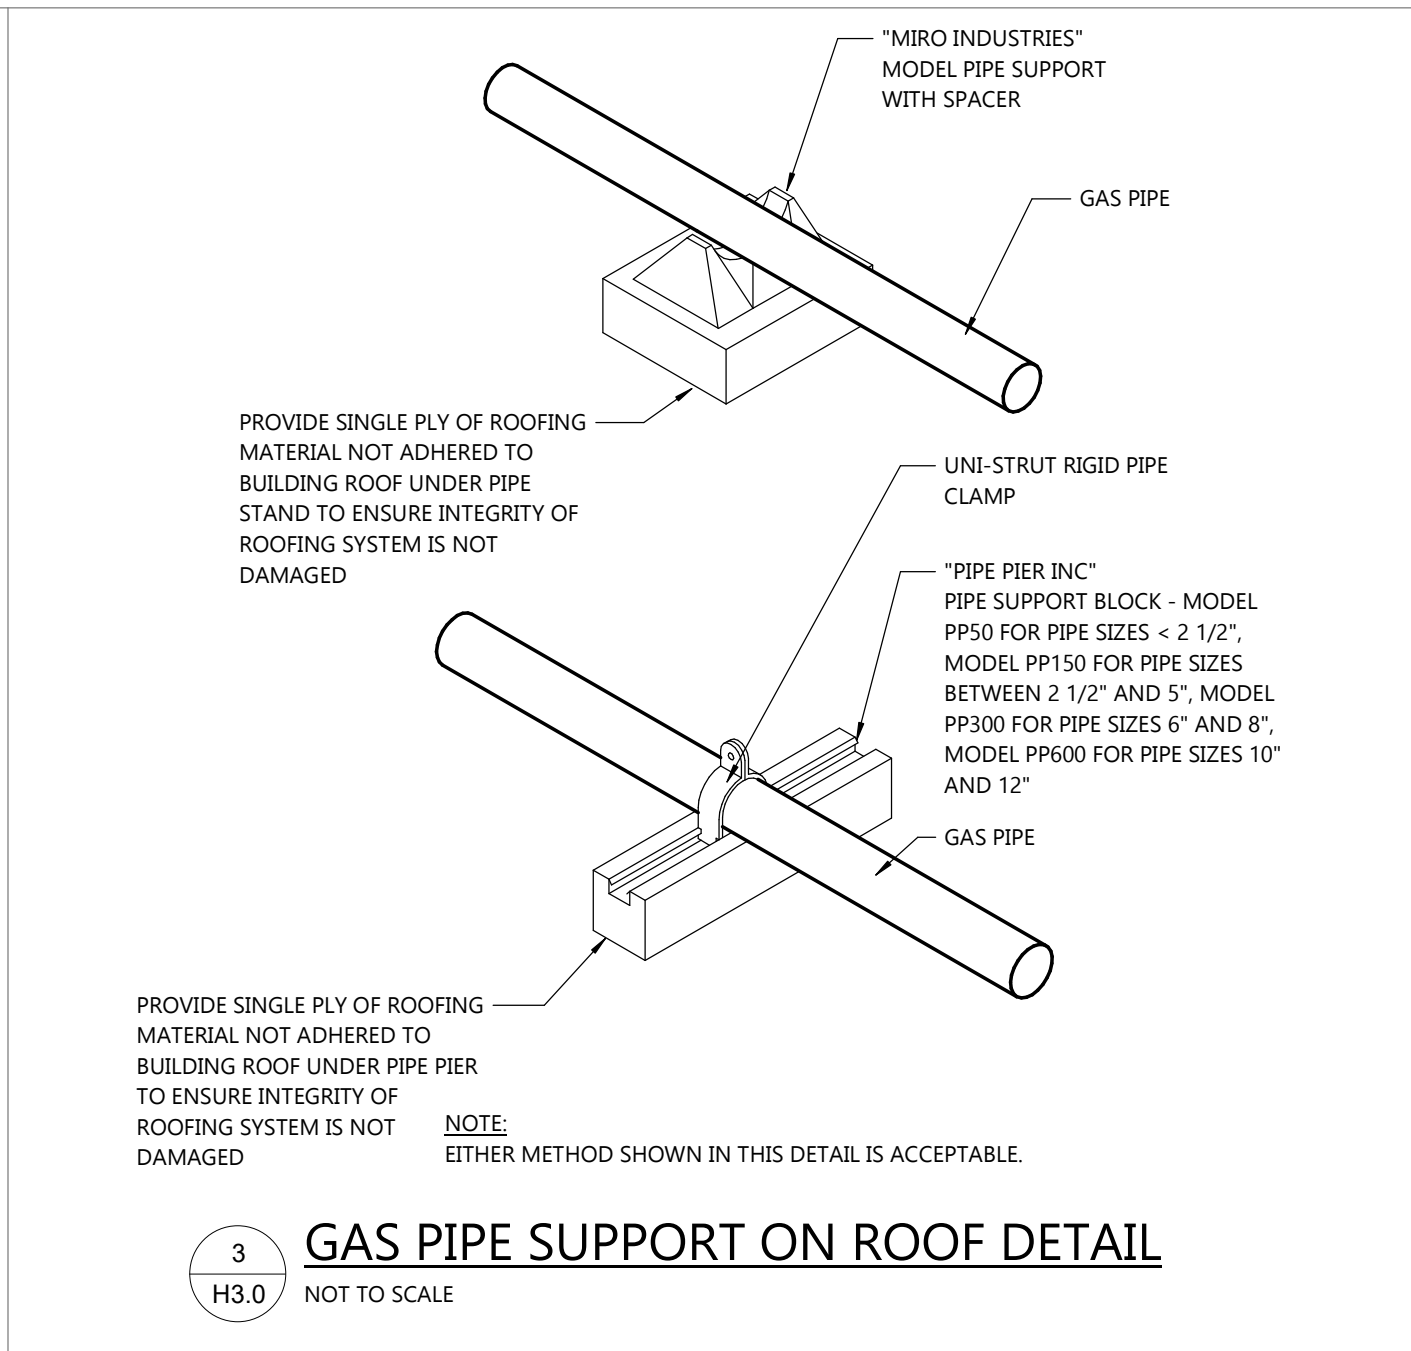


3
H3.0
NOT TO SCALE

GAS PIPE SUPPORT ON ROOF DETAIL

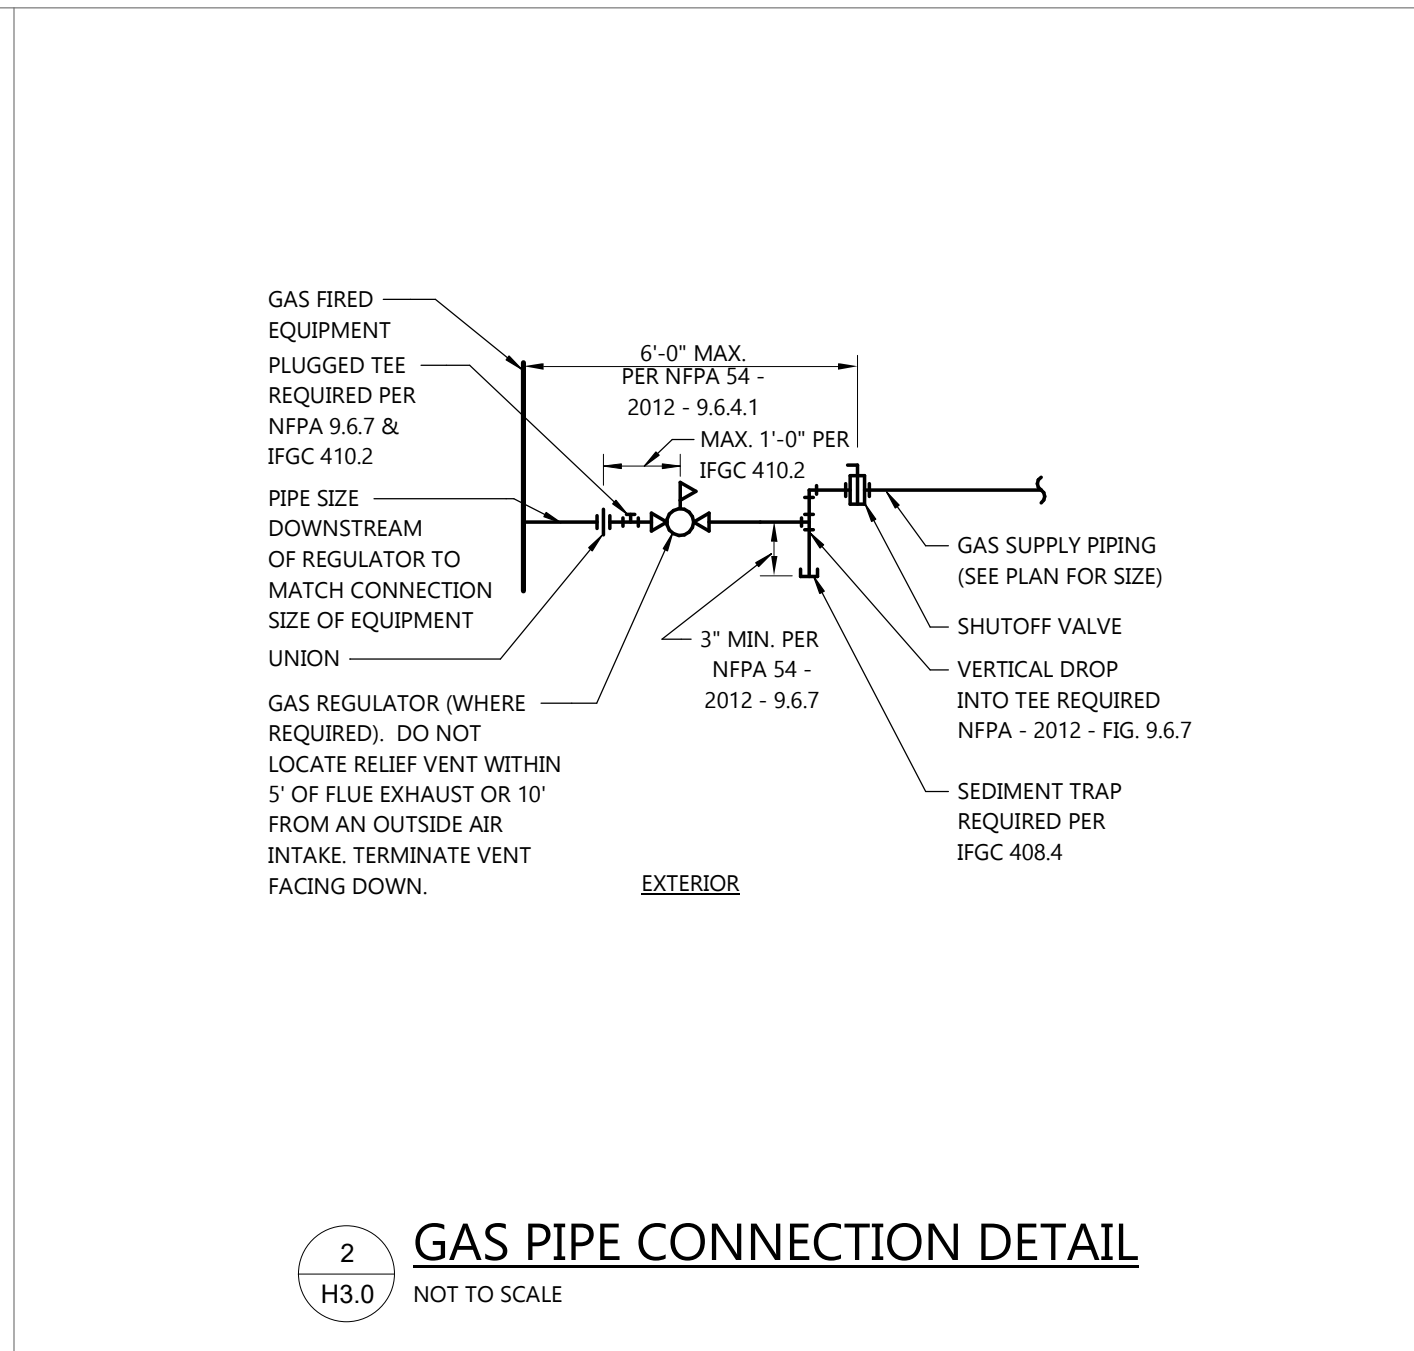


2
H3.0
NOT TO SCALE

GAS PIPE CONNECTION DETAIL

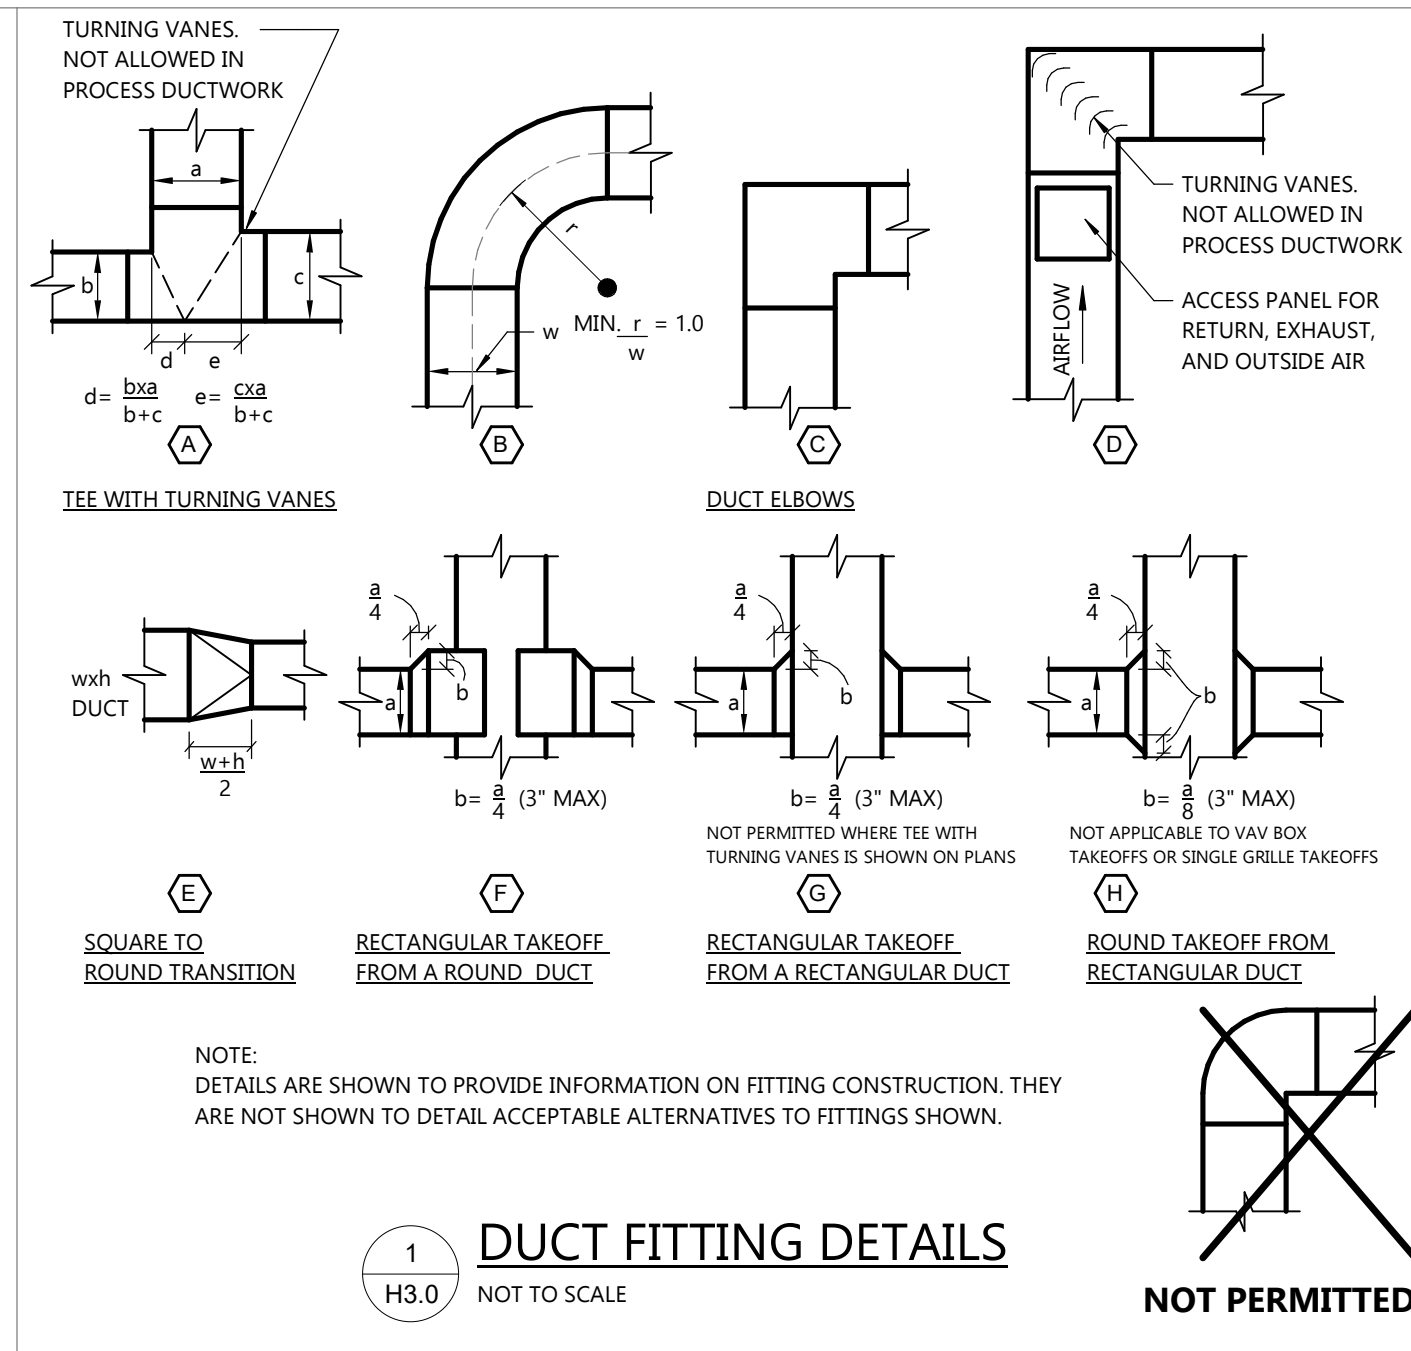


1
H3.0
NOT TO SCALE

DUCT FITTING DETAILS

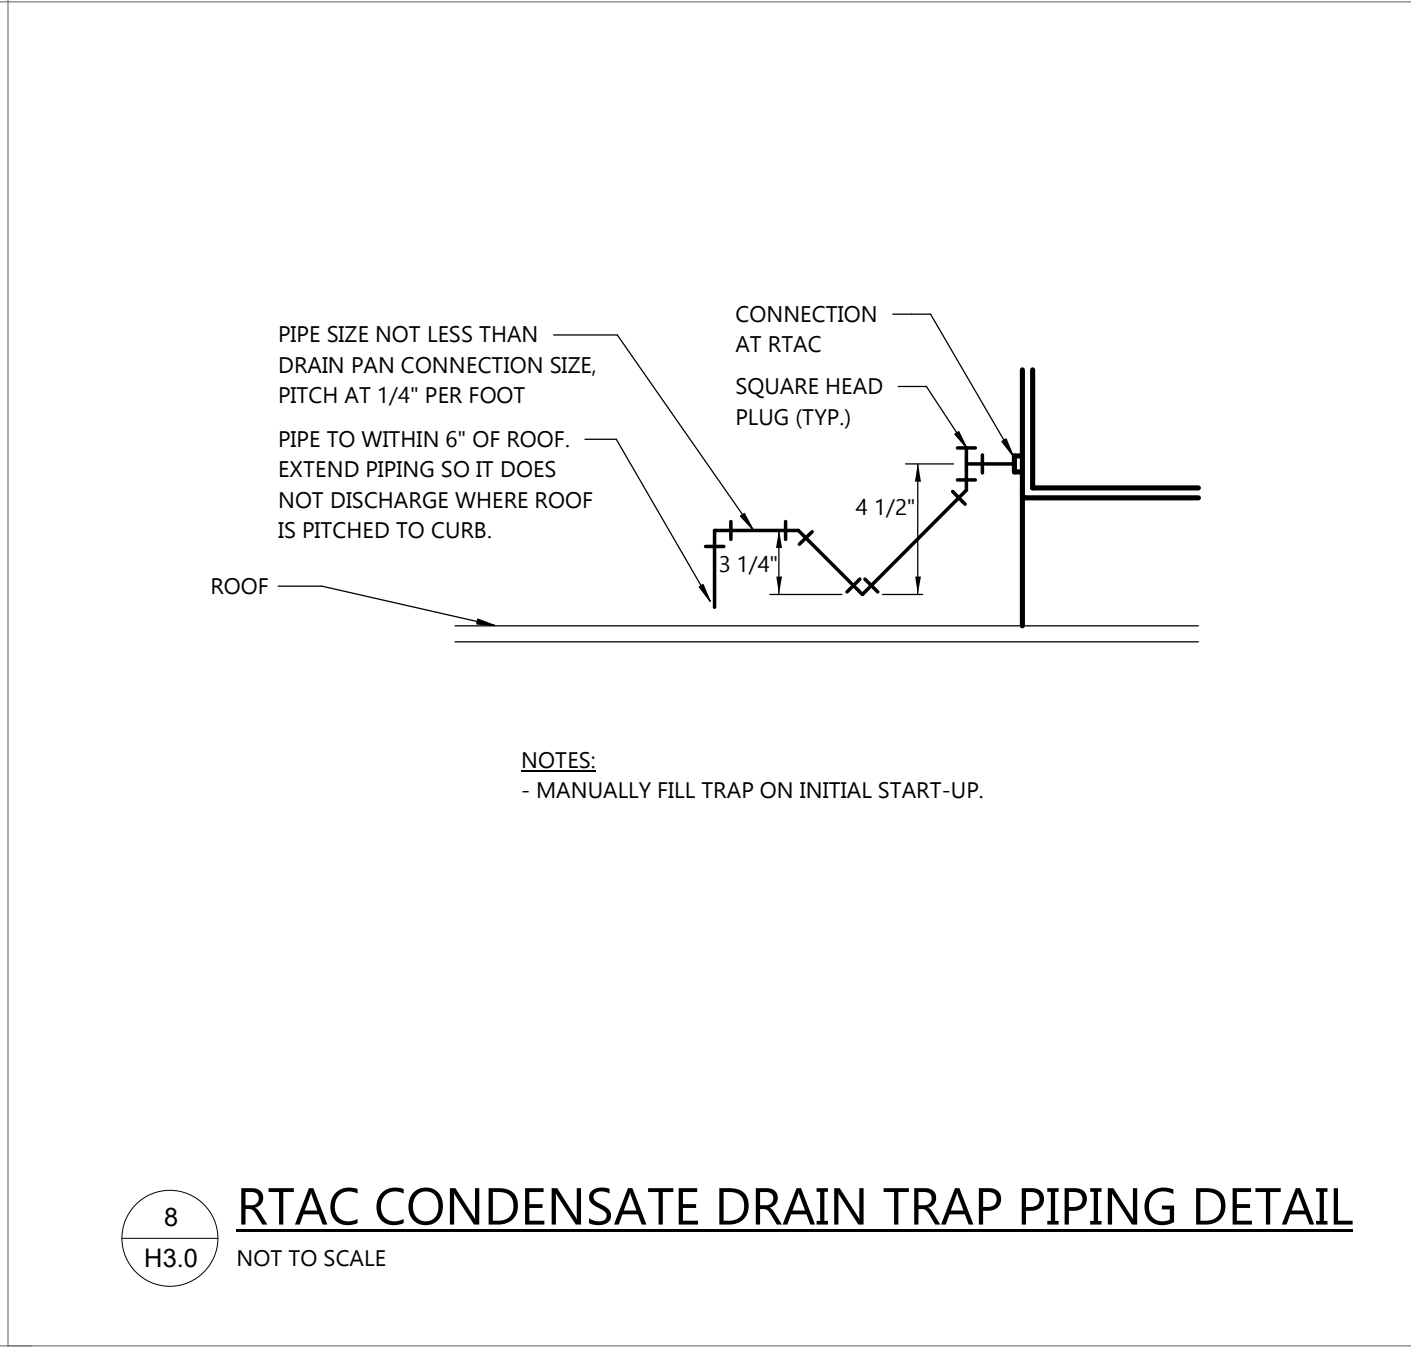


8
H3.0
NOT TO SCALE

RTAC CONDENSATE DRAIN TRAP PIPING DETAIL

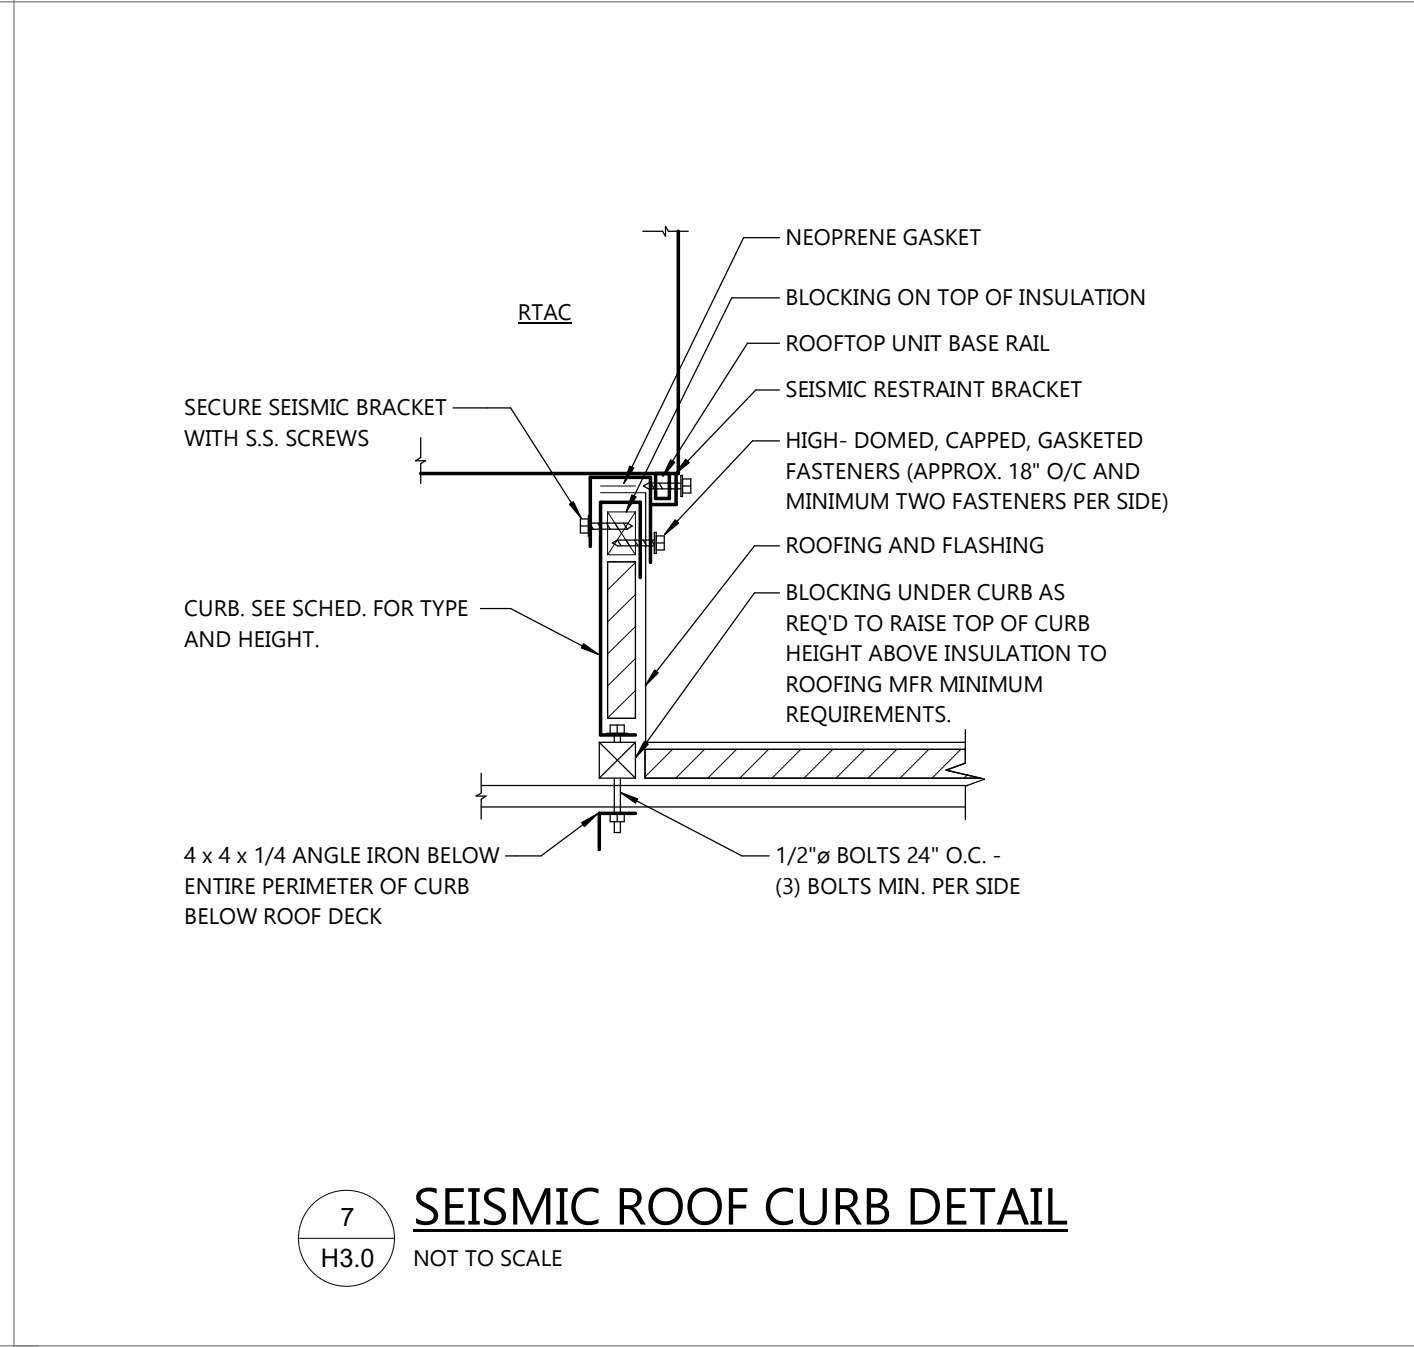

7
H3.0
NOT TO SCALE

SEISMIC ROOF CURB DETAIL

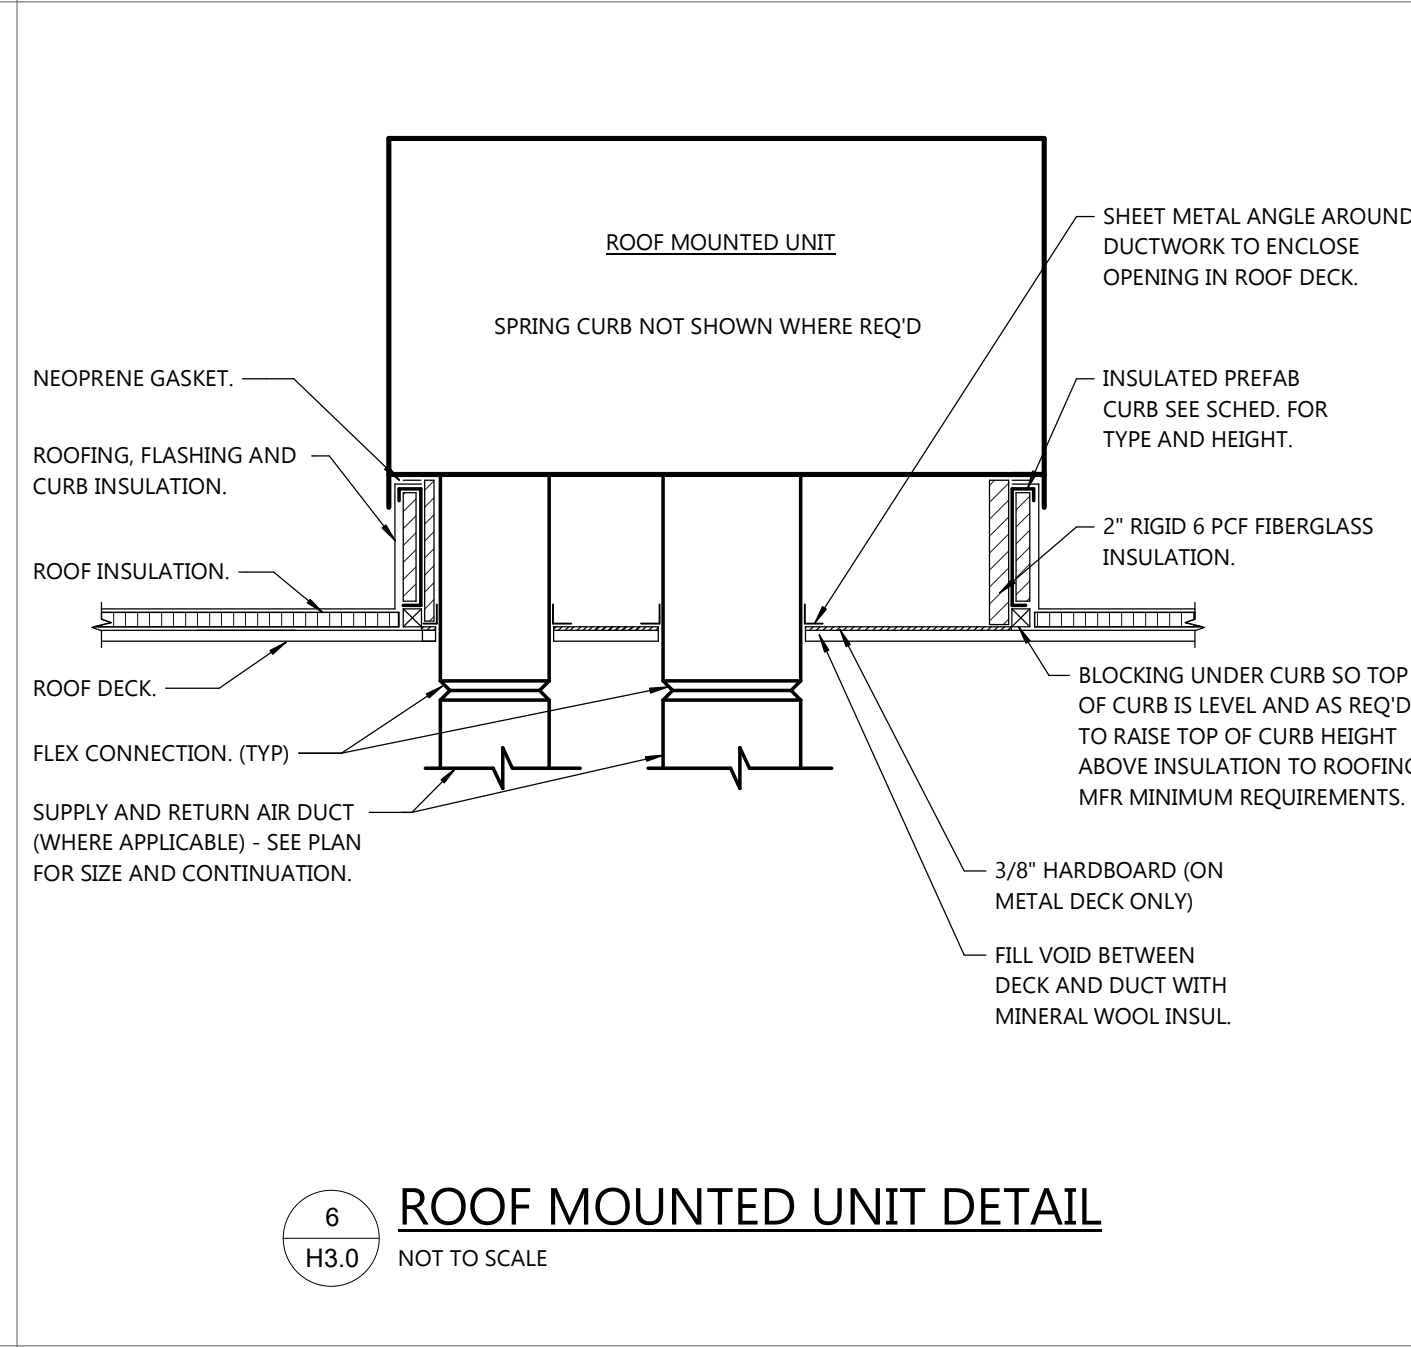

6
H3.0
NOT TO SCALE

ROOF MOUNTED UNIT DETAIL

PROJECT INFORMATION

STORAGE WAREHOUSE EXPANSION FOR:
WEST POINT DAIRY PRODUCTS
570 NORTH 500 WEST • HYRUM, UT 84319

PROFESSIONAL SEAL


NOT FOR CONSTRUCTION

SHEET DATES	
ISSUED FOR BUDGET	
IFB	APR. 17, 2026

JOB NUMBER
250429500

SHEET NUMBER

H3.0

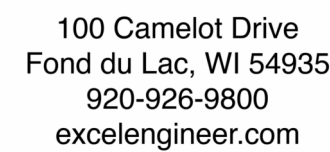

STORAGE WAREHOUSE EXPANSION FOR:

PROFESSIONAL SEAL

NOT FOR CONSTRUCTION

IFB APR. 17, 2026

JOB NUMBER

250420500

250125500

SHEET NUMBER

U10

114.0

(12) PROVIDE INTEGRAL UNIT CONTROL WITH BACNET OR LON COMPATIBLE INTEROPERABILITY WITH BUILDING MANAGEMENT SYSTEM. VERIFY REQUIREMENTS WITH TEMPERATURE CONTROL CONTRACTOR. SEE SEQUENCE OF OPERATION SPECIFICATIONS FOR RTAC CONTROL REQUIREMENTS.

MOTOR

(2) PROVIDE NEMA DESIGN B MOTOR BUILT TO NEMA MG1 PART 31 SUITABLE FOR VFD APPLICATION. PROVIDE FACTORY INSTALLED AEGIS SHAFT GROUNDING RING.

DISCONNECT

(4) PROVIDE PREWIRED DISCONNECT WITH AUXILIARY CONTACTS. LEVITON POWER SWITCH DS-AX OR HUBBELL HBDS. IF DISCONNECT DOESN'T FIT UNDER FAN HOOD, PROVIDE NEMA 4X DISC, WELD BRACKET TO CORNER OF FAN BASE. FACTORY MOUNT DISC ON BRACKET AND RUN LIQUIDTIGHT FROM DISC TO MOTOR.

(6) PROVIDE WITH GREENHECK VCD-23 DAMPER, 16 GA. GALV. FRAME AND BLADES, TPE BLADE SEALS, SS COMPRESSION JAMB SEAL PLATED STEEL LINKAGE AND AXLES, SYNTHETIC BEARINGS. MAXIMUM 4 CFM PER SF LEAKAGE AT 1.0" W.G.

(13) 24 VAC.

- ACCEPTABLE MANUFACTURERS: ENVIRO-FAN, LEADING EDGE.
- PROVIDE WITH DOWNROD LENGTH AS REQUIRED TO MEET SCHEDULED BLADE HEIGHT

(1) PROVIDE SOLID STATE SPEED CONTROL FOR 3 FANS IN ROOM 100.

N/A = NOT REQUIRED
 EXPOSED = VISIBLE FROM OCCUPIED SPACE, DOES NOT INCLUDE DUCTWORK ABOVE WALK-ON CEILINGS AND IN MECHANICAL ROOMS. DUCTWORK IN ROOMS WITH CLOUD CEILINGS ARE CLASSIFIED AS EXPOSED.
 CONCEALED = HIDDEN FROM VIEW BY WALLS AND CEILINGS. INCLUDES DUCTWORK ABOVE WALK-ON CEILINGS AND IN MECHANICAL ROOMS.
 MATERIALS:
 GALV. STEEL: ASTM A653. COAT FORMING QUALITY, 1.25 OUNCES/ S.F. ZINC COATING (G90 IN ACCORDANCE WITH ASTM AND BOTH SIDES).
 ALL JOINTS, LONGITUDINAL AND TRANSVERSE SEAMS AND CONNECTIONS IN DUCTWORK SHALL BE SEALED PER 2017 IECC 403.1.2.
 (2) INSULATE FROM 18" UPSTREAM OF THE BACKDRIFT OR MOTOR OPERATED DAMPER TO THE POINT WHERE THE DUCT EXITS THE BUILDING.

(19) ASTM F656 SOLVENT WELD WITH ASTM F493 CLEAR SOLVENT CEMENT.

INTER: INTER - INTEGRATED. PROVIDES INTERLATCH WITH EQUIPMENT. RELAY 10: LISTED MOTOR RATED RELAY WITH SEPARATE TERMINALS FOR INPUT AND OUTPUT CONTACTS (RBIT SERIES). OVERRIDE SWITCH AND LED STATUS INDICATOR. CONTACT: RELAY CONFIGURATION, AND COIL VOLTAGE SUITABLE FOR APPLICATION. MAN - MANUAL: NEMA ICS 2, 3. GENERAL PURPOSE CLASS A MANUALLY OPERATED, FULL-VOLTAGE CONTROLLER WITH QUICK MAKE AND BREAK TOGGLE ACTION AND DOUBLE BREAK SILVER ALLOY CONTACTS. BIFURCATED OR MELTING ALLOY TYPE THERMAL OVERLOAD UNITS. NEMA ICS 3 GENERAL PURPOSE CLASS A MANUALLY OPERATED, FULL-VOLTAGE CONTROLLER WITH QUICK MAKE AND BREAK TOGGLE ACTION AND DOUBLE BREAK SILVER ALLOY CONTACTS. MAG - MAGNETIC: NEMA ICS 2, 3. GENERAL PURPOSE CLASS A MAGNETIC ACROSS-THE-LINE CONTROLLER. DOUBLE BREAK SILVER ALLOY CONTACTS. NEMA SOLID STATE OVERLOAD RELAY WITH USER SELECTABLE SETTINGS, CLASS 10, 20, 30, AND 30-BUILT-IN MEMORY TO PREVENT HOT MOTOR STARTING. OPERATING TEMPERATURE RANGE -40 TO 125 DEGREES C. PROTECTS AGAINST OVERHEATING, OVERCURRENT, UNDERCURRENT, UNDERVOLTAGE, UNDERLOAD, AND OVERVOLTAGE. PROVIDE NEMA ICS 6. TYPE 1 ENCLOSURE AIRFLOW SETTINGS AS REQUIRED FOR CONTROL. PROVIDE 120V, 60 HZ, SECONDARY. 100VA FUSED MINIMUM. TRANSFORMER IN EACH STARTER FUSED PRIMARY AND SECONDARY. DONUT UNFUSED LEG OF SECONDARY TO ENCLOSURE. COMB - COMBINATION: COMBINE MAGNETIC STARTER AND NON-FUSED DISCONNECT SWITCH IN COMMON ENCLOSURE. LOCKABLE IN OPEN POSITION. INCLUDES CAST-TYPE MOTOR TERMINAL BLOCK. CURRENTS TO 100A. VOLTS - VARIABLE FREQUENCY DRIVE - SEE SPECS.			
FURNISHED BY: EM - EQUIPMENT MANUFACTURER HC - HEATING CONTRACTOR EC - ELECTRICAL CONTRACTOR	ACCESSORIES: HA - HAND-OFF AUTO HL - LED PILOT LIGHT PH - PUSH BUTTON	DISCONNECT: NR - NOT REQUIRED R - REQUIRED F - FUSED	REMARKS: REC - RECEPTACLE

- ACCEPTABLE MANUFACTURERS: ALLEN BRADLEY, CUTLER HAMMER, SQUARE D, GENERAL ELECTRIC.
 - VERIFY VOLTAGE AND PHASE WITH ELECTRICAL CONTRACTOR BEFORE ORDERING EQUIPMENT.
 - FURNISH MOTOR STARTERS TO E.C. FOR INSTALLATION AND WIRING WHEN THE STARTER SCHEDULED CALLS FOR H.C. TO FURNISH.
 - NAME RATINGS OF COMPONENTS SHALL BE SUITABLE FOR THE ENVIRONMENT THEY ARE MOUNTED IN (NEMA 3R FOR OUTDOORS, NEMA 4X FOR WASHDOWN, ETC)
 (2) DISCONNECT FACTORY MOUNTED AND PREWIRED BY MANUFACTURER.
 (C) EC SHALL WIRE FROM AUX CONTACT AT DSC TO SHUT DOWN VFD WHEN DSC IS ENGAGED. EC TO PROVIDE AUX CONTACT AT DISCONNECT IF EC IS PROVIDING DISCONNECT.

ELECTRICAL SPECIFICATIONS

DIVISION 26 ELECTRICAL

26 05 00 BASIC ELECTRICAL REQUIREMENTS

- A. SEE DIVISION 00 PROCUREMENT AND CONTRACTING AND DIVISION 01 GENERAL REQUIREMENT FOR ADDITIONAL REQUIREMENTS.
- B. ELECTRICAL CONTRACTOR SHALL VERIFY REQUIREMENTS FOR TEMPORARY LIGHTING AND POWER WITH GENERAL CONTRACTOR AND INCLUDE IN HIS SCOPE OF WORK WHEN DIRECTED BY G.C. INSTALL IN ACCORDANCE WITH ALL CODE AND OSHA REQUIREMENTS FOR CONSTRUCTION PROJECTS.
- C. SUBSTITUTIONS:
- SEE DIVISION 01 25 00 PRODUCT SUBSTITUTION PROCEDURES FOR ADDITIONAL REQUIREMENTS.
 - CONTRACTOR SHALL PROVIDE ALL SUPPORTING DATA AND ASSURE THE BUREAU OF PROOF THAT ANY SUBSTITUTE IS EQUIVALENT AS TO APPEARANCE, CONSTRUCTION, CAPACITY, AND PERFORMANCE. THE JUDGMENT OF EQUIVALENCY SHALL BE MADE BY THE ENGINEER AT THE TIME OF SHOP DRAWING REVIEW, NOT DURING BIDDING.
 - WHERE SUBSTITUTE EQUIPMENT REQUIRES REDESIGN OF ANY PART OF THE PROJECT, THE COST OF REDESIGN AND ADDITIONAL COSTS OF THE WORK SHALL BE PAID BY THE CONTRACTOR. REDESIGN SHALL BE SUBJECT TO THE APPROVAL OF ALL AUTHORITIES HAVING JURISDICTION OVER THE WORK INCLUDING THE ARCHITECT/ENGINEER.
- D. SHOP DRAWINGS, PRODUCT DATA, TEST RESULTS AND SAMPLE SUBMITTALS:
- SEE DIVISION 01 33 25 SHOP DRAWINGS, PRODUCT DATA, AND SAMPLES FOR ADDITIONAL REQUIREMENTS.
 - ELECTRICAL CONSTRUCTION ADMINISTRATION SUBMITTAL LIST:
 - PANELBOARD CIRCUIT BREAKERS
 - LIGHT FIXTURES
 - ALL DIVISION 27
 - ALL DIVISION 28
 - INCLUDE OUTLINE AND GENERAL ARRANGEMENT DRAWINGS, DATA SHEETS AND WIRING DIAGRAMS.
 - SHOP DRAWINGS SHALL CLEARLY INDICATE SPECIFIC MODEL BEING PROVIDED WHERE CUT SHEETS SHOW MULTIPLE MODELS.
 - LIGHT FIXTURE SHOP DRAWINGS SHALL CLEARLY INDICATE IDENTIFICATION TAG AS INDICATED IN LIGHT FIXTURE SCHEDULE. ALL OPTIONS, ACCESSORIES AND FINISHES BEING PROVIDED SHALL BE CLEARLY INDICATED.
 - SYSTEM WIRING RISER DIAGRAMS SHALL INDICATE ALL COMPONENTS SHOWN ON THE FLOOR PLANS, TYPE AND TERMINATION POINT OF CABLE TO EACH COMPONENT.
 - PROJECT CLOSEOUT
 - MARK RECORD DRAWINGS ON A FINAL SET OF DRAWINGS WHICH INCLUDES ALL REVISIONS.
 - FINISHING AND PAINTING:
 - SEE DIVISION 09 01 00 FINISH AND PAINTING FOR ADDITIONAL REQUIREMENTS.
 - PREPARE EXPOSED CONDUIT, FITTINGS, SUPPORTS, AND ACCESSORIES FOR FINISH PAINTING IN ROOMS THAT WILL HAVE CEILING AND STRUCTURE PAINTED.
 - E.C. SHALL PROVIDE A FACTORY OR FIELD APPLIED PRIME AND FINISH COAT OF COLOR SELECTED BY THE OWNER'S REPRESENTATIVE TO ALL ROOF MOUNTED EQUIPMENT AND OTHER EXTERIOR MATERIALS INCLUDING SUPPORT HARDWARE.
 - COORDINATE WORK WITH THE PAINTERS SO THAT ALL EQUIPMENT IS INSTALLED PRIOR TO PAINTING. E.C. SHALL PAINT ITEMS IF NOT IN PLACE PRIOR TO NORMAL ROUTINE PAINTING.
 - IF FINISH BECOMES RUSTED, CORRODED, SCRATCHED, OR FLAKED DURING STORAGE OR INSTALLATION, REFINISH THE EQUIPMENT TO THE SATISFACTION OF THE OWNER.
 - WHERE THE ELECTRICAL CONTRACTOR IS REQUIRED TO PAINT, THE PAINTING SHALL BE DONE IN ACCORDANCE WITH THE PAINTING PORTION OF THE ARCHITECTURAL SPECIFICATION.
 - DETAILS AND SCHEDULES ARE SHOWN TO AID THE CONTRACTOR AND ARE NOT MEANT TO BE INCLUSIVE OF ALL DEVICES. PROVIDE REQUIRED EQUIPMENT AND ACCESSORIES FOR A COMPLETE INSTALLATION.
 - INSTALL ALL EQUIPMENT PER MANUFACTURER'S INSTALLATION INSTRUCTIONS AND REQUIREMENTS. PROVIDE ADDITIONAL WORK AND MATERIALS AS REQUIRED.
 - COORDINATE INSTALLATION OF ELECTRICAL WORK WITH THE OTHER CONTRACTORS TO AVOID CONFLICTS WITH OTHER WORK.
 - MAINTAIN MAXIMUM HEADROOM AND SPACE CONDITION AT ALL POINTS IN THE BUILDING. WHERE HEADROOM OR SPACE CONDITIONS ARE NOT ADEQUATE, NOTIFY ARCHITECT/ENGINEER BEFORE PROCEEDING WITH THE INSTALLATION.
 - COMPLY WITH THE REQUIREMENTS OF NFPA: NATIONAL, STATE AND LOCAL ELECTRICAL CODES AND LOCAL UTILITY REGULATIONS.
 - MATERIAL SHALL BEAR UL AND/OR OTHER APPROVED AGENCY LISTING.
 - INSTALL MOTOR STARTERS/VFDs FURNISHED BY HVAC AND PLUMBING CONTRACTORS, AND WIRE FROM THE POWER SOURCE TO THE STARTER/VFD AND FROM THE STARTER/VFD TO THE MOTOR.
 - VERIFY ELECTRICAL SIZE AND CONNECTION REQUIREMENTS FOR EQUIPMENT FURNISHED BY OTHERS WITH FINAL SHOP DRAWINGS.
 - CONTRACTOR SHALL CALL LOCAL UTILITY LOCATING SERVICE AND CONDUCT A PRIVATE UTILITY LOCATION TO ENSURE THAT ALL ELECTRICAL FEEDERS, BRANCH CIRCUITS, LOW VOLTAGE CABLES AND FIBER OPTIC HAVE BEEN LOCATED BEFORE STARTING SITE DEMOLITION. DESIGN ENGINEER AND GENERAL CONTRACTOR SHALL BE NOTIFIED OF ANY DISCREPANCIES BETWEEN PLAN AND FIELD CONDITIONS PRIOR TO CONSTRUCTION.
 - SCHEDULE REQUIRED POWER, TELEPHONE OR DATA OUTAGES IN OCCUPIED AREAS OF THE BUILDING WITH THE OWNER. CONTRACTOR SHALL WORK UNTIL SERVICE IS RESTORED. OUTAGE WORK SHALL BE PERFORMED DURING NON-WORKING HOURS, WEEKENDS, OR HOLIDAYS.
 - PROVIDE ALL CUTTING AND PATCHING NECESSARY FOR ELECTRICAL WORK INSTALLATION UNLESS THIS WORK IS IDENTIFIED TO BE THE WORK OF OTHER CONTRACTORS. PATCHING SHALL MATCH ADJACENT SURFACES.
 - PROJECT COMPLETION
 - CLEAN FIXTURES AND EQUIPMENT AND LEAVE IN PROPER WORKING CONDITION AT THE TIME OF FINAL CLEAN-UP.
 - PROVIDE OPERATING INSTRUCTIONS AS FOLLOWS:
 - TWO (2) HOURS FOR BUILDING GENERAL ELECTRICAL SYSTEM.
 - MAINTAIN A RECORD OF OPERATING INSTRUCTION PERIODS.
 - LOCATION:
 - THE ARCHITECT SHALL RESERVE THE RIGHT TO MAKE OUTLET POSITION CHANGES UP TO 10" BEFORE INSTALLATION WITHOUT ANY ADDITIONAL COST TO PROJECT.
 - DO NOT LOCATE OUTLETS WHERE THE EQUIPMENT OR EQUIPMENT AND/OR OPERATION WILL BE AFFECTED BY THE WORK OF OTHER TRADES, DRAIN SWIRLING, COUNTER, EQUIPMENT, ETC.
 - ACCESS:
 - INSTALL EQUIPMENT, JUNCTION BOXES, PULL BOXES AND ACCESSORIES TO PERMIT ACCESS WITHOUT RELOCATING INSTALLED OR YET TO BE INSTALLED EQUIPMENT.
 - ACCESS PANELS
 - FURNISH ACCESS PANELS OF ADEQUATE SIZE TO PERMIT SERVICE OF CONCEALED DEVICES. PANELS SHALL BE SUITABLE FOR INSTALLATION IN THE MATERIAL FORMING THE FINISHED SURFACE, WITH FLUSH METAL FRAME, FLUSH HINGED SEAL DOOR, FLUSH HINGED/VER OPERATED LATCH.
 - PANELS UL LISTED TO CONFORM TO THE FIRE RATING OF THE SURFACE INSTALLED IN.
 - TURN ACCESS PANEL OVER TO CONTRACTOR SILLED IN THE CONSTRUCTION OF THE SURFACES INVOLVED FOR INSTALLATION.
 - ARCHITECT TO APPROVE ACCESS PANEL LOCATION PRIOR TO INSTALLATION OF EQUIPMENT REQUIRING ACCESS.
 - COORDINATE WITH THE OTHER CONTRACTORS AND WHEREVER PRACTICAL, GROUP DEVICES IN SUCH A MANNER SO AS TO MINIMIZE PANELS.

26 05 19 LOW VOLTAGE POWER CONDUCTORS AND CABLES (600V AND LESS)

- A. TYPE AND SIZE
- NO. 10 & 12: SOLID OR STRANDED COPPER, 600V, THHN/THWN.
 - NO. 8 TO 3: STRANDED COPPER, 600V, THHN/THWN.
 - NO. 2 TO 40: STRANDED COPPER, 600V, THHN/THWN.
 - MINIMUM BRANCH CIRCUIT WIRE SIZE NO. 12.
 - CONTROL WIRING: STRANDED COPPER, MINIMUM NO. 14.
 - GREEN INSULATION, COPPER STRANDED EQUIPMENT GROUND.
- B. NEUTRALS AND GROUNDS SHALL BE COLOR CODED PER NEC.
- C. WIRE COLORS
- 120/208-VOLT AND 120/240-VOLT SYSTEM: PHASE-A (BLACK), PHASE-B (RED), PHASE-C (BLUE).
 - 277/480-VOLTS SYSTEM: PHASE-A (BROWN), PHASE-B (ORANGE), PHASE-C (YELLOW).
- D. VOLTAGE DROP
- AT NO POINT IN THE ELECTRICAL SYSTEM SHALL THERE BE MORE THAN 5 PERCENT TOTAL VOLTAGE DROP.
 - THE CONTRACTOR SHALL APPROPRIATELY INCREASE THE SIZE OF ALL CIRCUIT CONDUCTORS TO LIMIT VOLTAGE DROP TO 2 PERCENT OR LESS FOR FEEDERS, AND 3 PERCENT OR LESS FOR BRANCH CIRCUITS.
 - VOLTAGE DROP ON BRANCH CIRCUITS FOR LIGHTING OR RECEPTABLES SHALL BE CALCULATED USING 80 PERCENT AMPLITUDE OF THE BRANCH CIRCUITS OVERCURRENT PROTECTION DEVICE.
- E. PROVIDE GROUND CONDUCTOR(S) WITH EVERY BRANCH CIRCUIT AND EVERY FEEDER.
- F. PROVIDE A SEPARATE GROUND CONDUCTOR AND A SEPARATE NEUTRAL CONDUCTOR WHEN AN INDIVIDUAL RECEPTACLE OR PIECE OF EQUIPMENT IS SHOWN WITH AN INDIVIDUAL HOMERUN.
- G. PROVIDE A SEPARATE GROUND CONDUCTOR AND SEPARATE NEUTRAL CONDUCTOR FOR EVERY SEQUENCE BRANCH CIRCUIT FED FROM A PANELBOARD WITH SEPARATE PROTECTION.
- H. PROVIDE A SEPARATE NEUTRAL CONDUCTOR FOR EACH LIGHTING BRANCH CIRCUIT THAT SERVES SOLID-STATE LED DRIVERS OR PROVIDE A NEUTRAL CONDUCTOR ONE SIZE LARGER THAN THE LARGEST SOURCE CONDUCTOR WHEN THE NEUTRAL IS SHARED.
- I. TESTING: ALL CIRCUITS SHALL BE TESTED FOR PROPER OPERATION AND FUNCTION. REPAIR ALL NON-WORKING, NEWLY INSTALLED, CIRCUITS.
- J. VERIFY LUG SIZES AND TERMINATION LOCATION PRIOR TO INSTALLING FEEDERS.

26 05 26 GROUNDING AND BONDING

- A. GROUNDING AND BONDING PRODUCTS
- GOVERNING REQUIREMENTS: WHERE TYPES, SIZES, RATINGS, AND QUANTITIES INDICATED ARE IN EXCESS OF NEC REQUIREMENTS, MORE STRINGENT REQUIREMENTS AND GREATER SIZE, RATING, AND QUANTITY INDICATIONS GOVERN.
- B. WIRE AND CABLE GROUNDING CONDUCTORS
- CONFORM TO NEC TABLE B, EXCEPT AS OTHERWISE INDICATED FOR CONDUCTOR PROPERTIES, INCLUDING STRANDING.
 - MATERIAL: COPPER.
 - EQUIPMENT GROUNDING CONDUCTORS: INSULATED WITH GREEN COLOR INSULATION.
- C. APPLICATION
- EQUIPMENT GROUNDING CONDUCTORS: COMPLY WITH NEC ARTICLE 250 FOR TYPES, SIZES, AND QUANTITIES OF EQUIPMENT GROUNDING CONDUCTORS, EXCEPT WHERE SPECIFIC TYPES, LARGER SIZES, OR MORE CONDUCTORS THAN REQUIRED BY NEC ARE INDICATED.
 - INSTALL EQUIPMENT GROUNDING CONDUCTOR WITH CIRCUIT CONDUCTORS FOR ITEMS BELOW IN ADDITION TO THOSE REQUIRED BY CODE:
 - FEEDERS AND BRANCH CIRCUITS.
 - LIGHTING CIRCUITS.
 - RECEPTACLE CIRCUITS.
 - SINGLE-PHASE MOTOR OR APPLIANCE BRANCH CIRCUITS.
 - THREE-PHASE MOTOR OR APPLIANCE BRANCH CIRCUITS.
 - SIGNAL AND COMMUNICATION SYSTEMS: FOR TELEPHONE, ALARM, VOICE AND DATA, AND OTHER COMMUNICATION SYSTEMS, PROVIDE NO. 4 AWG MINIMUM INSULATED GROUNDING CONDUCTOR IN RACEWAY FROM GROUNDING-ELECTRODE SYSTEM TO EACH SERVICE LOCATION, TERMINAL CABINET, WIRING CLOSET, AND CENTRAL EQUIPMENT LOCATION.
 - SERVICE AND CENTRAL EQUIPMENT LOCATIONS AND WIRING CLOSETS: TERMINATE GROUNDING CONDUCTOR ON 1/4 BY 8 BY 2 1/2 INCHES (6 BY 50 BY 300 MILLIMETER) GROUNDING BUS.
 - TERMINAL CABINETS: TERMINATE GROUNDING CONDUCTOR ON CABINET GROUNDING TERMINAL.
 - SEPARATELY DERIVED SYSTEMS: WHERE NEC REQUIRES GROUNDING, GROUND ACCORDING TO NEC PARAGRAPH 250.30.
 - PIPING SYSTEMS AND OTHER EQUIPMENT: COMPLY WITH NEC ARTICLE 250 FOR BONDING REQUIREMENTS.
- D. INSTALLATION
- GROUND ELECTRICAL SYSTEMS AND EQUIPMENT ACCORDING TO NEC REQUIREMENTS, EXCEPT WHERE DRAWINGS OR SPECIFICATIONS EXCEED NEC REQUIREMENTS.
- E. CONNECTIONS
- EQUIPMENT GROUNDING-WIRE TERMINATIONS: FOR NO. 8 AWG AND LARGER, USE PRESSURE-TYPE GROUNDING LUGS. NO. 10 AWG AND SMALLER GROUNDING CONDUCTORS MAY BE TERMINATED WITH WINGED PRESSURE-TYPE CONNECTORS.
 - NONCONTACT METAL RACEWAY TERMINATIONS: WHERE METALLIC RACEWAYS TERMINATE AT METAL HOUSINGS WITHOUT MECHANICAL AND ELECTRICAL CONNECTION TO HOUSING, TERMINATE EACH CONDUIT WITH A GROUNDING BUSHING. CONNECT GROUNDING BUSHINGS WITH BARE GROUNDING CONDUCTOR TO GROUNDING BUS OR TERMINAL IN HOUSING. BOND ELECTRICALLY NONCONTINUOUS CONDUITS AT BOTH ENTRANCES AND EXITS WITH GROUNDING BUSHINGS AND BARE GROUNDING CONDUCTORS, EXCEPT AS OTHERWISE INDICATED.

26 05 29 HANGERS AND SUPPORTS

- A. CONDUIT HANGERS, ATTACHMENTS, AND SUPPORTS
- PROVIDE PROPER FITTINGS AND SUPPORT SUITABLE FOR AMBIENT/ENVIRONMENTAL CONDITIONS AND SERVICE DUTY.
 - ATTACH TO STRUCTURAL COMPONENTS TO NOT JEOPARDIZE STRUCTURAL INTEGRITY.
 - PROVIDE ANGLES, CHANNELS, AND BEAMS AS REQUIRED.

26 05 30 CONDUIT

- A. RMC
- ALLOWED FOR ALL SIZES BELOW GRADE AND INSIDE ABOVE GRADE.
 - REQUIRED WHERE CALLED OUT ON PLANS.
 - REQUIRED FOR ALL SIZES OF OUTDOOR ABOVE GRADE CONDUIT.
 - GALVANIZED RIGID STEEL REQUIRED FOR ALL INSIDE ABOVE GRADE DEGREE BENDS.
 - GALVANIZED RIGID STEEL WITH GALVANIZED RIGID STEEL FITTINGS, THREADED WATERIGHT.
- B. IMC
- ALLOWED FOR ALL AREAS OF THE PLANT OTHER THAN PROCESS AREAS AND WASHDOWN AREAS.
- C. EMT
- ALLOWED FOR INSIDE ABOVE GRADE CONDUIT 2" AND SMALLER.
 - COMPRESSION TYPE FITTINGS WITH INSULATED THROAT.
 - CAST METAL SET SCREW FITTINGS NOT ALLOWED.
- D. FLEXIBLE
- MINIMUM SIZE 1/2".
 - MAXIMUM LENGTH: 10' FOR CONNECTION TO HVAC EQUIPMENT.
 - MAXIMUM LENGTH 72" FOR CONNECTION TO FIXTURES IN TILE CEILING.
 - STEEL FITTINGS WITH INSULATED THROAT, UL LISTED.
- E. FITTINGS
- FITTING MATERIAL SHALL MATCH CONDUIT MATERIAL UNLESS OTHERWISE NOTED IN PLANS AND SPECIFICATIONS OR WITH WRITTEN APPROVAL BY ENGINEER.
- F. INSTALLATION
- DRAWINGS AND DIAGRAMS SHOW SIZE AND APPROXIMATE LOCATION OF CONDUIT. THE DRAWINGS ARE DIAGRAMMATIC AND SHALL NOT BE SCALED TO DETERMINE EXACT LOCATION. PROVIDE ADDITIONAL OFFSETS AS REQUIRED FOR FIELD CONDITIONS. ROUTE CONDUIT IN ORDERLY MANNER, PARALLEL TO BUILDING STRUCTURE.
 - INSTALL UL APPROVED EXPANSION FITTINGS COMPLETE WITH GROUNDING JUMPERS WHERE CONDUITS CROSS BUILDINGS EXPANSION JOINTS AND IN LONG CONDUIT RUNS WHERE DIFFERENTIAL EXPANSION OR CONTRACTION WOULD CAUSE BENDING OR SEPARATION.
 - COMPLY WITH MANUFACTURERS PUBLISHED STANDARDS.
 - INSTALL NO MORE THAN EQUIVALENT OF THREE 90-DEGREE BENDS IN CONDUIT RUN. SUPPORT WITHIN TWELVE INCHES OF ANY CHANGE IN DIRECTION.
 - INSTALL CONDUIT CONCEALED IN EXISTING AND NEW STUD WALLS AND NEW MASONRY WALLS.
 - SURFACE MOUNT CONDUIT ON FLUSH OR SURFACE MOUNTED CABINETS AS INDICATED. NEMA 250, TYPE 1, UNLESS OTHERWISE INDICATED TO COMPLY WITH ENVIRONMENTAL CONDITIONS AT INSTALLED LOCATION.
 - INSTALL CONDUIT WITH ADEQUATE DRAINAGE.
 - PROVIDE PULL STRING IN ALL EXISTING CONDUITS.
 - WHEN REQUIRED BY STATE AND LOCAL CODES AND ORDINANCES, PROVIDE SEPARATE CONDUIT/RACEWAY FOR FIRE ALARM, EMERGENCY STAND-BY, REQUIRED STAND-BY, TELECOMMUNICATION SYSTEMS.
 - ROUTE CONDUIT ABOVE LAV-IN SUSPENDED CEILING SO AS NOT TO INTERFERE WITH TILE REMOVAL.
 - INSTALL FLEXIBLE STEEL CONDUIT DROPS FROM INDEPENDENT JUNCTION BOX MOUNTED ABOVE CEILING TO RECESSED LIGHT FIXTURES.
 - SECURE CONDUITS WITH AT LEAST ONE CORROSION PROOF MALLEABLE ALLOY STRAP OR HANGER EVERY 8 FT.
 - DO NOT USE REVERSE BENDING AND TIGHTENING.
 - PROVIDE UL LISTED FIRE-WALL PENETRATIONS WHEN CONDUIT PASS THROUGH A FIRE RATED WALL.

26 05 33 BOXES

- A. FLUSH INTERIOR 4" SQUARE STEEL BOXES WITH RAISED COVERS AND SQUARE CUT CORNERS. PROVIDE BOXES RATED FOR THROUGH FEED.
- B. PROVIDE CAST BOXES FOR EXTERIOR USE DEVICES. PROVIDE COVERS WITH GASKETS.
- C. JUNCTION AND SPINDLES FOR EXTERIOR USE DEVICES SHALL BE RATED FOR THROUGH FEEDS AND BE NOT LESS THAN CODE DIMENSIONS. THROUGH WALL AND BACK-TO-BACK BOXES NOT ALLOWED.
- D. OUTLET AND JUNCTION BOXES USED AS SURFACE METAL RACEWAY SHALL BE MANUFACTURED BY THE SURFACE METAL RACEWAY MANUFACTURER TO BE COMPATIBLE WITH THE RACEWAY USED.
- E. VERIFY LOCATION PRIOR TO ROUGH-IN. MATCH THE HEIGHT OF EXISTING DEVICES FOR INSTALLATIONS IN ADDITIONS TO EXISTING FACILITIES.
- F. TESTING
- TEST INSULATION RESISTANCE FOR EACH ENCLOSED CONTROLLER BUS, COMPONENT, CONNECTING SUPPLY, FEEDER, AND CONTROL CIRCUIT.
 - TEST CONTINUITY OF EACH CIRCUIT.
 - PERFORM ELECTRICAL TESTS AND VISUAL AND MECHANICAL INSPECTIONS.
 - CERTIFY COMPLIANCE WITH TEST PARAMETERS RECOMMENDED BY MANUFACTURER.
 - CORRECT MALFUNCTIONING UNITS ON-SITE WHERE POSSIBLE, AND RETEST TO DEMONSTRATE COMPLIANCE. OTHERWISE, REPLACE WITH NEW UNITS AND RETEST.
 - SET FIELD ADJUSTABLE SWITCHES AND CIRCUIT BREAKER TRIP RANGES.
 - MANUAL ENCLOSED CONTROLLERS: NEMA ICS 2, GENERAL PURPOSE, CLASS A, WITH TOGGLE ACTION AND OVERLOAD ELEMENT.
 - MAGNETIC ENCLOSED CONTROLLERS: NEMA ICS 2, CLASS A, FULL VOLTAGE, NON-REVERSING, ACROSS THE LINE, UNLESS OTHERWISE INDICATED.
 - CONTROL CIRCUIT: 120 V, OBTAINED FROM INTEGRAL CONTROL POWER TRANSFORMER.
 - COMBINATION CONTROLLER, FACTORY ASSEMBLED CONTROLLER AND DISCONNECT SWITCH.
 - FUSIBLE DISCONNECT: NEMA KS 1, HEAVY-DUTY, FUSIBLE SWITCH WITH REACTION-TYPE FUSE CLIPS RATED FOR FUSES. SELECT AND SIZE FUSES TO PROVIDE TYPE 2 PROTECTION.
 - NONFUSIBLE DISCONNECT: NEMA KS 1, HEAVY-DUTY, NONFUSIBLE SWITCH.
 - ADJUSTABLE OVERLOAD RELAY: DIP SWITCH SELECTABLE FOR MOTOR RUNNING OVERLOAD PROTECTION AND SELECTED TO PROTECT MOTOR AGAINST VOLTAGE AND CURRENT UNBALANCE AND SINGLE PHASING. PROVIDE RELAY WITH CLASS II GROUND-FAULT PROTECTION, WITH START AND RUN DELAYS TO PREVENT NUISANCE TRIP ON STARTING.
- G. VARIABLE FREQUENCY DRIVES (VFD)
- MANUFACTURER: YASKAWA
 - GA-800 SERIES DRIVE - HEAVY DUTY.
 - FOR ALL MOTORS 2HP AND BELOW, PROVIDE 2HP RATED DRIVE.
 - PROVIDE INPUT LINE FILTERS FOR ALL VARIABLE FREQUENCY DRIVES PROVIDED.
 - MOUNT VARIABLE FREQUENCY DRIVE AND FILTER TO WALL WHERE INDICATED IN PLANS.
 - AUX CONTACTS: PROVIDE FOR CONNECTION TO LOCAL MOTOR DISCONNECTS SO DRIVE WILL NOT FUNCTION WHILE LOCAL DISCONNECT IS IN "OFF" POSITION.
 - SAFETY INTERLOCKS: PROVIDE TERMINALS FOR REMOTE CONTACT TO INHIBIT STARTING UNDER BOTH MANUAL AND AUTOMATIC MODE.
 - CONTROL INTERLOCKS: PROVIDE TERMINALS FOR REMOTE CONTACT TO ALLOW STARTING IN AUTOMATIC MODE.
 - PROVIDE DOOR MOUNTED WIRELESS REMOVABLE HUMAN INTERFACE MODULE WITH FULL NUMERIC KEY PAD WHEN VFD IS MOUNTED IN A MCC.
 - VERIFY EXACT LOCATION OF VFD WITH OWNER PRIOR TO ROUGH-IN.

26 05 53 IDENTIFICATION FOR ELECTRICAL SYSTEMS

- A. ENGRAVED LABELS: ENGRAVED 3-LAYER PHENOLIC LABEL WITH BLACK LETTERS ON WHITE MATERIAL. UNLESS OTHER COLORS ARE CALLED OUT IN THE DRAWINGS OR DETAILS, LABELS MINIMUM 3/4" HIGH AND 3" LONG. LABELS MAY BE ATTACHED WITH DOUBLE BACKED ADHESIVE TAPE UNLESS INDICATED OTHERWISE. LABELS REQUIRED AT:
- DISCONNECTS.
 - LABEL EQUIPMENT THAT IT SERVES.
 - "FED FROM" LABEL.
- B. PROVIDE TYPEWRITTEN DIRECTORY ACCURATELY INDICATING ROOMS AND/OR EQUIPMENT BEING SERVED AT THE FOLLOWING LOCATIONS:
- PANELBOARDS.
 - PROVIDE TYPEWRITTEN DIRECTORY ELECTRONICALLY TO THE OWNER IN A FORMAT ACCEPTABLE TO THE OWNER.
- C. PROVIDE TYPE-WRITTEN LABEL WITH 1/8" BLACK LETTERING ON CLEAR MATERIAL INDICATING CIRCUIT AND PANEL THAT THE DEVICE IS FED FROM FOR ALL RECEPTABLES AND SWITCHES.
- D. PROVIDE ALL CODE REQUIRED LABELS. EXAMPLES OF CODE REQUIRED LABELS, BUT ARE NOT LIMITED TO, ARE THE 2021 NEC ARTICLE 110 AND FOR BUILDINGS WITH MULTIPLE SECTIONS ARTICLE 230.2 (E).

26 27 22 WIRING DEVICES

- A. MANUFACTURERS: COOPER, HUBBELL, LEVITON AND PASS & SEYMOUR.
- B. COLOR
- SWITCH AND RECEPTACLE COLORS SHALL "MATCH EXISTING".
 - COVER PLATE COLORS SHALL "MATCH EXISTING".
- C. WALL SWITCHES:
- 20-AMPERE HUBBELL 1221 SINGLE POLE, 1223 THREE-WAY AND 1224 FOUR-WAY.
 - SEE LEGEND FOR MOUNTING HEIGHTS.
 - PROVIDE PILOT LIGHT SWITCHES WHERE INDICATED.
- D. RECEPTABLES
- DUPLEX GROUNDING RECEPTABLES, 20 AMPERE SPECIFICATION GRADE, HUBBELL 5362.
 - GFCI RECEPTABLES: 20-AMPERE HUBBELL SPECIFICATION GRADE WITH LOCK OUT CAPABILITY UPON GFCI FAILURE.
 - EXTERIOR RECEPTABLES SHALL BE MARKED "WEATHER-RESISTANT" PER NEC.
 - SEE LEGEND FOR MOUNTING HEIGHTS.
 - REVIEW RECEPTACLE LAYOUT WITH OWNER PRIOR TO ROUGH-IN.
 - VERIFY ACTUAL LOCATION OF EQUIPMENT WITH OWNER PRIOR TO ROUGH-IN.
 - THAT THE DEVICE IS FED FROM FOR ALL RECEPTABLES AND SWITCHES.
- E. COVER PLATES
- INTERIOR: SMOOTH NYLON MATERIAL.
 - MECHANICAL EQUIPMENT ROOM: STEEL.
 - DRY LOCATION INDUSTRIAL SPACES: STEEL.
 - EXTERIOR: WEATHER-PROOF, GASKETED, LIFT COVER. RECEPTACLE COVER SHALL ALLOW CONTINUOUS USE WHEN COVER IS CLOSED.

26 27 27 OCCUPANCY SENSORS / VACANCY SENSORS

- A. MANUFACTURERS: COOPER, HUBBELL, LEVITON, SENSOR SWITCH, & THE WATT STOPPER.
- COLOR:
 - WALL MOUNTED SENSORS SHALL BE THE SAME COLOR AS WIRING DEVICES. REFERENCE SPECIFICATION SECTION 26 27 26.
 - CEILING MOUNTED SENSORS SHALL MATCH COLOR OF CEILING THEY'RE INSTALLED ON.
 - SHALL BE FROM THE SAME MANUFACTURER AS THE WIRING DEVICES.
- B. SENSOR TECHNOLOGY
- PASSIVE INFRARED (PIR).
 - DUAL TECHNOLOGY (PASSIVE INFRARED & ULTRASONIC)
 - OTHER SPACES
- C. SENSOR PERFORMANCE
- INFRARED:
 - UTILIZE MULTIPLE SEGMENTED LENS, WITH INTERNAL GROOVES TO ELIMINATE DUST AND RESIDUE BUILD-UP.
 - ULTRASONIC:
 - UTILIZE AN OPERATING FREQUENCY OF 32 KHZ OR 40 KHZ THAT SHALL BE CRYSTAL CONTROLLED TO OPERATE WITHIN PLUS OR MINUS 0.005% TOLERANCE. UTILIZE DOPPLER SHIFT ULTRASONIC DETECTION TECHNOLOGY.
 - DUAL TECHNOLOGY:
 - UTILIZE MULTIPLE SEGMENTED LENS, WITH INTERNAL GROOVES TO ELIMINATE DUST AND RESIDUE BUILD-UP.
 - UTILIZE AN OPERATING FREQUENCY OF 32 KHZ OR 40 KHZ THAT SHALL BE CRYSTAL CONTROLLED TO OPERATE WITHIN PLUS OR MINUS 0.005% TOLERANCE.
 - INCORPORATE DOPPLER SHIFT ULTRASONIC AND PASSIVE INFRARED MOTION DETECTION TECHNOLOGIES. PRODUCTS THAT REACT TO NOISE OR AMBIENT SOUND SHALL NOT BE CONSIDERED.
 - SENSOR DEVICES SHALL HAVE EITHER INTEGRAL DUAL RELAYS OR CONTROL SEPARATE DUAL RELAY POWER PACKS TO ACHIEVE DUAL LEVEL LIGHTING WHEN DUAL LEVEL CONTROL IS INDICATED.
 - INTERVAL ADJUSTABLE LIGHT LEVEL SENSOR WITH CAPACITY TO CONTROL ONE OR MORE RELAY WHEN THE SELECTED ADEQUATE DAYLIGHT IS PRESENT.
 - UTILIZE ZERO CROSSING CIRCUITRY WHICH INCREASES RELAY LIFE AND SENSORS LONGEVITY.
 - SHOULD POWER BE INTERRUPTED AND SUBSEQUENTLY RESTORED, SETTINGS AND PARAMETERS SAVED IN PROTECTED MEMORY SHALL NOT BE LOST.
 - SENSORS SHALL BE SIZED FOR THE ROOM THEY SERVE BY MANUFACTURER'S VENDOR OR COVER 1,500 SQUARE FEET WITH STANDARD LENS AND UP TO 30 LINEAR FEET WITH LONG RANGE LENS FOR WALKING MOTION WHEN MOUNTED AT A CEILING HEIGHT OF 12 FEET.
 - INDEPENDENT SENSITIVITY ADJUSTMENTS AND LED DISPLAY FOR EACH SENSING TECHNOLOGY.
 - SENSOR SHALL HAVE STANDARD 5 YEAR WARRANTY AND BE UL LISTED.
- D. CONTROL STRATEGIES
- AUTOMATIC CONTROLS SHALL BE MANUAL ON, OR SHALL TURN ON NOT MORE THAN 50% OF THE OF THE CONTROL LAMPS WITH THE REMAINING LAMPS BEING CONTROLLED MANUALLY.
 - EXCEPTION: PUBLIC CORRIDORS, STARWAYS, RESTROOMS, PRIMARY ENTRANCES AND LOBBIES SHALL HAVE FULL ON AUTOMATIC CONTROLS.
 - AUTOMATIC CONTROLS SHALL TURN LIGHTS OFF WITHIN 20 MINUTES OF ALL OCCUPANTS LEAVING THE SPACE.
 - REFRIGERATOR TIME DELAY: ONLY ONE MOTION IS NECESSARY TO TURN ON THE LIGHTS WITHIN 5 SECONDS AFTER TURNING OFF.
 - E.C. SHALL INCLUDE TIME IN HIS BID TO WORK WITH THE OWNER AND MANUFACTURER TO DETERMINE THE PROPER TIME AND SENSOR SETTINGS FOR EACH SENSOR IN THE SPACES IN WHICH THEY OPERATE. INCLUDE TIME REQUIRED TO HAVE THE MANUFACTURER'S REPRESENTATIVE ON SITE AND REVIEW THE JOB TO DETERMINE WHAT THE EXPECTED EQUIPMENT SETTINGS SHOULD BE.

26 28 16 ENCLOSED DISCONNECT SWITCHES

- A. ELECTRICAL COMPONENTS, DEVICES, AND ACCESSORIES: LISTED AND LABELED AS DEFINED IN NFPA 70, ARTICLE 100, BY A TESTING AGENCY ACCEPTABLE TO AUTHORITIES HAVING JURISDICTION, AND MARKED FOR INTENDED USE.
- B. NONFUSIBLE SWITCH: TYPE GD WITH LOCKABLE HANDLE.
- C. FUSIBLE SWITCH: TYPE HD WITH CLIPS TO ACCOMMODATE FUSES. HANDLE LOCKABLE IN OPEN AND CLOSED POSITION. HANDLE INTERLOCKED WITH COVER IN CLOSED POSITION WITH INTERLOCK SPRINGS.
- D. ENCLOSURES: NEMA AB 1 AND NEMA KS 1 TO MEET ENVIRONMENTAL CONDITIONS OF INSTALLED LOCATION.
- OUTDOOR LOCATIONS: NEMA 250 TYPE 3R.
 - KITCHEN AREAS: NEMA 250 TYPE 4X, STAINLESS STEEL.
 - OTHER WET OR DAMP INDOOR LOCATIONS: NEMA 250 TYPE 4.
 - HAZARDOUS AREAS INDICATED ON DRAWINGS: NEMA 250 TYPE 7C.
- E. MANUFACTURER'S STANDARD PRIME-COAT FINISH READY FOR FIELD PAINTING.
- F. LABEL EACH ENCLOSURE WITH ENGRAVED METAL OR LAMINATED PLASTIC NAMEPLATE MOUNTED WITH CORROSION-RESISTANT SCREWS.
- G. INSTALL EQUIPMENT GROUNDING CONNECTIONS FOR SWITCHES AND CIRCUIT BREAKERS WITH GROUND CONTINUITY TO MAIN ELECTRICAL GROUND BUS.
- H. DEMONSTRATE PRODUCT CAPABILITY AND COMPLIANCE WITH REQUIREMENTS AFTER INSTALLATION AND AFTER ELECTRICAL CIRCUITRY HAS BEEN ENERGIZED.
- PERFORM VISUAL AND MECHANICAL INSPECTION AND ELECTRICAL TEST. CERTIFY COMPLIANCE WITH TEST PARAMETERS.
 - CORRECT MALFUNCTIONING UNITS, ON-SITE WHERE POSSIBLE, AND RETEST TO DEMONSTRATE COMPLIANCE.
- I. FOR MOTORS THAT ARE FED WITH VARIABLE FREQUENCY DRIVES PROVIDE DISCONNECTS WITH AUXILIARY CONTACTS AS PART OF THE DISCONNECT FOR SADM MOTORS.
- PROVIDE TWO CONTROL CONDUCTORS FROM THE AUXILIARY CONTACT IN THE DISCONNECT TO LOCAL I/O CABINET IN PROCESS ROOM (FOR PROCESS MOTORS) AND /FOR NON-PROCESS MOTORS ROUTE AUX CONTACTS BACK TO VARIABLE FREQUENCY DRIVE'S CONTACTS. CONTACT TO INFORM THE VARIABLE FREQUENCY DRIVE THAT DISCONNECT HAS BEEN OPENED.
 - PROVIDE RACEWAY FOR THE CONTROL CONDUCTORS THAT COMPLIES WITH THESE SPECIFICATIONS.

26 29 13 MOTOR CONTROLLERS

- A. MANUFACTURERS: ALLEN BRADLEY, CUTLER HAMMER SQUARE D. ALL STARTERS SHALL BE FROM THE SAME MANUFACTURER. (SAME AS THE MOTOR CONTROL CENTER MANUFACTURER).
- B. ELECTRICAL COMPONENTS, DEVICES, AND ACCESSORIES: LISTED AND LABELED AS DEFINED IN NFPA 70, ARTICLE 100, BY A TESTING AGENCY ACCEPTABLE TO AUTHORITIES HAVING JURISDICTION, AND MARKED FOR INTENDED USE.
- C. COORDINATE FEATURES OF ENCLOSED CONTROLLERS AND ACCESSORY DEVICES WITH PILOT DEVICES AND CONTROL CIRCUITS TO WHICH THEY CONNECT. COORDINATE FEATURES, ACCESSORIES, AND FUNCTIONS OF EACH ENCLOSED CONTROLLER WITH RATINGS AND CHARACTERISTICS OF SUPPLY CIRCUIT, MOTOR, REQUIRED CONTROL SEQUENCE, AND CYCLE OF MOTOR AND LOAD.
- D. SELECT HORSPOWER RATING OF CONTROLLERS TO SUIT MOTOR CONTROLLED.
- E. SURFACE MOUNT CONSOLE OR SURFACE MOUNTED CABINETS AS INDICATED. NEMA 250, TYPE 1, UNLESS OTHERWISE INDICATED TO COMPLY WITH ENVIRONMENTAL CONDITIONS AT INSTALLED LOCATION.
- OUTDOOR LOCATIONS: NEMA 250, TYPE 3R.
 - OTHER WET OR DAMP INDOOR LOCATIONS: NEMA 250, TYPE 4.
- F. FACTORY FINISH:
- MANUFACTURER'S STANDARD PRIME COAT FINISH READY FOR FIELD PAINTING.
 - MANUFACTURER'S STANDARD PAINT APPLIED TO FACTORY-ASSEMBLED AND -TESTED ENCLOSED CONTROLLERS BEFORE SHIPPING.
- G. BOLT UNITS TO WALL OR MOUNT ON STEEL CHANNELS BOLTED TO WALL.
- H. INSTALL A FULL SET OF WIRING IN EACH FUSIBLE SWITCH.
- DO NOT USE REVERSE BENDING AND TIGHTENING.
 - PROVIDE UL LISTED FIRE-WALL PENETRATIONS WHEN CONDUIT PASS THROUGH A FIRE RATED WALL.
- I. INSTALL PER MANUFACTURER'S INSTALLATION INSTRUCTIONS.
- K. CONNECT HAND-OFF AUTOMATIC SWITCH AND OTHER AUTOMATIC CONTROL DEVICES WHERE APPLICABLE.
- CONNECT SELECTOR SWITCHES TO BYPASS ONLY MANUAL- AND AUTOMATIC- CONTROL DEVICES THAT HAVE NO SAFETY FUNCTIONS WHEN SWITCH IS IN HAND POSITION.
 - CONNECT SELECTOR SWITCHES WITH ENCLOSED CONTROLLER CIRCUIT IN BOTH HAND AND AUTOMATIC POSITIONS FOR SAFETY-TYPE CONTROL DEVICES SUCH AS LOW- AND HIGH-PRESSURE CUTOUTS, HIGH-TEMPERATURE CUTOUTS, AND MOTOR OVERLOAD PROTECTORS.

- L. TESTING
- TEST INSULATION RESISTANCE FOR EACH ENCLOSED CONTROLLER BUS, COMPONENT, CONNECTING SUPPLY, FEEDER, AND CONTROL CIRCUIT.
 - TEST CONTINUITY OF EACH CIRCUIT.
 - PERFORM ELECTRICAL TESTS AND VISUAL AND MECHANICAL INSPECTIONS.
 - CERTIFY COMPLIANCE WITH TEST PARAMETERS RECOMMENDED BY MANUFACTURER.
 - CORRECT MALFUNCTIONING UNITS ON-SITE WHERE POSSIBLE, AND RETEST TO DEMONSTRATE COMPLIANCE. OTHERWISE, REPLACE WITH NEW UNITS AND RETEST.
 - SET FIELD ADJUSTABLE SWITCHES AND CIRCUIT BREAKER TRIP RANGES.
 - MANUAL ENCLOSED CONTROLLERS: NEMA ICS 2, GENERAL PURPOSE, CLASS A, WITH TOGGLE ACTION AND OVERLOAD ELEMENT.
 - MAGNETIC ENCLOSED CONTROLLERS: NEMA ICS 2, CLASS A, FULL VOLTAGE, NON-REVERSING, ACROSS THE LINE, UNLESS OTHERWISE INDICATED.
 - CONTROL CIRCUIT: 120 V, OBTAINED FROM INTEGRAL CONTROL POWER TRANSFORMER.
 - COMBINATION CONTROLLER, FACTORY ASSEMBLED CONTROLLER AND DISCONNECT SWITCH.
 - FUSIBLE DISCONNECT: NEMA KS 1, HEAVY-DUTY, FUSIBLE SWITCH WITH REACTION-TYPE FUSE CLIPS RATED FOR FUSES. SELECT AND SIZE FUSES TO PROVIDE TYPE 2 PROTECTION.
 - NONFUSIBLE DISCONNECT: NEMA KS 1, HEAVY-DUTY, NONFUSIBLE SWITCH.
 - ADJUSTABLE OVERLOAD RELAY: DIP SWITCH SELECTABLE FOR MOTOR RUNNING OVERLOAD PROTECTION AND SELECTED TO PROTECT MOTOR AGAINST VOLTAGE AND CURRENT UNBALANCE AND SINGLE PHASING. PROVIDE RELAY WITH CLASS II GROUND-FAULT PROTECTION, WITH START AND RUN DELAYS TO PREVENT NUISANCE TRIP ON STARTING.
- M. SET FIELD ADJUSTABLE SWITCHES AND CIRCUIT BREAKER TRIP RANGES.
- N. MANUAL ENCLOSED CONTROLLERS: NEMA ICS 2, GENERAL PURPOSE, CLASS A, WITH TOGGLE ACTION AND OVERLOAD ELEMENT.
- O. MAGNETIC ENCLOSED CONTROLLERS: NEMA ICS 2, CLASS A, FULL VOLTAGE, NON-REVERSING, ACROSS THE LINE, UNLESS OTHERWISE INDICATED.
- P. CONTROL CIRCUIT: 120 V, OBTAINED FROM INTEGRAL CONTROL POWER TRANSFORMER.
- Q. COMBINATION CONTROLLER, FACTORY ASSEMBLED CONTROLLER AND DISCONNECT SWITCH.
- R. FUSIBLE DISCONNECT: NEMA KS 1, HEAVY-DUTY, FUSIBLE SWITCH WITH REACTION-TYPE FUSE CLIPS RATED FOR FUSES. SELECT AND SIZE FUSES TO PROVIDE TYPE 2 PROTECTION.
- S. NONFUSIBLE DISCONNECT: NEMA KS 1, HEAVY-DUTY, NONFUSIBLE SWITCH.
- T. ADJUSTABLE OVERLOAD RELAY: DIP SWITCH SELECTABLE FOR MOTOR RUNNING OVERLOAD PROTECTION AND SELECTED TO PROTECT MOTOR AGAINST VOLTAGE AND CURRENT UNBALANCE AND SINGLE PHASING. PROVIDE RELAY WITH CLASS II GROUND-FAULT PROTECTION, WITH START AND RUN DELAYS TO PREVENT NUISANCE TRIP ON STARTING.

- Q. VARIABLE FREQUENCY DRIVES (VFD)
- MANUFACTURER: YASKAWA
 - GA-800 SERIES DRIVE - HEAVY DUTY.
 - FOR ALL MOTORS 2HP AND BELOW, PROVIDE 2HP RATED DRIVE.
 - PROVIDE INPUT LINE FILTERS FOR ALL VARIABLE FREQUENCY DRIVES PROVIDED.
 - MOUNT VARIABLE FREQUENCY DRIVE AND FILTER TO WALL WHERE INDICATED IN PLANS.
 - AUX CONTACTS: PROVIDE FOR CONNECTION TO LOCAL MOTOR DISCONNECTS SO DRIVE WILL NOT FUNCTION WHILE LOCAL DISCONNECT IS IN "OFF" POSITION.
 - SAFETY INTERLOCKS: PROVIDE TERMINALS FOR REMOTE CONTACT TO INHIBIT STARTING UNDER BOTH MANUAL AND AUTOMATIC MODE.
 - CONTROL INTERLOCKS: PROVIDE TERMINALS FOR REMOTE CONTACT TO ALLOW STARTING IN AUTOMATIC MODE.
 - PROVIDE DOOR MOUNTED WIRELESS REMOVABLE HUMAN INTERFACE MODULE WITH FULL NUMERIC KEY PAD WHEN VFD IS MOUNTED IN A MCC.
 - VERIFY EXACT LOCATION OF VFD WITH OWNER PRIOR TO ROUGH-IN.

26 29 23 FEEDERS FROM VARIABLE FREQUENCY DRIVES TO MOTORS

- A. SHIELDED CABLE IN CONDUIT
- PROVIDE ONLY STEEL OR ALUMINUM CONDUIT. BOND CONDUIT TO VARIABLE FREQUENCY DRIVE GROUND.
 - PROVIDE A SEPARATE CONDUCTOR CABLE FOR EACH MOTOR CIRCUIT.
 - TRINED COPPER STRANDED FLEXIBLE CONDUCTOR UL RATED 1000-VOLT AC, 2000-VOLTS AC PEAK, TEMPERATURE RANGE -25 TO 90 DEGREE CELSIUS, 100 PERCENT FOUL-SHIELD AND 85 PERCENT TINNED COPPER BRAID AND DRAIN WIRE. PVC EXTERIOR JACKET.
 - CABLE SHALL BE APPROVED FOR USE WITH SOLID STATE VARIABLE FREQUENCY DRIVES.
 - CABLE BENDING RADIUS SHALL NOT EXCEED TWELVE TIMES THE CABLE DIAMETER.
 - PROVIDE GROUNDING BOND OF THE SHIELDS ONLY AT THE VARIABLE FREQUENCY DRIVE GROUND AND THE MOTOR HOUSING. BONDING SHIELDS AT THE MOTOR DISCONNECT IS PROHIBITED.

LEGEND

NOTE: ALL SYMBOLS SHOWN MAY NOT APPEAR ON DRAWINGS. ALL MOUNTING HEIGHTS ARE TYPICAL UNLESS NOTED OTHERWISE.

SYMBOL	IDENTIFICATION	SYMBOL	IDENTIFICATION
	RECESSED, SURFACE, OR PENDANT MOUNTED LIGHT FIXTURE		EMERGENCY LIGHT MOUNT 11" 0" AFF. TO TOP OR 8" BELOW CEILING, WHICHEVER IS LOWER
	WALL MOUNTED LIGHT FIXTURE		RECESSED EMERGENCY LIGHT
	MOUNT 7'-37" AFF. OR 8" ABOVE MIRROR		EXIT LIGHT
	RECESSED, SURFACE MOUNTED, OR CHAIN HUNG LIGHT FIXTURE		OCCUPANCY SENSOR
	PENDANT FIXTURE		WALL MOUNTED OCCUPANCY SENSOR WITH SWITCH
	EXTERIOR WALL MOUNTED OR INTERIOR WALL WASH FIXTURE		D = DIMMER
	SINGLE HEAD POLE		DUAL LEVEL/CIRCUIT OCCUPANCY SENSOR WITH SWITCH
	TWIN HEAD POLE MOUNTED FIXTURE		PHOTO CONTROL
	SINGLE POLE SWITCH, MOUNT 46" AFF. TO CENTER, 3 = 3 WAY, 4 = 4 WAY, P = PILOT, D = DIMMER, K = KEAY		DUPLEX RECEPTACLE, MOUNT IN CABINET BEHIND MICROWAVE, FIELD VERIFY HEIGHT
	DUAL LEVEL SWITCH, MOUNT 46" AFF. TO CENTER, SEE DETAIL		POWER RECEPTACLE, MOUNT 18" AFF. TO CENTER
	LOW VOLTAGE SWITCH, MOUNT 46" AFF. TO CENTER		SWITCH BOTTOM HALF OF RECEPTACLE TOP HALF UNWITCHED
	SIMPLEX RECEPTACLE, MOUNT 18" AFF. TO CENTER		SPECIAL OUTLET
	DUPLEX RECEPTACLE, MOUNT 18" AFF. TO CENTER		JUNCTION BOX
	DOUBLE DUPLEX RECEPTACLE, MOUNT 18" AFF. TO CENTER		SWITCH BOTTOM HALF OF GFI RECEPTACLE TOP HALF UNWITCHED
	GFI DUPLEX RECEPTACLE, MOUNT 18" AFF. TO CENTER		DUPLEX RECEPTACLE SURFACE MOUNTED CLG = CEILING/SOFT/IT MOUNTED
	GFI DOUBLE DUPLEX RECEPTACLE, MOUNT 18" AFF. TO CENTER		BLANK BOX 4" EXTRA DEEP BOX, SINGLE GANG RING, BLANKPLATE, 1" C STUB INTO ACCESSIBLE SPACE, MOUNT 18" AFF. TO CENTER
	DUPLEX RECEPTACLE MOUNT VERTICALLY 6" ABOVE BACKSPASH TO CENTER. IF NO BACKSPASH MOUNT 6" ABOVE COUNTER		ABOVE COUNTER BLANK BOX 4" EXTRA DEEP BOX, SINGLE GANG RING, BLANKPLATE, 1" C STUBBED INTO ACCESSIBLE SPACE, MOUNT 6" ABOVE BACKSPASH TO CENTER
	DUPLEX RECEPTACLE MOUNT VERTICALLY 6" ABOVE BACKSPASH TO CENTER. IF NO BACKSPASH MOUNT 6" ABOVE COUNTER		COMBINATION FLOOR OUTLET/BLANK JUNCTION BOX - WIREBOLTS - RESOLUBLE SPRING OR EQUIVALENT, 1" C STUB INTO ACCESSIBLE SPACE
	DISCONNECT, FURNISHED BY EC F = FUSIBLE		MANUAL STARTER
	NON-COMBINATION STARTER		MOTOR CONNECTION
	COMBINATION STARTER		MOTOR CONNECTION REQUIRING REMOTE STARTER/VFD
	SURFACE MOUNTED PANELBOARD		EQUIPMENT CONNECTION

ELECTRICAL SPECIFICATIONS (CONT.)

DIVISION 27 COMMUNICATIONS

27 05 00 BASIC COMMUNICATION REQUIREMENTS

- A. SEE DIVISION 00 PROCUREMENT AND CONTRACTING AND DIVISION 01 GENERAL REQUIREMENT FOR ADDITIONAL REQUIREMENTS.
- B. SUBSTITUTIONS
- SEE DIVISION 01 25 00 PRODUCT SUBSTITUTION PROCEDURES FOR ADDITIONAL REQUIREMENTS.
 - CONTRACTOR SHALL PROVIDE ALL SUPPORTING DATA AND ASSUME THE BURDEN OF PROOF THAT ANY SUBSTITUTE IS EQUIVALENT AS TO APPEARANCE, CONSTRUCTION, CAPACITY, AND PERFORMANCE. THE JUDGMENT OF EQUIVALENCY SHALL BE MADE BY THE ENGINEER AT THE TIME OF SHOP DRAWING REVIEW, NOT DURING BIDDING.
 - WHERE SUBSTITUTE EQUIPMENT REQUIRES REDESIGN OF ANY PART OF THE PROJECT, THE COST OF REDESIGN AND ADDITIONAL COSTS OF THE WORK SHALL BE PAID BY THE CONTRACTOR. REDESIGN SHALL BE SUBJECT TO THE APPROVAL OF ALL AUTHORITIES HAVING JURISDICTION OVER THE WORK INCLUDING THE ARCHITECT/ENGINEER.
- C. GENERAL REQUIREMENTS
- OWNER FURNISHED EQUIPMENT: CONTRACTOR SHALL ENSURE COMPLIANCE WITH THE SECTION SPECIFICATION AND NOTIFY OWNER IF EQUIPMENT IS INSUFFICIENT OR WILL NOT ALLOW COMPLIANCE.
 - CORPORATE NETWORK CONNECTIONS.
 - THE CORPORATE NETWORK UTILIZES A FIBER OPTIC BACKBONE BETWEEN MDF AND IDF ROOMS. INSTALLED NETWORK DEVICES SHALL HAVE THE PROPER CONVERTERS OR COORDINATE THE FURNISHING OF REQUIRED INFRASTRUCTURE WITH IT DEPARTMENT.
 - FOR SYSTEM INSTALLATIONS USING THE CORPORATE NETWORK, CONTRACTOR SHALL LIST ALL NETWORK ENABLED DEVICES, INCLUDING MAC ADDRESSES AND STATIC / DYNAMIC ADDRESS REQUIREMENTS TO THE IT DEPARTMENT BEFORE CONNECTING DEVICES TO THE NETWORK.
 - RELATED WORK BY OTHERS.
 - ELECTRICAL CONTRACTOR (EC) TO PROVIDE CONDUIT, BACK BOXES, RACEWAY AND POWER CIRCUITS PER DIVISION 26 THAT ARE NOT SPECIFICALLY INDICATED AS CONTRACTOR RESPONSIBILITY.
 - VERIFY AND COORDINATE ALL CONDUIT AND DEVICE LOCATIONS WITH ELECTRICAL CONTRACTOR AND OWNER'S REPRESENTATIVE.
 - SHOP DRAWINGS, PRODUCT DATA, TEST RESULTS AND SAMPLE SUBMITTALS.
 - SEE DIVISION 01 31 23 SHOP DRAWINGS, PRODUCT DATA, AND SAMPLES FOR ADDITIONAL REQUIREMENTS.
 - COMMUNICATION CONSTRUCTION ADMINISTRATION SUBMITTAL LIST:
 - DIVISION 27, ALL SECTIONS.
 - DIVISION 28, ALL SECTIONS.
 - SHOP DRAWINGS TO INCLUDE:
 - BILL OF MATERIALS.
 - FIRST PAGE SHOULD LIST MATERIALS INCLUDED IN THE SUBMITTAL WITH COLUMNS FOR:
 - MANUFACTURER
 - MODEL/PART
 - ITEM DESCRIPTION
 - PAGE NUMBER
 - EQUIPMENT:
 - MANUFACTURER'S PRODUCT DATA/INSTALLATION FOR EACH PRODUCT USED.
 - CLEARLY INDICATE SPECIFIC MODEL BEING PROVIDED WHERE CUT SHEETS SHOW MULTIPLE MODELS.
 - USE RED BOX OR YELLOW HIGHLIGHTER
 - MANUFACTURER'S STANDARD WARRANTY, INCLUDING LABOR AND MATERIALS TO REPAIR OR REPLACE DEFECTIVE MATERIALS.
 - MANUFACTURER'S OPERATION AND MAINTENANCE DATA, OPERATING INSTRUCTIONS, SPARE PARTS LIST AND MAINTENANCE SCHEDULE.
 - OUTLINE AND GENERAL ARRANGEMENT DRAWINGS, DATA SHEETS AND WIRING DIAGRAMS.
 - DIMENSIONED PLAN AND ELEVATION VIEWS OF COMPONENTS.
 - ACCESS AND WORKSPACE REQUIREMENTS AND SYSTEM LABELING SCHEDULES.
 - COMPLETE FRONT ELEVATION DRAWING OF EQUIPMENT CABINETS, RACK AND EXACT COMPONENT LAYOUT WITHIN RACKS OR ENCLOSURES.
 - SYSTEM WIRING RISER DIAGRAMS SHALL INDICATE ALL COMPONENTS SHOWN ON THE FLOOR PLANS, TYPE AND TERMINATION POINT OF CABLE TO EACH COMPONENT.
 - INDEX LISTING EACH INSTALLED CABLE IN SPREADSHEET FORMAT SHOWING ROOM LOCATION, HEAD-END LOCATION AND LABELING ON EACH END OF EACH OUTLET.
 - REDUCED SIZE BUILDING FLOOR PLAN DRAWING (11"X17") SHOWING LOCATION OF ALL LOW-VOLTAGE CABLE TERMINATIONS AND CABLE OUTLET AND CABLE NUMBER LABELING.
 - BACKBONE CABLING.
 - SYSTEM LABELING SCHEDULES: ELECTRONIC COPY OF LABELING SCHEDULES THAT ARE PART OF THE CABLING IDENTIFICATION SYSTEM SOFTWARE.
 - WIRING DIAGRAMS TO SHOW TYPICAL WIRING SCHEMATICS INCLUDING THE FOLLOWING: PATHWAYS, CROSS-CONNECTS AND PATCH PANELS.
 - CROSS-CONNECTS AND PATCH PANELS: DETAIL MOUNTING ASSEMBLIES AND SHOW ELEVATIONS AND PHYSICAL RELATIONSHIP BETWEEN THE INSTALLED COMPONENTS.
 - OSM MANUALS AS A SINGLE PDF FILE TO INCLUDE THE FOLLOWING.
 - MARK RECORD DRAWINGS ON A FINAL SET OF DRAWINGS WHICH INCLUDES ALL REVISIONS.
 - APPROXIMATE PATH OF THE J-HOOK SYSTEMS.
 - UPDATED POINT TO POINT SYSTEM RISER DIAGRAM
 - DRAWINGS INDICATING SPEAKER LOCATION, WATTAGE TAPS, SPEAKER CIRCUIT EOL RESISTOR LOCATIONS AND SYSTEM WIRING.
 - ALL INPUT/OUTPUT DEVICE LOCATIONS SHALL BE SHOWN.
 - FRONT ELEVATION DRAWING OF EQUIPMENT RACK AND COMPONENT LAYOUT WITHIN RACK.
 - PROVIDE AN INDEX LISTING FOR EACH INSTALLED CABLE. INDICATE IN SPREADSHEET FORMAT SHOWING ROOM LOCATION, HEAD-END LOCATION, AND LABELING PROVIDED ON EACH END OF EACH OUTLET.
 - TEST RESULTS.
 - PROVIDE A REDUCED SIZE 11"X17" BUILDING FLOOR PLAN DRAWING SHOWING LOCATION OF ALL LOW-VOLTAGE CABLE TERMINATIONS, AND CABLE OUTLET AND CABLE NUMBER LABELING PER THE RESPECTIVE IDENTIFICATION AND LABELING SPECIFICATION IN EACH SECTION.
 - FUNCTIONALITY MATRIX.
 - PROVIDE SYSTEM SOFTWARE BACK-UP FILES FOR HEAD-END EQUIPMENT AND MIXER PROGRAM SETTINGS FOLLOWING FINAL SYSTEM ACCEPTANCE TESTING.
 - CONTACT AND WARRANTY INFORMATION AND STATEMENTS.
 - OPERATING INSTRUCTIONS.
 - SHOP DRAWINGS.
 - MANUFACTURERS' EQUIPMENT MANUALS.
- FINISHING AND PAINTING
 - SEE DIVISION 09 91 00 FINISH AND PAINTING FOR ADDITIONAL REQUIREMENTS.
 - PREPARE EXPOSED CONDUIT, FITTINGS, SUPPORTS, AND ACCESSORIES FOR FINISH PAINTING IN ROOMS THAT WILL HAVE CEILING AND STRUCTURE PAINTED.
 - PROVIDE A FACTORY OR FIELD APPLIED PRIME AND FINISH COAT OF COLOR SELECTED BY THE OWNER'S REPRESENTATIVE TO ALL ROOF MOUNTED EQUIPMENT AND OTHER EXTERIOR MATERIALS, INCLUDING SUPPORT HARDWARE.
 - COORDINATE WORK WITH THE PAINTERS SO THAT ALL EQUIPMENT IS INSTALLED PRIOR TO PAINTING. PAINT ITEMS IF NOT IN PLACE PRIOR TO NORMAL ROUTINE PAINTING.
 - IF FINISH BECOMES RUSTED, CORRODED, SCRATCHED, OR FLAKED DURING STORAGE OR INSTALLATION, REFINISH THE EQUIPMENT TO THE SATISFACTION OF THE OWNER.
 - WHERE THE COMMUNICATION CONTRACTOR IS REQUIRED TO PAINT, THE PAINTING SHALL BE DONE IN ACCORDANCE WITH THE PAINTING PORTION OF THE ARCHITECTURAL SPECIFICATION.
- DETAILS AND SCHEDULES ARE SHOWN TO AID THE CONTRACTOR AND ARE NOT MEANT TO BE INCLUSIVE OF ALL DEVICES. PROVIDE REQUIRED EQUIPMENT AND ACCESSORIES FOR A COMPLETE INSTALLATION.
- INSTALL ALL EQUIPMENT PER MANUFACTURER'S INSTALLATION INSTRUCTIONS AND REQUIREMENTS. PROVIDE ADDITIONAL WORK AND MATERIALS AS REQUIRED.
- COORDINATE INSTALLATION OF WORK WITH THE OTHER CONTRACTORS TO AVOID CONFLICTS WITH OTHER WORK. MAINTAIN SERVICE CLEARANCES.
- MAINTAIN MAXIMUM HEADROOM AND SPACE CONDITION AT ALL POINTS IN THE BUILDING. WHERE HEADROOM OR SPACE CONDITIONS APPEAR INADEQUATE, NOTIFY ARCHITECT/ENGINEER BEFORE PROCEEDING WITH THE INSTALLATION.
- COMPLY WITH THE REQUIREMENTS OF NFPA, NATIONAL, STATE AND LOCAL ELECTRICAL CODES AND LOCAL UTILITY REGULATIONS.
- MATERIAL SHALL BEAR UL LISTING AND/OR OTHER APPROVED AGENCY LISTING.
- PROJECT COMPLETION
 - CLEAN DEVICES AND EQUIPMENT AND LEAVE IN PROPER WORKING CONDITION AT THE TIME OF FINAL CLEAN-UP.
 - PROVIDE OPERATING INSTRUCTIONS TO OWNER'S PERSONNEL FOR ALL SYSTEMS. MAINTAIN A RECORD OF OPERATING INSTRUCTION PERIODS.
- LOCATION
 - THE ARCHITECT SHALL RESERVE THE RIGHT TO MAKE DEVICE POSITION CHANGES UP TO 10' BEFORE INSTALLATION WITHOUT ANY ADDITIONAL COST TO PROJECT.
 - DO NOT LOCATE DEVICES OR EQUIPMENT WHERE THE USEFULNESS AND/OR OPERATION WILL BE AFFECTED BY THE WORK OF OTHER TRADES, DOOR SWING, COUNTER, EQUIPMENT, ETC.
 - REVIEW THE ARCHITECTURAL DRAWINGS TO VERIFY ALL WIRING DEVICE LOCATIONS PRIOR TO ROUGH-IN. LOCATE DEVICES AS SHOWN ON THE ARCHITECTURAL DRAWINGS.
- ACCESS
 - INSTALL EQUIPMENT, JUNCTION BOXES, PULL BOXES AND ACCESSORIES TO PERMIT ACCESS WITHOUT RELOCATING INSTALLED OR YET TO BE INSTALLED EQUIPMENT.
 - ACCESS PANELS
 - FURNISH ACCESS PANELS OF ADEQUATE SIZE TO PERMIT SERVICE OF CONCEALED DEVICES. PANELS SHALL BE SUITABLE FOR INSTALLATION IN THE MATERIAL FORMING THE FINISHED SURFACE, WITH FLUSH METAL FRAME, FLUSH HINGED STEEL DOOR, FLUSH SCREWDRIVER OPERATED LATCH.
 - PANELS UL LISTED TO CONFORM TO THE FIRE RATING OF THE SURFACE INSTALLED IN.
 - TURN ACCESS PANEL OVER TO CONTRACTOR SKILLED IN THE CONSTRUCTION OF THE SURFACES INVOLVED FOR INSTALLATION.
 - ARCHITECT TO APPROVE ACCESS PANEL LOCATION PRIOR TO INSTALLATION OF EQUIPMENT REQUIRING ACCESS.
 - COORDINATE WITH THE OTHER CONTRACTORS AND WHEREVER PRACTICAL, GROUP DEVICES IN SUCH A MANNER SO AS TO MINIMIZE PANELS.

27 05 35 PENETRATIONS

- A. PROVIDE CORE DRILLING FOR EXISTING CONCRETE WALLS.
- B. SLEEVES
- FURNISH STEEL OR PVC SLEEVES FOR CABLES PASSING THROUGH MASONRY, CONCRETE, OR OTHER SIMILAR CONSTRUCTION, MINIMUM OF 6" FROM THE WALL WITH INSULATED CONNECTORS OR OTHER TYPE OF CABLE PROTECTION ON THE END.
 - FURNISH SLEEVE TO MASON FOR NEW MASONRY WALLS.
 - FURNISH, INSTALL, AND GROUT SLEEVE IN EXISTING MASONRY AND NEW CONCRETE WALLS.
 - SLEEVE NOT REQUIRED FOR DRYWALL WALLS OR CORE DRILLED HOLE IN CONCRETE WALL.
 - SECURE SLEEVES ON BOTH SIDES OF THE PENETRATION TO PREVENT SHIFTING DURING CABLE INSTALLATION.
 - PLACE SLEEVES ABOVE THE CEILING THROUGH THE WALL WHERE CABLES ARE TO BE ROUTED.
 - NON-FIRE RATED INTERIOR WALL AND FLOOR PENETRATIONS: FILL VOID BETWEEN CONDUIT AND SLEEVE, CONCRETE OR DRYWALL WITH EXPANDING POLYURETHANE FOAM. CAULK BETWEEN CONDUIT AND SLEEVE OR WALL WITH NON-HARDENING CAULK.
 - FIRE RATED INTERIOR WALL AND FLOOR PENETRATIONS: SEAL OPENING AROUND PIPE WITH A UL APPROVED FIRE-STOP SYSTEM HAVING AN I-RATING NOT LESS THAN THE HOURLY RATING OF THE ASSEMBLY BEING PENETRATED.
 - SMOKE WALL PENETRATIONS: CONDUITS OR CABLES PENETRATING PENETRATION SHALL NOT DESTROY THE BARRIER'S INTEGRITY.
 - CONTRACTOR SHALL USE CAUTION PRIOR TO MAKING PENETRATIONS AS TO NOT DISTURB ANY EXISTING UTILITIES THAT MIGHT BE PRESENT IN EXISTING WALLS, CEILINGS OR FLOORS. THIS CONTRACTOR IS RESPONSIBLE FOR LOCATING EXISTING UTILITIES IN EXISTING WALLS, CEILINGS OR FLOORS.
 - SEAL ALL RACEWAY, CABLE AND CONDUIT PENETRATIONS THROUGH ALL WALLS IN THE ELECTRICAL ROOM(S).

27 05 26 GROUNDING AND BONDING

- A. GENERAL REQUIREMENTS
- GROUNDING MUST CONFORM TO APPLICABLE BUILDING CODES AS WELL AS ANSI-I STD-607-A AND THE NEC.
 - GROUND CABLE SHIELDS, DRAIN CONDUCTORS, AND EQUIPMENT TO ELIMINATE SHOCK HAZARD AND TO MINIMIZE GROUND LOOPS, COMMON-MODE RETURNS, NOISE PICKUP, CROSS TALK, AND OTHER IMPAIRMENTS.
 - BOND SHIELDS AND DRAIN CONDUCTORS TO GROUND AT ONLY ONE POINT IN EACH CIRCUIT.
 - SHORT METALLIC PATHWAYS (WALL AND FLOOR SLEEVES) ARE NOT REQUIRED TO BE BONDED.
 - THE CONDUIT SYSTEM SHALL NOT BE CONSIDERED SUITABLE FOR EQUIPMENT GROUNDING.

- BONDING THE NEUTRAL TO EARTH GROUND SHALL NOT BE DONE ANYWHERE EXCEPT AT THE SECONDARY SIDE OF THE CONTROL TRANSFORMER WHERE IT MUST BE DONE (INCLUDING CONTROL VOLTAGE TRANSFORMERS).

27 05 53 IDENTIFICATION FOR COMMUNICATION SYSTEMS

- A. GENERAL REQUIREMENTS
- ALL LABELS SHALL BE PERMANENT AND MACHINE GENERATED. NO HANDWRITTEN OR NON-PERMANENT LABELS ALLOWED.
 - LABELS SHALL BE PHYSICALLY AND CHEMICALLY RESISTANT TO DAMAGE THAT WOULD AFFECT READABILITY. INSTALL LABELS AS RECOMMENDED BY MFG. INSTALL LABELS SQUARELY AND NEATLY ON ALL EQUIPMENT. POSITION LABELS AS TO BE VISIBLE AND NOT OBSCURED BY HARDWARE OR OTHER CABLING.
- B. LABEL FORMAT:
- 3A A4-3-5/01
 - 3A-IDENTIFIER FOR IDF SERVING THAT LOCATION.
 - A04-RACK/CABINET IDENTIFIER.
 - 35-THE RACK (RACK UNIT) LOCATION OF THE PATCH PANEL.
 - 01-PORT ID OF THE ASSOCIATED PATCH PANEL.
- C. EQUIPMENT RACKS
- ENGRAVED 3-LAYER PHENOLIC LABEL WITH BLACK LETTERS ON WHITE MATERIAL, UNLESS OTHER COLORS ARE CALLED OUT ON THE DRAWINGS OR DETAILS. LABELS MINIMUM 1" HIGH AND 3" LONG.
 - POSITION LABELS AT TOP OF RACK, LEFT, RIGHT OR CENTER FOR BEST VISIBILITY.
- D. HORIZONTAL CABLE AND TERMINATION HARDWARE
- LABEL ALL EQUIPMENT OUTLETS, PATCH PANELS, TERMINATIONS BLOCKS, AND CABLES.
 - THIS IS INCLUSIVE OF EACH VOICE, DATA, VIDEO, OR FIBER OPTIC OUTLET.
 - FLAG TYPE LABELS ARE NOT ALLOWED.
 - POSITION LABEL WITHIN 4 INCHES OF EACH CABLE END. CABLE ID SHALL REPEAT AROUND PERIMETER OF THE CABLE 3 TIMES MINIMUM.
- E. WORKSTATIONS/EQUIPMENT OUTLET
- LABELS THAT ARE PLACED IN RECESSED LABEL HOLDERS SHALL BE WHITE PAPER ON WHICH OUTLET INFORMATION IS ADDED.
 - LABELS SHALL BE WHITE BACKGROUND WITH BLACK LETTERING. LETTER SIZE SHALL BE AS LARGE AS PRACTICABLE, UP TO 16 POINT TO FITTING PROPERLY. NO LETTERING SHALL BE SMALLER THAN 12 POINT.
 - REFERENCE PLANS: SYSTEMS IDENTIFICATION DETAIL.
- F. FIBER OPTIC AND MODULAR PATCH PANEL
- PAPER INSERTS INTEGRAL TO PATCH PANEL, ADHESIVE LABELS OR FACTORY SCREENED NUMBERING.
- G. MISCELLANEOUS
- WHERE A EQUIPMENT OUTLET OR FIELD TERMINABLE PLUG IS CONCEALED ABOVE A SUSPENDED CEILING, PROVIDE A MARKING ON THE CEILING TO IDENTIFY SUCH LOCATION. COORDINATE WITH OWNER TO DETERMINE IDENTIFICATION METHOD.
- 27 10 00 STRUCTURED CABLING SYSTEM
- A. ABBREVIATIONS
- CABLE TYPES
 - UTP — UNSHIELDED TWISTED PAIR
 - F/UTP (FTP) — AN OVERALL FOIL SHIELD WITH UNSHIELDED TWISTED PAIRS (FTP)
 - S/UTP (STP) — AN OVERALL BRAIDED SCREEN WITH UNSHIELDED TWISTED PAIRS (UTP)
 - S/FTP — AN OVERALL FOIL SHIELD WITH INDIVIDUALLY SHIELDED TWISTED PAIRS
 - IDC — INSULATION DISPLACEMENT CONNECTOR
 - IDF — INTERMEDIATE DISTRIBUTION FACILITY
 - MDF — MAIN DISTRIBUTION FRAME
 - TIA — TELECOMMUNICATION INDUSTRY ASSOCIATION
 - TIA-FOCIS — FIBER OPTIC CONNECTOR INTERMATEABILITY STANDARD
- B. CONDUIT
- CONDUIT REQUIRED FOR CABLE IN THE FOLLOWING LOCATIONS:
 - ALL LOCATIONS.
 - SEE CONDUIT MATRIX ON ELECTRICAL DRAWINGS AND DIVISION 26 SPECIFICATIONS FOR ADDITIONAL CONDUIT AND SUPPORT REQUIREMENTS.
 - CONTRACTOR IS RESPONSIBLE FOR PROVIDING ALL CONDUIT, BRACKETS AND ASSOCIATED HARDWARE.
 - PARALLEL RUNS OF EXPOSED LOW VOLTAGE CONDUIT SHALL BE RACED TOGETHER ON COMMON SUPPORTS WITH A MINIMUM OF 1/2" BETWEEN CONDUITS. MAINTAIN PROPER SPACING FROM LINE VOLTAGE CONDUIT.
 - STUB CONDUITS INTO AN ACCESSIBLE CEILING SPACE.
 - SIZE
 - VOICE DATA AND OTHER LV SYSTEM CONDUIT DROPS SHALL BE A MINIMUM 1" UNLESS NOTED OTHERWISE (MAX 40% FILL).
 - TELEVISION, DISPLAY OR FLOOR BOXES CONTAINING AUDIO-VISUAL CABLES SHALL BE 1.25" ID UNLESS NOTED OTHERWISE (MAX 40% FILL).
 - MAXIMUM LENGTH
 - MAX TWO 90-DEGREE BENDS IN CONDUIT BETWEEN PULL POINTS.
 - IF MORE THAN TWO BENDS OR IF CONDUIT RUN GREATER THAN 100 FEET IN LENGTH, INSERT PULL BOX.
 - IF FIELD CONDITIONS DOES NOT PERMIT, INCREASE CONDUIT SIZE TO THE NEXT TRADE SIZE FOR EACH ADDITIONAL 90-DEGREE BEND (OFFSETS ARE CONSIDERED EQUIVALENT TO A 90-DEGREE BEND).
 - DE-BUR AND BUSH ALL CONDUIT ENDS. PROVIDE CONDUITS WITH PLASTIC INSULATED BUSHING FOR CONDUITS TERMINATING INSIDE A RACK OR ENCLOSURE.
 - PROVIDE A PULL LINE IN EACH CONDUIT.
 - MAINTAIN AUDIO OR VIDEO SIGNAL CONDUITS A MINIMUM 4" SEPARATE FROM LINE VOLTAGE CONDUITS IF MORE THAN 10 FEET.
- C. CERTIFICATION
- PERFORM ALL TESTS IAW TIA/EIA-568-C-2 AND TIA/EIA-568-C-3 AND TELECOMMUNICATIONS STANDARDS FOR TWISTED PAIR AND OPTICAL FIBER CABLING REQUIREMENTS OF THIS SECTION.
 - PROVIDE DOCUMENTATION OF TESTING IAW TELECOMMUNICATIONS STANDARDS FOR TWISTED PAIR AND OPTICAL FIBER CABLING REQUIREMENTS OF THIS SECTION.

27 15 00 HORIZONTAL CABLING

- A. GENERAL
- PROVIDE THE SAME MANUFACTURER FOR ALL CABLING AND CONNECTIVITY COMPONENTS THROUGHOUT THE PROJECT.
- B. CABLING
- MANUFACTURERS:
 - PANDUIT
 - COMMSCOPE
 - HUBBELL
 - LEVITON
 - CABLING SHALL HAVE A MINIMUM 10 FT SLACK LOOP MANAGED AT EACH IDF AND MDF ROOMS.
 - CABLE JACKET COLOR SHALL BE:
 - BLUE — OFFICE NETWORK
 - PURPLE — WIFI
 - GREEN — SECURITY CAMERAS / ACCESS CONTROLS
 - ORANGE — INDUSTRIAL NETWORK
 - PINK — PAGING SYSTEM
 - TYPICAL COPPER CABLING
 - CABLE SHALL BE TIA/EIA-568-B CATEGORY 6, 4-PAIR UTP
 - PROVIDE WATER BLOCKED CABLE FOR ANY SLAB-ON-GRADE FLOOR BOX APPLICATION OR DATA CABLE INSTALLED IN CONDUIT IN OR UNDER SLAB. NOTE IF CABLE IS NOT PLENUM RATED IT MUST BE INSTALLED IN CONDUIT IF INSTALLED ABOVE THE CEILING IN A PLENUM SPACE. PVC CONDUIT MAY BE ROUTED UNDERGROUND DIRECTLY IN LIEU OF USING RMT ABOVE CEILINGS. CABLE SHALL BE APPROVED FOR WET LOCATIONS AND FLOODED FOR MOISTURE PROTECTION.
 - WIRELESS ACCESS POINT
 - CABLE SHALL BE TIA/EIA-568-B CATEGORY 6, 4-PAIR UTP
 - ACCESS POINT DEVICES SHALL BE PROVIDED BY OWNER, INSTALLED BY CONTRACTOR.
- E. SEPARATION FROM EMI SOURCES
- COMPLY WITH BEST PRACTICE AND TIA/EIA-568-B RECOMMENDATIONS FOR SEPARATING UNSHIELDED COPPER VOICE AND DATA COMMUNICATION CABLE FROM POTENTIAL EMI SOURCES, INCLUDING ELECTRICAL POWER LINES AND EQUIPMENT.
 - SEPARATION BETWEEN OPEN COMMUNICATIONS CABLES OR CABLES IN NON-METALLIC RACEWAYS AND UNSHIELDED POWER CONDUCTORS AND ELECTRICAL EQUIPMENT AS FOLLOWS:
 - ELECTRICAL EQUIPMENT RATING LESS THAN 2 KVA — MINIMUM 5 INCHES.
 - ELECTRICAL EQUIPMENT RATING BETWEEN 2 AND 5 KVA — MINIMUM 12 INCHES.
 - ELECTRICAL EQUIPMENT RATING LESS THAN 5 KVA — MINIMUM 24 INCHES.
 - SEPARATION BETWEEN COMMUNICATIONS CABLES AND ELECTRICAL MOTORS AND TRANSFORMERS, 5 KVA OR HP AND LARGER — MINIMUM 48 INCHES.
- F. QUALITY ASSURANCE
- VISUALLY INSPECT UTP CABLE JACKET MATERIALS FOR NRTL CERTIFICATION MARKINGS. INSPECT CABLING TERMINATIONS IN COMMUNICATIONS EQUIPMENT ROOMS FOR COMPLIANCE WITH COLOR CODING FOR PIN ASSIGNMENTS AND INSPECT CABLING CONNECTIONS FOR COMPLIANCE WITH TIA/EIA-568-B.1.
 - VISUALLY CONFIRM MARKINGS OF OUTLETS, COVER PLATES, OUTLET/CONNECTORS AND PATCH PANELS.
 - VISUALLY INSPECT CABLE PLACEMENT, CABLE TERMINATION, GROUNDING AND BONDING, EQUIPMENT, PATCH CORDS AND LABELING OF ALL COMPONENTS.
 - UTP PERFORMANCE. PERFORM THE FOLLOWING TESTS ACCORDING TO TIA/EIA-568-B.1 AND TIA/EIA-568-B.2.
 - WIRE MAP
 - LENGTH (PHYSICAL VS ELECTRICAL AND LENGTH REQUIREMENTS.
 - INSERTION LOSS.
 - NEAR-END CROSSTALK(NEXT) LOSS.
 - POWER SUM NEAR-END CROSSTALK (PSNEXT) LOSS.
 - EQUAL-LEVEL FAR-END CROSSTALK (ELFEXT).
 - POWER SUM EQUAL-LEVEL FAR-END CROSSTALK (PSLEFEXT).
 - RETURN LOSS.
 - PROPAGATION DELAY.
 - DELAY SKEW
 - REMOVE AND REPLACE CABLING WHERE TEST RESULTS INDICATE IT DOES NOT COMPLY WITH SPECIFIED REQUIREMENTS. END-TO-END CABLING WILL BE CONSIDERED DEFECTIVE IF IT DOES NOT PASS TESTS AND INSPECTIONS.
 - PREPARE TEST AND INSPECTION REPORTS.
- G. UTP PATCH PANEL
- MODULAR PANEL HOUSING MULTIPLE NUMBERED JACK UNITS WITH IDC-TYPE CONNECTORS AT EACH OPENING.
 - 48 PORT OR 24 PORT HIGH DENSITY.
 - NUMBER OF PANELS AND PORTS AS REQUIRED.
 - PROVIDE SHIELDED BASED ON CABLE TYPE.
 - WHITE BACKGROUND DESIGNATION STRIPS WITH CLEAR PLASTIC COVER LABELING INTEGRAL TO PATCH PANEL.
 - REAR HORIZONTAL CABLE MANAGEMENT.
- H. BOXES
- BOXES SHALL BE RECESSED IN THE WALL IN EXISTING AND NEW STUD WALLS AND NEW MASONRY WALLS.
 - BOXES SHALL BE SURFACE MOUNTED ON IMP, PRECAST AND EXISTING MASONRY WALLS.
 - DEPTH TO BE GREATER THAN BEND OF RADIUS OF CABLE IN RESPECTIVE BOX.
- I. FACEPLATES, JACKS, AND PLUGS
- FACEPLATES:
 - PROVIDE ABS PLASTIC OR STAINLESS STEEL VERTICAL FACEPLATES AS REQUIRED PER AREA INSTALLED.
 - PLATES SHALL ACCEPT IDC-TYPE JACK MODULES AND ALLOW A LABEL TO BE INSERTED INTO AN INTEGRAL LABEL POCKET WITH CLEAR COVER.
 - COLOR SHALL BE AS SPECIFIED IN DIVISION 26.
 - ALL FACEPLATE, JACK, PLUG AND CONNECTOR MANUFACTURERS SHALL BE CONSISTENT THROUGHOUT PROJECT.
 - WALL PHONE MOUNTING PLATES
 - STAINLESS STEEL WITH TWO MOUNTING STUDS.
 - JACKS
 - PROVIDE MODULAR COLOR-CODED IDC-TYPE FACEPLATE INSERT / RJ-45 RECEPTACLE UNITS FOR EACH CABLE WITHIN THE OUTLET AS SHOWN ON PLANS.
 - INSTALL DUST CAPS AND SECURE ALL JACKS PER MANUFACTURER'S RECOMMENDATIONS.
 - PATCH PANEL JACK COLOR SHALL FOLLOW CABLE JACKET COLOR CODE.
 - PROVIDE SHIELDED BASED ON CABLE TYPE.
 - PLUGS
 - UTP AND F/UTP CABLE PLUG CATEGORY LISTING SHALL MATCH THAT OF THE CABLE MINIMUM.
 - PARTITION COMMUNICATION OUTLETS

- PROVIDE ADAPTORS, AS REQUIRED, TO MOUNT COMMUNICATION OUTLETS WITHIN PARTITIONS.
 - MANUFACTURER LEVITON 49910 OR EQUAL. VERIFY ADAPTER IS COMPATIBLE WITH THE SPECIFIED MODULAR FURNITURE MANUFACTURER. ALL FACEPLATE, JACK, PLUG AND CONNECTOR MANUFACTURERS SHALL BE CONSISTENT THROUGHOUT PROJECT.
 - PLATES SHALL ACCEPT IDC-TYPE JACK MODULES AND ALLOW A LABEL TO BE INSERTED INTO AN INTEGRAL LABEL POCKET WITH CLEAR COVER.
 - COLOR SHALL BE AS SHOWN ON PLANS OR BY OWNER.
- K. WORKSTATION COMMUNICATION BOXES AND OUTLETS
- USE 4" SQUARE, 1.18" DEEP (MINIMUM) OUTLET BOX WITH SINGLE GANG RING UNLESS OTHERWISE SHOWN ON PLAN. PROVIDE CONDUIT STUB INTO CEILING TOWARD CABLE TRAY OR CABLE SUPPORT PATHWAY.
 - PROVIDE COMBINATION TYPE FACEPLATE WITH 4-POSITION OPENINGS FOR IDC-TYPE OUTLETS.
 - FACEPATES SHALL HAVE LABEL HOLDERS WITH A TYPED OVERLAY LABEL AFFIXED ABOVE / BELOW EACH OUTLET POSITION INDICATING THE OUTLET NUMBER.
 - PROVIDE THE APPROPRIATE COMMUNICATIONS DEVICE IN THE OPENINGS AS SHOWN ON THE PLANS. CLOSE ALL EMPTY OPENINGS WITH BLANK INSERTS.

27 16 00 COMMUNICATIONS PATCH CORDS

- A. GENERAL
- PROVIDE THE SAME MANUFACTURER OF HORIZONTAL CABLING FOR ALL PATCH CORDS.
 - JACKET COLOR TO MATCH HORIZONTAL CABLE COLOR SCHEME.
 - SEE 27 15 00 HORIZONTAL CABLING REQUIREMENTS.
 - PROVIDE (5) ATTIC STOCK OF EACH COLOR USED.
- B. IDF UTP AND F/UTP PATCH CABLES: PATCH CABLES SHALL BE INSTALLED IN LENGTHS TO ALLOW FOR PROPER BEND RADIUS AND SHALL BE INSTALLED BY CONTRACTOR IN A NEAT, ORGANIZED MANNER USING INDUSTRY STANDARD MEANS AND METHODS.
- C. WORKSTATION UTP AND F/UTP PATCH CABLES
- WORKSTATION PATCH CABLES SHALL BE PROVIDED IN LENGTHS TO ALLOW FOR PROPER BEND RADIUS AND SHALL BE INSTALLED BY CONTRACTOR IN A NEAT, ORGANIZED MANNER USING INDUSTRY STANDARD MEANS AND METHODS.
 - COLOR CODE CORDS TO KEEP DATA PATCH CABLES SEPARATE FROM VOICE PATCH CABLES PER GENERAL INSTRUCTION REQUIREMENTS IN THIS SECTION OR AS NOTED OTHERWISE. COLORS SHALL BE CONSISTENT THROUGHOUT THE PROJECT.

27 51 16 PUBLIC ADDRESS SYSTEM

- A. SCOPE OF WORK — EXTEND THE EXISTING PUBLIC ADDRESS SYSTEM INCLUDING THE FOLLOWING FEATURES:
- POWER AMPLIFIER
 - LOUD SPEAKERS
 - RACEWAYS
 - CONDUCTORS
- B. PRODUCTS
- POWER AMPLIFIER
 - MAUFACTURERS — MATCH EXISTING EQUIPMENT.
 - MOUNTING — RACK
 - OUTPUT POWER — 70V, 300WATT MINIMUM
 - THD: LESS THAN 3 PERCENT AT RATED POWER
 - MINIMUM SIGNAL TO NOISE RATIO: 80 DB AT RATED POWER
 - INPUT FOR CONNECTION TO OWNERS TELEPHONE SYSTEM.
 - INPUT FOR CONNECTION TO FIRE ALARM SYSTEM.
 - LOUDSPEAKERS
 - HORN TYPE SPEAKERS
 - SINGLE HORN UNIT, DOUBLE REINERTANT DESIGN, WITH MINIMUM FULL-RANGE POWER RATING OF 15 W.
 - MATCHING TRANSFORMER: FULL POWER RATED WITH FOUR STANDARD TAPS. MAXIMUM INSERTION LOSS OF 0.5 DB.
 - MOUNTING: INTEGRAL BRACKET
 - WEATHER RATING: WET LOCATION
 - RACEWAYS
 - NON PROCESS SPACES: REFERENCE SECTION 26 05 30 — CONDUIT
 - PROCESS SPACES: REFERENCE SECTION 26 06 00 — PROCESS ROOM SPECIFICATIONS
 - CONDUCTORS:
 - JACKETED UNSHIELDED TWISTED MULTI-PAIR, UNTINNED SOLID COPPER.
 - REFERENCE SECTION 27 15 00 — COMMUNICATIONS HORIZONTAL CABLING.
- C. EXECUTION
- WIRING METHOD — INSTALL CABLES IN RACEWAYS.
 - GENERAL CABLE REQUIREMENTS
 - TERMINATE CONDUCTORS. NO CABLE SHALL CONTAIN UNTERMINATED ELEMENTS. MAKE TERMINATIONS ONLY AT OUTLETS AND TERMINALS.
 - SEPARATION OF WIRES — SEPARATE BRACING WIRING FROM ALL OTHER WIRING BY NOT LESS THAN 12 INCHES. WHERE MINIMUM SEPARATION CANNOT BE ACHIEVED, PROVIDE SHIELDED CABLES.
 - INSTALLATION
 - COORDINATE INSTALLATION WITH ALL OTHER TRADES.
 - IDENTIFICATION: APPLY WIRE TAGS AT TERMINATION POINTS.
 - ADJUST SPEAKER TAP SETTINGS IN FIELD WITH OWNERS DIRECTION TO ACHIEVE OPTIMAL PERFORMANCE.



Always a Better Plan

100 Camelot Drive
Fond du Lac, WI 54935
920-926-9800
excelengineer.com

PROJECT INFORMATION

STORAGE WAREHOUSE EXPANSION FOR:
WEST POINT DAIRY PRODUCTS
570 NORTH 500 WEST • HYRUM, UT 84319

PROFESSIONAL SEAL

SHEET DATES

ISSUED FOR BUDGET

IFB APR. 17, 2026

JOB NUMBER

250429500

SHEET NUMBER

E0.2

PROJECT INFORMATION

STORAGE WAREHOUSE EXPANSION FOR:
WEST POINT DAIRY PRODUCTS
570 NORTH 500 WEST • HYRUM, UT 84319

PROFESSIONAL SEAL

SHEET DATES

ISSUED FOR BUDGET
IFB APR. 17, 2026

JOB NUMBER
250429500

SHEET NUMBER

E1.1L


GENERAL NOTES

- VERIFY ALL EXPOSED CONDUIT ROUTING WITH ARCHITECT/ENGINEER WHERE CONDUIT IS EXPOSED IN FINISHED ROOMS.
- COORDINATE LIGHT FIXTURE LOCATIONS IN MECHANICAL EQUIPMENT ROOMS WITH OTHER CONTRACTORS PRIOR TO ROUGH IN.
- WIRE EMERGENCY LIGHTS UNSWITCHED TO LIGHTING CIRCUIT SERVING SAME ROOM, OR TO "NIGHT LIGHT" CIRCUIT WHEN AVAILABLE.
- LOCATE EXTERIOR EGRESS LIGHT AT SINGLE WYTHE MASONRY CONSTRUCTION MIN. 12" ABOVE FLASHING AT DOOR HEAD.
- EXIT LIGHT CONDUIT AT SINGLE WYTHE MASONRY CONSTRUCTION SHALL NOT PENETRATE FLASHING ABOVE DOOR HEAD IF EXIT LIGHT IS WALL MOUNTED.
- PENETRATE MASONRY WALL PER STRUCTURAL DRAWINGS. PENETRATIONS NOT PERMITTED THROUGH MARKED GROUTED/REINFORCED MASONRY, AND SHALL NOT BE MODIFIED WITHOUT WRITTEN APPROVAL FROM STRUCTURAL ENGINEER.
- SEE HVAC PLANS FOR AREAS THAT ARE USED AS A RETURN AIR PLENUM. PROVIDE PLENUM RATED CONSTRUCTION.
- SEE ARCHITECTURAL REFLECTED CEILING AND ELEVATION PLANS FOR LOCATION OF ALL LIGHTING FIXTURES. LOCATE FIXTURES IN ACCORDANCE WITH CEILING AND ELEVATION PLANS.
- DEVICE LOCATIONS MAY BE DISTORTED FOR CLARITY. LOCATE DEVICES SYMMETRICALLY WITH THE ARCHITECTURAL ELEMENTS.
- SEE LIGHTING FIXTURE LEGEND FOR FIXTURE WIRING INFORMATION.


KEYNOTES

ALL KEYNOTES MAY NOT APPEAR ON THIS SHEET.

- ① SEE ARCHITECTURAL ELEVATIONS FOR MOUNTING HEIGHTS.
- ② PROVIDE REMOTE MOUNTED LED DRIVE 107A-C920 IN NEMA 1 ENCLOSURE IN NON-PROCESS AREAS AND NEMA 4X IN PROCESS AREAS. MOUNT ON WALL INSIDE BUILDING. DRIVE TO PROVIDE EMERGENCY POWER TO EGRESS LIGHT FIXTURES.
- ③ LIGHT FIXTURE SHALL BE SURFACE MOUNTED TO METAL LINER PANEL. SEE DETAIL #9/E3.0 FOR MORE INFORMATION.

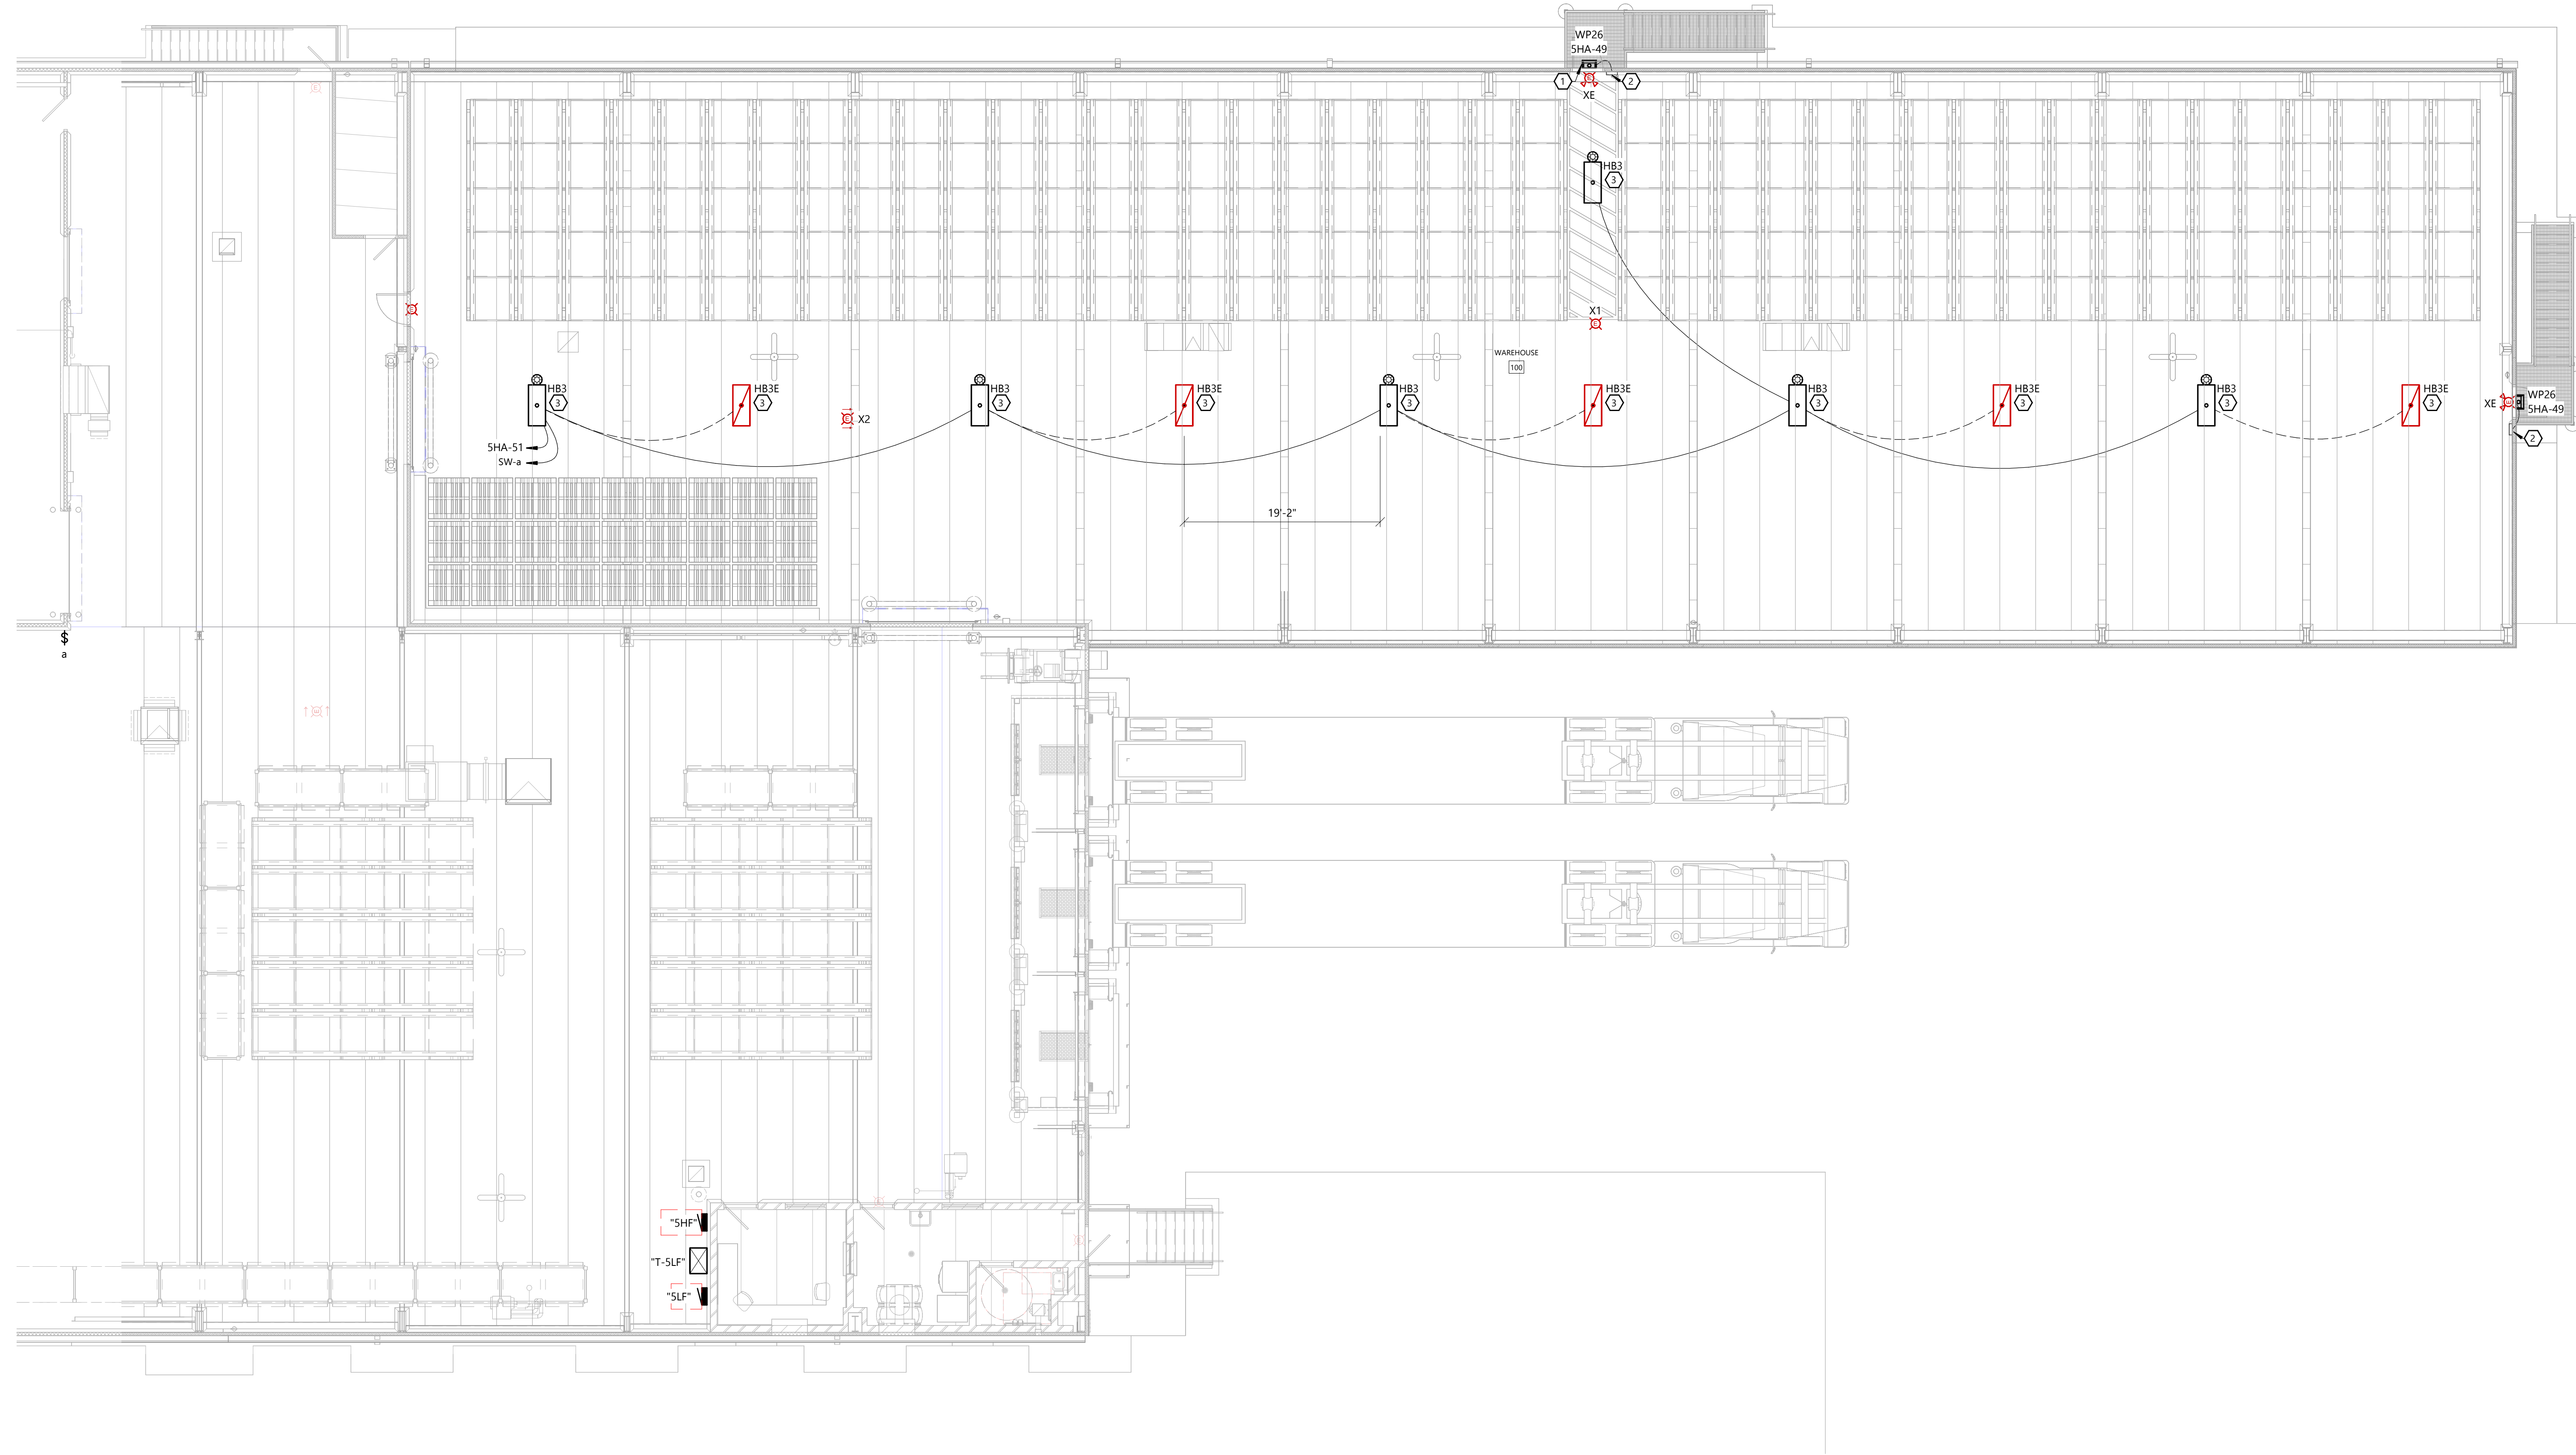

FIRST FLOOR PLAN - AREA "A" - LIGHTING
SCALE: 1/8" = 1'-0"
0' 8' 16'

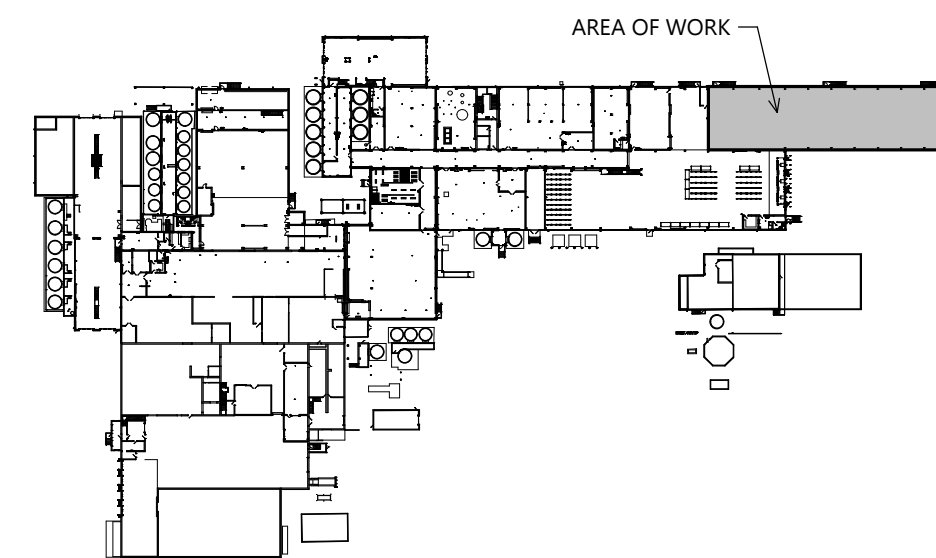

KEY PLAN

ELECTRICAL FIRST FLOOR PLAN - AREA 'A' - LIGHTING

NOT FOR CONSTRUCTION



Always a Better Plan
100 Camelot Drive
Fond du Lac, WI 54935
920-926-9800
excelengineer.com

PROJECT INFORMATION

STORAGE WAREHOUSE EXPANSION FOR:
WEST POINT DAIRY PRODUCTS
570 NORTH 500 WEST • HYRUM, UT 84319

PROFESSIONAL SEAL

SHEET DATES

ISSUED FOR BUDGET
IFB APR. 17, 2026

JOB NUMBER
250429500

SHEET NUMBER


E1.1P

GENERAL NOTES

- VERIFY ALL EXPOSED CONDUIT ROUTING WITH ARCHITECT/ENGINEER WHERE CONDUIT IS EXPOSED IN FINISHED ROOMS.
- DETAIL REFERENCES ON PLANS ARE TO AID THE CONTRACTOR IN IDENTIFYING THE APPLICABLE DETAIL. NOT ALL DETAILS, OR INSTANCES OF DETAILS, ARE REFERENCES ON PLANS. CONTRACTOR IS RESPONSIBLE TO REVIEW AND COMPLY WITH ALL APPLICABLE DETAILS WHETHER OR NOT REFERENCED ON PLANS.
- EXTERIOR RECEPTACLES SHALL BE GFI TYPE. PROVIDE PASS & SEYMOUR SERIES "W U.C." OR EQUIVALENT COVER. (PER NEC 406.8(B) AND AHJ). COLOR SHALL BE SELECTED BY ARCHITECT.
- SEE SHEET E4.0 FOR BRANCH CIRCUIT FEEDER SIZES.
- PENETRATE MASONRY WALL PER STRUCTURAL DRAWINGS. PENETRATIONS NOT PERMITTED THROUGH MARKED GROUTED/REINFORCED MASONRY AND SHALL NOT BE MODIFIED WITHOUT WRITTEN APPROVAL FROM STRUCTURAL ENGINEER.
- DEVICE LOCATIONS MAY BE DISTORTED FOR CLARITY. LOCATE DEVICES SYMMETRICALLY WITH THE ARCHITECTURAL ELEMENTS.
- SEE HVAC AND PLUMBING PLANS FOR LOCATIONS OF HEATING, VENTILATING, AIR CONDITIONING AND PLUMBING EQUIPMENT. DO NOT REFERENCE ELECTRICAL DRAWINGS FOR EXACT LOCATION.
- SEE HVAC SHEET PLANS FOR AREAS THAT ARE USED AS A RETURN AIR PLENUM. PROVIDE PLENUM RATED CONSTRUCTION.


KEYNOTES

- ① EC SHALL MOUNT AND WIRE THE SPEED SWITCH FURNISHED BY THE EQUIPMENT MANUFACTURER.

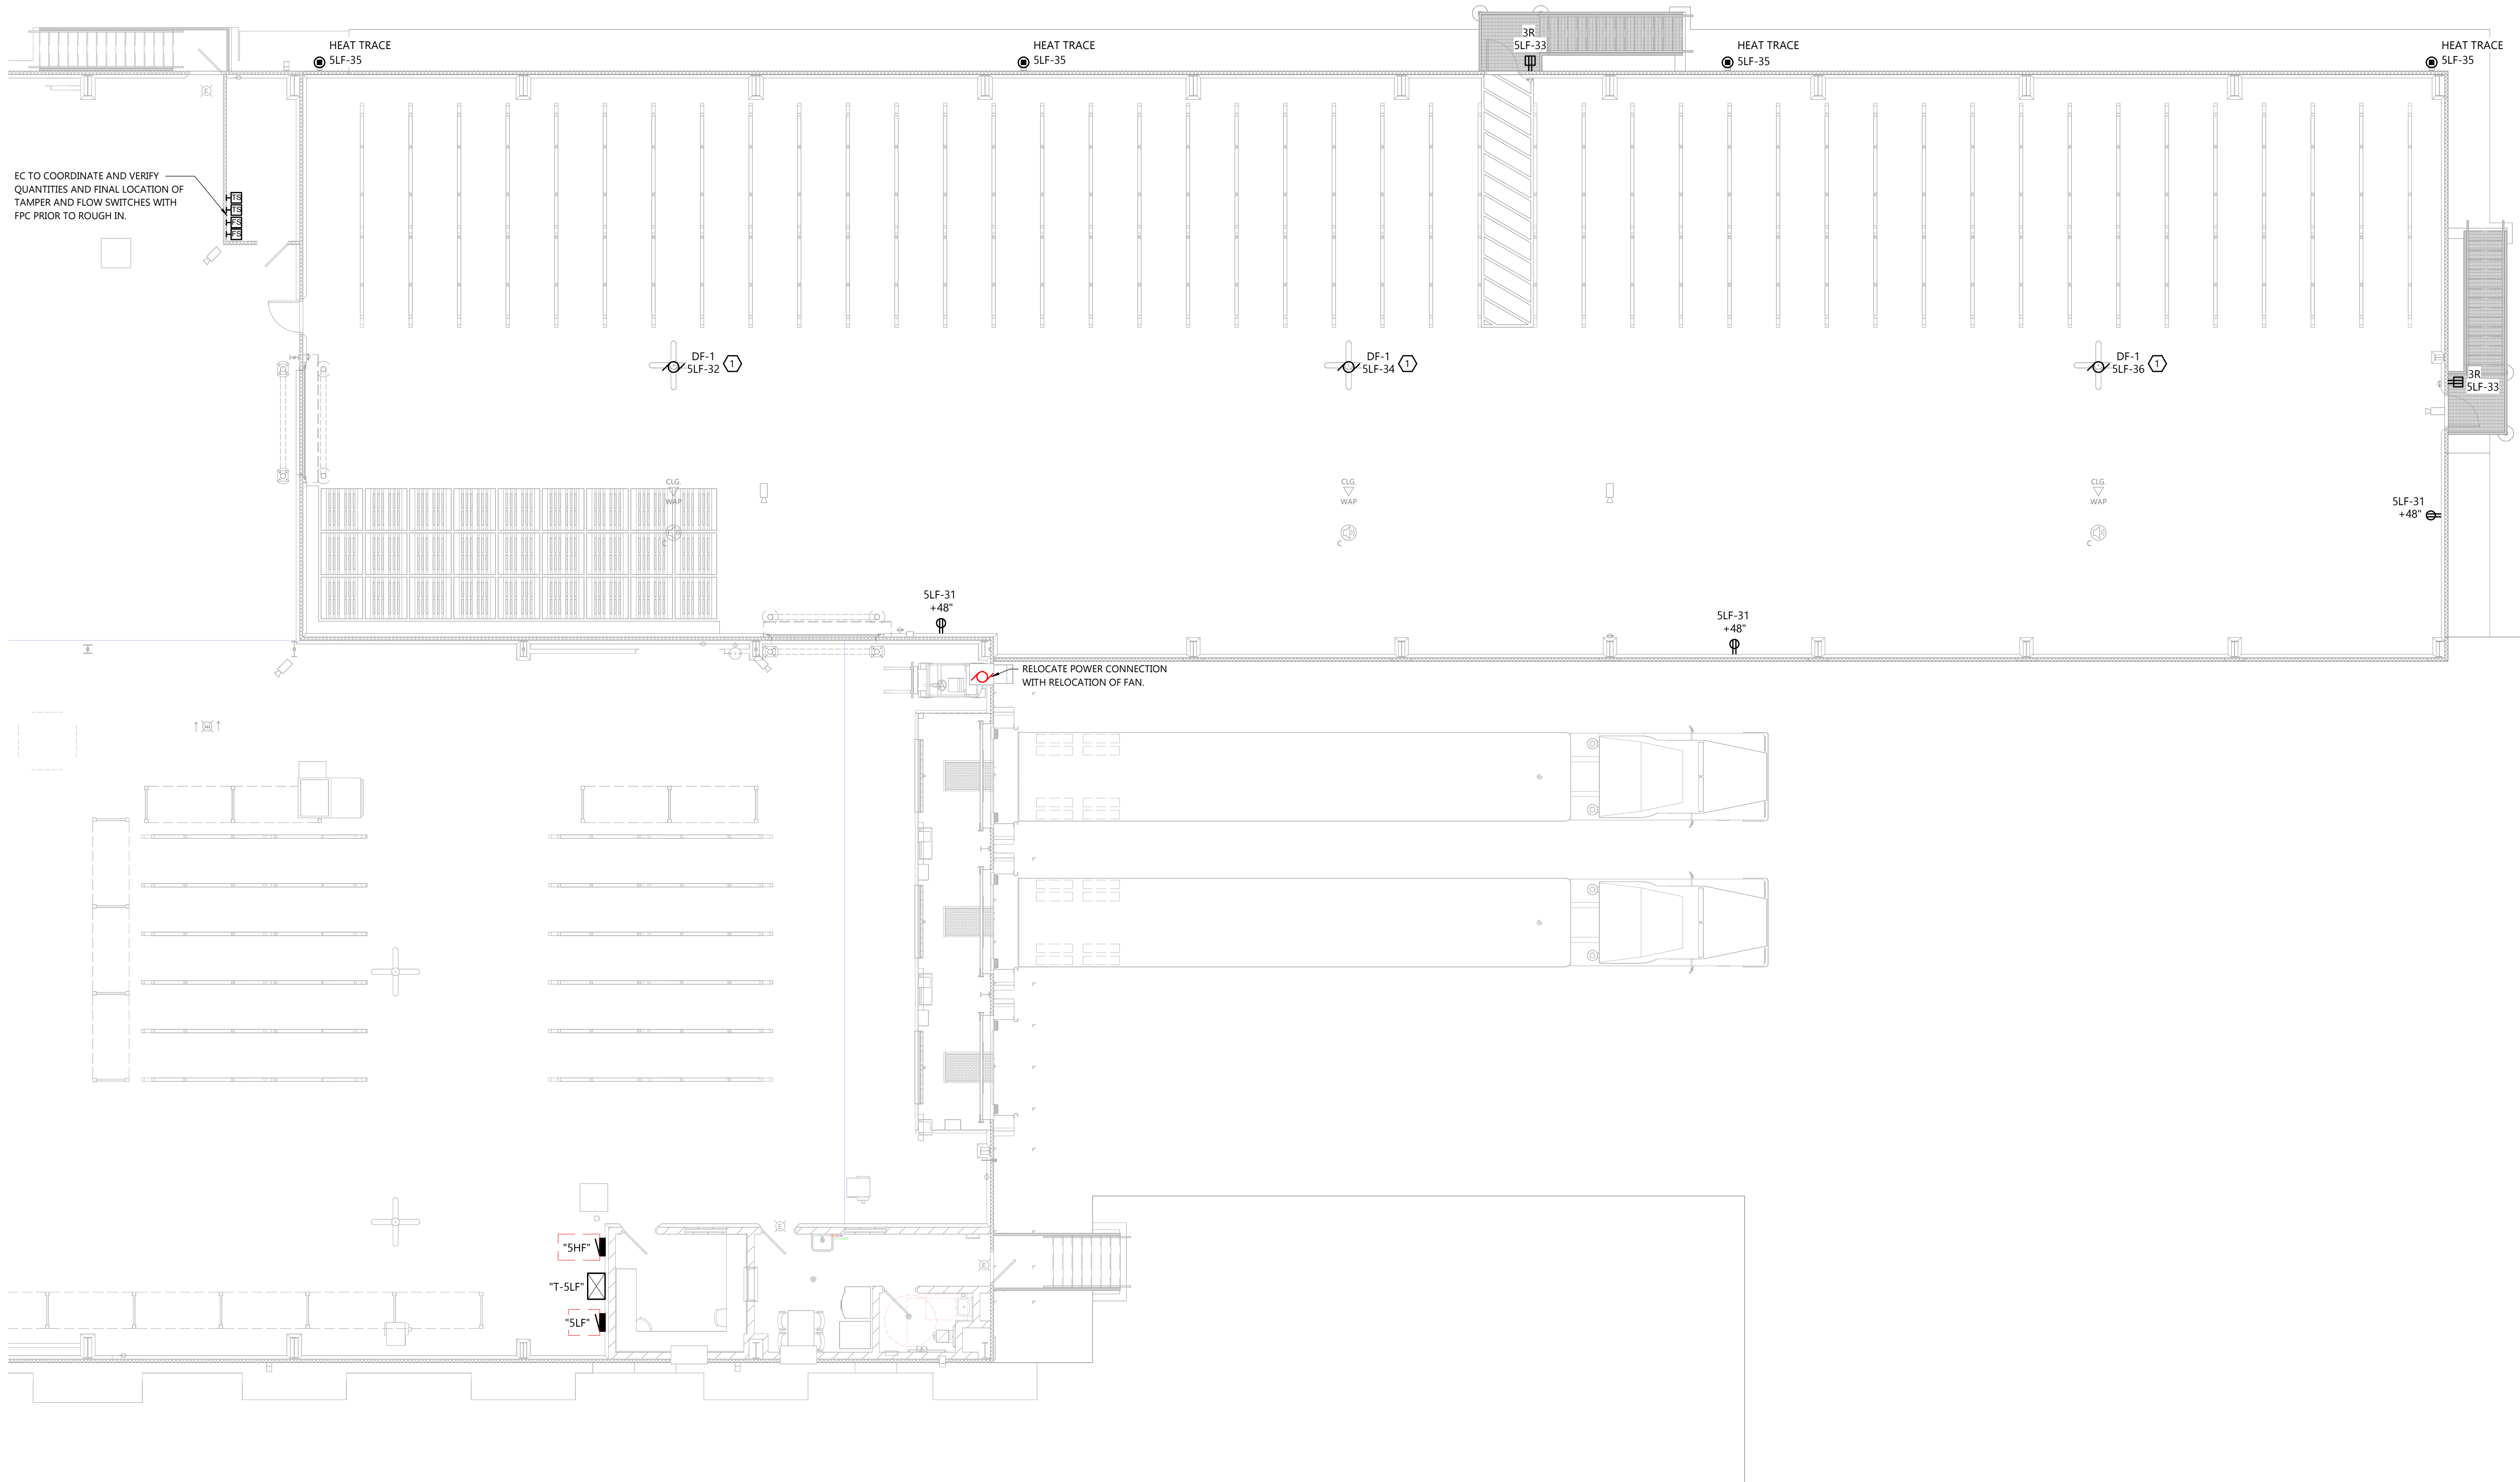

FIRST FLOOR PLAN - AREA "A" - POWER

SCALE: 1/8" = 1'-0"
0' 8' 16'

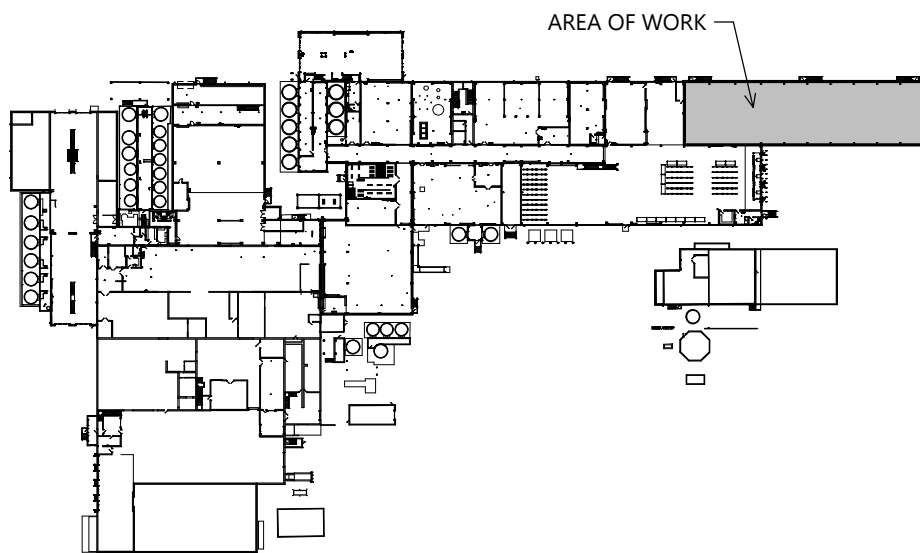

KEY PLAN

ELECTRICAL FIRST FLOOR PLAN - AREA 'A' - POWER

NOT FOR CONSTRUCTION



Always a Better Plan
100 Camelot Drive
Fond du Lac, WI 54935
920-926-9800
excelengineer.com

PROJECT INFORMATION

STORAGE WAREHOUSE EXPANSION FOR:
WEST POINT DAIRY PRODUCTS
570 NORTH 500 WEST • HYRUM, UT 84319

PROFESSIONAL SEAL

SHEET DATES

ISSUED FOR BUDGET
IFB APR. 17, 2026

JOB NUMBER
250429500

SHEET NUMBER

E1.1S

GENERAL NOTES

- VERIFY ALL EXPOSED CONDUIT ROUTING WITH ARCHITECT/ENGINEER WHERE CONDUIT IS EXPOSED IN FINISHED ROOMS.
- DETAIL REFERENCES ON PLANS ARE TO AID THE CONTRACTOR IN IDENTIFYING THE APPLICABLE DETAIL. NOT ALL DETAILS, OR INSTANCES OF DETAILS, ARE REFERENCES ON PLANS. CONTRACTOR IS RESPONSIBLE TO REVIEW AND COMPLY WITH ALL APPLICABLE DETAILS WHETHER OR NOT REFERENCED ON PLANS.
- ALL CONDUITS TO ISLAND CABINETS AND TABLES SHALL BE UNDERGROUND.
- PENETRATE MASONRY WALL PER STRUCTURAL DRAWINGS. PENETRATIONS NOT PERMITTED THROUGH MARKED GROUTED/REINFORCED MASONRY AND SHALL NOT BE MODIFIED WITHOUT WRITTEN APPROVAL FROM STRUCTURAL ENGINEER.
- ALL ITEMS OR DEVICES SHOWN "DARKER" ARE NEW LOW VOLTAGE DEVICES. ALL ITEMS OR DEVICES SHOWN "LIGHTER" ARE POWER DEVICES. POWER DEVICES ARE SHOWN FOR REFERENCE ONLY. REFER TO POWER SHEETS FOR MORE INFORMATION.

KEYNOTES

- ALL KEYNOTES MAY NOT APPEAR ON THIS SHEET.
- ① PROVIDE DATA OUTLET WITH DEDICATED CAT 6 CABLE IN RACEWAY FROM LOCAL IDF FOR WIRELESS ACCESS POINT. COORDINATE WIRELESS ACCESS POINT LOCATION WITH OWNERS. EQUIPMENT PROVIDER FOR OPTIMAL PERFORMANCE.


SYSTEMS COLOR LEGEND

- FIRE ALARM
- SECURITY/ACCESS CONTROL
- AUDIO/VIDEO
- NETWORK (IT)
- PROCESS NETWORK (OT)



FIRST FLOOR PLAN - AREA "A" - SYSTEMS

SCALE: 1/8" = 1'-0"
0' 8' 16'

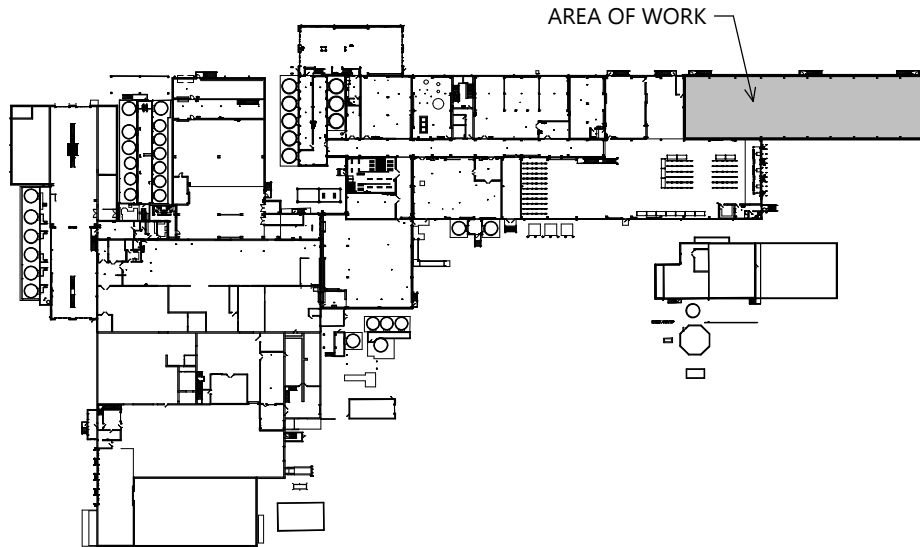


KEY PLAN

ELECTRICAL FIRST FLOOR PLAN - AREA 'A' - SYSTEMS

NOT FOR CONSTRUCTION

C:\Users\jdh\OneDrive\Documents\24042900_ELEC_Cover\2025_0404\250404E1.3.dwg
4/7/2025 10:47:46 AM

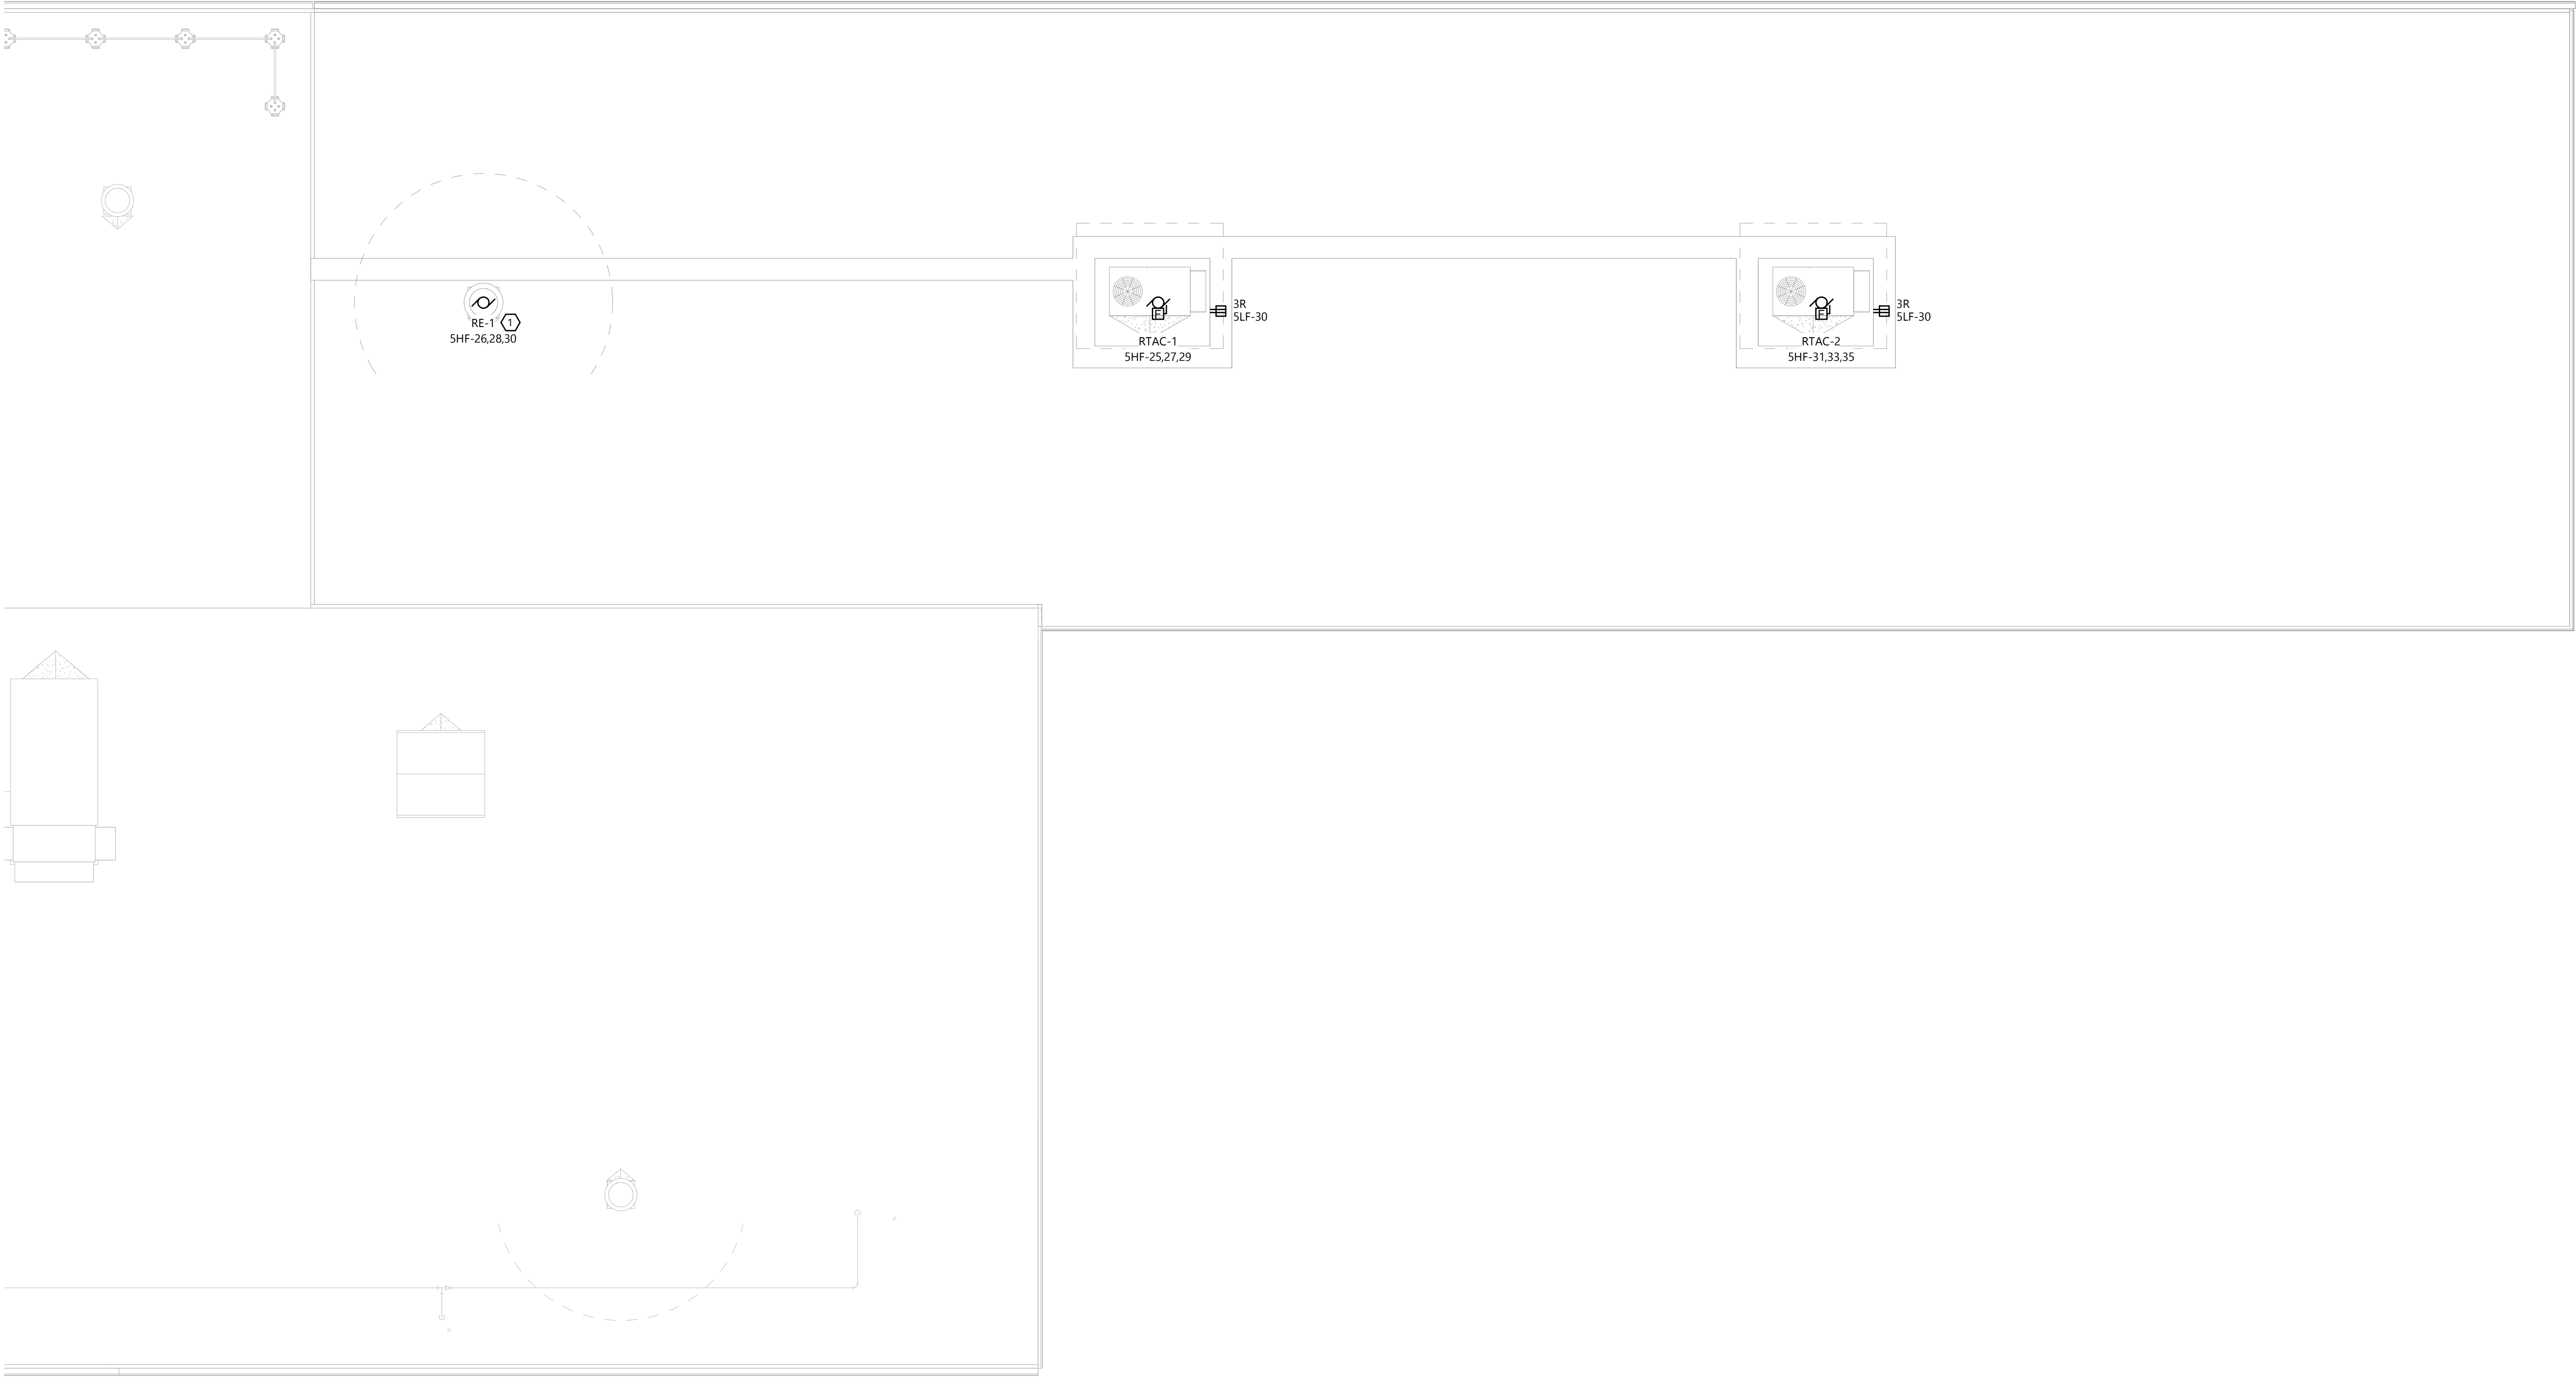

ROOF PLAN - AREA "A" - POWER
SCALE: 1/8" = 1'-0"
0' 8' 16'

GENERAL NOTES

- VERIFY ALL EXPOSED CONDUIT ROUTING WITH ARCHITECT/ENGINEER WHERE CONDUIT IS EXPOSED IN FINISHED ROOMS.
- EXTERIOR RECEPTACLES SHALL BE GFI TYPE. PROVIDE PASS & SEYMOUR SERIES "WE LUC" OR EQUIVALENT COVER. (PER NEC 406.8(B) AND AHJ). COLOR SHALL BE SELECTED BY ARCHITECT.
- SEE SHEET E4.0 FOR BRANCH CIRCUIT FEEDER SIZES.
- DEVICE LOCATIONS MAY BE DISTORTED FOR CLARITY. LOCATE DEVICES SYMMETRICALLY WITH THE ARCHITECTURAL ELEMENTS.
- SEE HVAC AND PLUMBING PLANS FOR LOCATIONS OF HEATING, VENTILATING, AIR CONDITIONING AND PLUMBING EQUIPMENT. DO NOT REFERENCE ELECTRICAL DRAWINGS FOR EXACT LOCATION.

KEYNOTES

- ALL KEYNOTES MAY NOT APPEAR ON THIS SHEET.
- ① EC SHALL WIRE FROM AUXILIARY CONTACT AT DISCONNECT TO SHUT DOWN VFD WHEN DISCONNECT IS ENGAGED. EC SHALL PROVIDE AUX CONTACT AT DISCONNECT IF EC IS PROVIDING DISCONNECT.

EXCEL
Always a Better Plan
100 Camelot Drive
Fond du Lac, WI 54935
920-926-9800
excelengineer.com

PROJECT INFORMATION

STORAGE WAREHOUSE EXPANSION FOR:
WEST POINT DAIRY PRODUCTS
570 NORTH 500 WEST • HYRUM, UT 84319

PROFESSIONAL SEAL

SHEET DATES

ISSUED FOR BUDGET
IFB APR. 17, 2026

JOB NUMBER

250429500

SHEET NUMBER

E1.3



Always a Better Plan

100 Camelot Drive
Fond du Lac, WI 54935
920-926-9800
excelengineer.com

PROJECT INFORMATION

STORAGE WAREHOUSE EXPANSION FOR:
WEST POINT DAIRY PRODUCTS
570 NORTH 500 WEST • HYRUM, UT 84319

PROFESSIONAL SEAL

SHEET DATES

ISSUED FOR BUDGET

IFB APR. 17, 2026

SHEET NUMBER

E4.0

PANELBOARD: 5HF

LOCATION:

SUPPLY FROM:

MOUNTING: SURFACE

ENCLOSURE: NEMA 12

VOLTS: 480/277 WYE

PHASES: 3

WIRES: 4

A.I.C. RATING: 65,000

MAINS TYPE: MLO

BUS RATING: 400A

MCB RATING: -

NOTES:

SEE BRANCH CIRCUIT FEEDER SCHEDULE FOR FEEDER DESIGNATIONS.

EXISTING PANEL.

EXISTING BREAKERS ARE SHOWN AS HALF-TONED

CKT	CIRCUIT DESCRIPTION	TRIP	POLES	A	B	C	POLES	TRIP	CIRCUIT DESCRIPTION	CKT
1	MOTOR - DOCK 141 DOCK EQUIPMENT	--	--	3			3	--	MOTOR - DOCK 141 QHD	2
3	--	--	--	--	--	--	--	--	--	4
5	--	--	--	--	--	--	--	--	--	6
7	MOTOR - DOCK 141 DOCK EQUIPMENT	--	--	3			3	--	MOTOR - DOCK 141 QHD	8
9	--	--	--	--	--	--	--	--	--	10
11	--	--	--	--	--	--	--	--	--	12
13	MOTOR - DOCK 141 DOCK EQUIPMENT	--	--	3			3	--	MOTOR - DOCK 141 QHD	14
15	--	--	--	--	--	--	--	--	--	16
17	--	--	--	--	--	--	--	--	--	18
19	T-SLF	--	--	3			1	--	LTG - EXTERIOR DOCK LTG	20
21	--	--	--	--	--	--	1	--	LTG - SOUTH SITE LIGHT	22
23	--	--	--	--	--	--	1	--	LTG - SOUTH EAST SITE LIGHTING	24
25	MOTOR - RTAC-1	25 A	3				3	15 A	MOTOR - ROOF EXHAUST (RE-1)	26
27	--	--	--	--	--	--	--	--	--	28
29	--	--	--	--	--	--	--	--	--	30
31	MOTOR - RTAC-2	25 A	3				--	--	--	32
33	--	--	--	--	--	--	--	--	--	34
35	--	--	--	--	--	--	--	--	--	36
37	--	--	--	--	--	--	--	--	--	38
39	--	--	--	--	--	--	--	--	--	40
41	--	--	--	--	--	--	--	--	--	42

PANELBOARD: 5LF

LOCATION:

SUPPLY FROM:

MOUNTING: SURFACE

ENCLOSURE: NEMA 12

VOLTS: 120/208 WYE

PHASES: 3

WIRES: 4

A.I.C. RATING: 10,000

MAINS TYPE: MCB

BUS RATING: 225A

MCB RATING: 225A

NOTES:

SEE BRANCH CIRCUIT FEEDER SCHEDULE FOR FEEDER DESIGNATIONS.

EXISTING PANEL

EXISTING BREAKERS ARE SHOWN AS HALF-TONED

CKT	CIRCUIT DESCRIPTION	TRIP	POLES	A	B	C	POLES	TRIP	CIRCUIT DESCRIPTION	CKT
1	REC - BATTERY CHARGER 145	--	--	2			1	--	REC - DOCK 141	2
3		--	--				1	--	REC - SP-1	4
5	REC - SHIP 142	--	--	1			1	--	REC - DOCK 141	6
7	REC - TRUCKERS 143	--	--	1			1	--	REC - SHIP 142	8
9	REC - TRUCKERS 143 VENDING MACHINE	--	--	1			1	--	REC - EAST EXTERIOR	10
11	REC - HALLWAY	--	--	1			1	--	REC - TRUCKER 143 VENDING MACHINE	12
13	REC - SP-1	--	--	1			1	--	REC - 2HR ELEVATOR 121	14
15	MOTOR - GUH -6	--	--	1			1	--	MOTOR - JF-2	16
17	ELECTRIC HEAT - EWH-1	--	--	2			1	--	MOTOR - GUH-7	18
19		--	--				2	--	ELECTRIC HEAT - PTAC -1	20
21	ELETRIC HEAT - PTAC -1	--	--	2			--	--		22
23		--	--				2	--	ELECTRIC HEAT - EWH-2	24
25	MOTOR - DF-1	--	--	1			--	--		26
27	SPACE	--	--	1			1	--	MOTOR - DF-1	28
29	MOTOR - EF-3	--	--	1			1	20 A	REC - ROOF RECEPTACLE	30
31	REC - SOUTH WALL (WAREHOUSE)	20 A	1				1	20 A	MOTOR - CEILING FAN (LEFT)	32
33	REC - OUTSIDE (WAREHOUSE)	20 A	1				1	20 A	MOTOR - CEILING FAN (CENTER)	34
35	ELEC HEAT - HEAT TRACE	GE	20 A	1			1	20 A	MOTOR - CEILING FAN (RIGHT)	36
37										38
39										40
41										42
43										44
45										46
47										48
49										50
51										52
53										54
55										56
57										58
59										60
61										62
63										64
65										66
67										68
69										70
71										72
73										74
75										76
77										78
79										80
81										82
83										84

PANELBOARD: 5HA											
LOCATION: EXIST. MCC 8-1-16				VOLTS: 480/277 WYE				A.I.C. RATING: 65,000			
SUPPLY FROM:				PHASES: 3				MAINS TYPE: MLO			
MOUNTING: RECESSED				WIRES: 4				BUS RATING: 400A			
ENCLOSURE: NEMA 12								MCB RATING: -			
NOTES: SEE BRANCH CIRCUIT FEEDER SCHEDULE FOR FEEDER DESIGNATIONS. EXISTING PANEL EXISTING BREAKERS ARE SHOWN AS HALF-TONED											
CKT	CIRCUIT DESCRIPTION	TRIP	POLES	A	B	C	POLES	TRIP	CIRCUIT DESCRIPTION	CKT	
1	T-3LA	--	--	3			3	--	MOTOR - RTAC-1	2	
3	--	--	--	--	--	--	--	--	--	4	
5	--	--	--	--	--	--	--	--	--	6	
7	LTG	--	--	1			3	--	MOTOR - RTAC-2	8	
9	LTG	--	--	1			--	--	--	10	
11	LTG	--	--	1			1	--	--	12	
13	LTG	--	--	1			3	--	MOTOR - RTAC-3	14	
15	LTG	--	--	1			--	--	--	16	
17	LTG	--	--	1			--	--	--	18	
19	LTG	--	--	1			1	--	SPACE	20	
21	LTG	--	--	1			1	--	SPACE	22	
23	LTG	--	--	1			1	--	SPACE	24	
25	LTG	--	--	1			1	--	SPACE	26	
27	LTG	--	--	1			1	--	SPACE	28	
29	LTG	--	--	1			1	--	SPACE	30	
31	LTG	--	--	1			1	--	SPACE	32	
33	LTG	--	--	1			1	--	SPACE	34	
35	LTG	--	--	1			1	--	SPACE	36	
37	LTG	--	--	1			1	--	SPACE	38	
39	LTG	--	--	1			1	--	SPACE	40	
41	LTG	--	--	1			1	--	SPACE	42	
43	LTG	--	--	1			1	--	LTG	44	
45	LTG	--	--	1			1	--	LTG	46	
47	LTG	--	--	1			3	--	OTHER - DRY2-CP-3170	48	
49	LTG - WALL PACK WAREHOUSE	20 A	1				--	--	--	50	
51	LTG - HIGH BAY WAREHOUSE	20 A	1				--	--	--	52	
53										54	
55										56	
57										58	
59										60	
61										62	
63										64	
65										66	
67										68	
69										70	
71										72	
73										74	
75										76	
77										78	
79										80	
81										82	
83										84	

BRANCH CIRCUIT FEEDER SCHEDULE		
AMP / POLE	CONDUIT SIZE	CONDUCTORS & GROUNDING CONDUCTOR SIZES
15A/1P OR 15A/2P	1/2"	(2) #12 & #12 GND
20A/1P OR 20A/2P	1/2"	(2) #12 & #12 GND
15A/3P OR 20A/3P	1/2"	(3) #12 & #12 GND
25A/1P OR 25A/2P	3/4"	(2) #10 & #10 GND
30A/1P OR 30A/2P	3/4"	(2) #10 & #10 GND
25A/3P OR 30A/3P	3/4"	(3) #10 & #10 GND
35A/1P OR 35A/2P	3/4"	(2) #8 & #10 GND
40A/1P OR 40A/2P	3/4"	(2) #8 & #10 GND
35A/3P OR 40A/3P	3/4"	(3) #8 & #10 GND
45A/1P OR 45A/2P	1"	(2) #6 & #10 GND
45A/3P OR 50A/3P	1"	(3) #6 & #10 GND
50A/1P OR 50A/2P	1"	(2) #6 & #10 GND
60A/1P OR 60A/2P	1"	(2) #4 & #8 GND
60A/3P	1-1/4"	(3) #4 & #8 GND
70A/3P OR 80A/3P	1-1/4"	(3) #4 & #8 GND
90A/3P	1-1/4"	(3) #3 & #8 GND
100A/3P OR 110A/3P	1-1/2"	(3) #2 & #6 GND
125A/3P	1-1/2"	(3) #1 & #6 GND
* PROVIDE BRANCH CIRCUIT FEEDERS AS NOTED ABOVE, UNLESS NOTED OTHERWISE		

PANEL SCHEDULE KEY					
CIRCUIT NUMBER	DESCRIPTION	SUFFIX	BREAKER AMP.	POLES	
37	RECEPTACLE - LOBBY AREA - WEST	x	20A	1	
39	MOTOR - ROOM AIR CONDITIONER	x	30A	2	
41	--	--	--	--	
PANEL SCHEDULE SUFFIX LEGEND					
A	ARC-FAULT BREAKER				
G	5mA GFCI BREAKER (PERSONAL PROTECTION)				
GE	30mA GFCI BREAKER (EQUIPMENT PROTECTION)				
AG	COMBINATION 5mA GFCI AND ARC-FAULT BREAKER				
ST	SHUNT TRIP BREAKER				
R	RELAY CONTROLLED CIRCUIT				

EXISTING PANEL SCHEDULE NOTES:
- ALL CIRCUITS SHOWN "LIGHTER" ARE EXISTING TO REMAIN.

MODIFIED PANEL SCHEDULE NOTES:
(1) UTILIZE EXISTING CIRCUIT BREAKER TO SERVE NEW LOAD.
(2) PROVIDE NEW CIRCUIT BREAKER TO SERVE NEW LOAD.
NEW BREAKER SHALL MATCH EXISTING PANEL STYLE AND AIC RATING.



Always a Better Plan
100 Camelot Drive
Fond du Lac, WI 54935
920-926-9800
excelengineer.com

PROJECT INFORMATION

STORAGE WAREHOUSE EXPANSION FOR:
WEST POINT DAIRY PRODUCTS
570 NORTH 500 WEST • HYRUM, UT 84319

PROFESSIONAL SEAL

NOT FOR CONSTRUCTION

SHEET DATES

ISSUED FOR BUDGET

IFB APR. 17, 2026

JOB NUMBER

250429500


SHEET NUMBER

E6.0

LIGHTING FIXTURE SCHEDULE

NOTES: • FIXTURE MODEL NUMBER MAY NOT REFLECT ALL MOUNTING HARDWARE. ELECTRICAL CONTRACTOR SHALL PROVIDE ALL NECESSARY MOUNTING EQUIPMENT, LENSES, STEMS. • REFER TO PANEL SCHEDULE SHEETS FOR EMERGENCY LIGHTING BATTERY INVERTER REQUIREMENTS.		LED REQUIREMENTS:			REMARKS: (1) PROVIDE UL924 LISTED EMERGENCY DRIVER TO LIGHT LED FIXTURE DURING LOSS OF NORMAL POWER.			
TYPE	DESCRIPTION	VOLTAGE	LIGHT SOURCE	CCT	FIXTURE WATTS	MIN. LUMENS	MANUFACTURER SERIES - BASIS OF DESIGN	REMARKS
INTERIOR								
H83	HIGHBAY LED - WIDE DISTRIBUTION - DIMMABLE FROSTED LENS	277 V	LED	4,000K	193 VA	30,000	METALUX / HBLED SERIES	
H83E	HIGHBAY LED - WIDE DISTRIBUTION - DIMMABLE FROSTED LENS - 14W 120V-277V EMERGENCY BATTERY PACK INSTALLED	277 V	LED	4,000K	193 VA	30,000	METALUX / HBLED SERIES	
EXTERIOR								
WP26	EXTERIOR 26W LED WALL PACK	277 V	LED	4,000K	20 VA	1,887	ILP / SLIM PROFILE WALL PACK	1
EMERGENCY								
X1	SINGLE FACE POLYCARBONATE EXIT - W/ BATTERY - RED LETTERS - SELF-DIAGNOSTICS	277 V	LED	-	5 VA	-	SURE-LITES / LPX SERIES	
X2	DOUBLE FACE POLYCARBONATE EXIT - W/ BATTERY - RED LETTERS - SELF-DIAGNOSTICS	277 V	LED	-	5 VA	-	SURE-LITES / LPX SERIES	
XE	NEMA 4X SINGLE FACE EXIT - W/ BATTERY - RED LETTERS - WHITE HOUSING - SELF-DIAGNOSTICS	277 V	LED	-	5 VA	-	SURE-LITES / LUX SERIES	

LIGHTING FIXTURE LEGEND

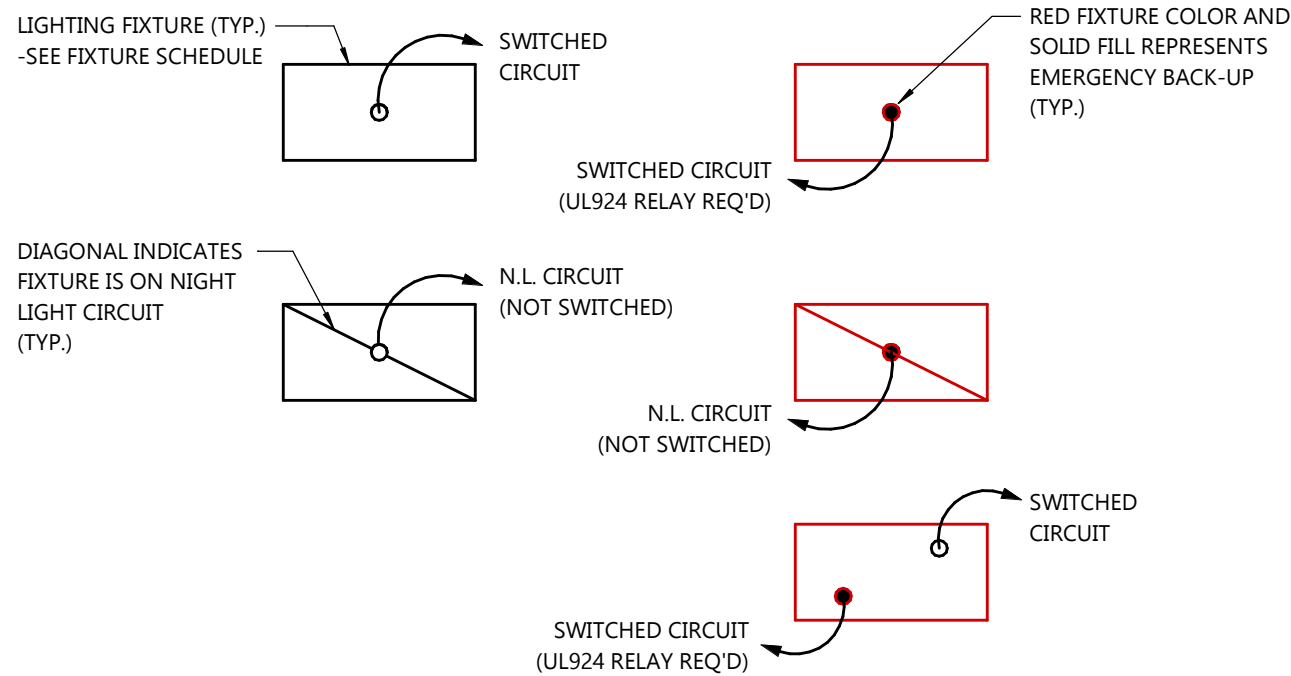

NOTE:
ADDITIONAL DRIVERS SHALL NOT BE NEEDED FOR EMERGENCY FIXTURES.
REFER TO "EMERGENCY LIGHTING CONTROL DETAIL" FOR MORE INFORMATION.

ELECTRICAL LIGHT FIXTURE SCHEDULE